



RENDEZVOUS ENGINEERING, P.C.

Civil Engineers and Planners in Wyoming and Idaho

RECEIVED

APR 09 2008

DEPARTMENT OF
WATER RESOURCES

Rendezvous Project No: 04-003

April 5, 2008

Ms. Deborah Gibson
Water Allocation Bureau
Idaho Department of Water Resources
P.O. Box 83720
Boise, Idaho 83720-0098

RE: Lapsed Permit No. 22-13178 / Teton Springs

Dear Ms. Gibson:

Attached is a completed Proof of Beneficial Use form (Form No. 217) and filing fee submitted on behalf of Teton Springs, LLC for the reinstatement of the above referenced groundwater permit.

As you are aware, this permit was originally filed for domestic use to serve up to 710 households for approximately 1.11 cfs (500 gpm). Two wells were drilled in early 2000 and late 2001 for the project, which together produce about 400 gpm (0.89 cfs). The flow on the wells was reduced slightly from the original permit to minimize drawdown and optimize operations. Flow meters have been installed on both wells as noted on the form.

Currently, the entire distribution system has been completed with service connections to about 736 units. About 200 units have been constructed or are in the process of being constructed as of this date. The attached record drawings provide detailed information on the distribution system and areas of use for this project.

The record drawings will also serve to show that use was taking place during the period of July 19, 2001 and August 1, 2006. The first set of record drawings was submitted in 2003. The attached correspondence with the DEQ helps to document the fact that the system was constructed as the dialogue deals with comments and questions on the completed construction. The final set of record drawings was submitted to the DEQ in the fall of 2007. A copy of these 2007 plans is also enclosed.

I am also attaching a letter from the DEQ dated October 27, 2006 which discusses a field visit made on September 19, 2006. Although this visit was after the date of August 1, 2006, the water facilities inspected at the time were clearly in place and in use for some time prior to the date of this inspection. Additional information may also be available from the DEQ regarding this.

Additional documentation in the form of dated construction photos, field reports and invoices for the payment for the utility work is also available. However, as we discussed on the phone, you were initially thought that the record drawings would provide reasonable documentation.

Please note that we as the engineers of record failed to file the original beneficial notice within the allotted time mostly out of a misunderstanding of the process in Idaho. This was the first large groundwater permit that we filed in the state and were not aware of the time requirements. Also, we were more familiar with a similar beneficial use in the State of Wyoming where notices are sent via certified mail to both the owner and engineer. We received information from the owner but were not aware of the specific deadline and potential lapse for the permit.

Thank you for your assistance with this matter and please call my cell phone (307-413-3052) or contact me via e-mail (rtablondi@aol.com) if you have questions or need additional information.

Sincerely,




Robert T. Ablondi,
Idaho P.E. 5994

Cc: Jon Pinardi, Teton Springs
Mike Potter, PC Development

Enclosures: Beneficial Use Form
Filing Fee \$100
DEQ Letter dated April 7, 2003
DEQ Letter dated October 27, 2007
Response Letter Dated May 19, 2003
Additional Response Letter Dated December 16, 2003
Record Drawings, 2003 (Water)
Record Drawings, 2007 (Water)



TETON SPRINGS ALL SEASON RESORT COMMUNITY

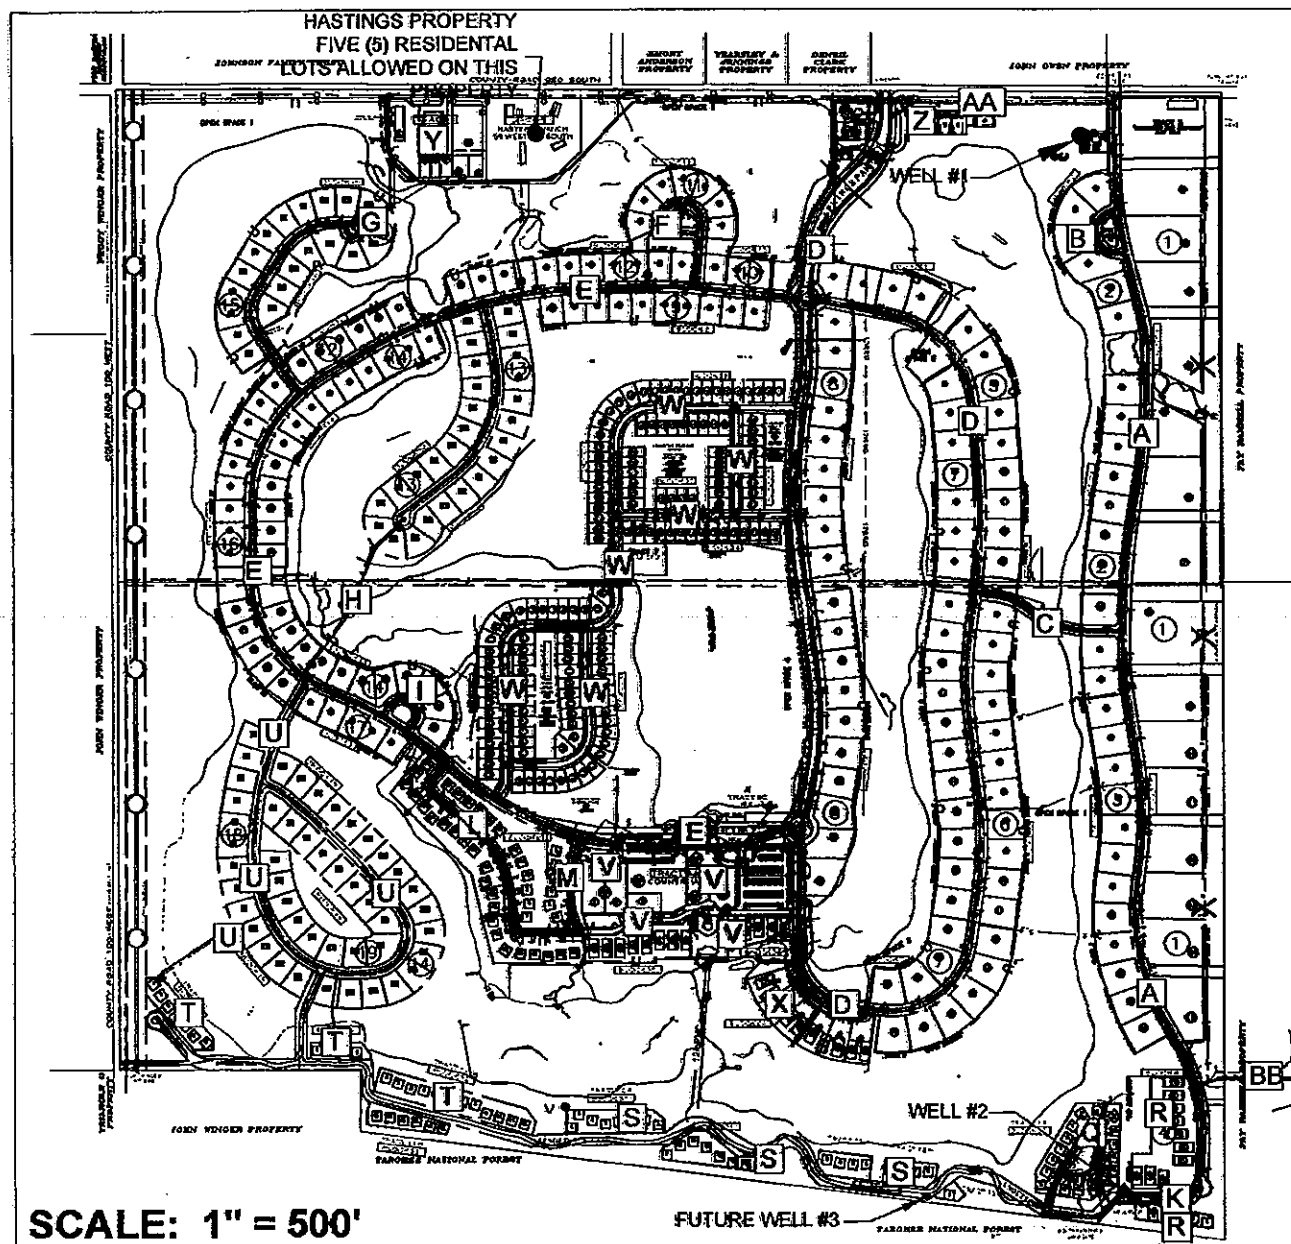

SHEET INDEX

ASBW1 WATER LINE PLAN/PROFILE SHEET INDEX

WATER LINE DESIGNATION	PLAN/PROFILE SHEETS
MAIN 'AA'	ASBW2, ASBW3
MAIN 'A'	ASBW4, ASBW5, ASBW6, ASBW7, ASBW8
MAIN 'B'	ASBW9
MAIN 'C'	ASBW10
MAIN 'D'	ASBW11, ASBW12, ASBW13, ASBW14,
MAIN 'D'	ASBW15, ASBW16, ASBW17, ASBW18
MAIN 'E'	ASBW19, ASBW20, ASBW21, ASBW22,
MAIN 'E'	ASBW23, ASBW24
MAIN 'F'	ASBW25
MAIN 'G'	ASBW26, ASBW27, ASBW28
MAIN 'H'	ASBW29
MAIN 'I'	ASBW30
MAIN 'K'	ASBW31
MAIN 'L'	ASBW32, ASBW33
MAIN 'M'	ASBW34
MAIN 'Q'	ASBW35
MAIN 'R'	ASBW36, ASBW37, ASBW38
MAIN 'S'	ASBW39, ASBW40, ASBW41
MAIN 'T'	ASBW42, ASBW43, ASBW44
MAIN 'T'	ASBW45, ASBW46, ASBW47
MAIN 'U'	ASBW48, ASBW49, ASBW50, ASBW51
MAIN 'V'	ASBW52, ASBW53, ASBW54
MAIN 'W'	ASBW55, ASBW56, ASBW57, ASBW58
MAIN 'W'	ASBW59, ASBW60, ASBW61
MAIN 'W'	ASBW62, ASBW63, ASBW64
MAIN 'W'	ASBW65, ASBW66
MAIN 'W'	ASBW67, ASBW68
MAIN 'X'	ASBW69, ASBW70
MAIN 'Y'	ASBW71, ASBW72
MAIN 'Z'	ASBW73
MAIN 'BB'	ASBW74, ASBW75
WELL HOUSE #1 & #2	ASBW76, ASBW77
WATER DETAILS	ASBW78, ASBW79, ASBW80
WATER TANK SITE PLAN	ASBW81, ASBW82
WATER TANK DETAILS	ASBW83
PITTSBURG TANK DWGS	1 - 22

WATER DISTRIBUTION SYSTEM RECORD DRAWINGS

PLANS & SPECIFICATIONS REVIEW

BY: WJH
Environmental Engineer

These plans and/or specifications have been reviewed for compliance with the Idaho Dept. of Environmental Quality regulations. This review does not relieve the owner, engineer, or contractor of their responsibility to design or construct these facilities in compliance with all current applicable state, federal, and local laws, rules, regulations, or ordinances.

Dated: 01/03/03
Plans and/or specifications must be resubmitted for review if construction is not initiated on or before.


LEGEND

WATER 4"	—
WATER 6"	—
WATER 8"	—
SANITARY SEWER	—
UNDERGROUND POWER	—
TEE	⊥
GATE VALVE	⊗
END CAP	⊥
BEND	⋈
FIRE HYDRANT	⊕
WATER SERVICE	⊕
SEWER SERVICE	⊕
SANITARY MANHOLE	⊕
STORM DRAIN MANHOLE	⊕

RECEIVED

DEC 17 2007

DEQ-IDAHO FALLS

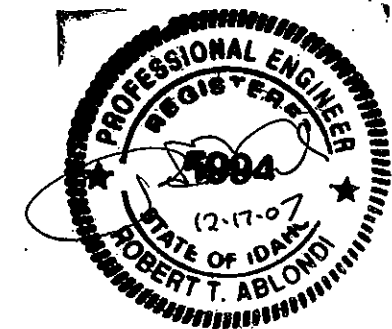

DRAWING TITLE:
AS BUILT WATER PLAN & PROFILE
SITE OVERVIEW

PROJECT TITLE:
TETON SPRINGS
RECORD DRAWINGS

PROJECT
NUMBER:
00-023
DRAWING
NUMBER:
ASBW1

Prepared By: JCO
Drawn By: JCO
Rev. Date: 10/07
Plot Info:
Title: Teton Springs All Season Resort Community
Date: 10/07/07

RENDEZVOUS ENGINEERING, P.C.
P.O. BOX 488 JACKSON, WYOMING 83001
25 SOUTH GROS VENTRE STREET
PHONE - 307.733.5252 FAX - 307.733.2234

TETON SPRINGS ALL SEASON RESORT COMMUNITY

Prepared By: EDD
Date: 2003
Rev. Date: 10/07
Pld Info:
Data:
Pld:
Pld:

RENDEZVOUS ENGINEERING, P.C.
P.O. BOX 4858 JACKSON, WYOMING 83001
25 SOUTH GROS VENTRE STREET
PHONE - 307.733.5252 FAX - 307.733.2334



DRAWING TITLE:
AS BUILT WATER PLAN & PROFILE
SITE OVERVIEW

PROJECT TITLE:
TETON SPRINGS
RECORD DRAWINGS

PROJECT
NUMBER:
00-023
DRAWING
NUMBER:
ASBW1

WATER DISTRIBUTION SYSTEM RECORD DRAWINGS



SHEET INDEX

ASBW1 WATER LINE PLAN/PROFILE SHEET INDEX


WATER LINE DESIGNATION	PLAN/PROFILE SHEETS
MAIN 'AA'	ASBW2, ASBW3
MAIN 'A'	ASBW4, ASBW5, ASBW6, ASBW7, ASBW8
MAIN 'B'	ASBW9
MAIN 'C'	ASBW10
MAIN 'D'	ASBW11, ASBW12, ASBW13, ASBW14,
MAIN 'D'	ASBW15, ASBW16, ASBW17, ASBW18
MAIN 'E'	ASBW19, ASBW20, ASBW21, ASBW22,
MAIN 'E'	ASBW23, ASBW24
MAIN 'F'	ASBW25
MAIN 'G'	ASBW26, ASBW27, ASBW28
MAIN 'H'	ASBW29
MAIN 'I'	ASBW30
MAIN 'K'	ASBW31
MAIN 'L'	ASBW32, ASBW33
MAIN 'M'	ASBW34
MAIN 'Q'	ASBW35
MAIN 'R'	ASBW36, ASBW37, ASBW38
MAIN 'S'	ASBW39, ASBW40, ASBW41
MAIN 'T'	ASBW42, ASBW43, ASBW44
MAIN 'T'	ASBW45, ASBW46, ASBW47
MAIN 'U'	ASBW48, ASBW49, ASBW50, ASBW51
MAIN 'V'	ASBW52, ASBW53, ASBW54
MAIN 'W'	ASBW55, ASBW56, ASBW57, ASBW58
MAIN 'W'	ASBW59, ASBW60, ASBW61
MAIN 'W'	ASBW62, ASBW63, ASBW64
MAIN 'W'	ASBW65, ASBW66
MAIN 'W'	ASBW67, ASBW68
MAIN 'X'	ASBW69, ASBW70
MAIN 'Y'	ASBW71, ASBW72
MAIN 'Z'	ASBW73
MAIN 'BB'	ASBW74, ASBW75
WELL HOUSE #1 & #2	ASBW76, ASBW77
WATER DETAILS	ASBW78, ASBW79, ASBW80
WATER TANK SITE PLAN	ASBW81, ASBW82
WATER TANK DETAILS	ASBW83
PITTSBURG TANK DWGS	1 - 22

LEGEND



WATER 4"	---
WATER 6"	---
WATER 8"	---
SANITARY SEWER	---
UNDERGROUND POWER	---
TEE	+
GATE VALVE	X
END CAP	T
BEND	1
FIRE HYDRANT	+
WATER SERVICE	+
SEWER SERVICE	+
SANITARY MANHOLE	SMH
STORM DRAIN MANHOLE	STORM

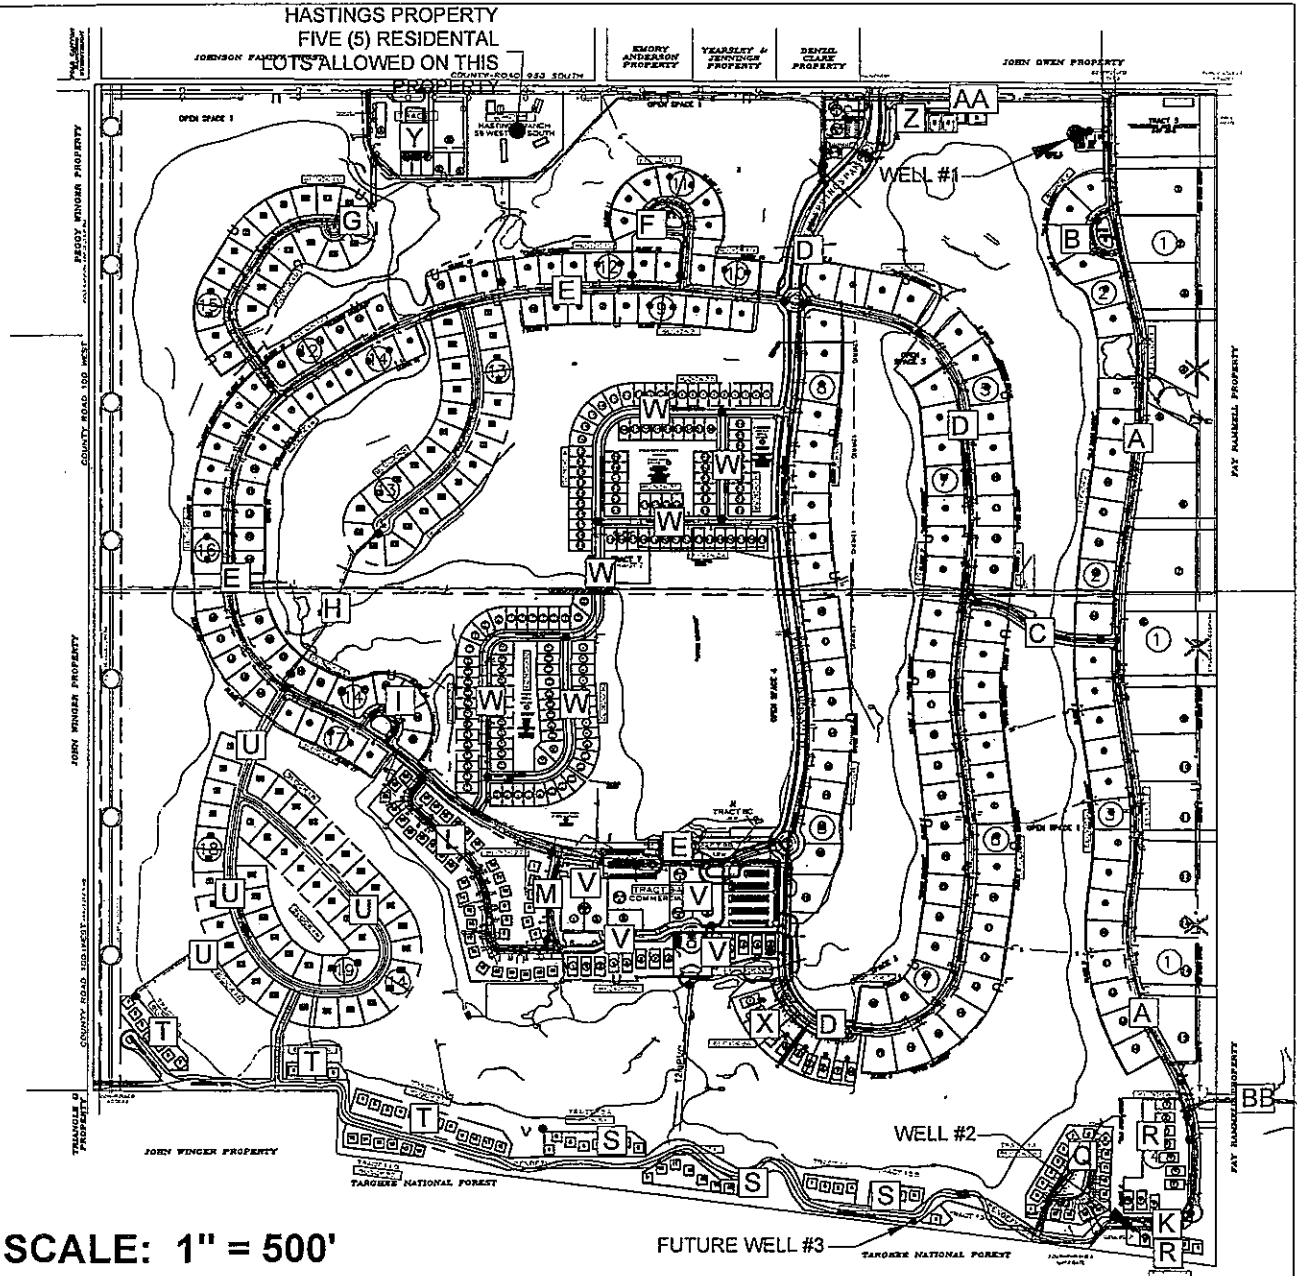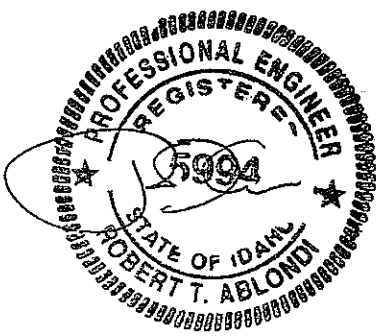

SCALE: 1" = 500'

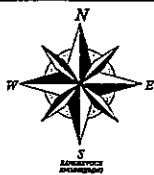

VICINITY MAP

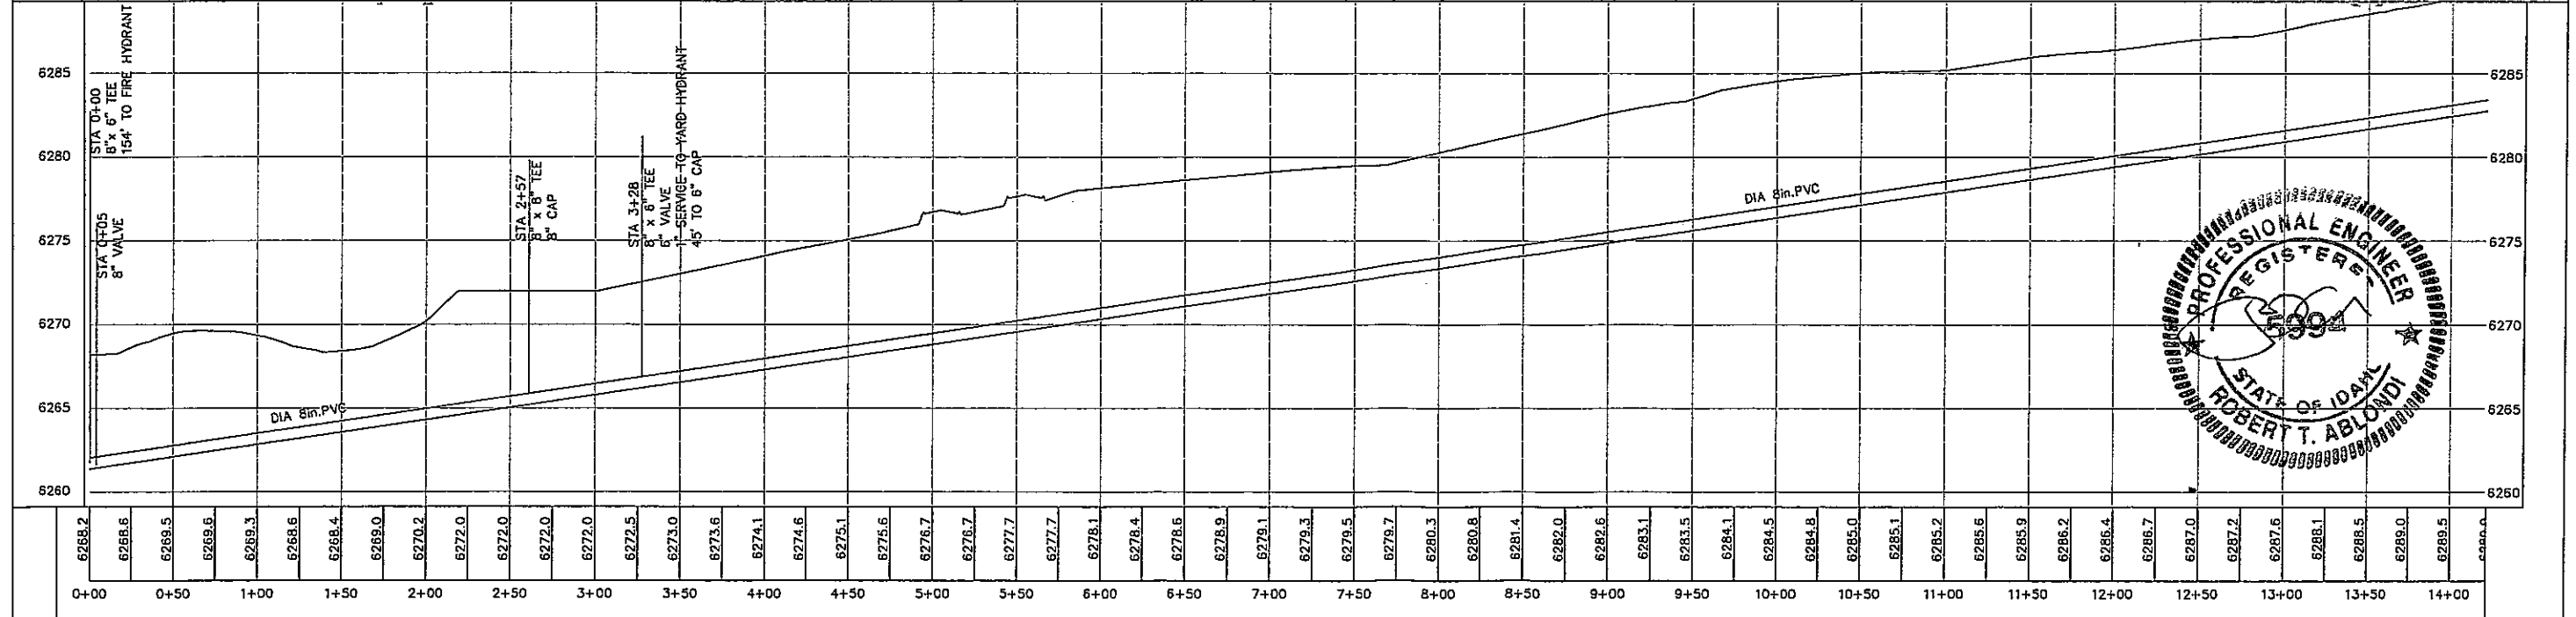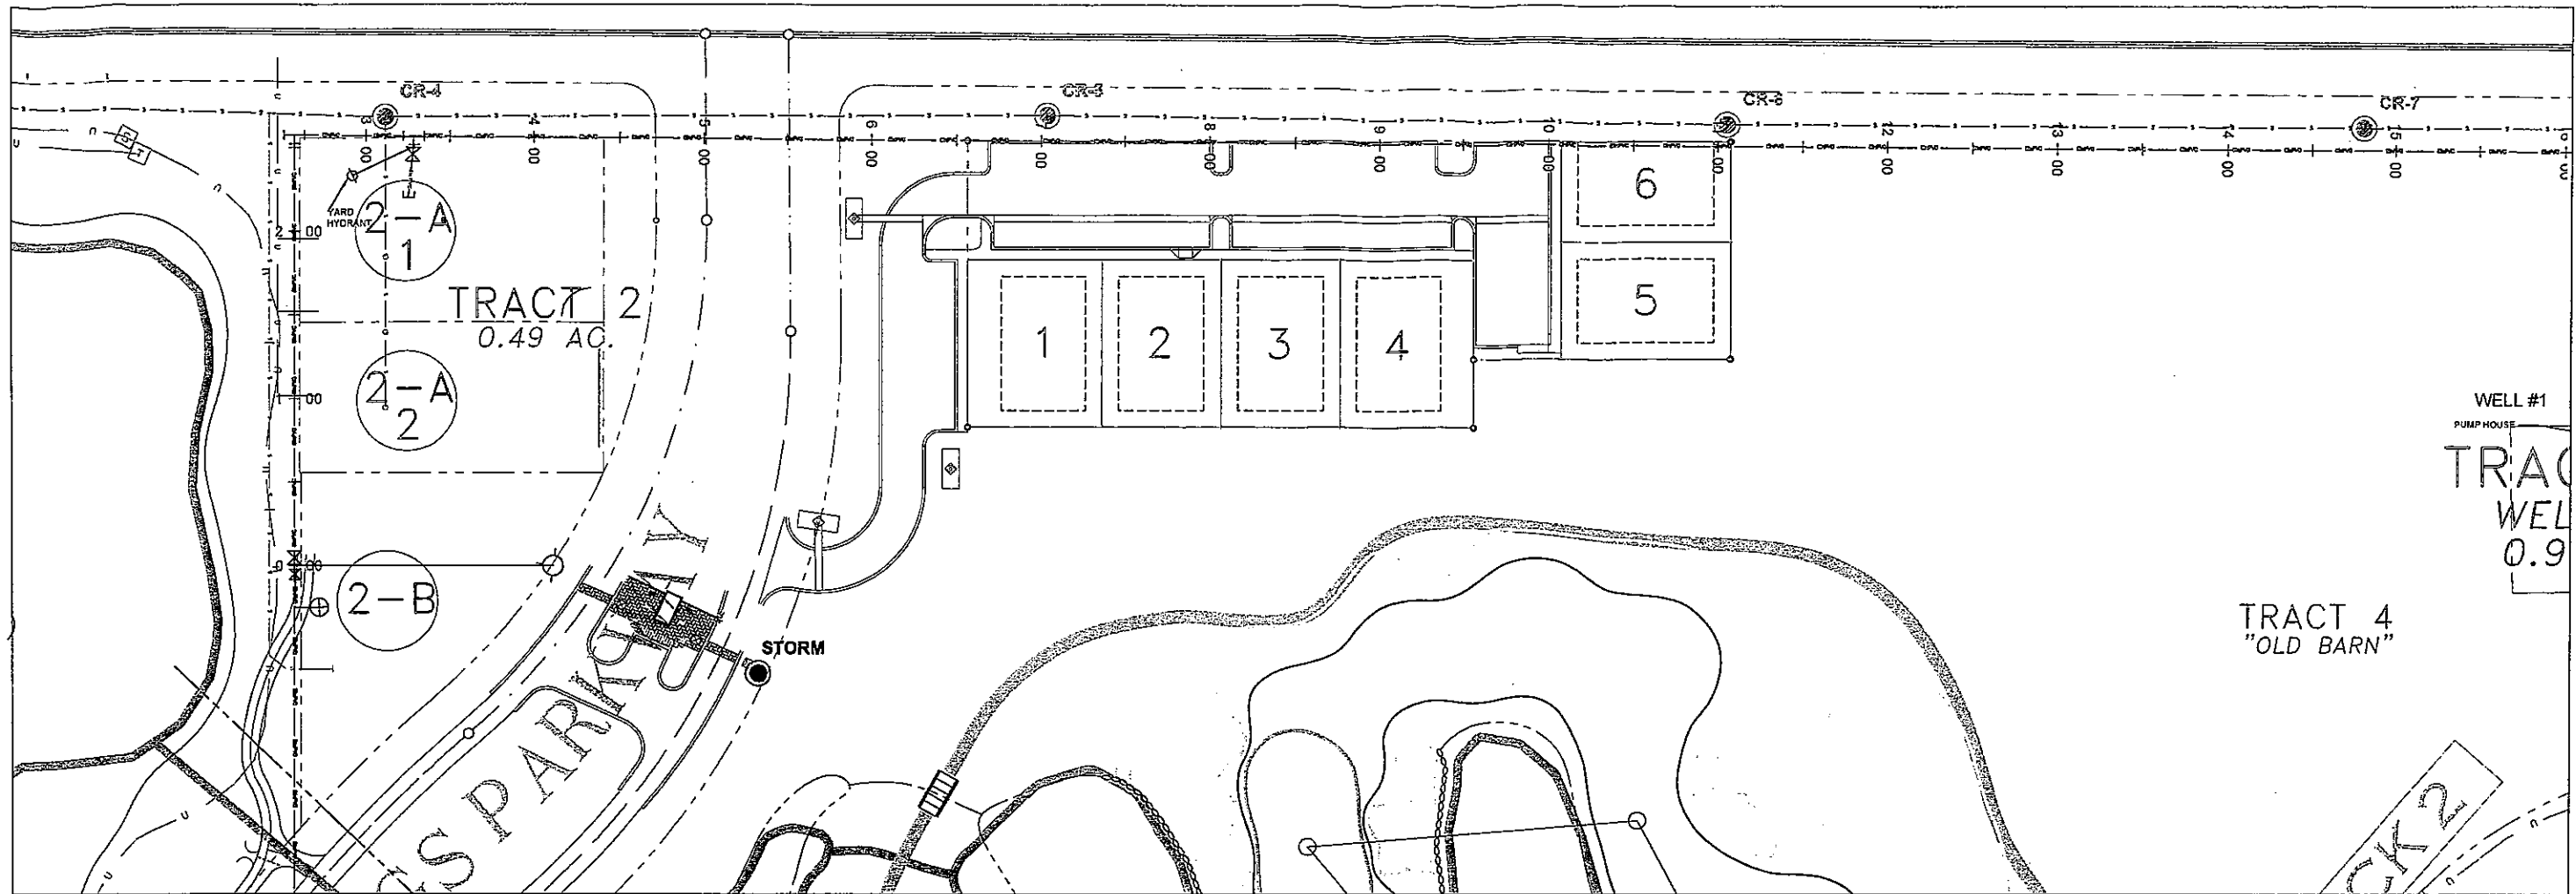

NOTES - THIS SHEET

GENERAL NOTES



Horizontal Scale: 1" = 50'
Vertical Scale: 1" = 5'

Prepared By: JKC
Date: 10/07
Rev. Date:
Rev. Date:
Plot Info:
Data: 10/07/07
Path: 10/07/07



RENDEZVOUS ENGINEERING, P.C.
P.O. BOX 4858 JACKSON, WYOMING 83001
PHONE - 307.733.5252 FAX - 307.733.2304

DRAWING TITLE:
AS BUILT WATER PLAN & PROFILE
WATER MAIN 'AA'
COUNTY ROAD 950 SOUTH

PROJECT TITLE:
RECORD DRAWINGS
TETON SPRINGS ALL
SEASONS RESORT COMMUNITY

PROJECT NUMBER:
00-023

DRAWING NUMBER:
ASBW2

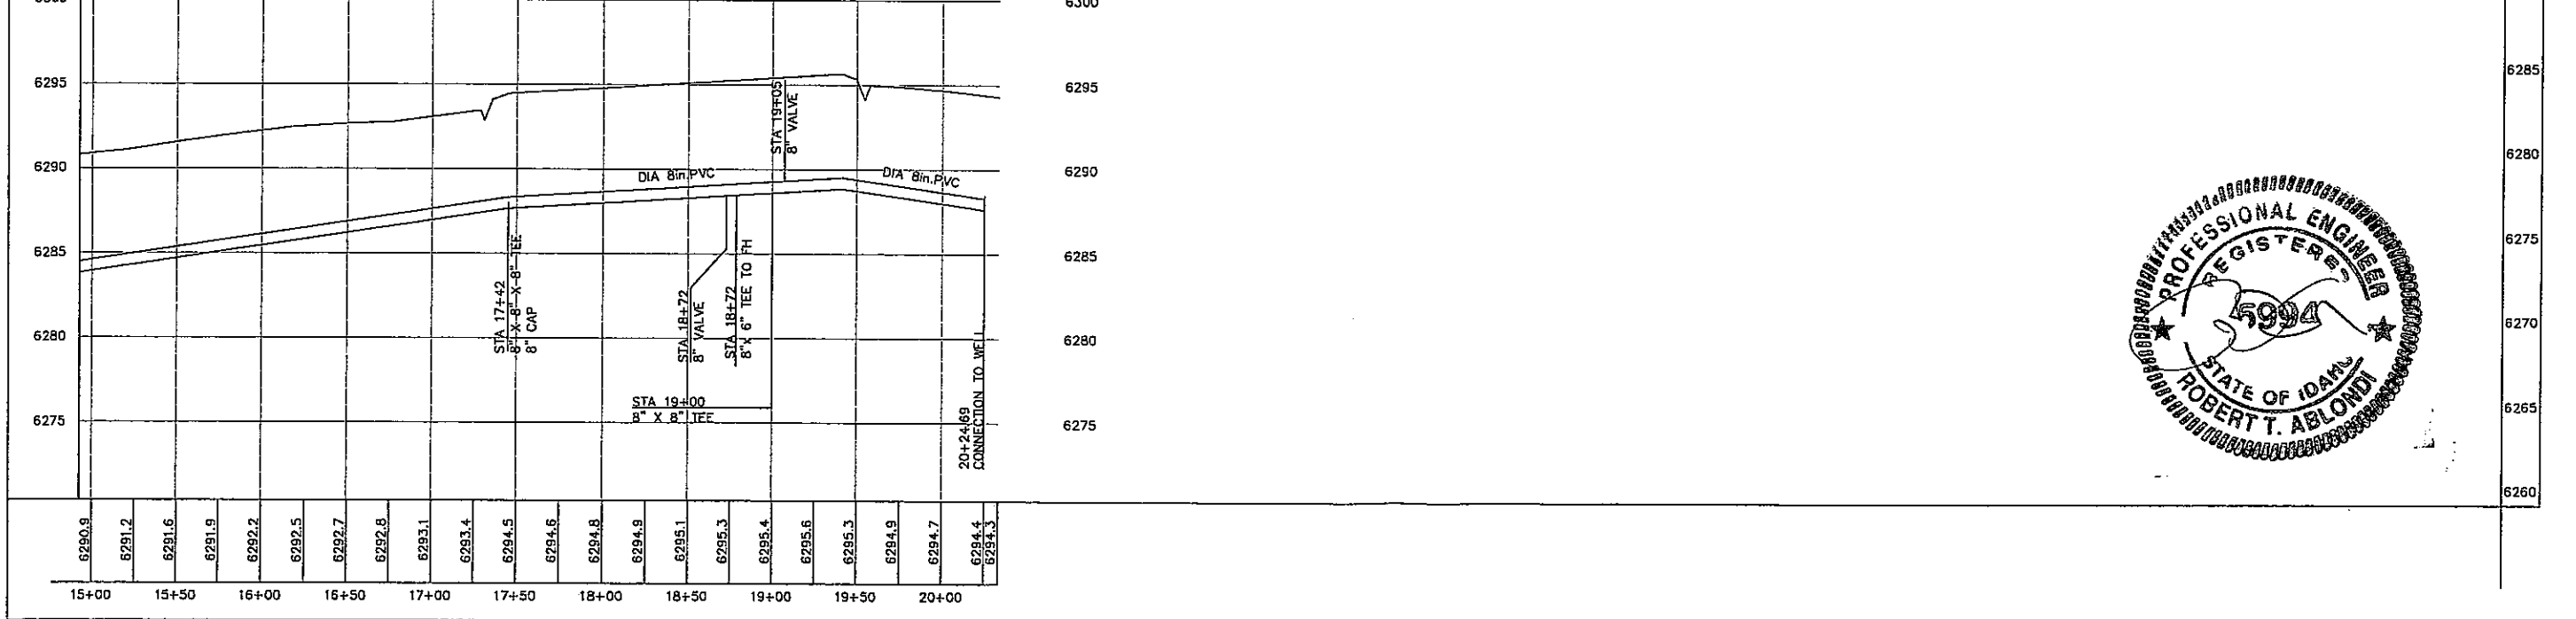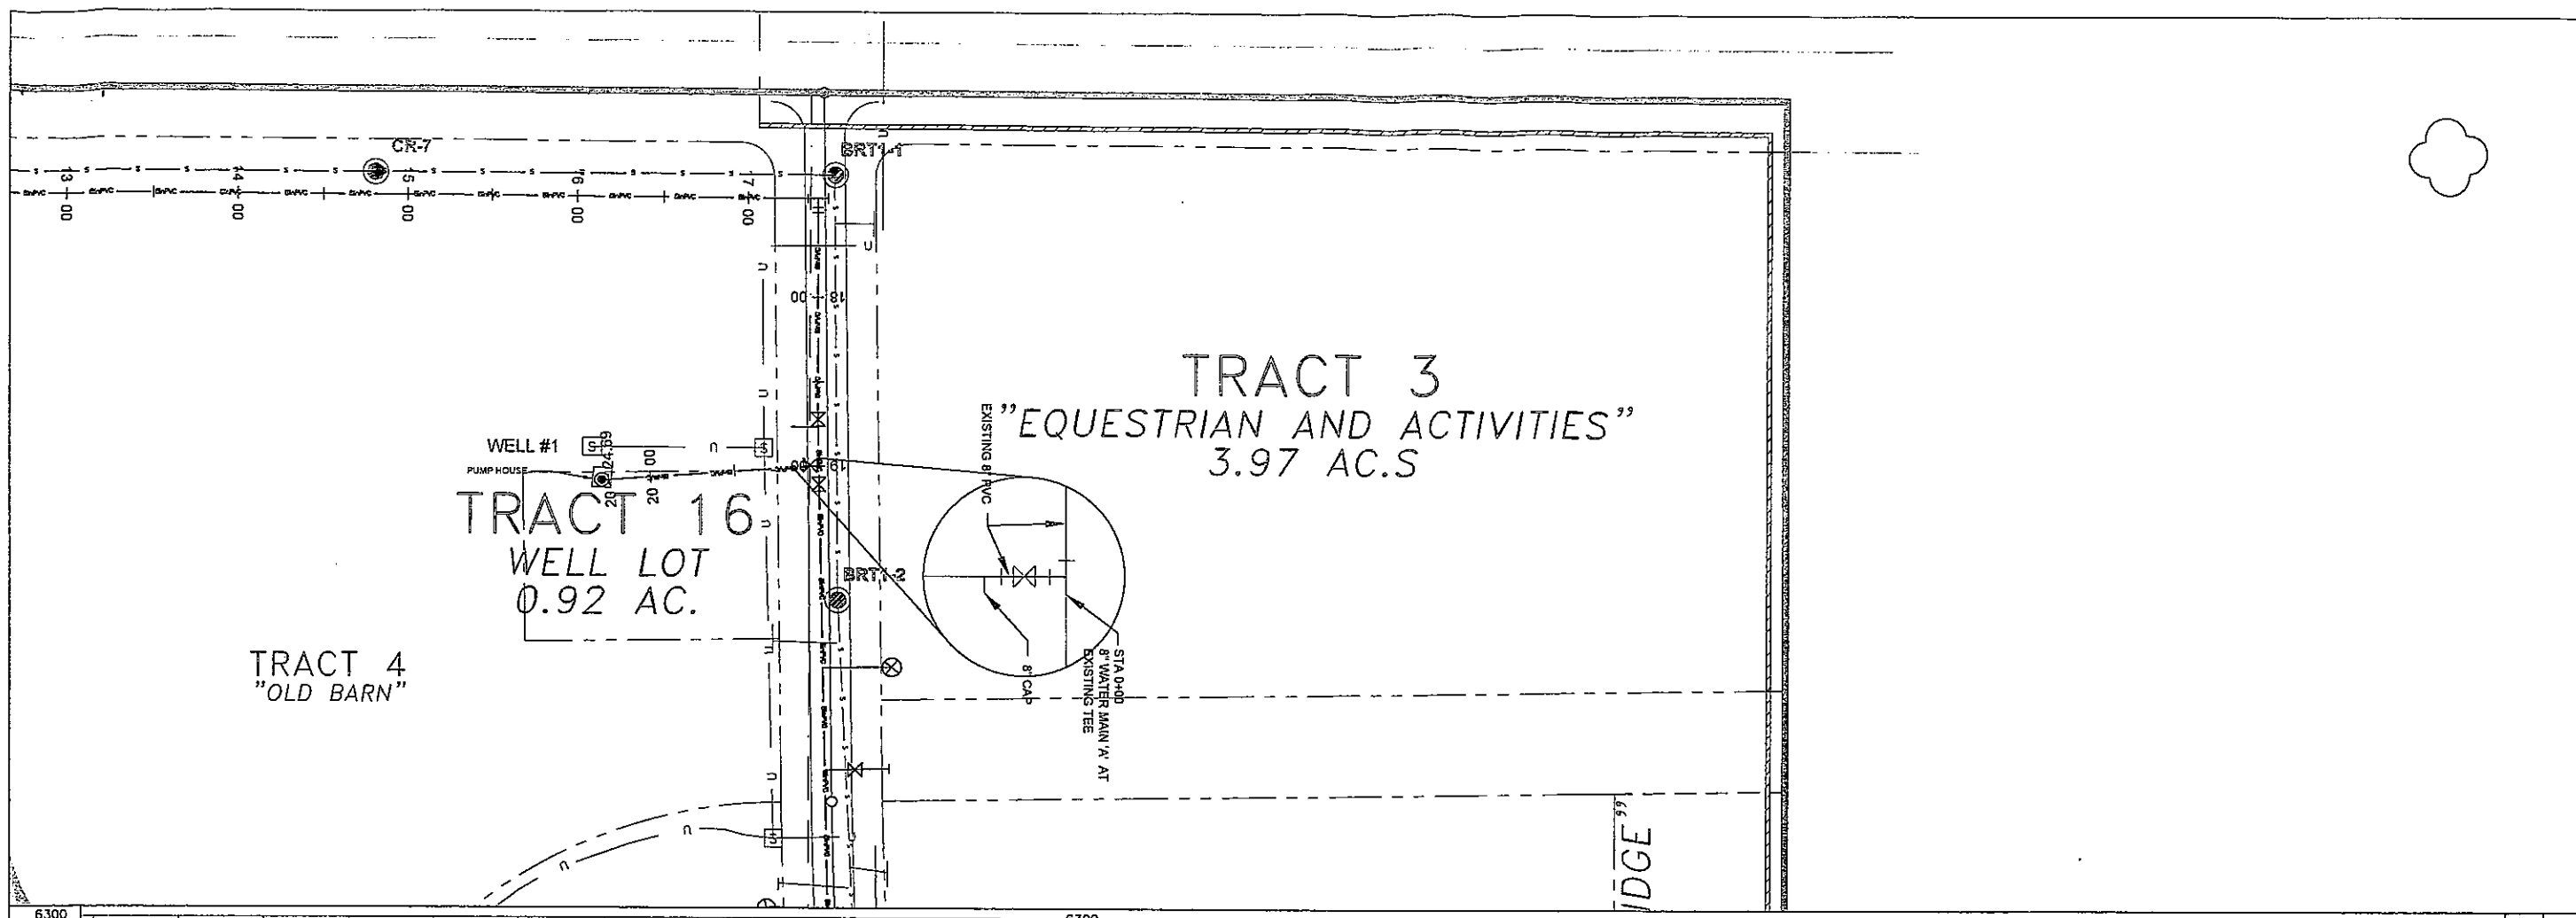


NOTES - THIS SHEET



GENERAL NOTES



Horizontal Scale: 1" = 50'
Vertical Scale: 1" = 5'

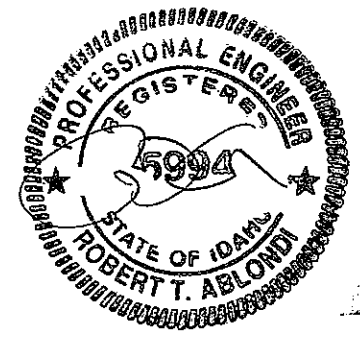


PROJECT TITLE: TETON SPRINGS RECORD DRAWINGS		DRAWING TITLE: AS BUILT WATER PLAN & PROFILE WATER MAIN 'AA' COUNTY ROAD 950 SOUTH		PREPARED BY: EDO DATE: 2003 REV. DATE: PILOT INFO: DATE: 11/14/03 FALL:	
PROJECT NUMBER: 00-023		DRAWING NUMBER: ASBW3		RENDEZVOUS ENGINEERING, P.C. P.O. BOX 4858 JACKSON, WYOMING 83001 25 SOUTH GROS VENTRE STREET PHONE - 307.733.5252 FAX - 307.733.2334	

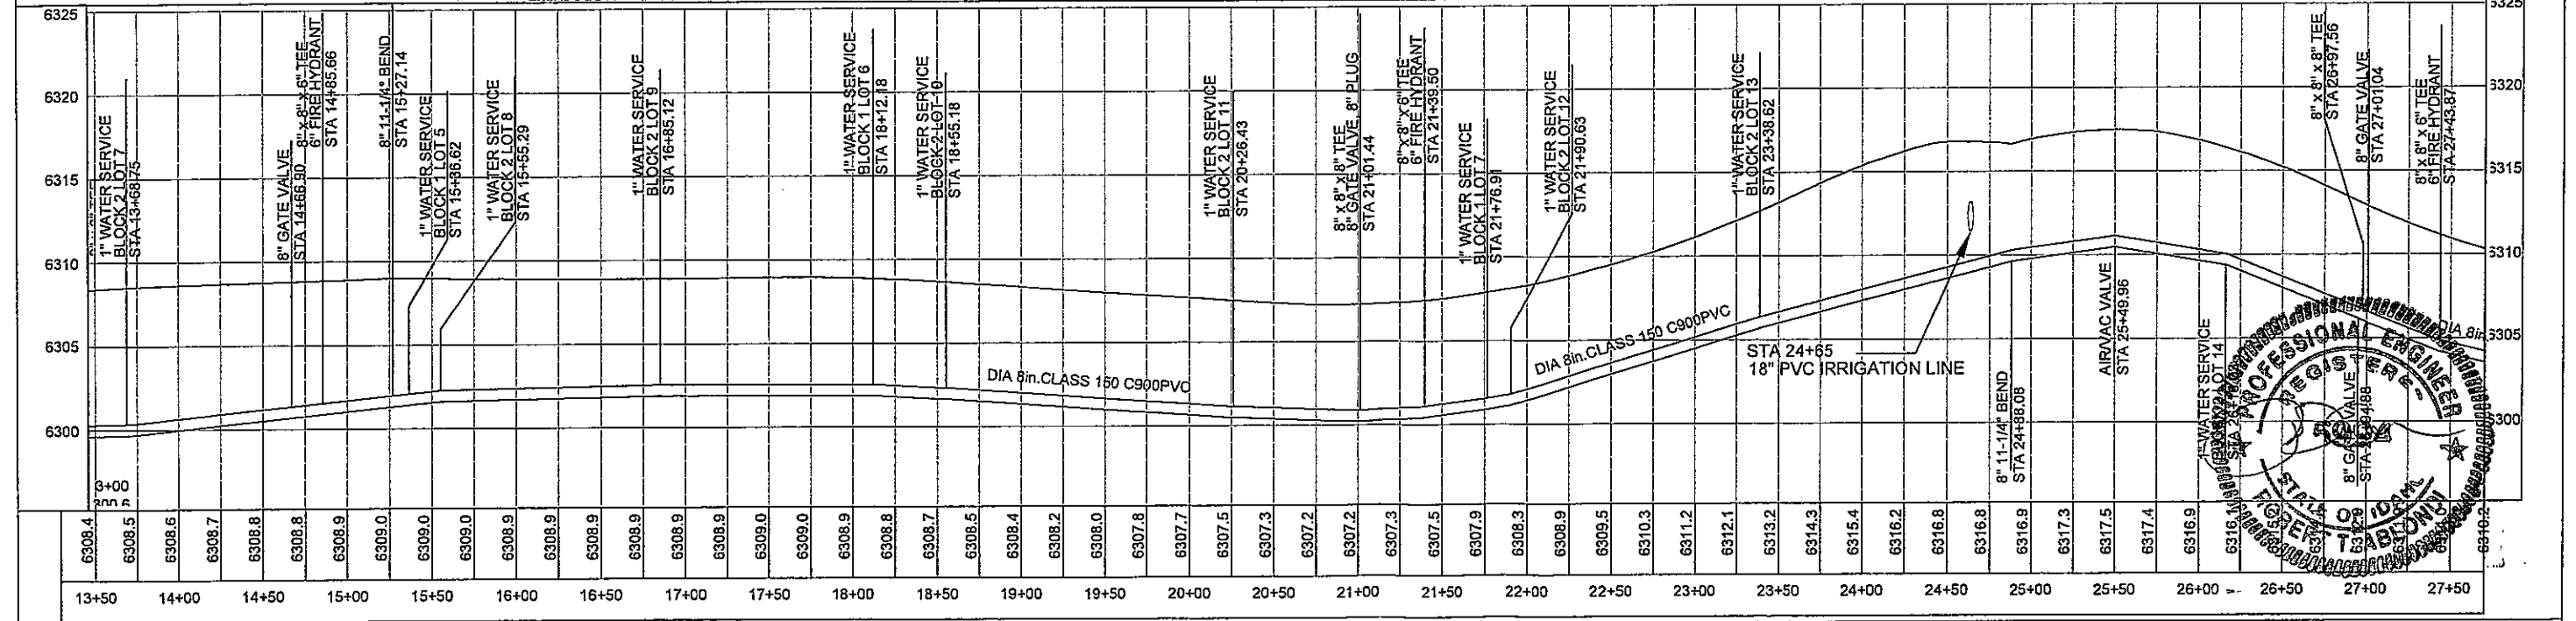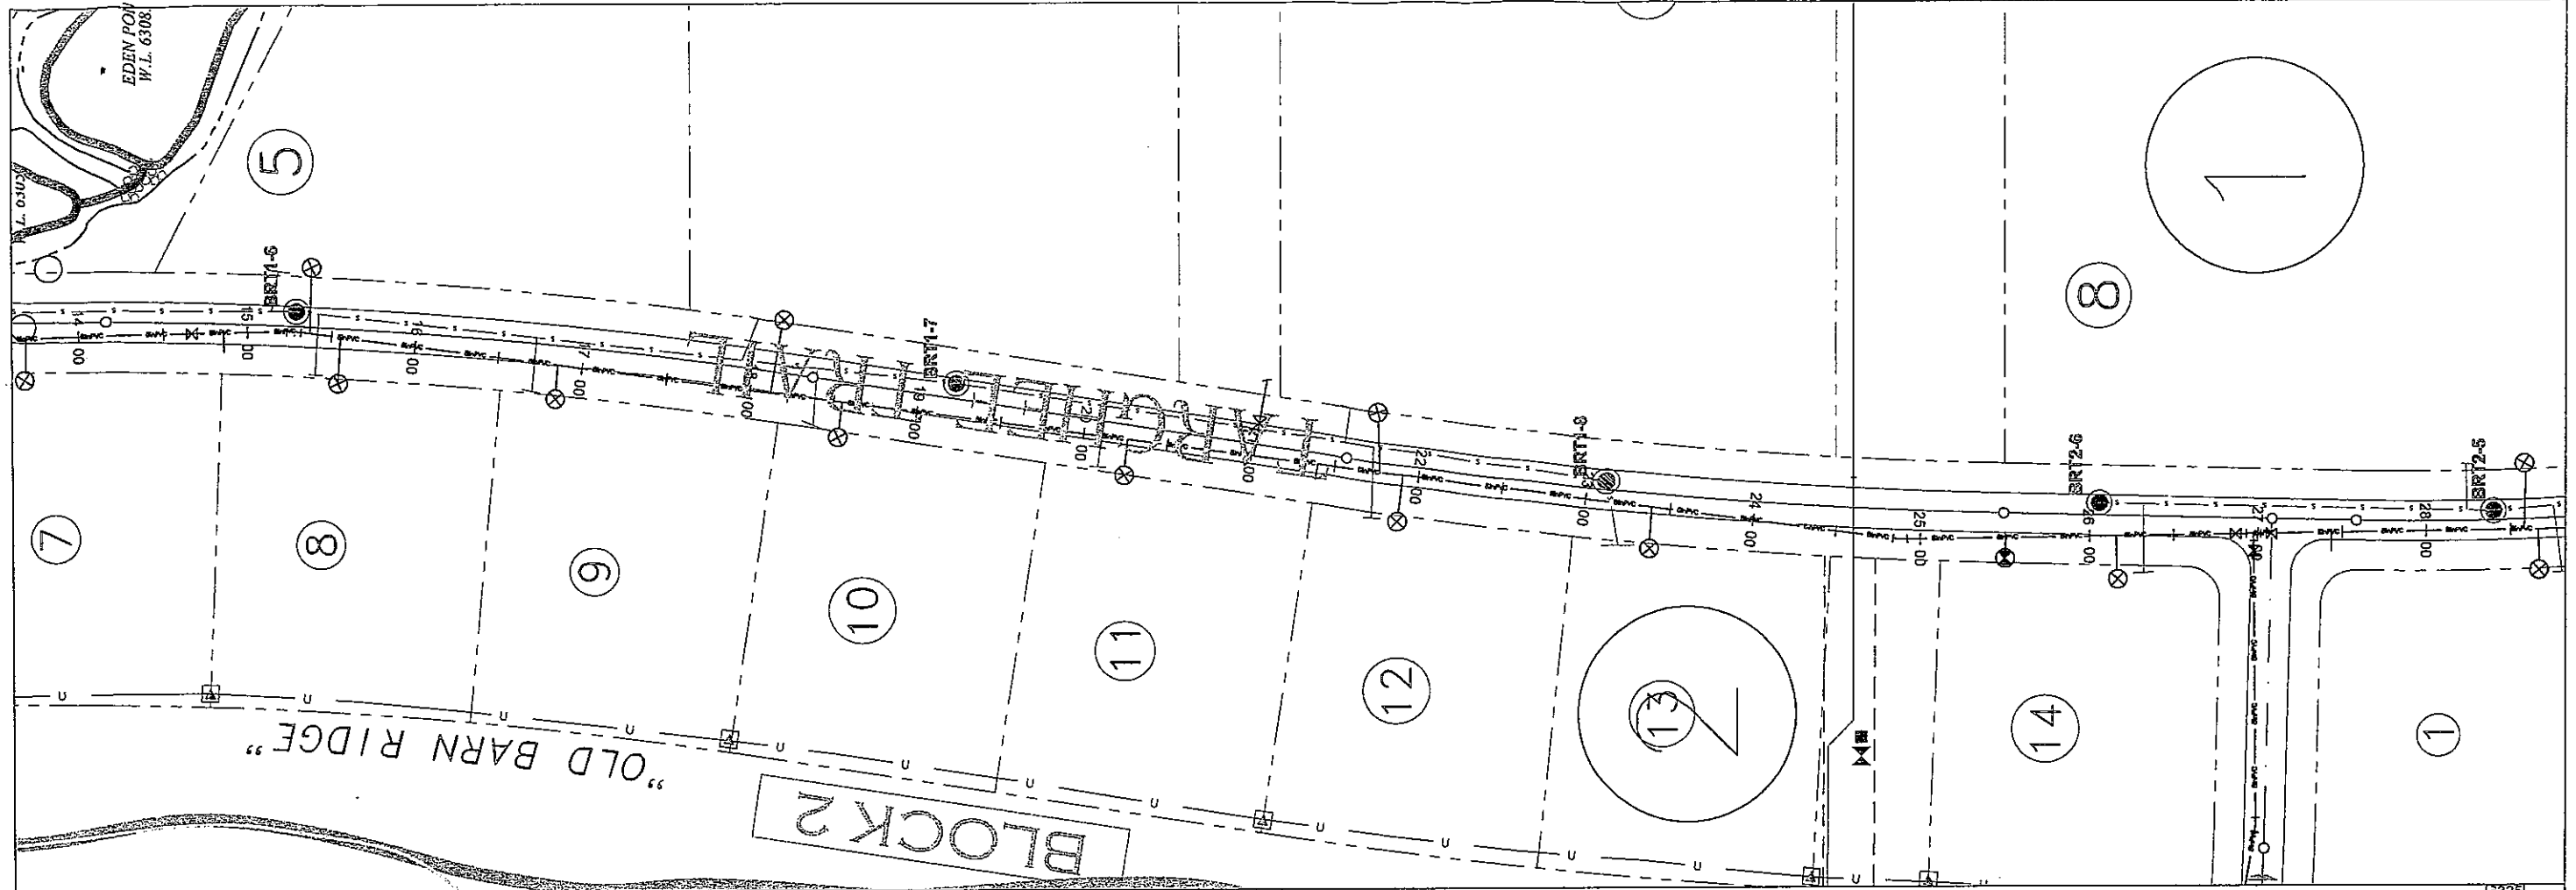

NOTES - THIS SHEET

GENERAL NOTES

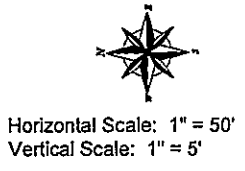

PROJECT TITLE:
**TETON SPRINGS
RECORD DRAWINGS**

PROJECT
NUMBER:
00-023

DRAWING
NUMBER:
ASBW5

DRAWING TITLE:
**AS BUILT WATER PLAN & PROFILE
WATER MAIN 'A'
TARGHEE TRAIL**

PREPARED BY: EDD

DATE: 203

REV. DATE:



PILOT INFO:

DATE: 203

PILOT:

RENDEZVOUS ENGINEERING, P.C.
P.O. BOX 4859 JACOBSON, WYOMING 83001
25 SOUTH GROS VENTRE STREET
PHONE - 307.733.5252 FAX - 307.733.2334



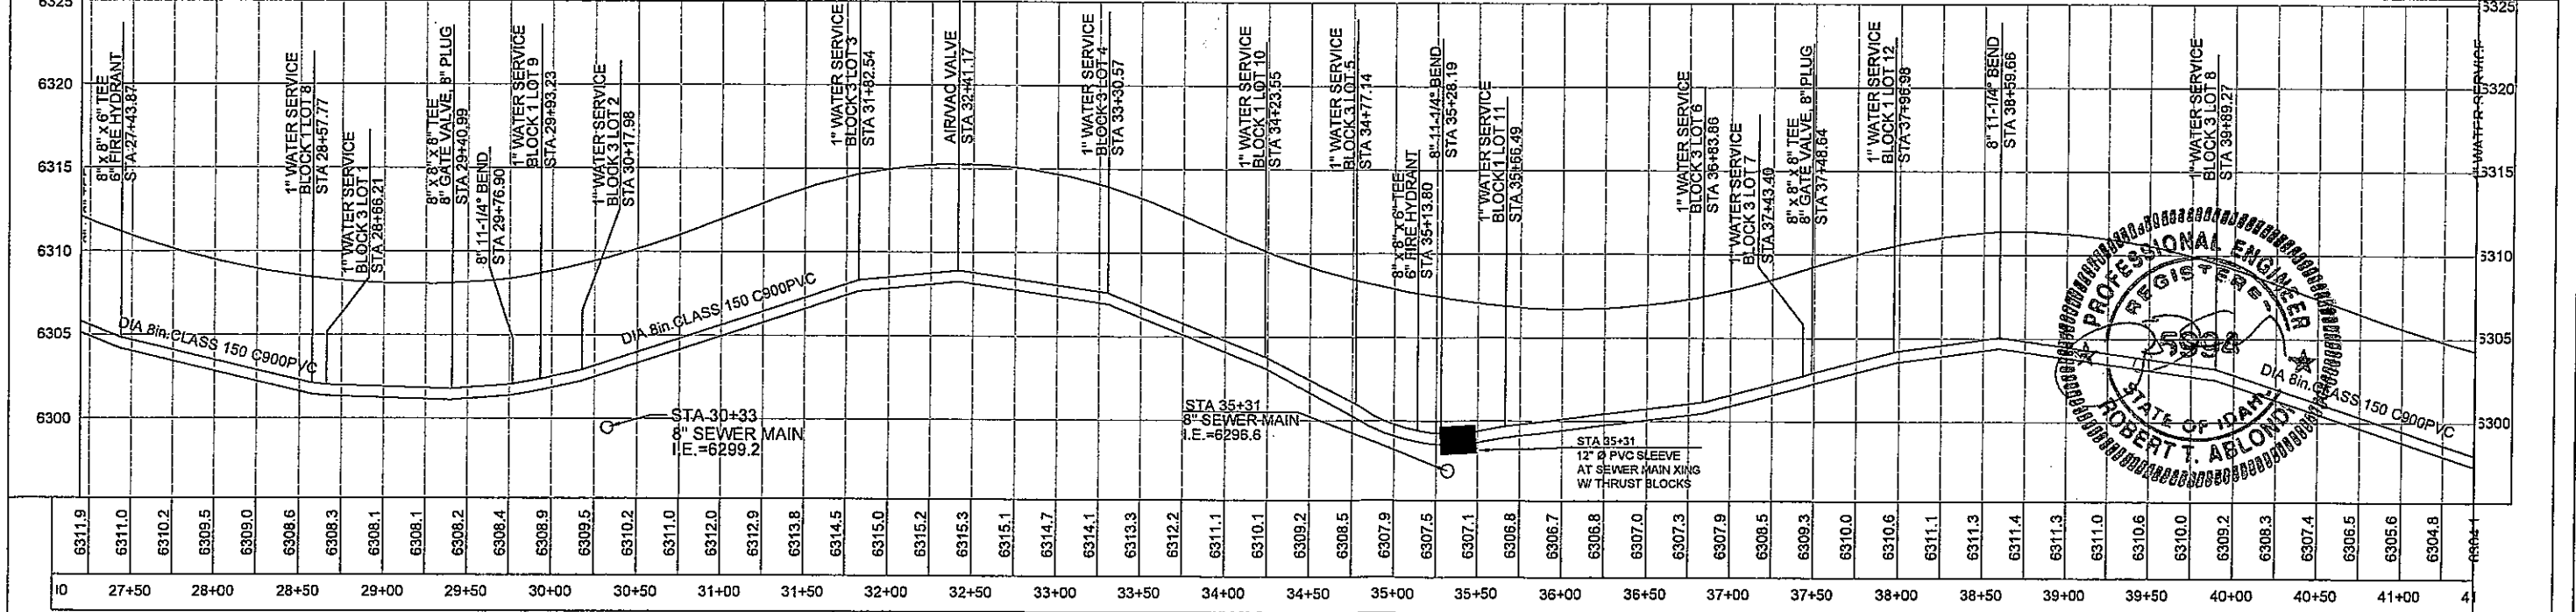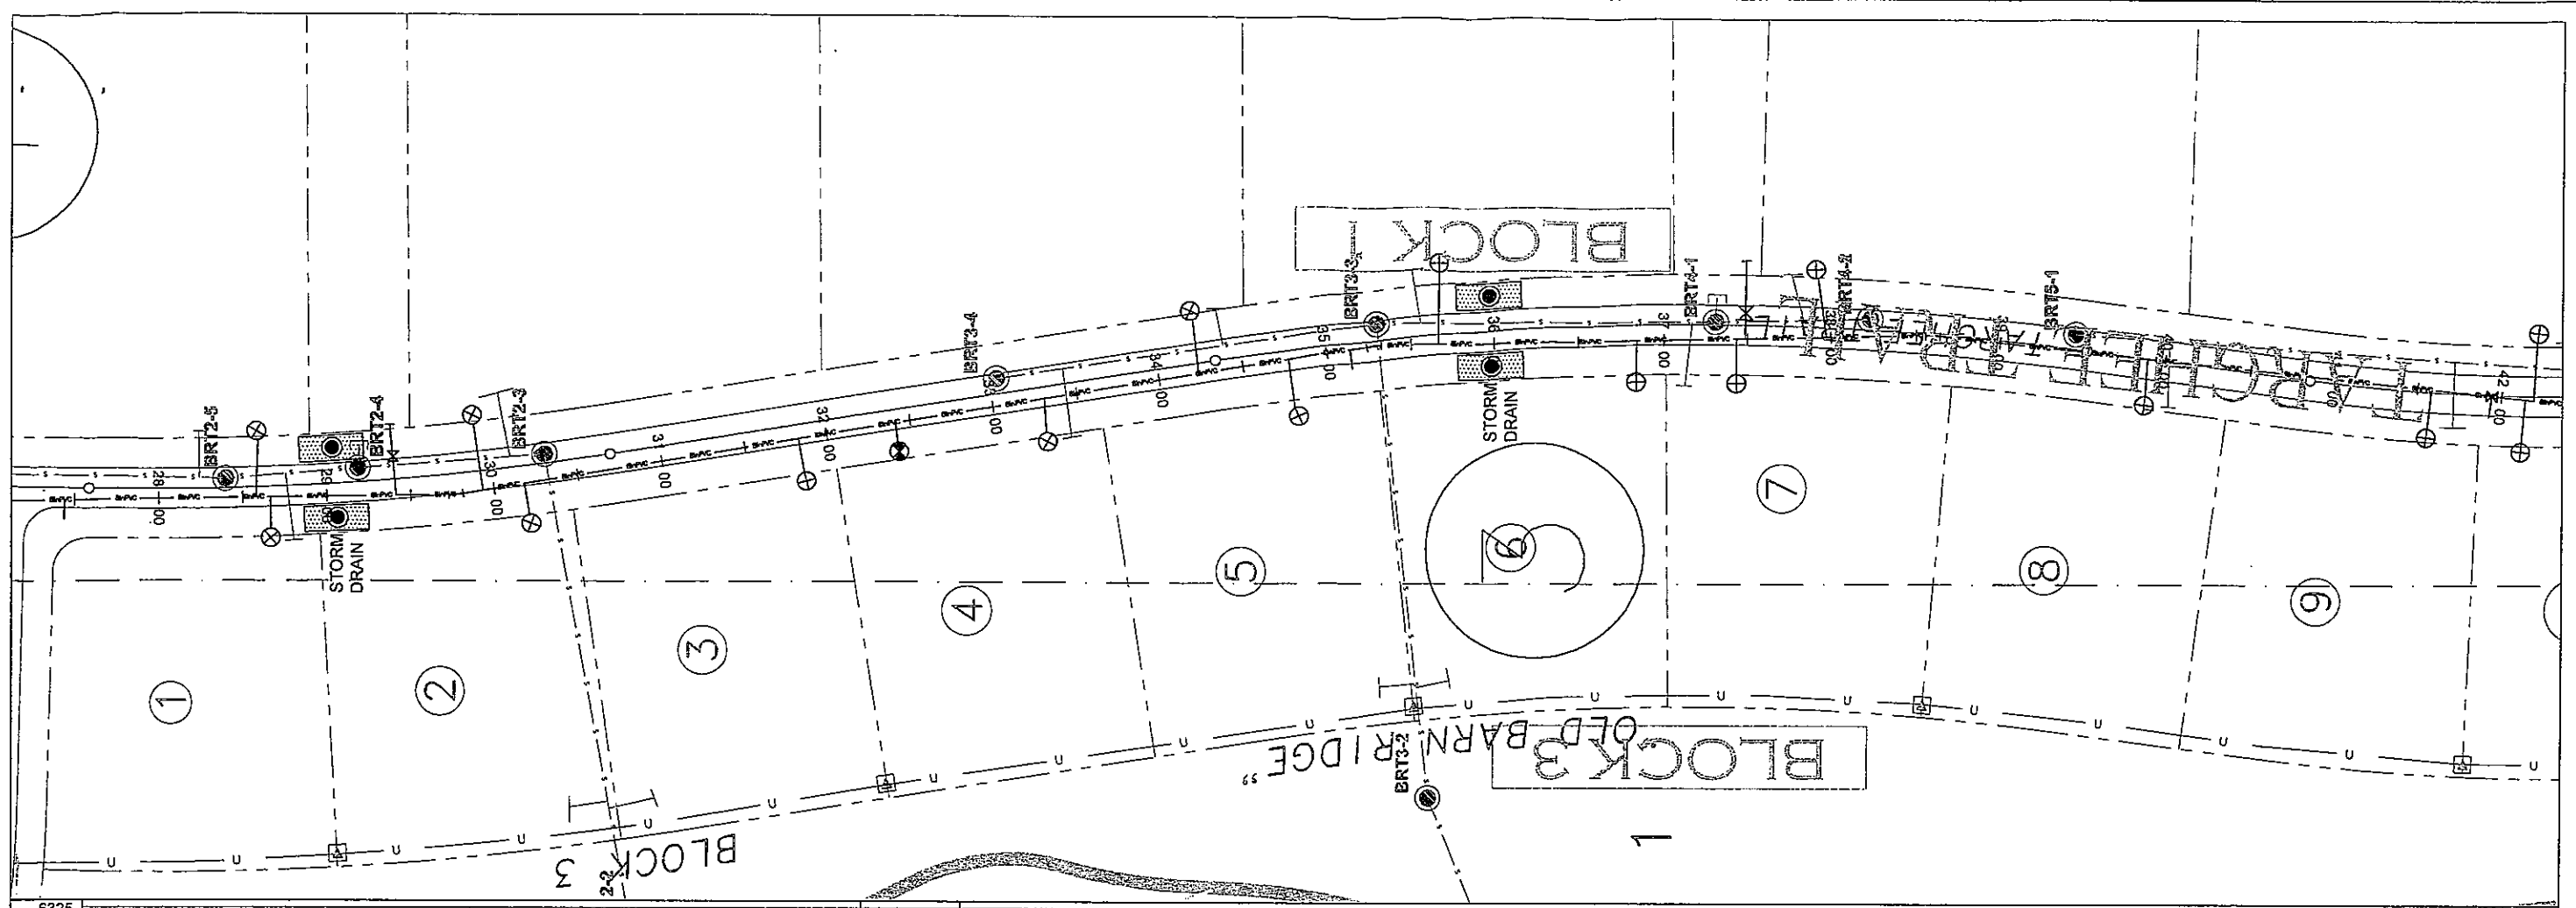

NOTES - THIS SHEET

GENERAL NOTES

Horizontal Scale: 1" = 50'

Vertical Scale: 1" = 5'

PROJECT TITLE:
TETON SPRINGS
RECORD DRAWINGS

PROJECT NUMBER:
00-023

DRAWING NUMBER:
ASBW6

DRAWING TITLE:
AS BUILT WATER PLAN & PROFILE
WATER MAIN 'A'
TARGHEE TRAIL



PROFESSIONAL ENGINEER
STATE OF IDAHO
ROBERT T. ABLONDI
25908

DIA 8in. CLASS 150 C900PVC

PREPARED BY: EDB
DATE: 2/03
REV. DATE:
PLOT INFO:
DATE: 2/03
PLOT:


RENDEZVOUS ENGINEERING, P.C.
P.O. BOX 4858 JACKSON, WYOMING 83001
25 SOUTH GROS VENTRE STREET
PHONE - 307.733.5252 FAX - 307.733.2334

1

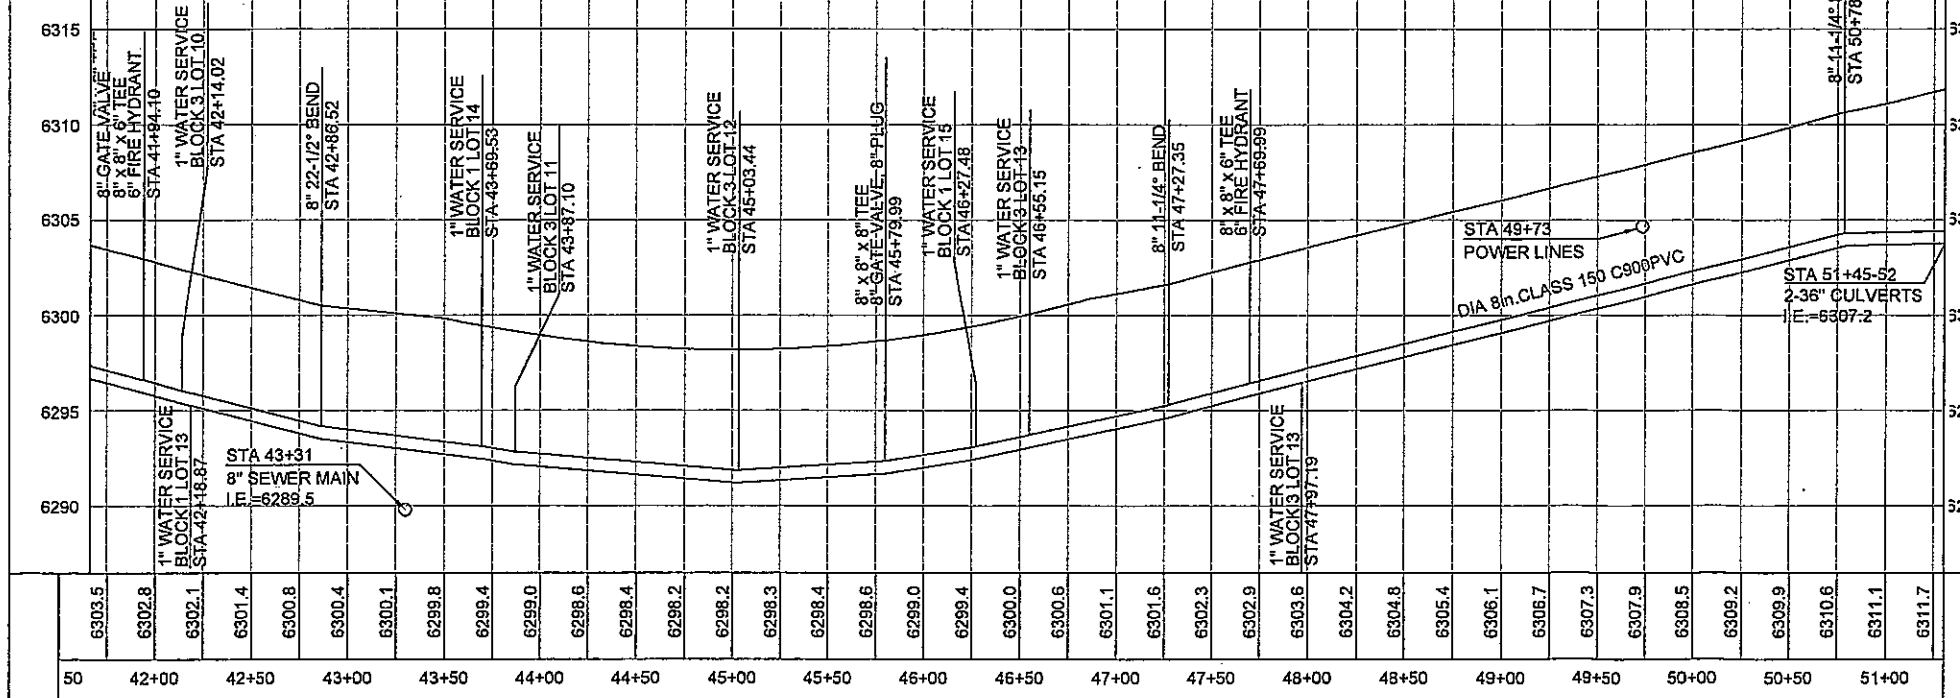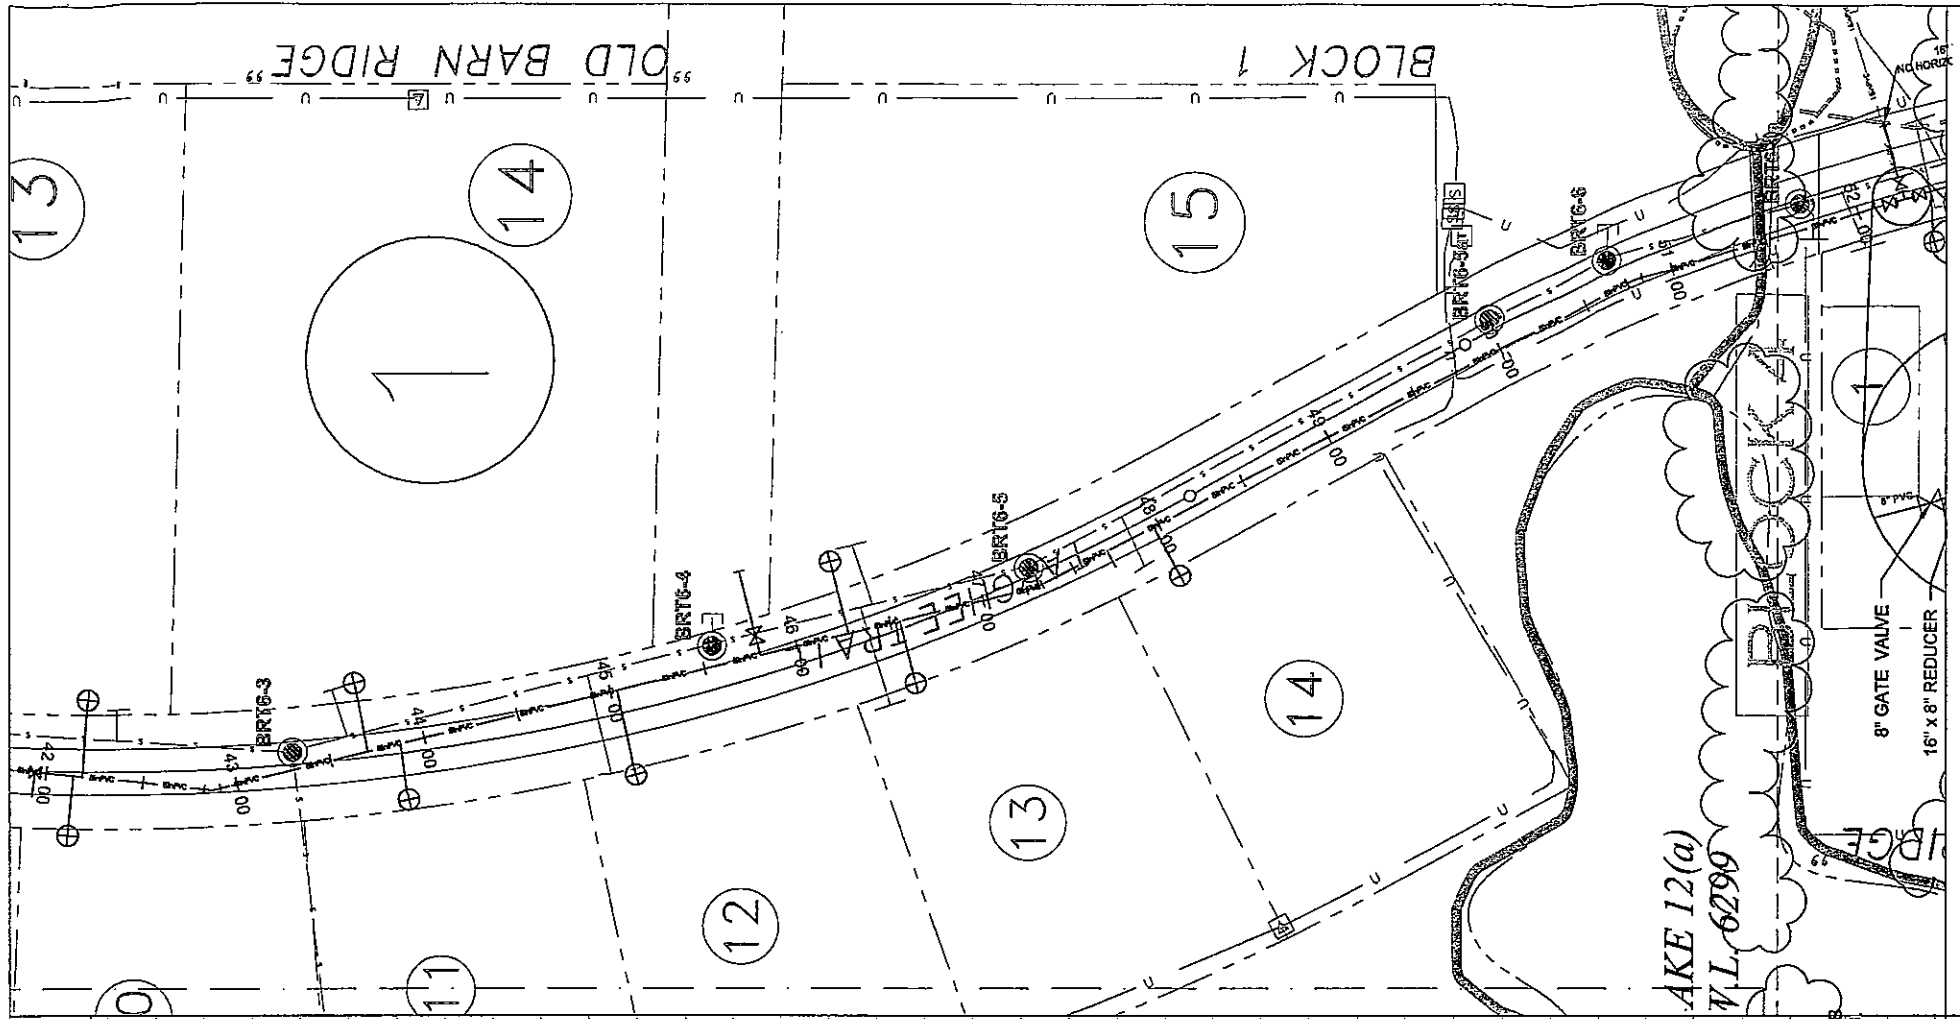

NOTES - THIS SHEET

GENERAL NOTES

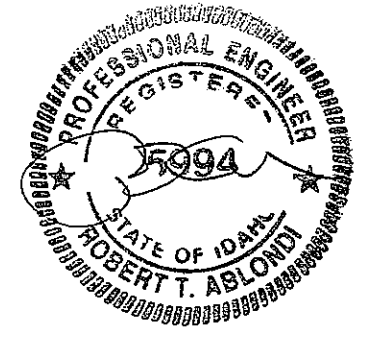

Horizontal Scale: 1" = 50'
Vertical Scale: 1" = 5'

PROJECT TITLE:
TETON SPRINGS
RECORD DRAWINGS



PROJECT NUMBER:
00-023

DRAWING NUMBER:
ASBW7

DRAWING TITLE:
AS BUILT WATER PLAN & PROFILE
WATER MAIN 'A'
TARGHEE TRAIL

**RENDEZVOUS ENGINEERING, P.C.**
P.O. BOX 4858 JACKSON, WYOMING 83001
25 SOUTH GROS VENTRE STREET
PHONE - 307.733.5252 FAX - 307.733.2334

Prepared By: EDO
Date: 2003
Rev. Date:
Plot Info:
Date:
Palt:

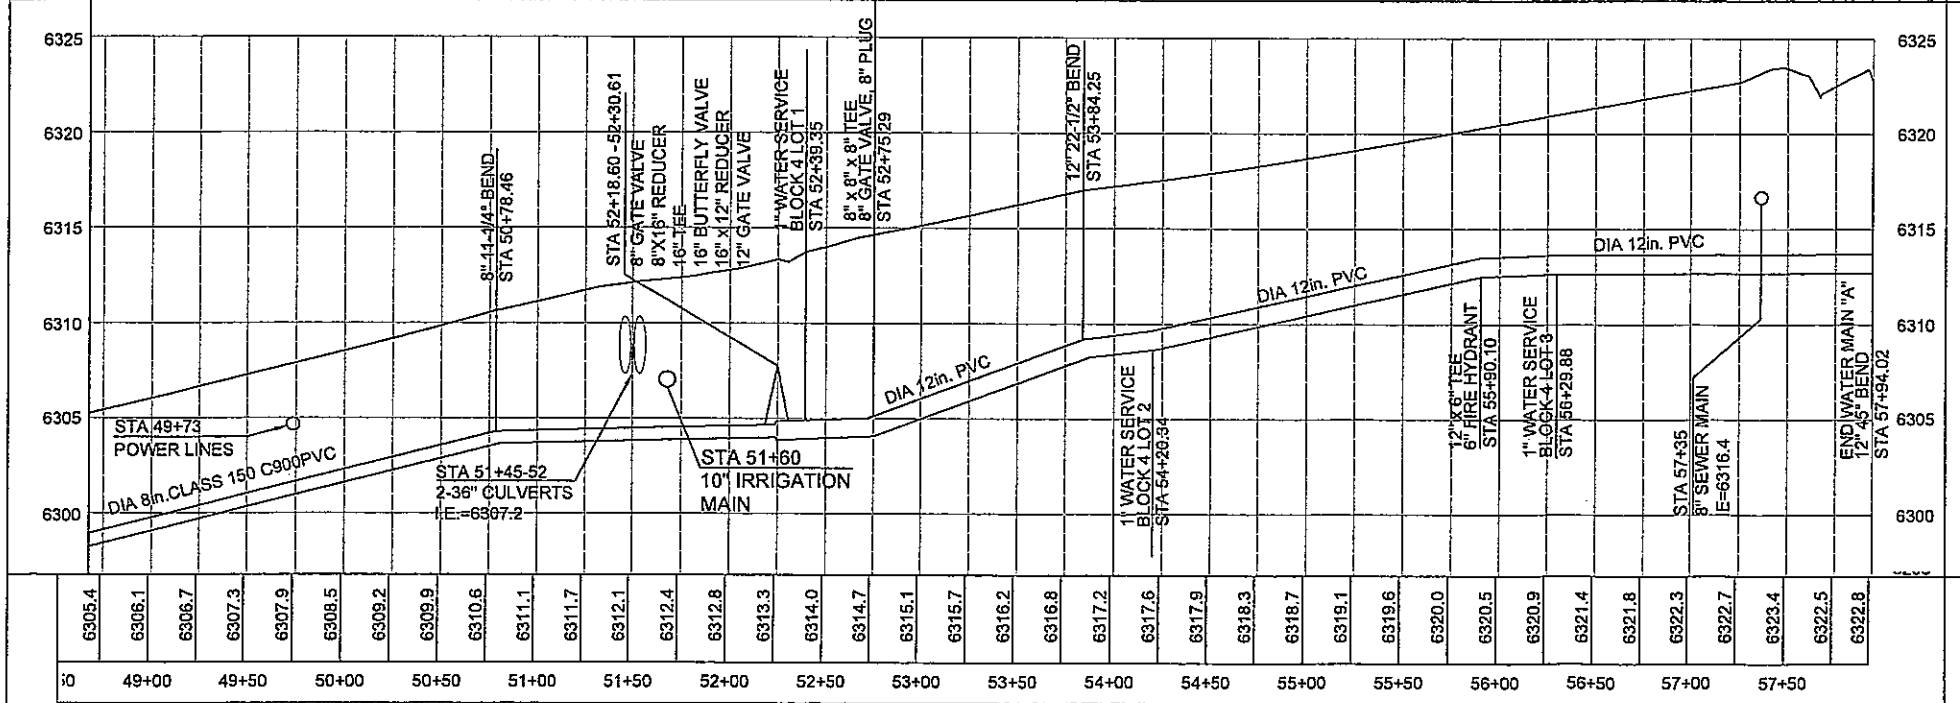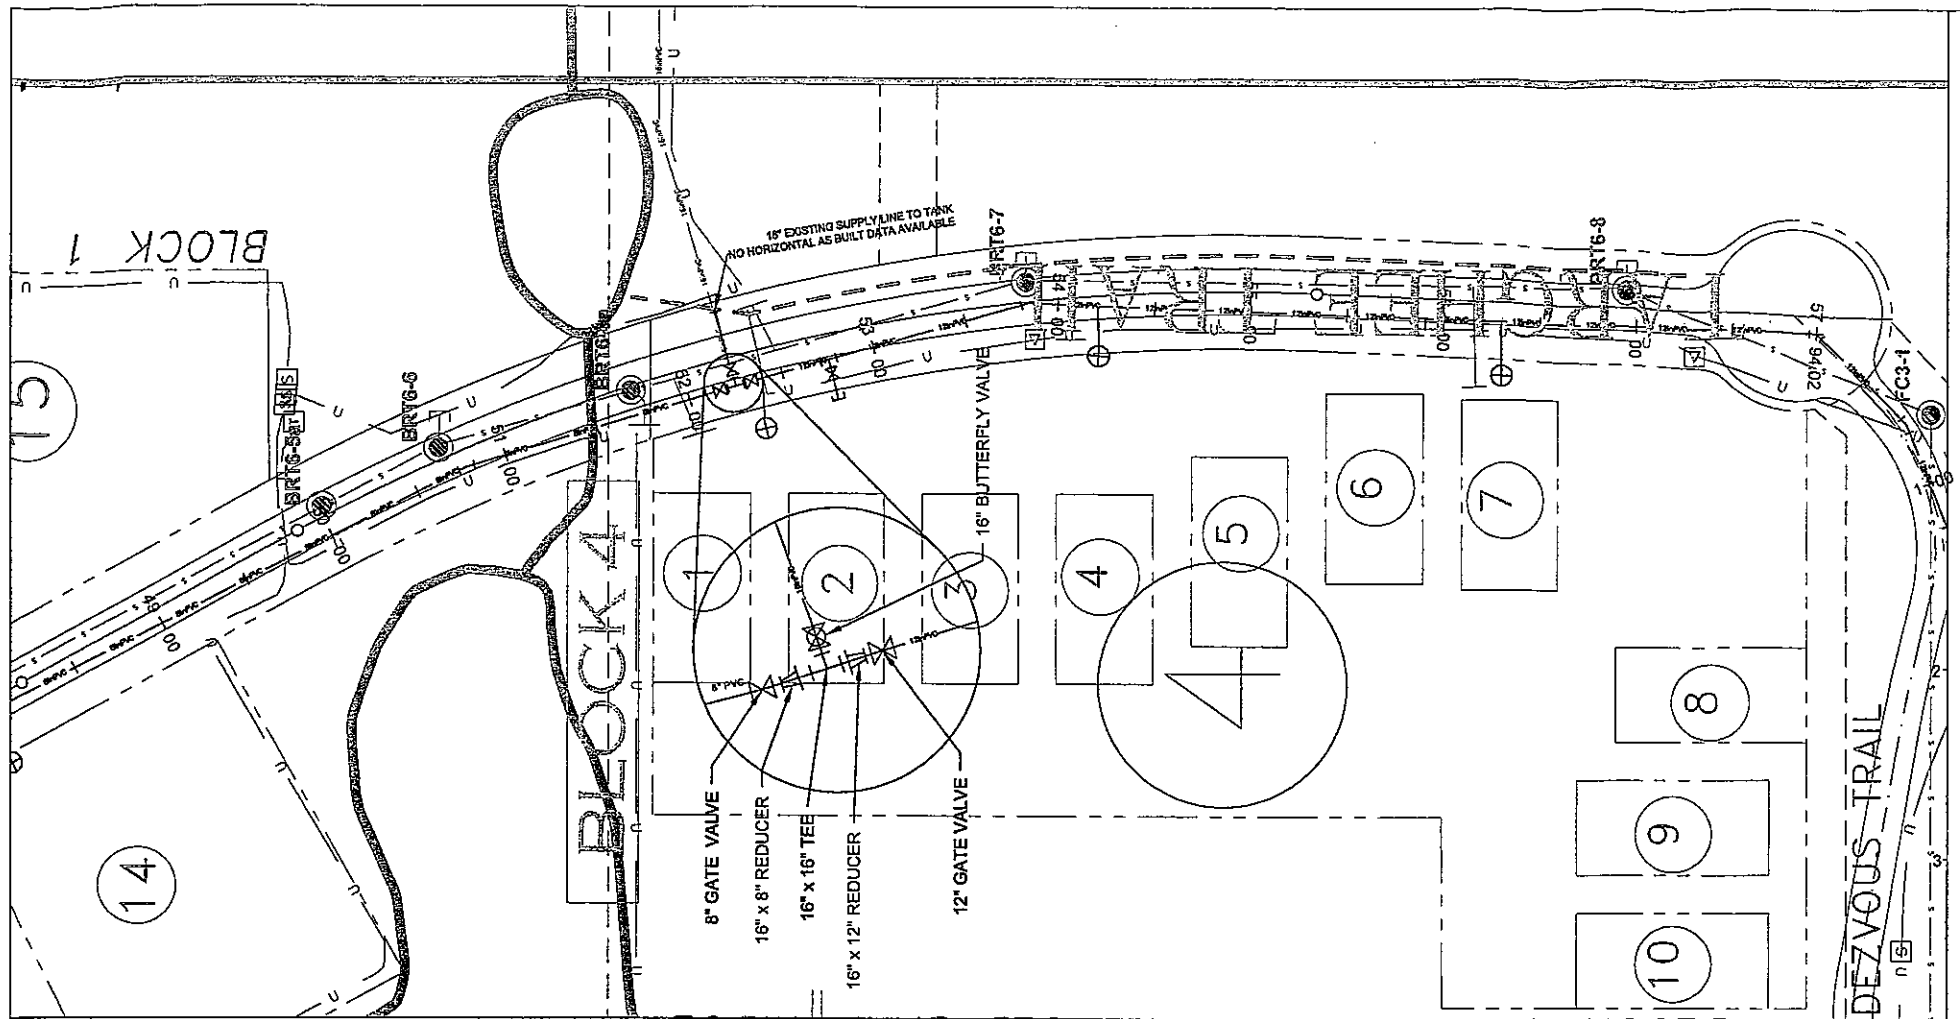


NOTES - THIS SHEET

GENERAL NOTES



Horizontal Scale: 1" = 50'
Vertical Scale: 1" = 5'

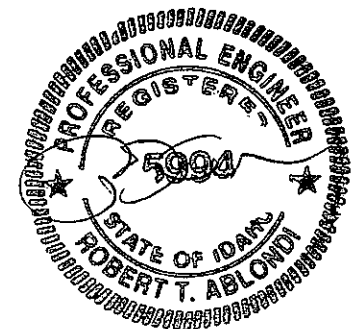



PROJECT TITLE:
TETON SPRINGS
RECORD DRAWINGS

PROJECT
NUMBER:
00-023
DRAWING
NUMBER:
ASBW8

DRAWING TITLE:
AS BUILT WATER PLAN & PROFILE
WATER MAIN 'A'
TARGHEE TRAIL

RENDEZVOUS ENGINEERING, P.C.
P.O. BOX 4858 JACKSON, WYOMING 83001
25 SOUTH GROSVENTRE STREET
PHONE - 307.733.5252 FAX - 307.733.2334


Prepared By: EOD
Date: 203
Rev. Date:
Plot Info:
Dwg
Patt:

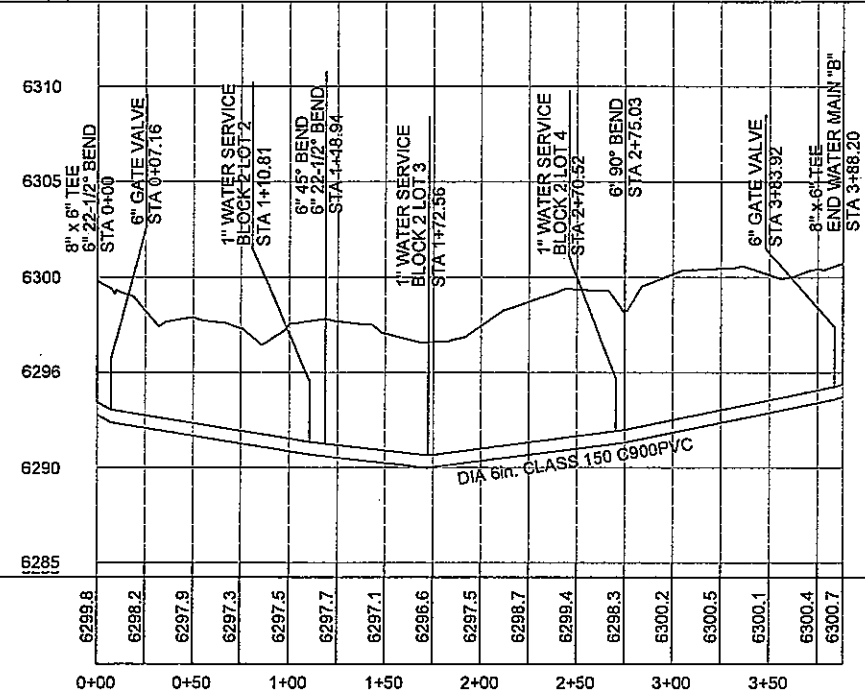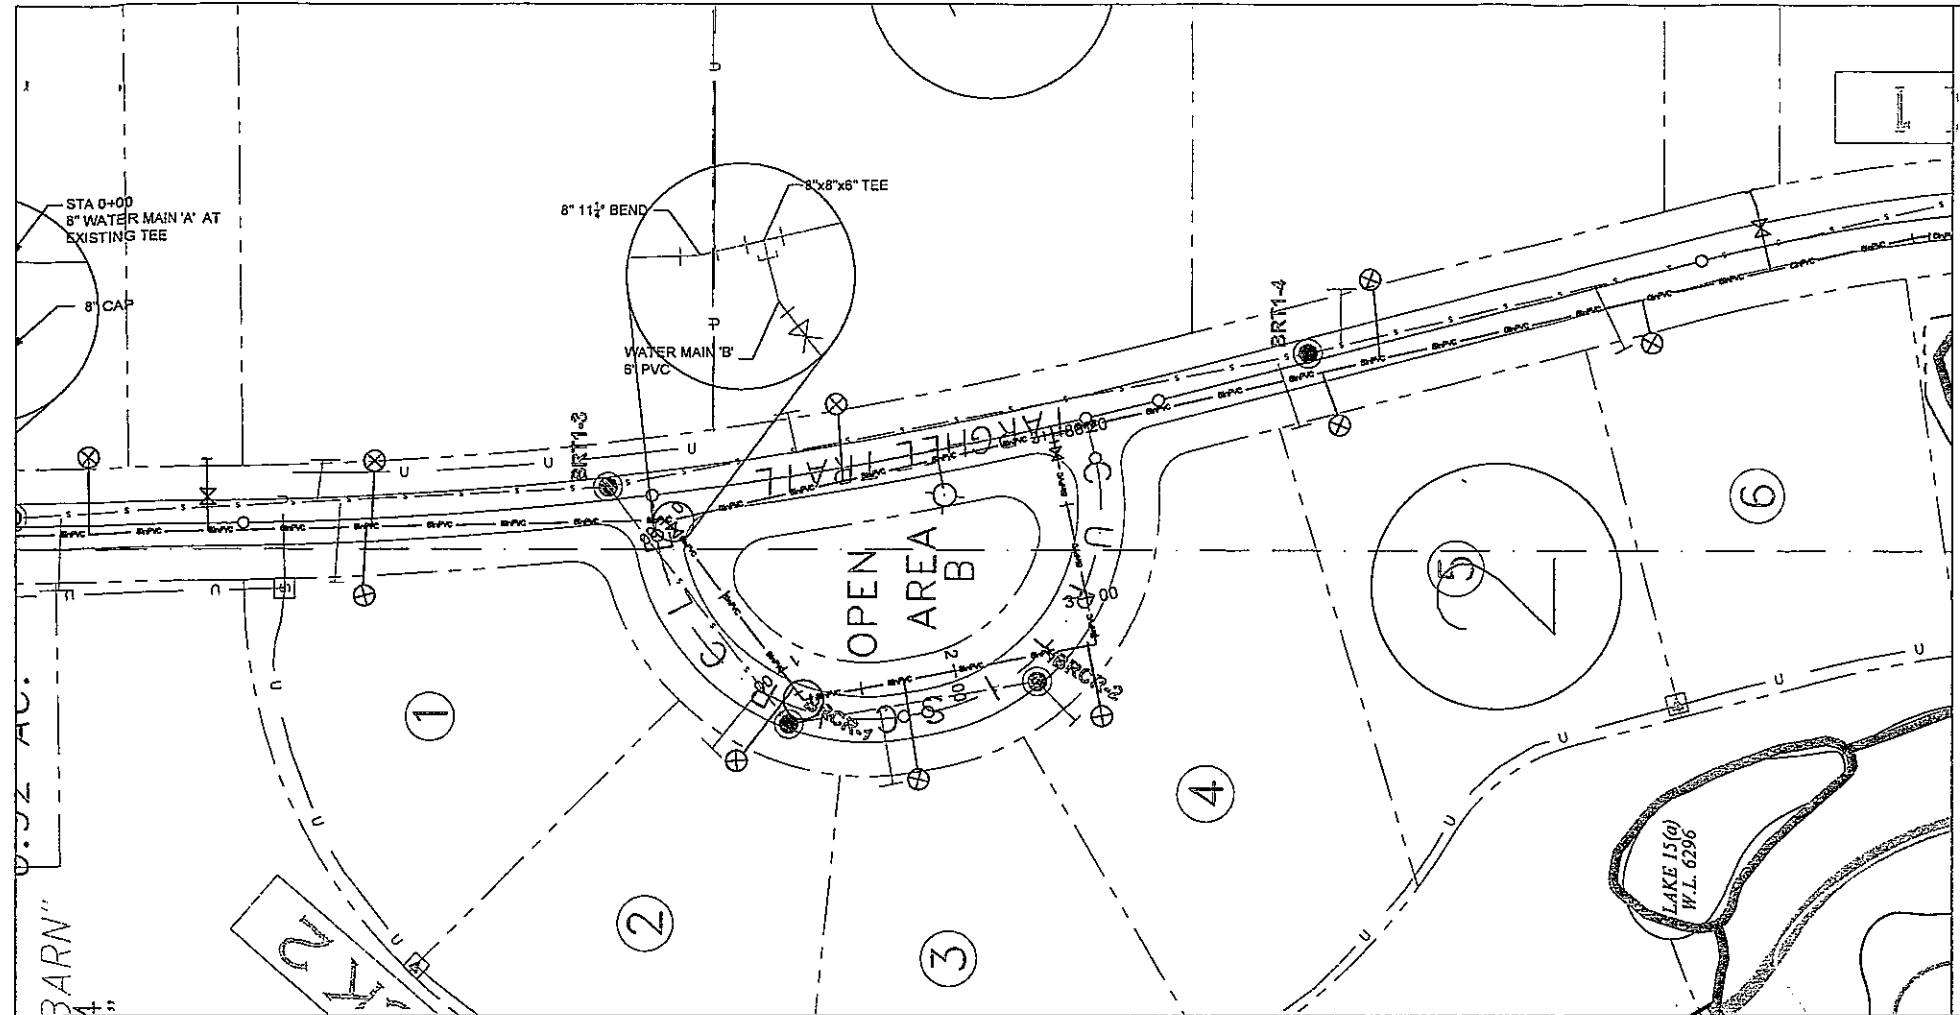

NOTES - THIS SHEET

GENERAL NOTES

Horizontal Scale: 1" = 50'
Vertical Scale: 1" = 5'

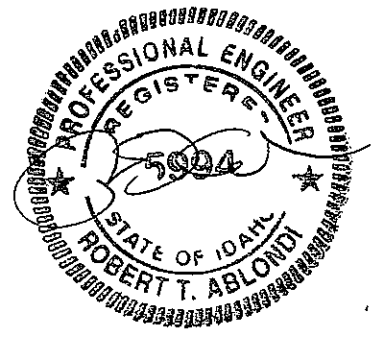

PROJECT TITLE:
**TETON SPRINGS
RECORD DRAWINGS**

PROJECT NUMBER:
00-023

DRAWING NUMBER:
ASBW9

DRAWING TITLE:
**AS BUILT WATER PLAN & PROFILE
WATER MAIN "B"
CURTIS CIRCLE**

Prepared By: **EDD**

Date: **2/03**

Rev. Date:

Rev. Info:

Date: **10/01/2003**

Drawn: **EDD**

Checked: **EDD**



Plotted: **EDD**

RENDEZVOUS ENGINEERING, P.C.

P.O. BOX 4858 JACKSON, WYOMING 83001

25 SOUTH CROSS VENTURE STREET


PHONE - 307.733.5252 FAX - 307.733.2334

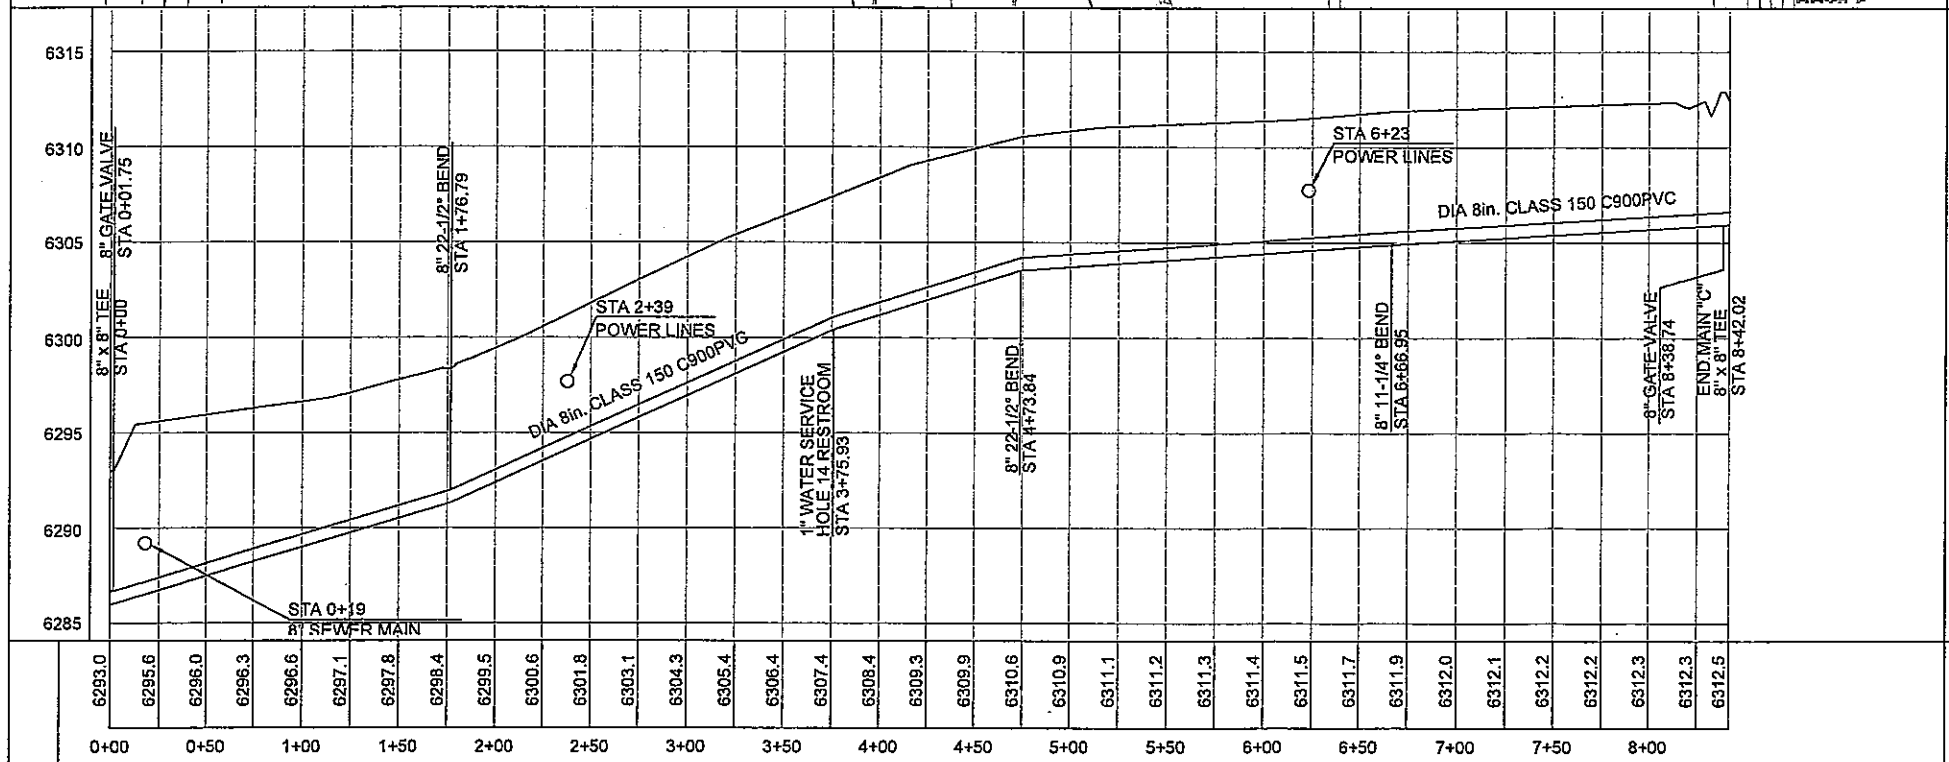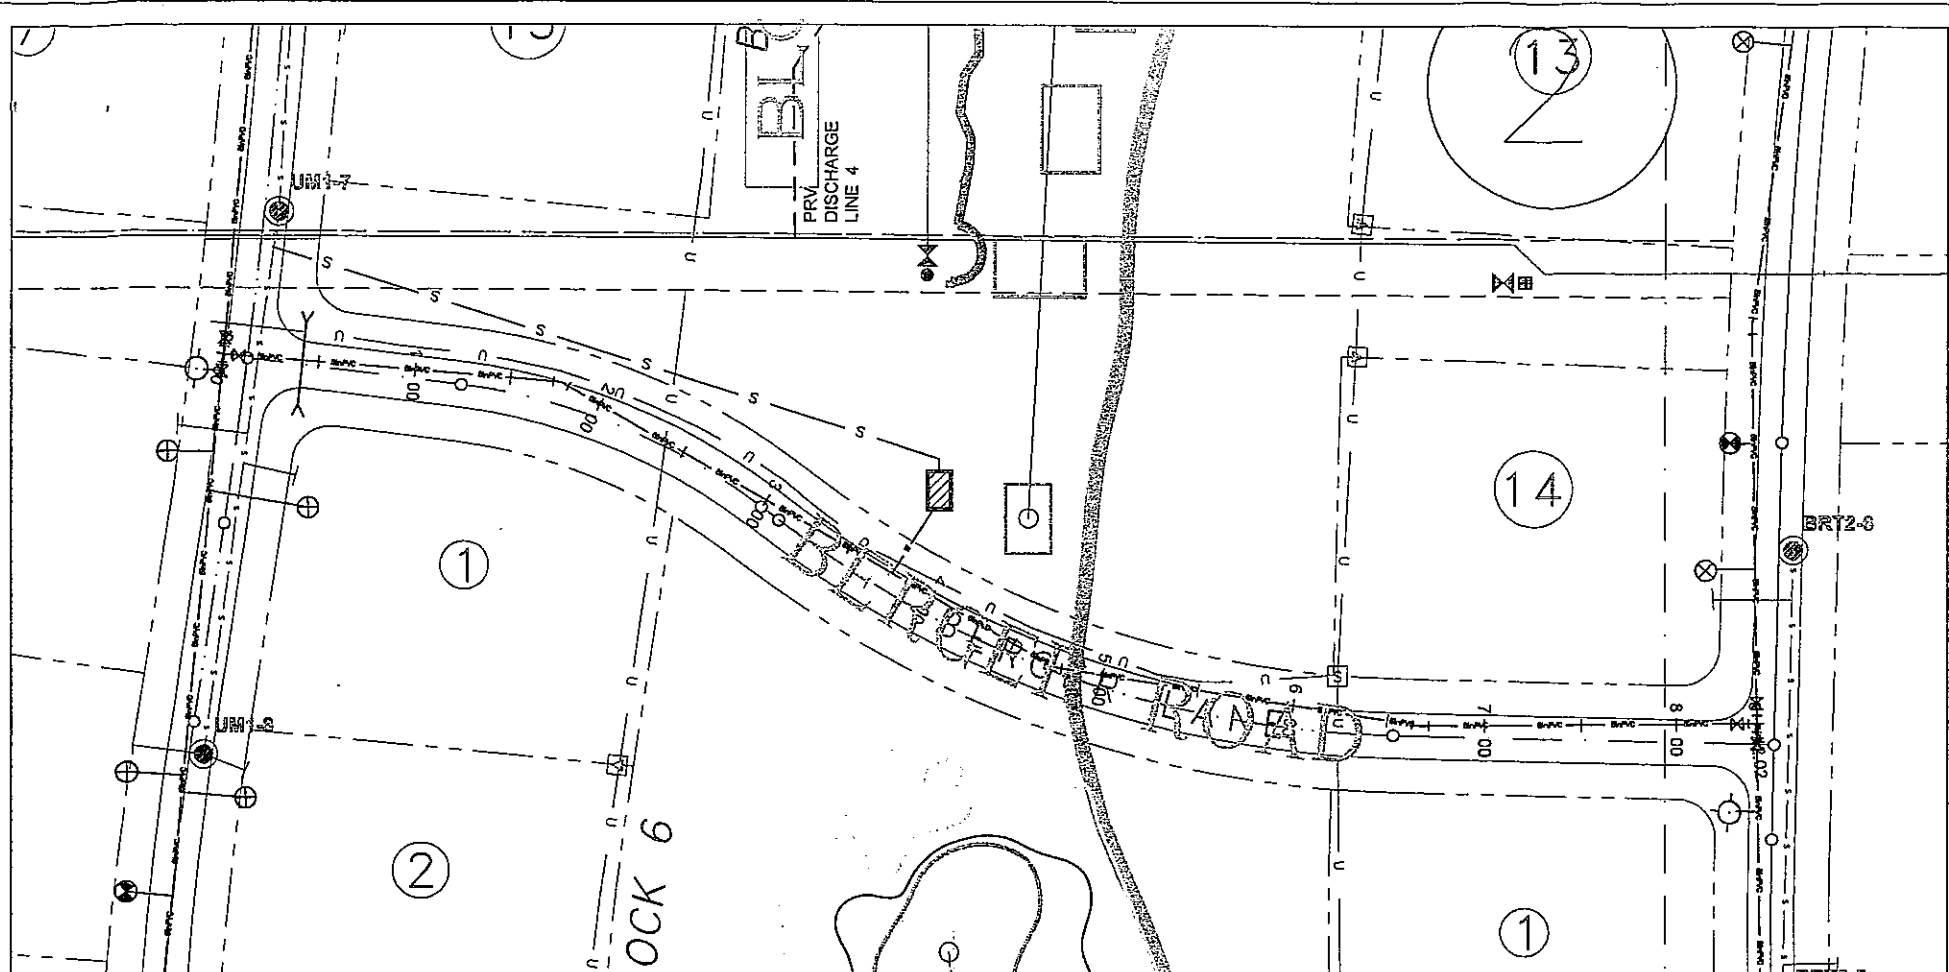



NOTES - THIS SHEET

GENERAL NOTES

Horizontal Scale: 1" = 50'
Vertical Scale: 1" = 5'

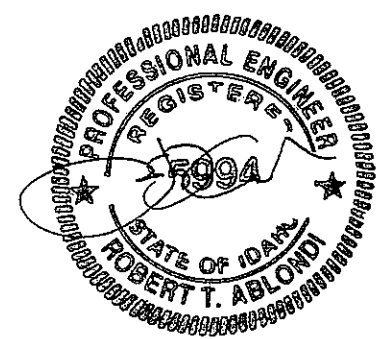

PROJECT TITLE: TETON SPRINGS RECORD DRAWINGS	DRAWING TITLE: AS BUILT WATER PLAN & PROFILE WATER MAIN 'C' BERGER ROAD	 RENDEZVOUS ENGINEERING, P.C. P.O. BOX 4858 - JACKSON, WYOMING 83001 23 SOUTH CROSS VENTURE STREET PHONE - 307.733.5252 FAX - 307.733.2334	Prepared By: EDO
			Date: 2/03
PROJECT NUMBER: 00-023			Rev. Date:
DRAWING NUMBER: ASBW10			Field Info:
			Date:
			Path:

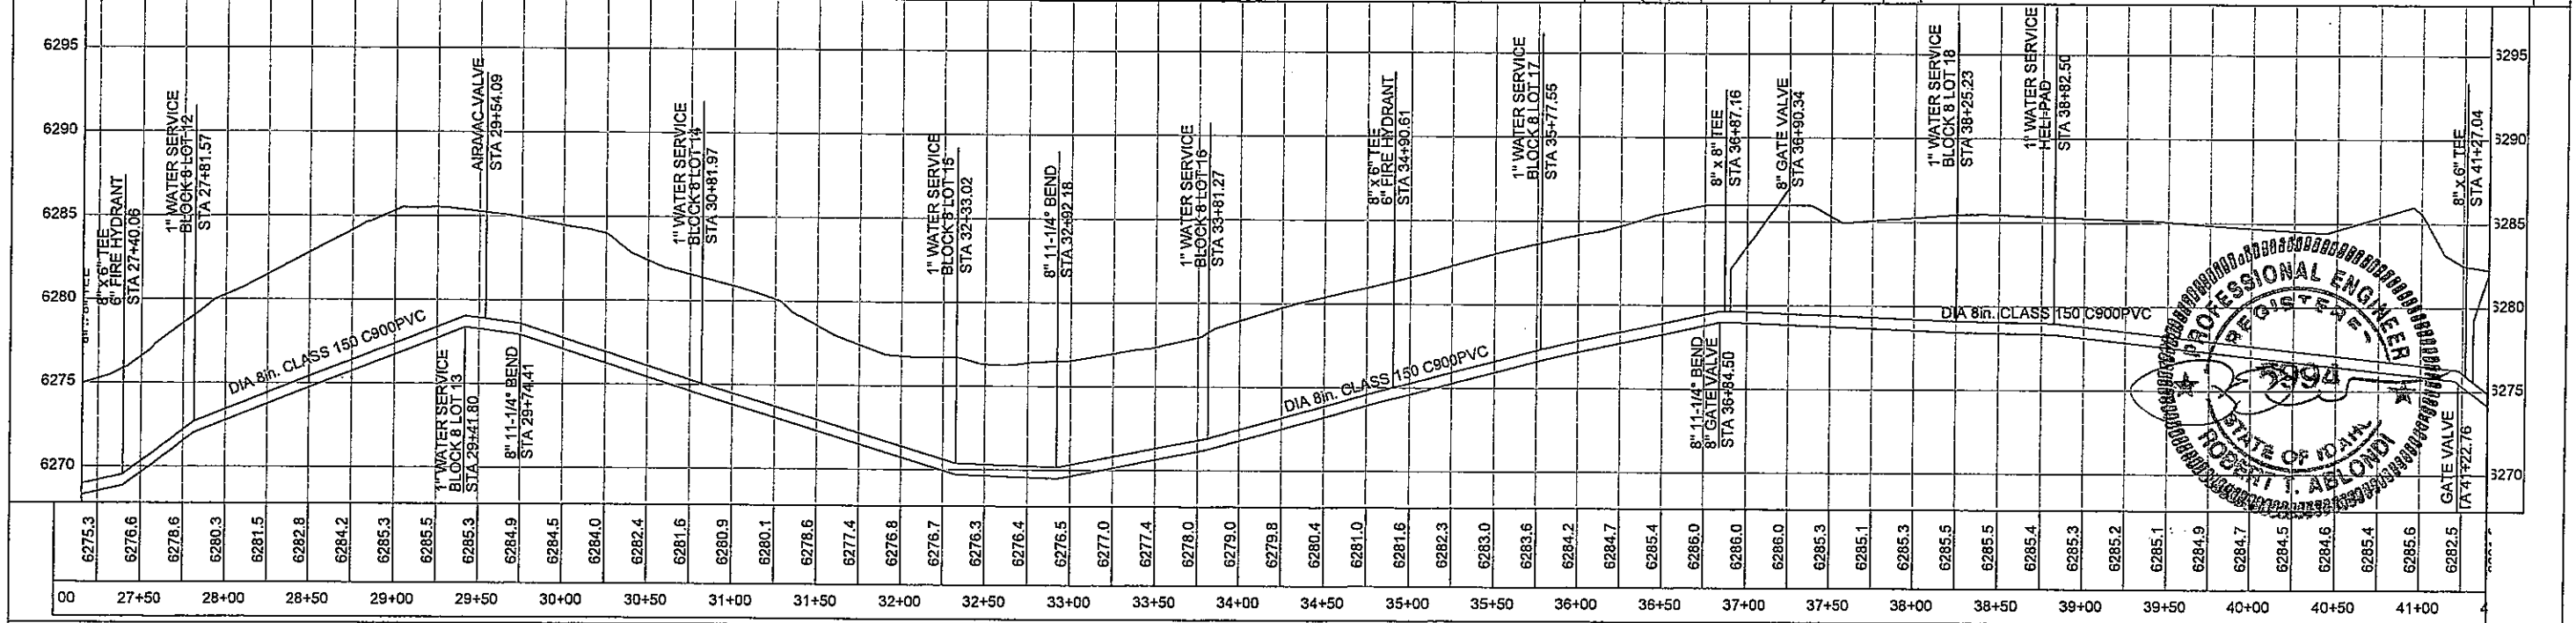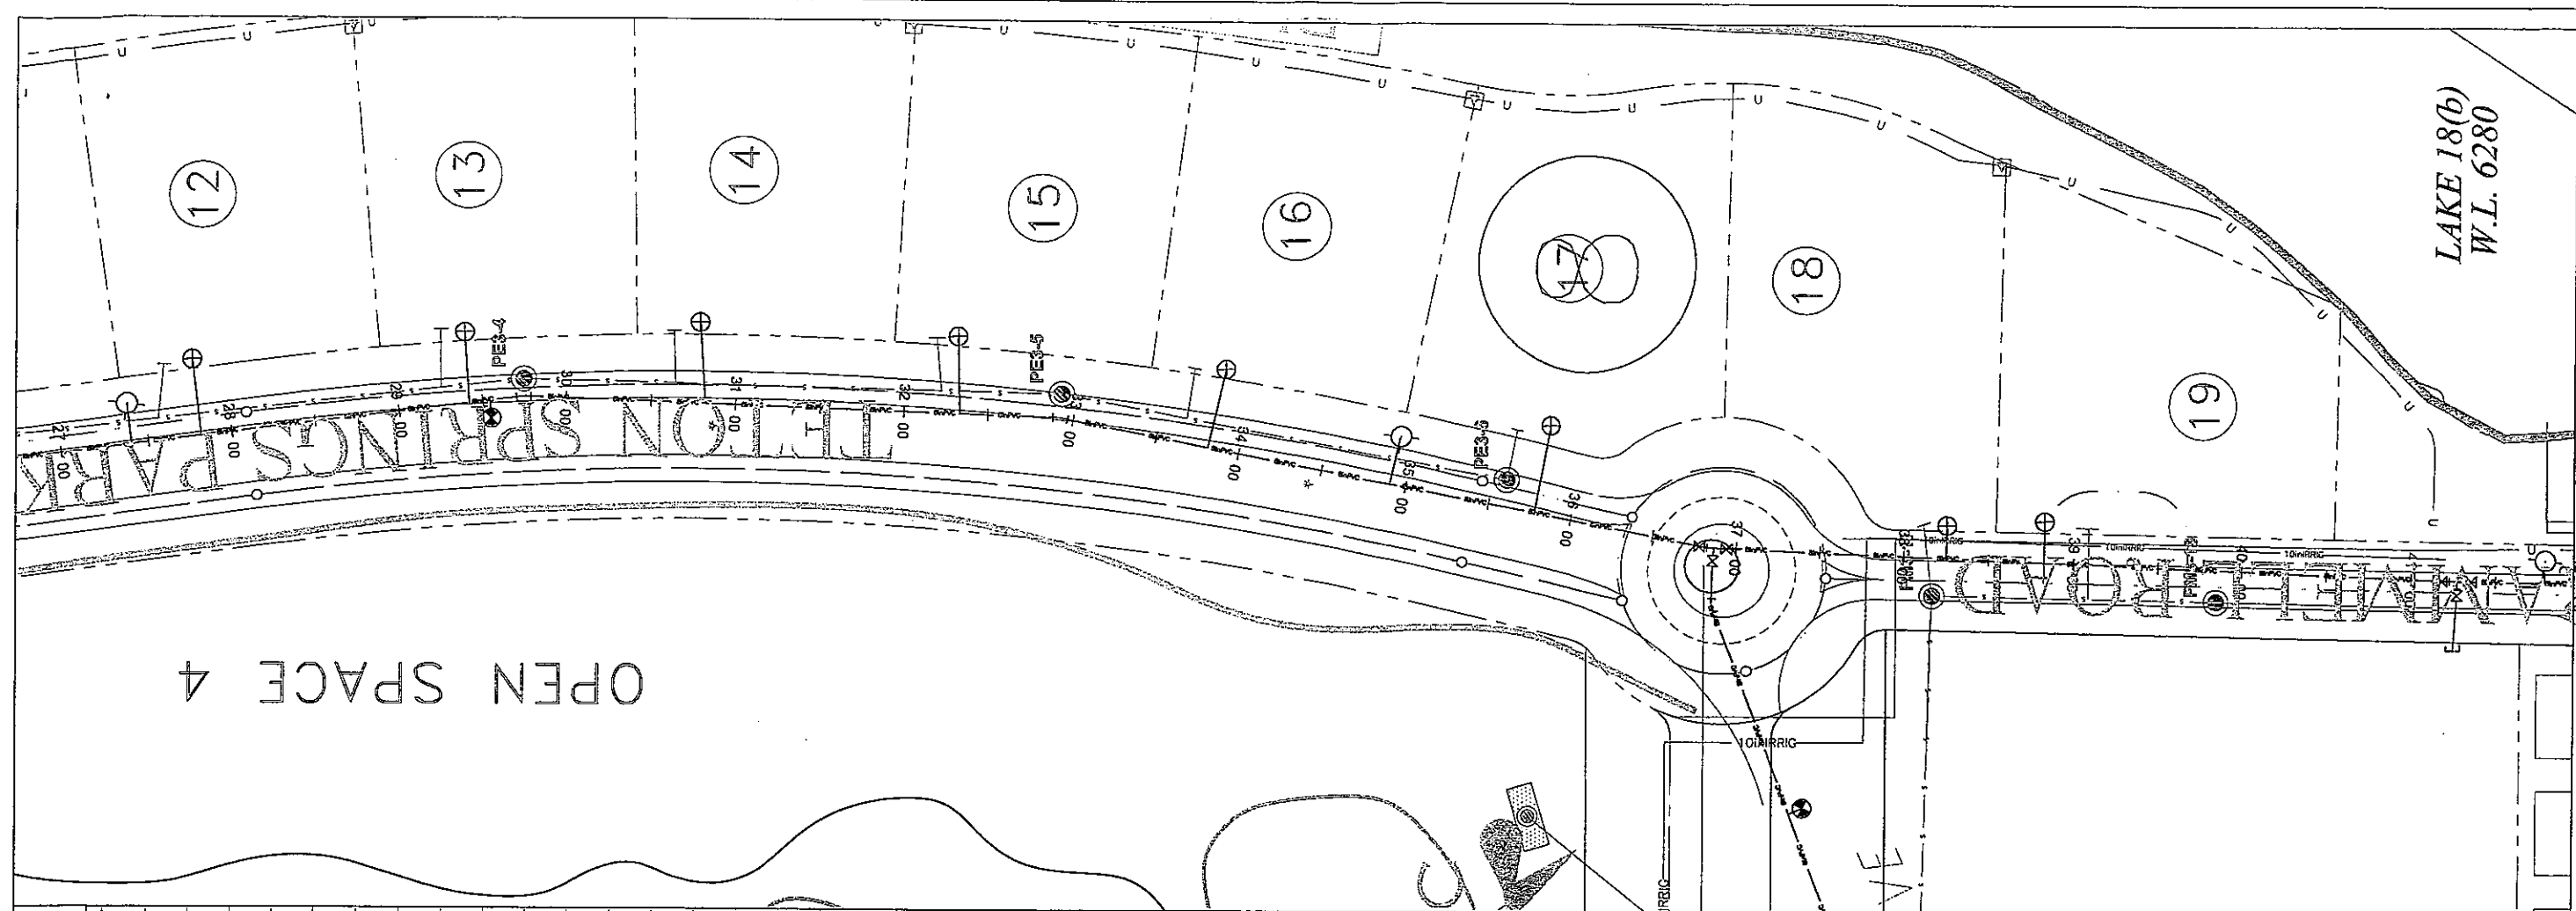

NOTES - THIS SHEET

GENERAL NOTES

Horizontal Scale: 1" = 50'
Vertical Scale: 1" = 5'

PROJECT TITLE:
TETON SPRINGS
RECORD DRAWINGS

PROJECT NUMBER:
00-023



DRAWING NUMBER:
ASBW13

DRAWING TITLE:
AS BUILT WATER PLAN & PROFILE
WATER MAIN 'D'
TETON SPRINGS PARKWAY

PROFESSIONAL ENGINEER
REGISTERED
STATE OF IDAHO
ROBERT J. ABLENDI
2994

RENDZVOUS ENGINEERING, P.C.
P.O. BOX 4858 JACKSON, WYOMING 83001
25 SOUTH GROS VENTRE STREET
PHONE - 307.733.5252 FAX - 307.733.2334

Prepared By: EDD
Date: 2/03
Rev. Date:
Plot Info:
Date: 2/03
PLOT:

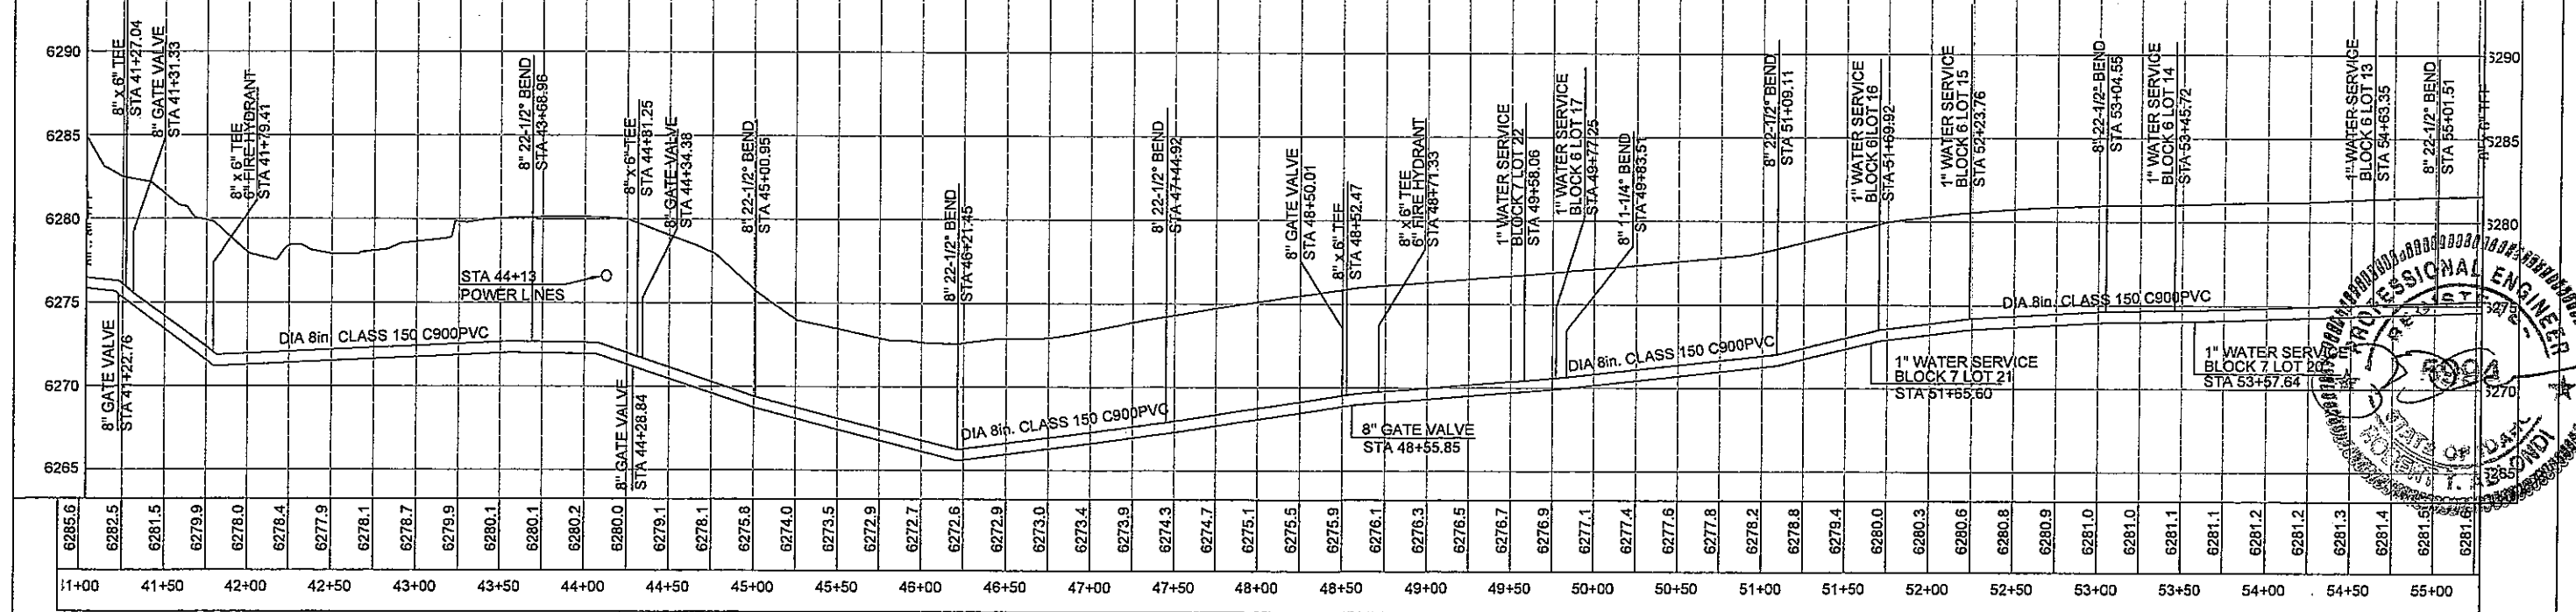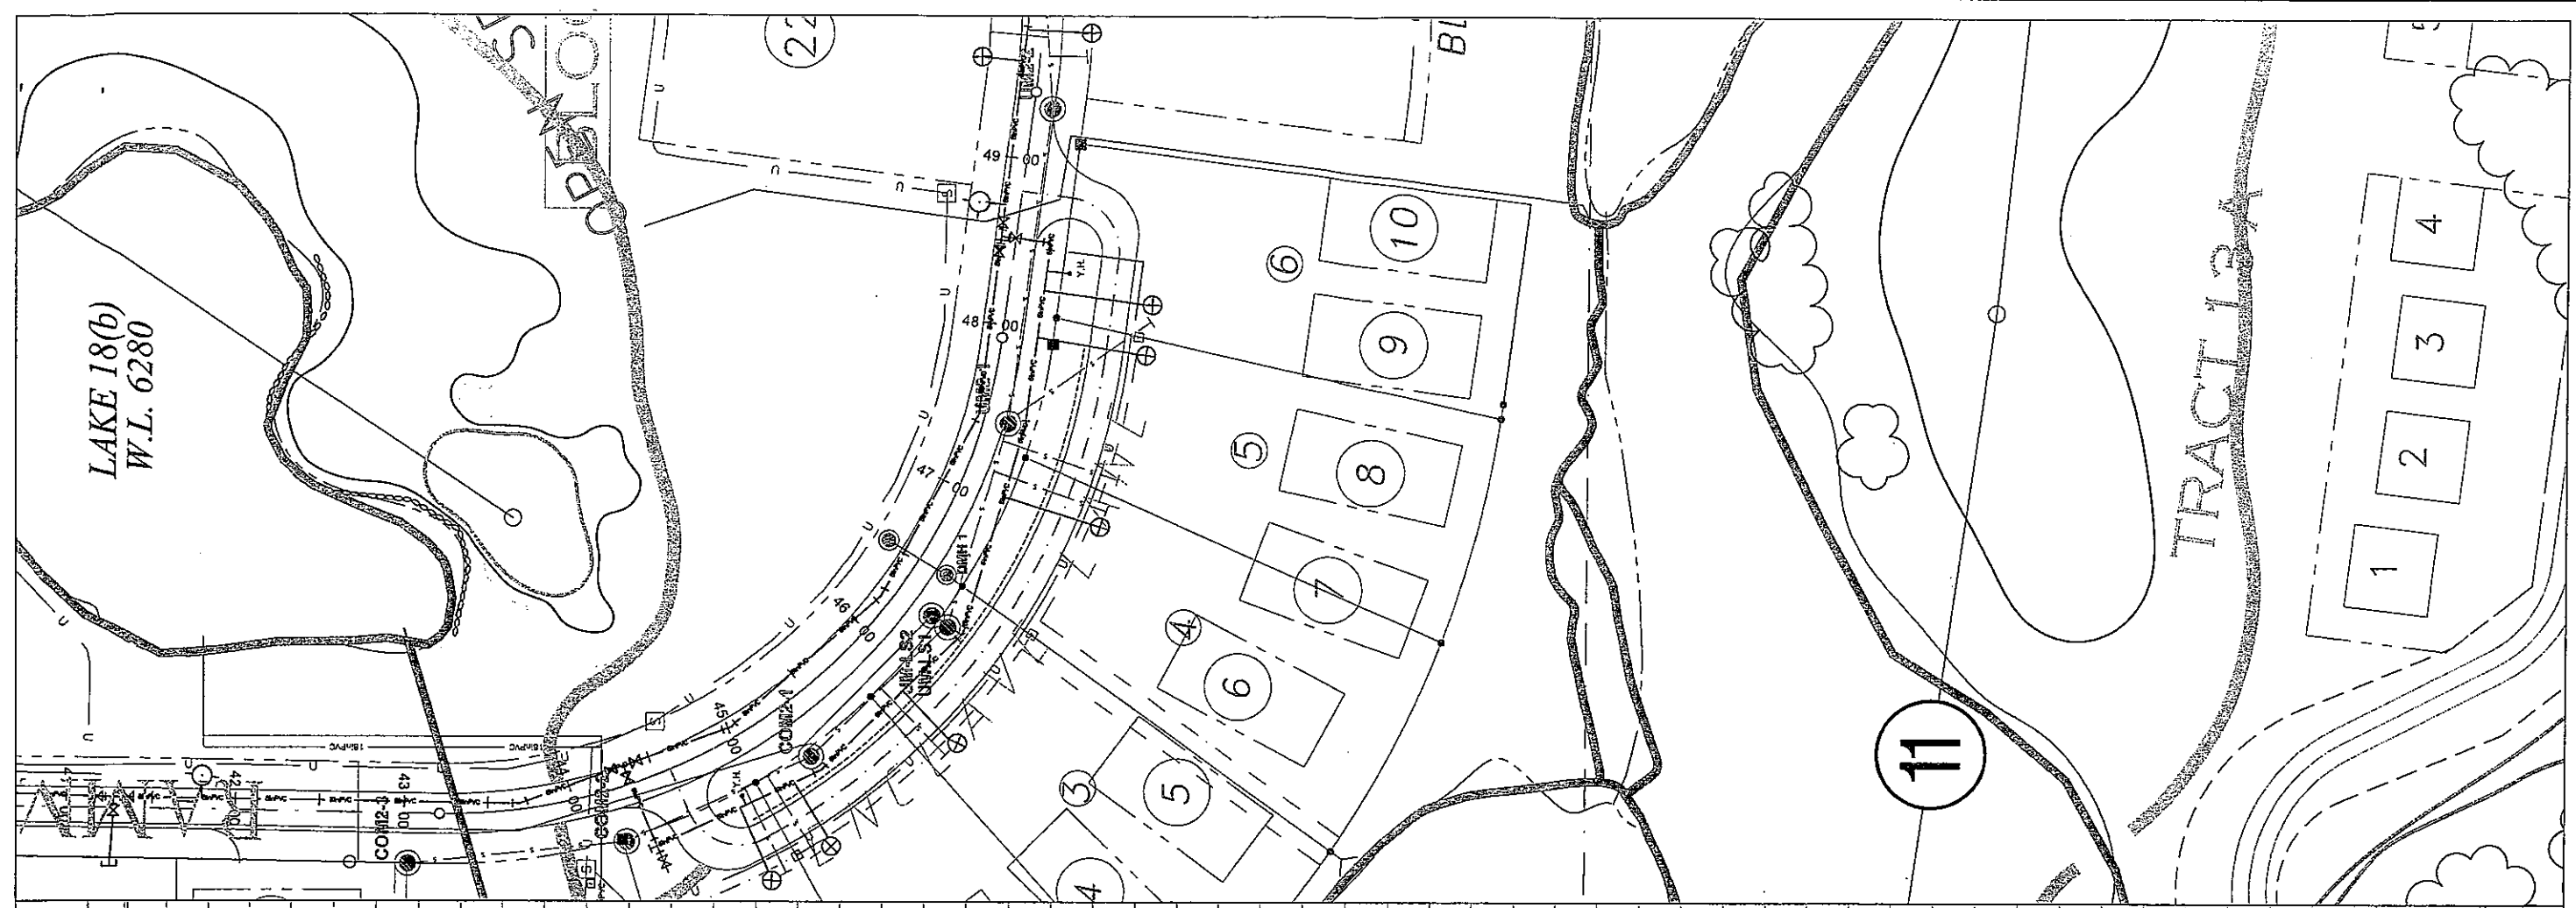

NOTES - THIS SHEET

GENERAL NOTES

Horizontal Scale: 1" = 50'
Vertical Scale: 1" = 5'



PROJECT TITLE:
TETON SPRINGS
RECORD DRAWINGS

DRAWING TITLE:
AS BUILT WATER PLAN & PROFILE
WATER MAIN 'D'
RAMMELL ROAD

PREPARED BY: EDO
DATE: 203
REV. DATE:
REV. INFO:
DATA
PATH:

RENDEZVOUS ENGINEERING, P.C.
P.O. BOX 4359 JACKSON, WYOMING 83001
25 SOUTH GROSVENTRE STREET
PHONE - 307.733.5252 FAX - 307.733.2334

PROJECT NUMBER:
00-023
DRAWING NUMBER:
ASBW14

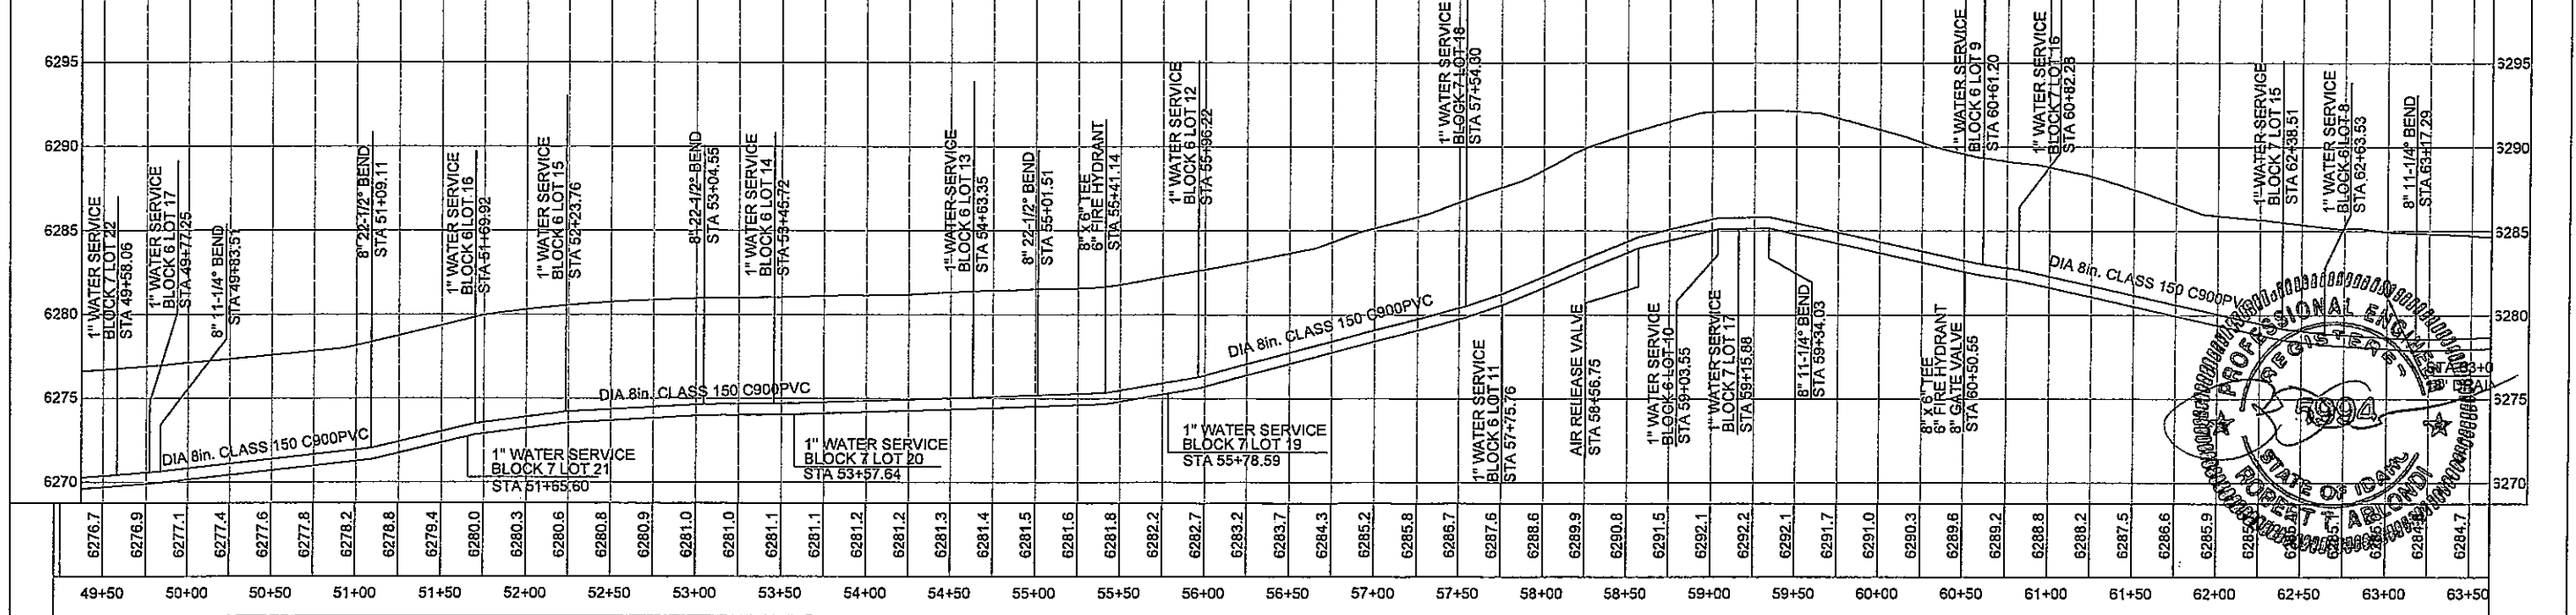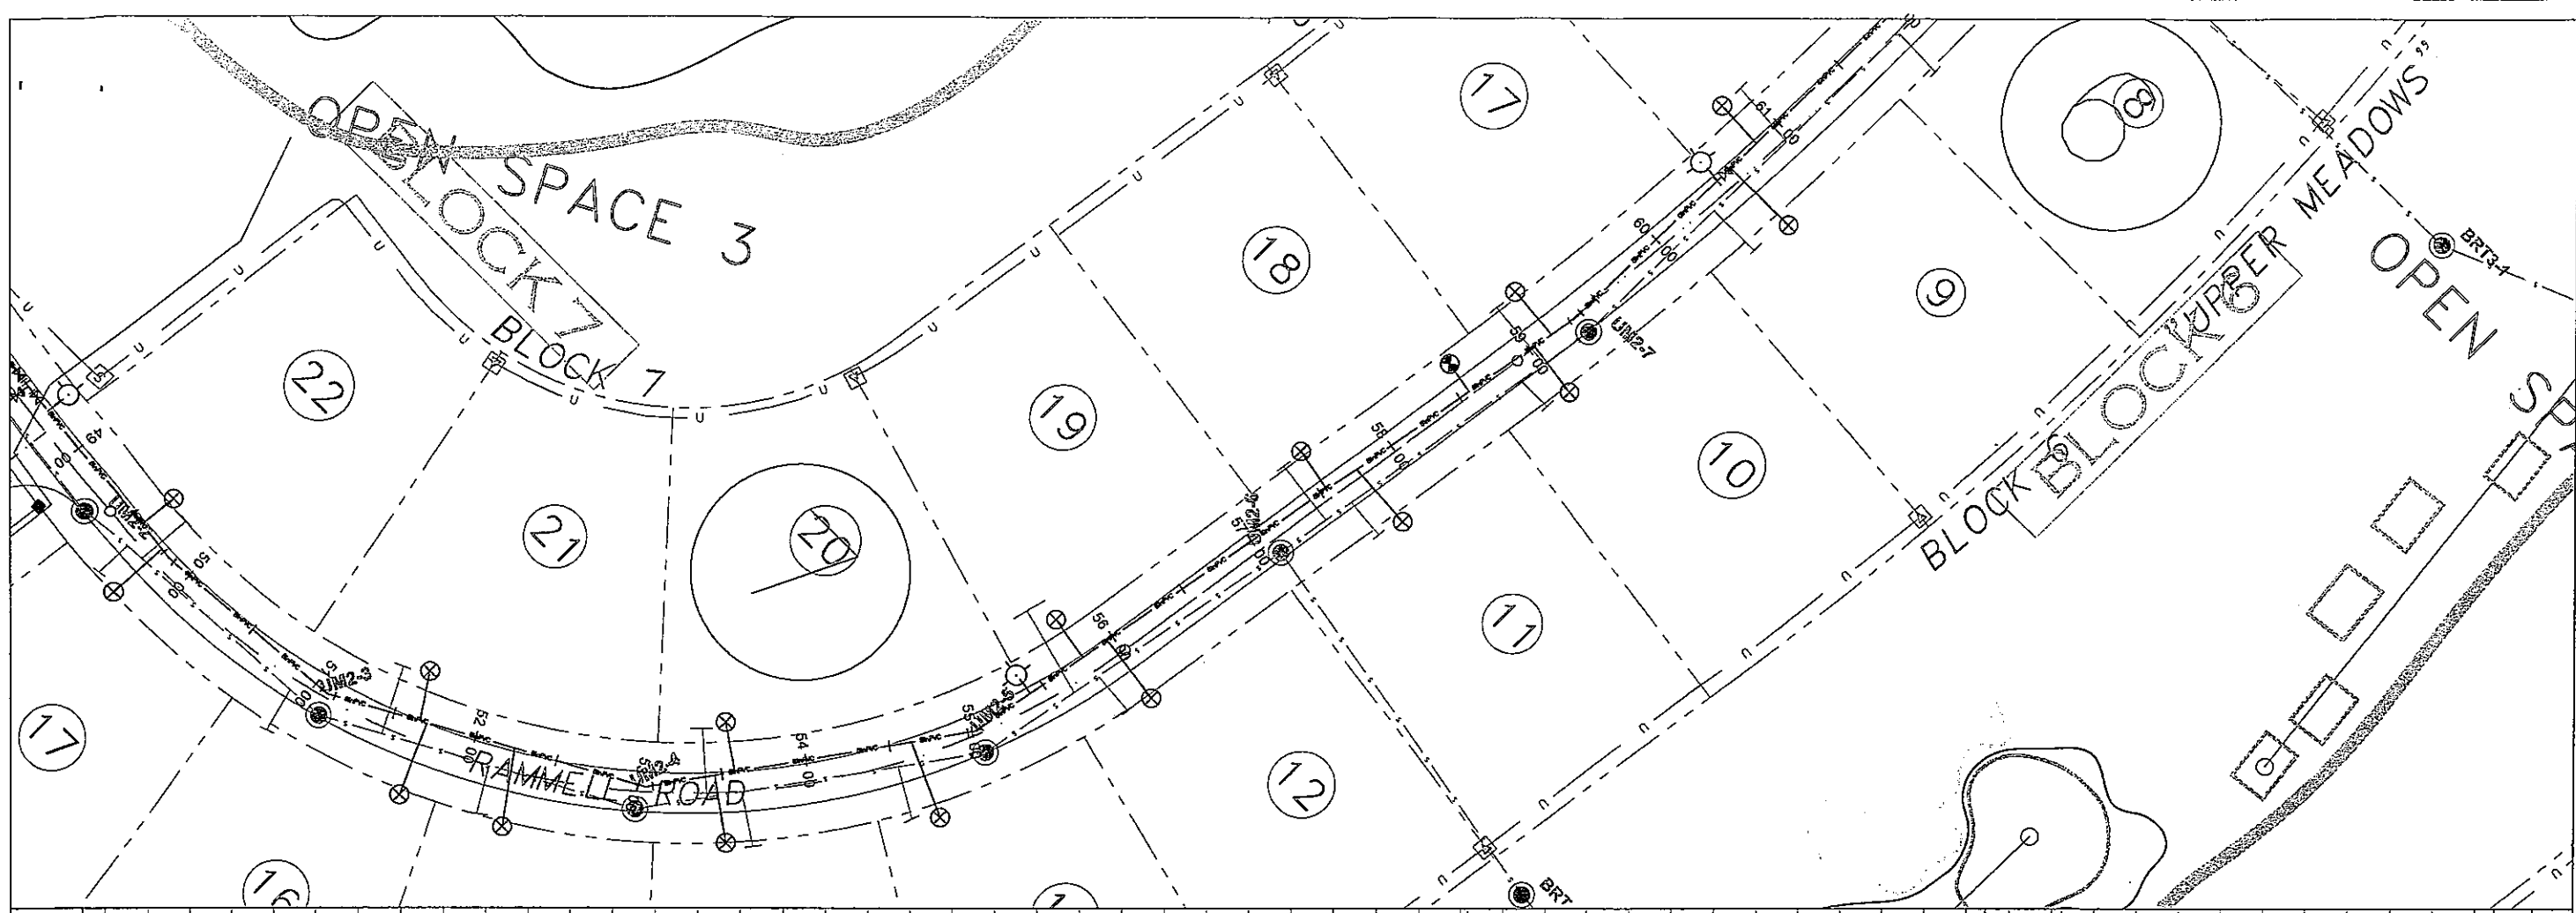

NOTES - THIS SHEET

GENERAL NOTES

Horizontal Scale: 1" = 50'
Vertical Scale: 1" = 5'

Prepared By: and
Date: 2023
Rev. Date:
Plot Info:
Data:
Path:



RENDEZVOUS ENGINEERING, P.C.
P.O. BOX 4858 JACKSON, WYOMING 83001
25 SOUTH GROS VENTRE STREET
PHONE - 307.733.5252 FAX - 307.733.2334

DRAWING TITLE:
**AS BUILT WATER PLAN & PROFILE
WATER MAIN 'D'
RAMMELL ROAD**

PROJECT TITLE:
**TETON SPRINGS
RECORD DRAWINGS**

PROJECT NUMBER:
00-023
DRAWING NUMBER:
ASBW15

STATE OF IDAHO
DAVID L. ARONSON, PE
CIVIL ENGINEERING
LICENSE NO. 5994

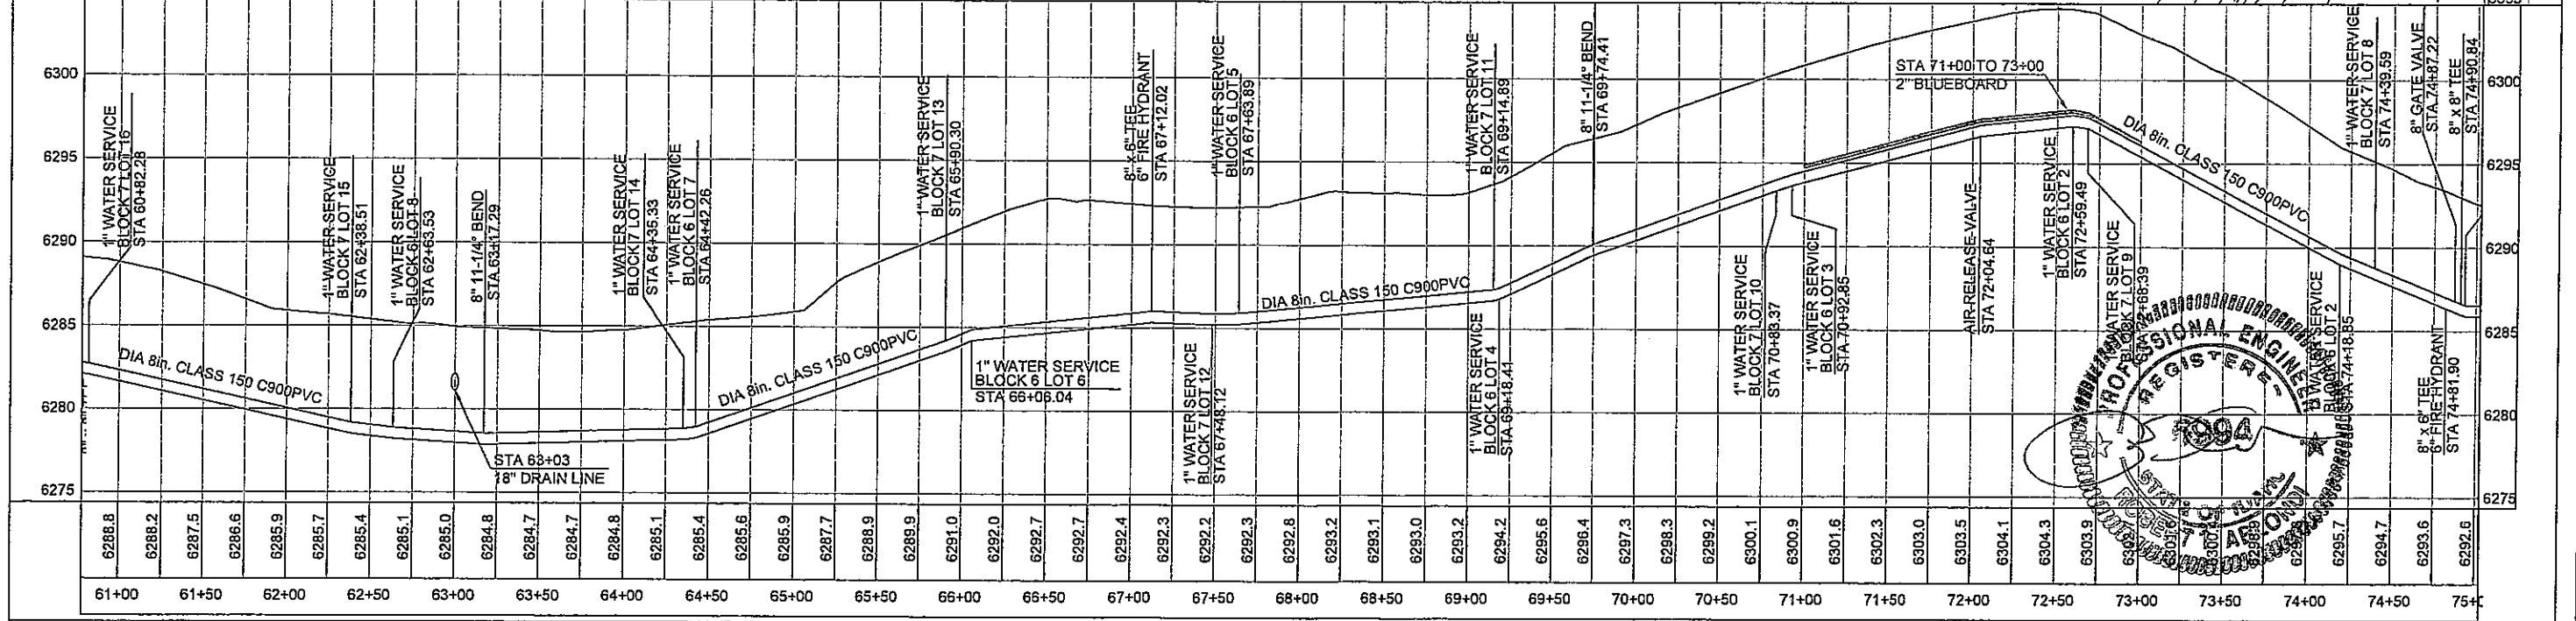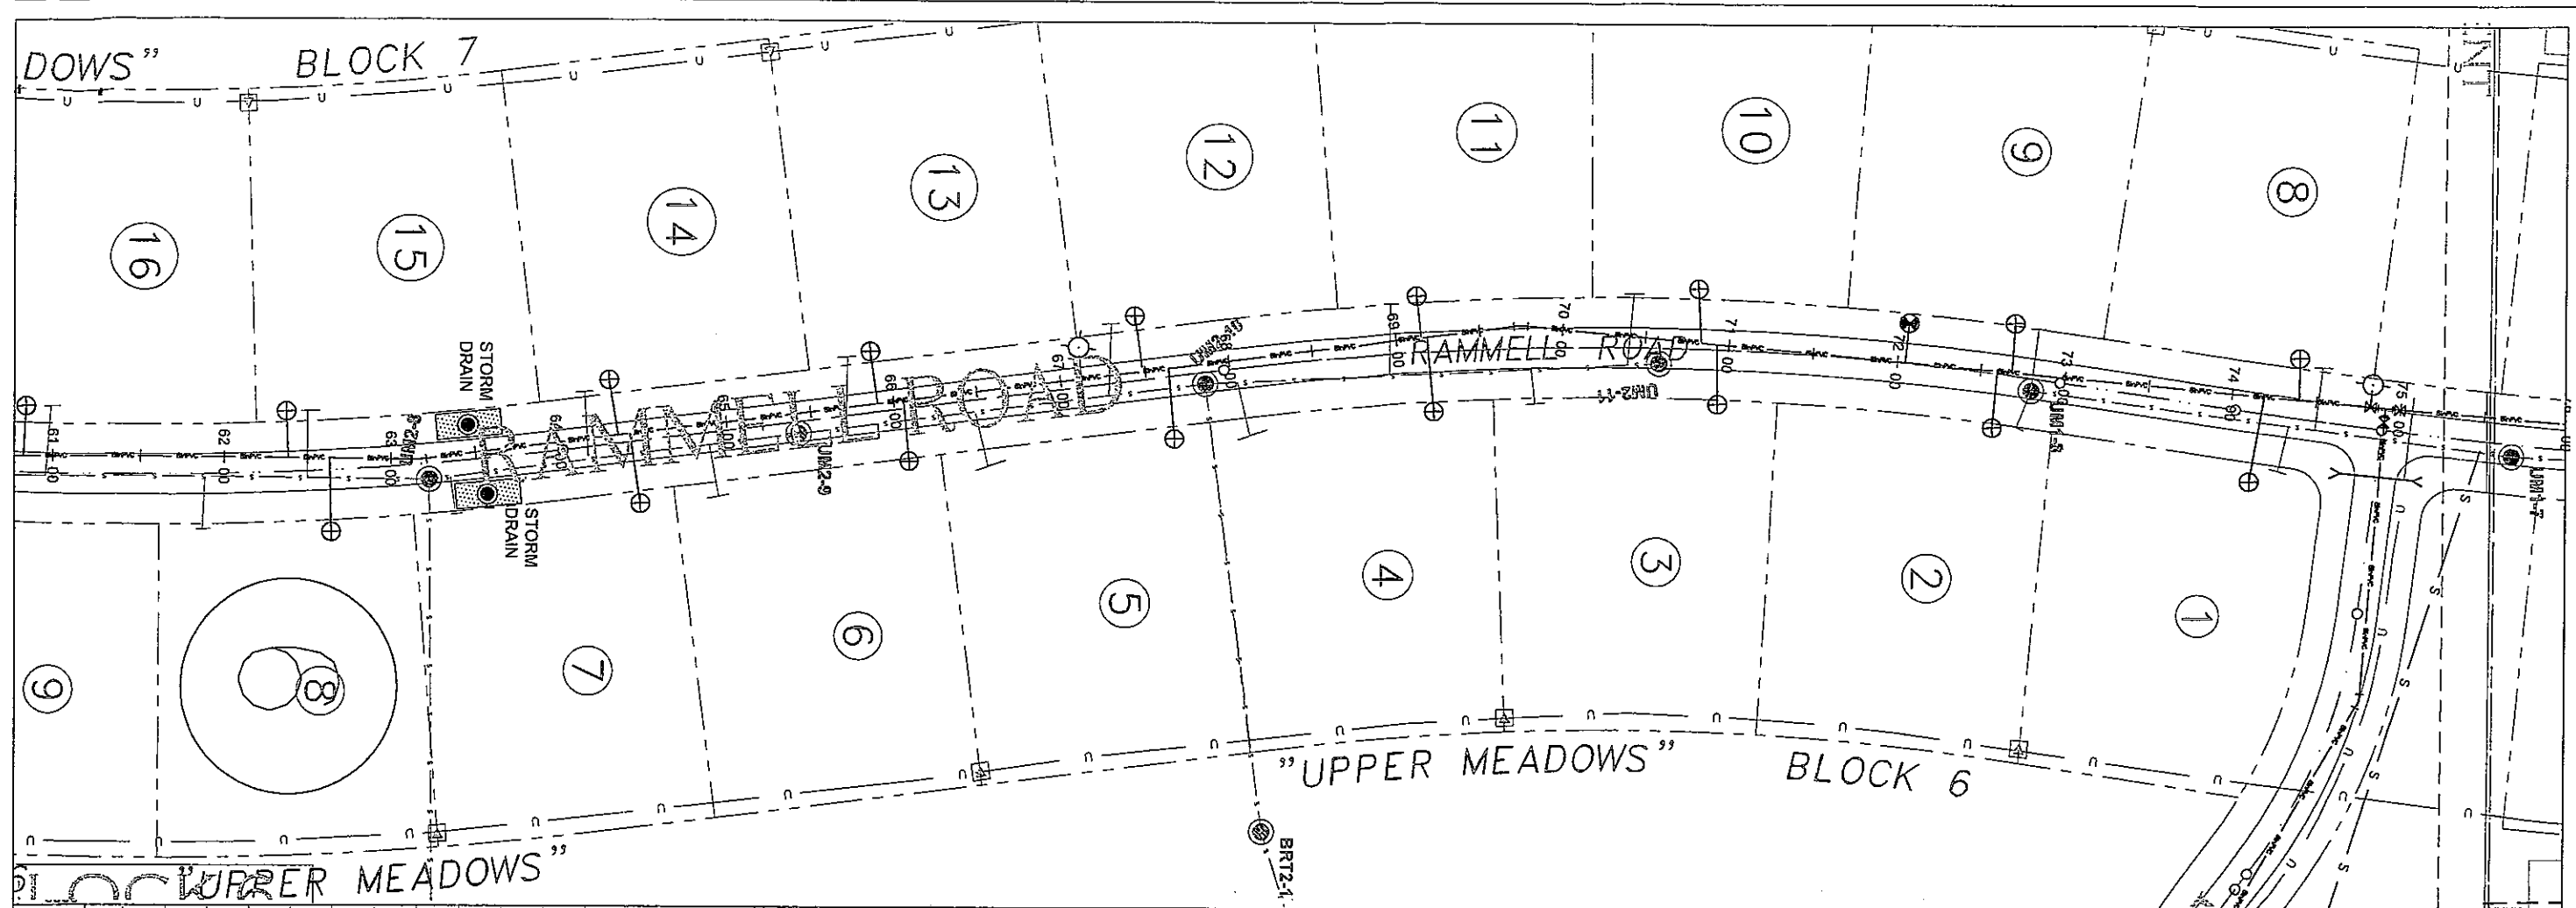


NOTES - THIS SHEET

GENERAL NOTES

Horizontal Scale: 1" = 50'

Vertical Scale: 1" = 5'

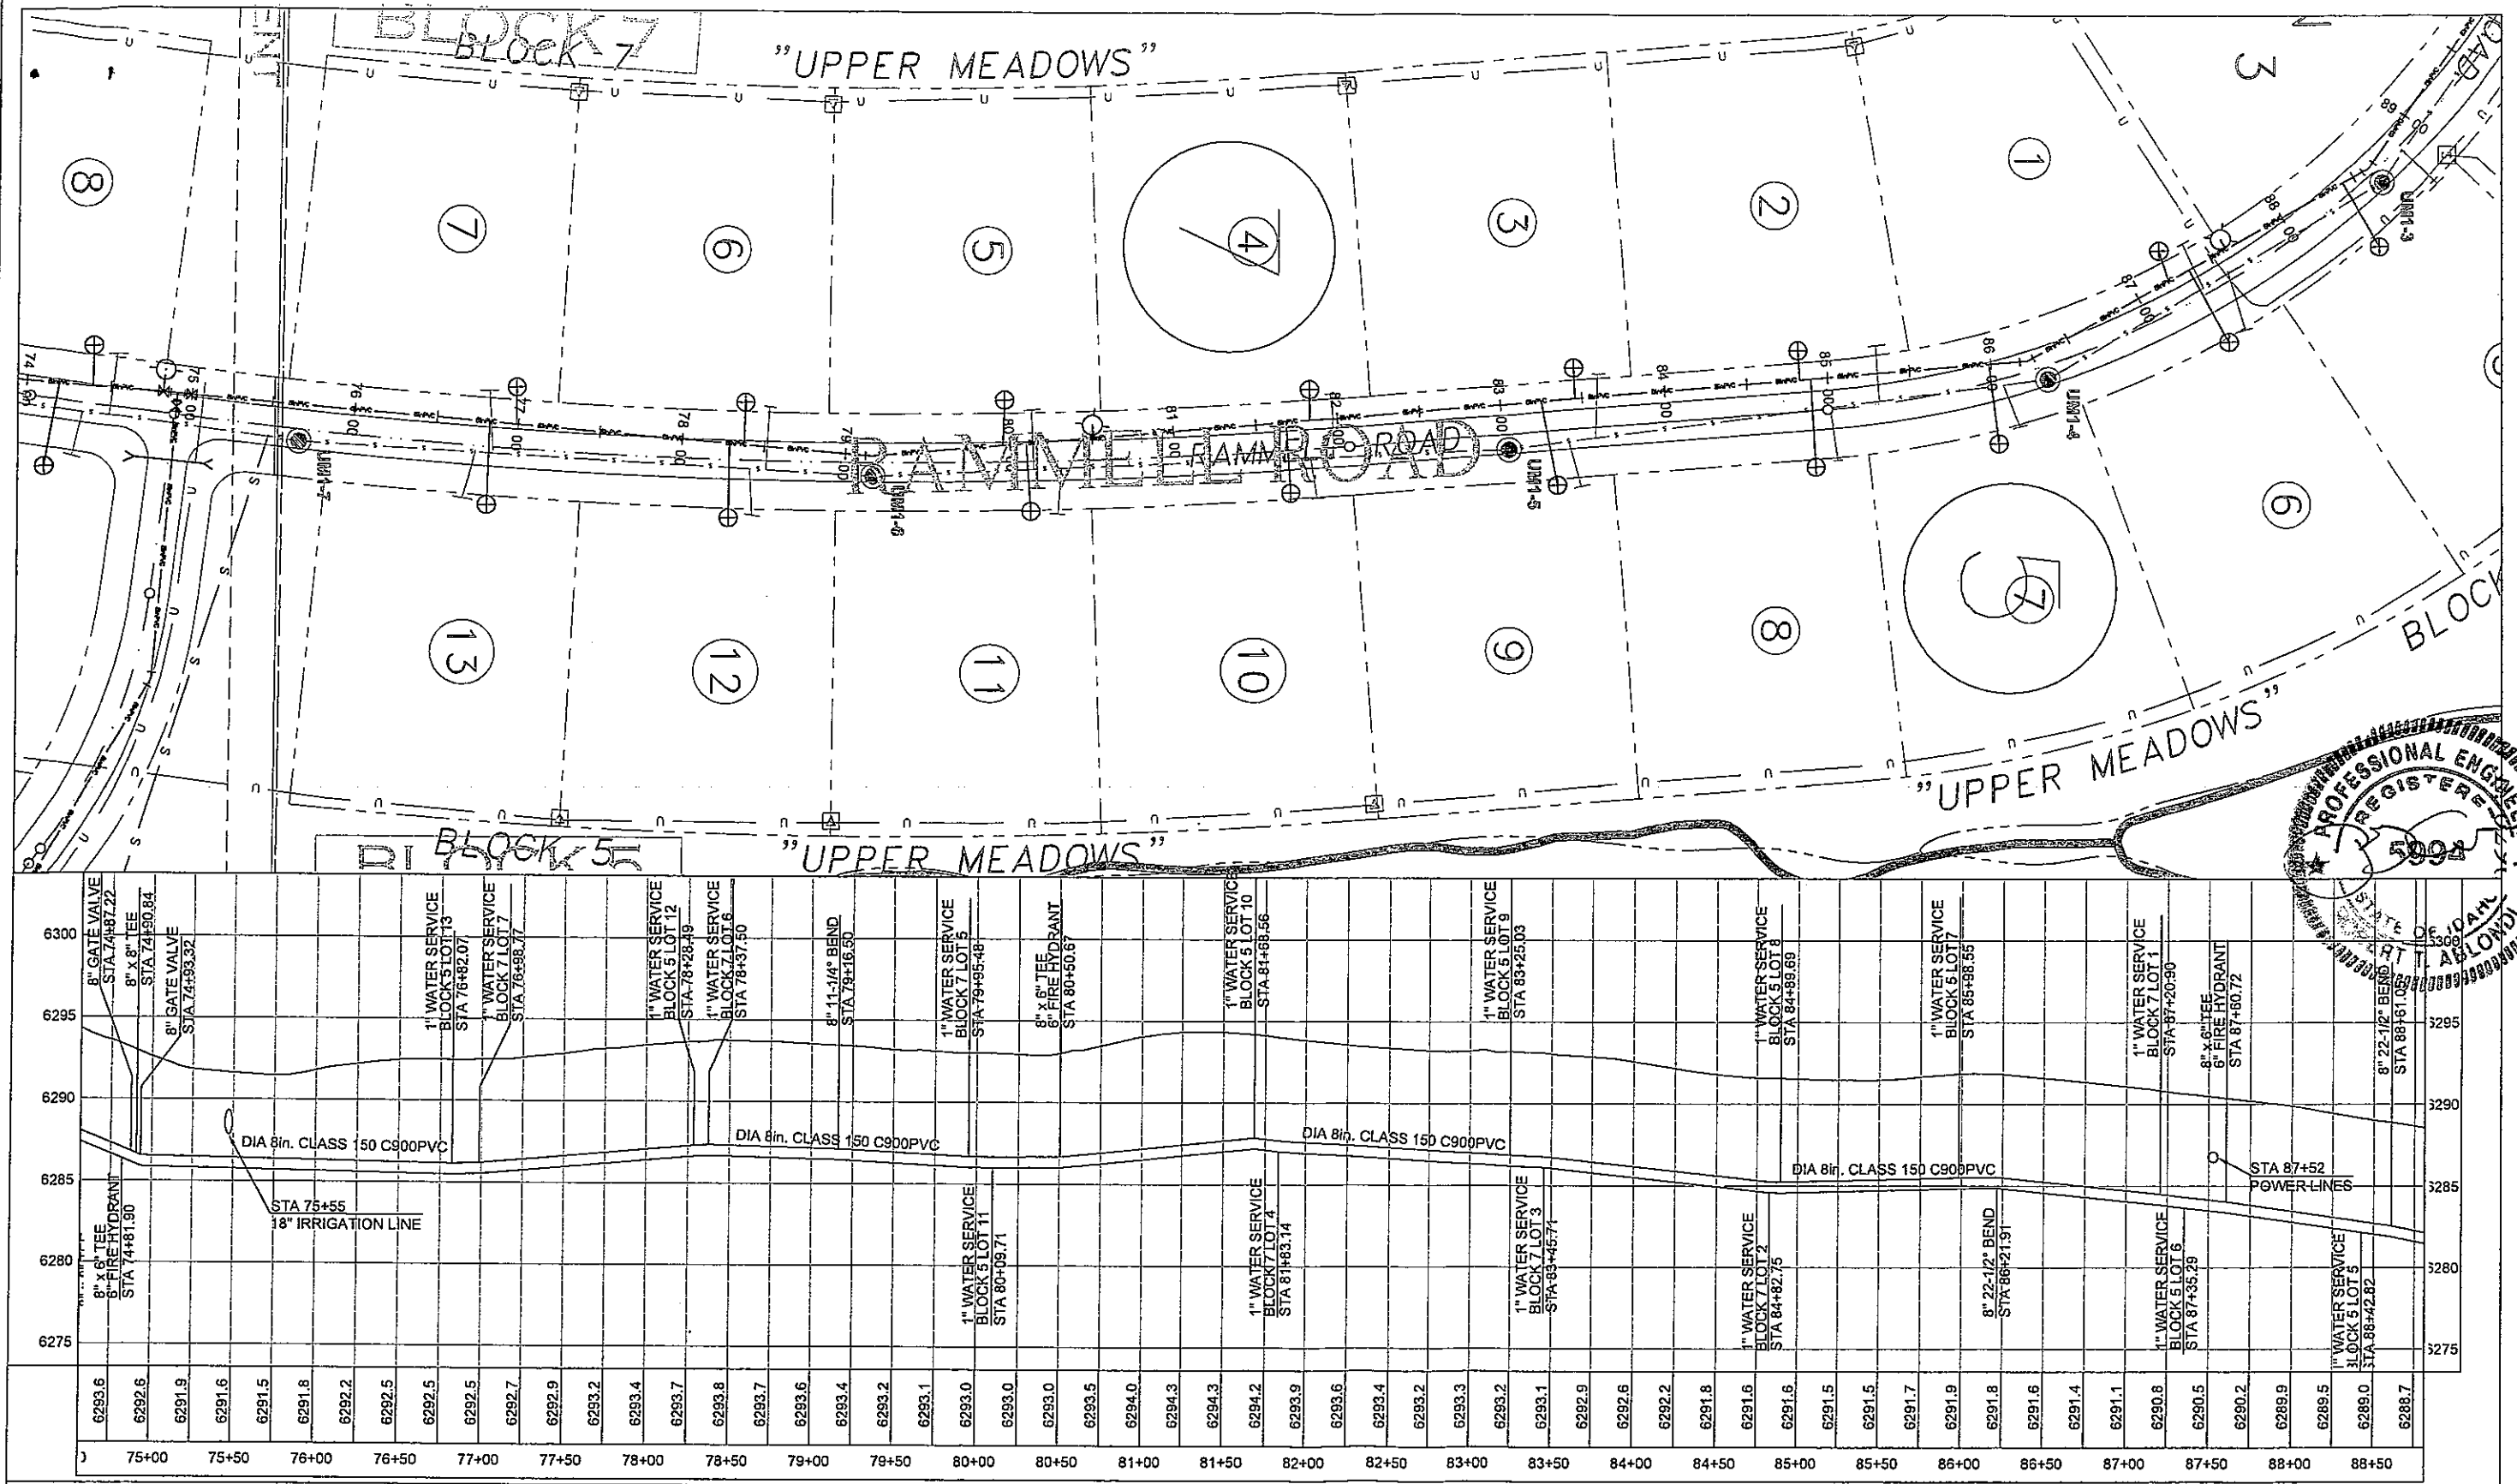

NOTES - THIS SHEET

GENERAL NOTES

Horizontal Scale: 1" = 50'
Vertical Scale: 1" = 5'

PROJECT TITLE:
TETON SPRINGS
RECORD DRAWINGS

PROJECT NUMBER:
00-023

DRAWING NUMBER:
ASBW17

DRAWING TITLE:
AS BUILT WATER PLAN & PROFILE
WATER MAIN 'D'
RAMMELL ROAD

DATE: 01/11/2011

DATE: 01/11/2011

PREPARED BY: EDO

DATE: 01/11/2011

REV. DATE: 01/11/2011

REV. DATE: 01/11/2011

DATE: 01/11/2011




DATE: 01/11/2011

RENDZVOUS ENGINEERING, P.C.

P.O. BOX 4858 JACKSON, WYOMING 83001

25 SOUTH GROS VENTRE STREET

PHONE - 307.733.3252 FAX - 307.733.3334

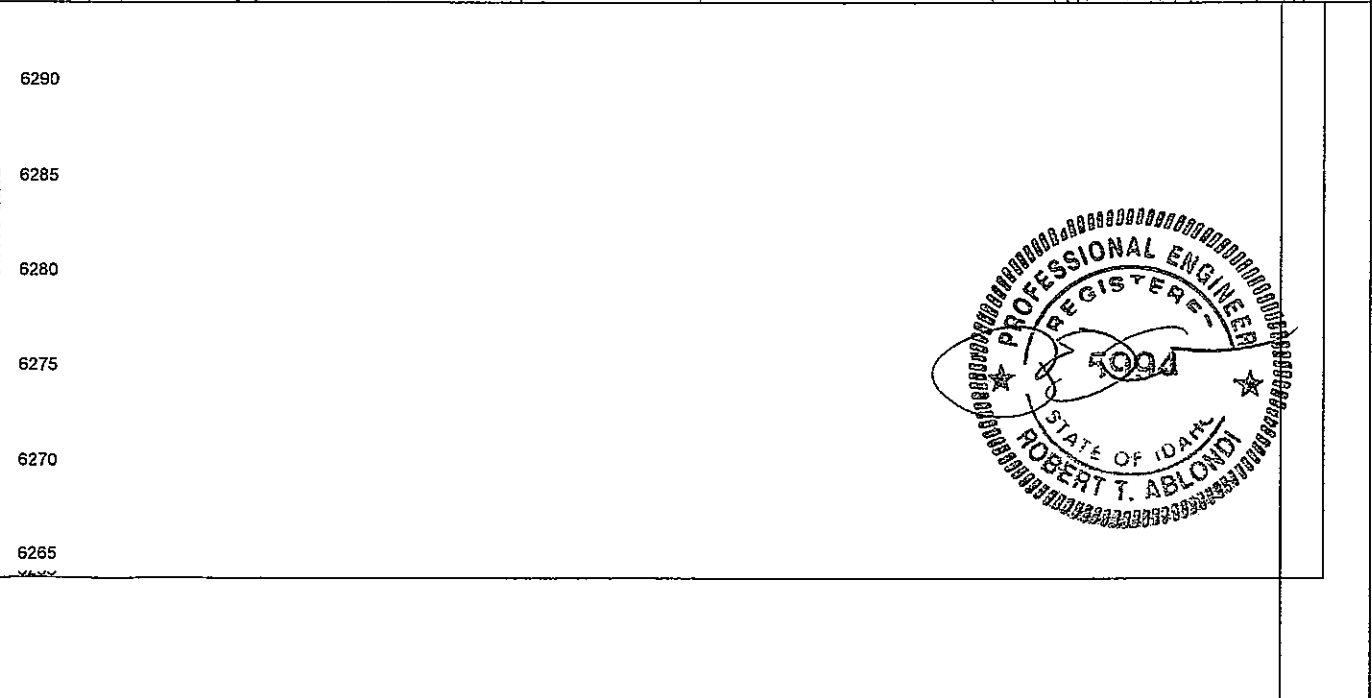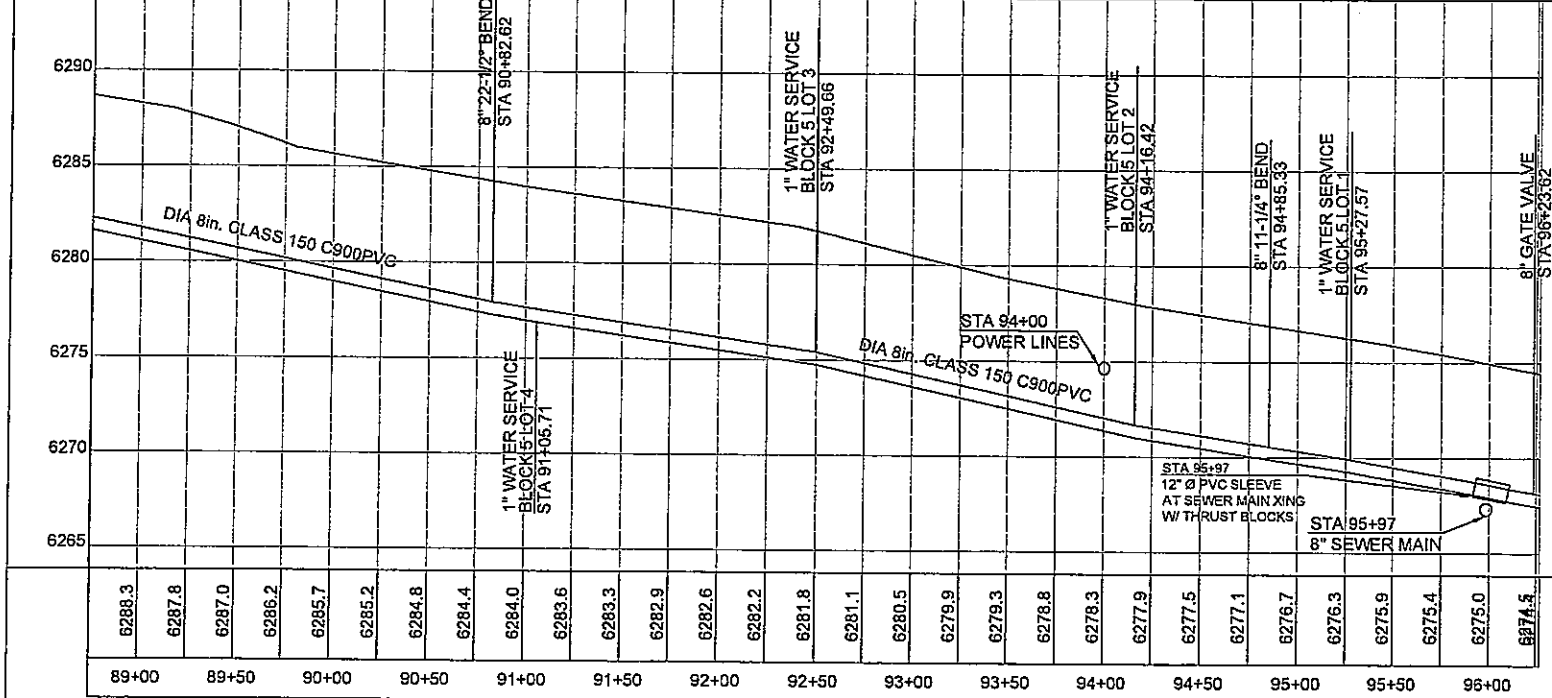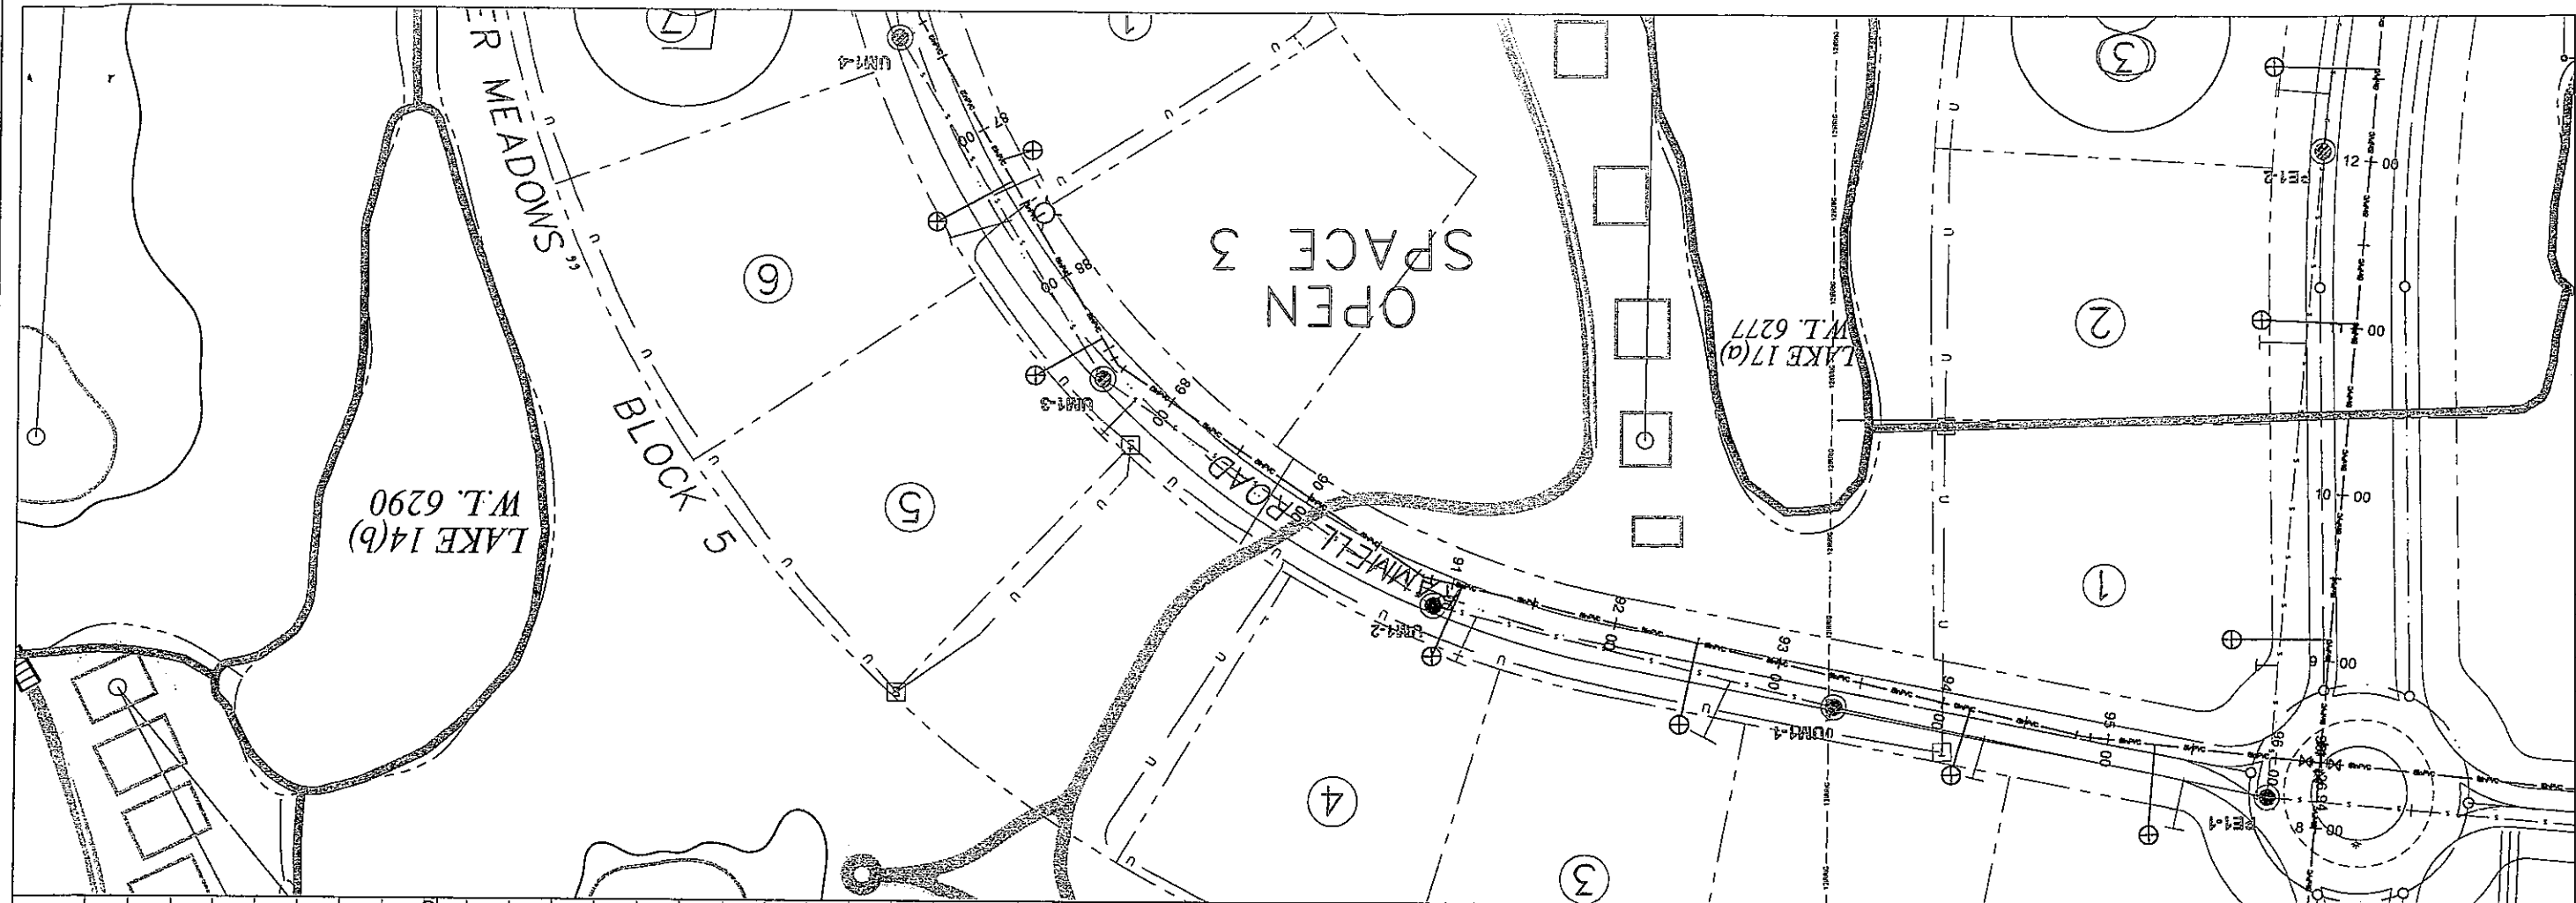


NOTES - THIS SHEET


GENERAL NOTES



Horizontal Scale: 1" = 50'
Vertical Scale: 1" = 5'

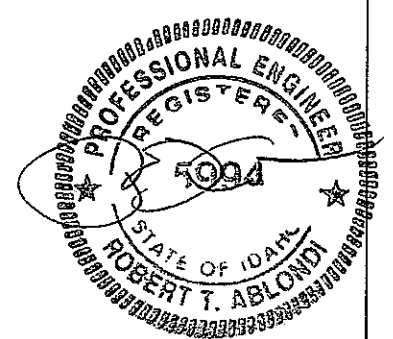


	RENDZVOUS ENGINEERING, P.C.	
	Prepared By: EBD	Date: 203
	Rev. Date:	Rev. Date:
	P.O. BOX 4858 JACKSON, WYOMING 83001 25 SOUTH GROS VENTRE STREET PHONE - 307.733.5252 FAX - 307.733.2334	
PROJECT TITLE: TETON SPRINGS RECORD DRAWINGS		DRAWING TITLE: AS BUILT WATER PLAN & PROFILE WATER MAIN 'D' RAMMELL ROAD
PROJECT NUMBER: 00-023		DRAWING NUMBER: ASBW18

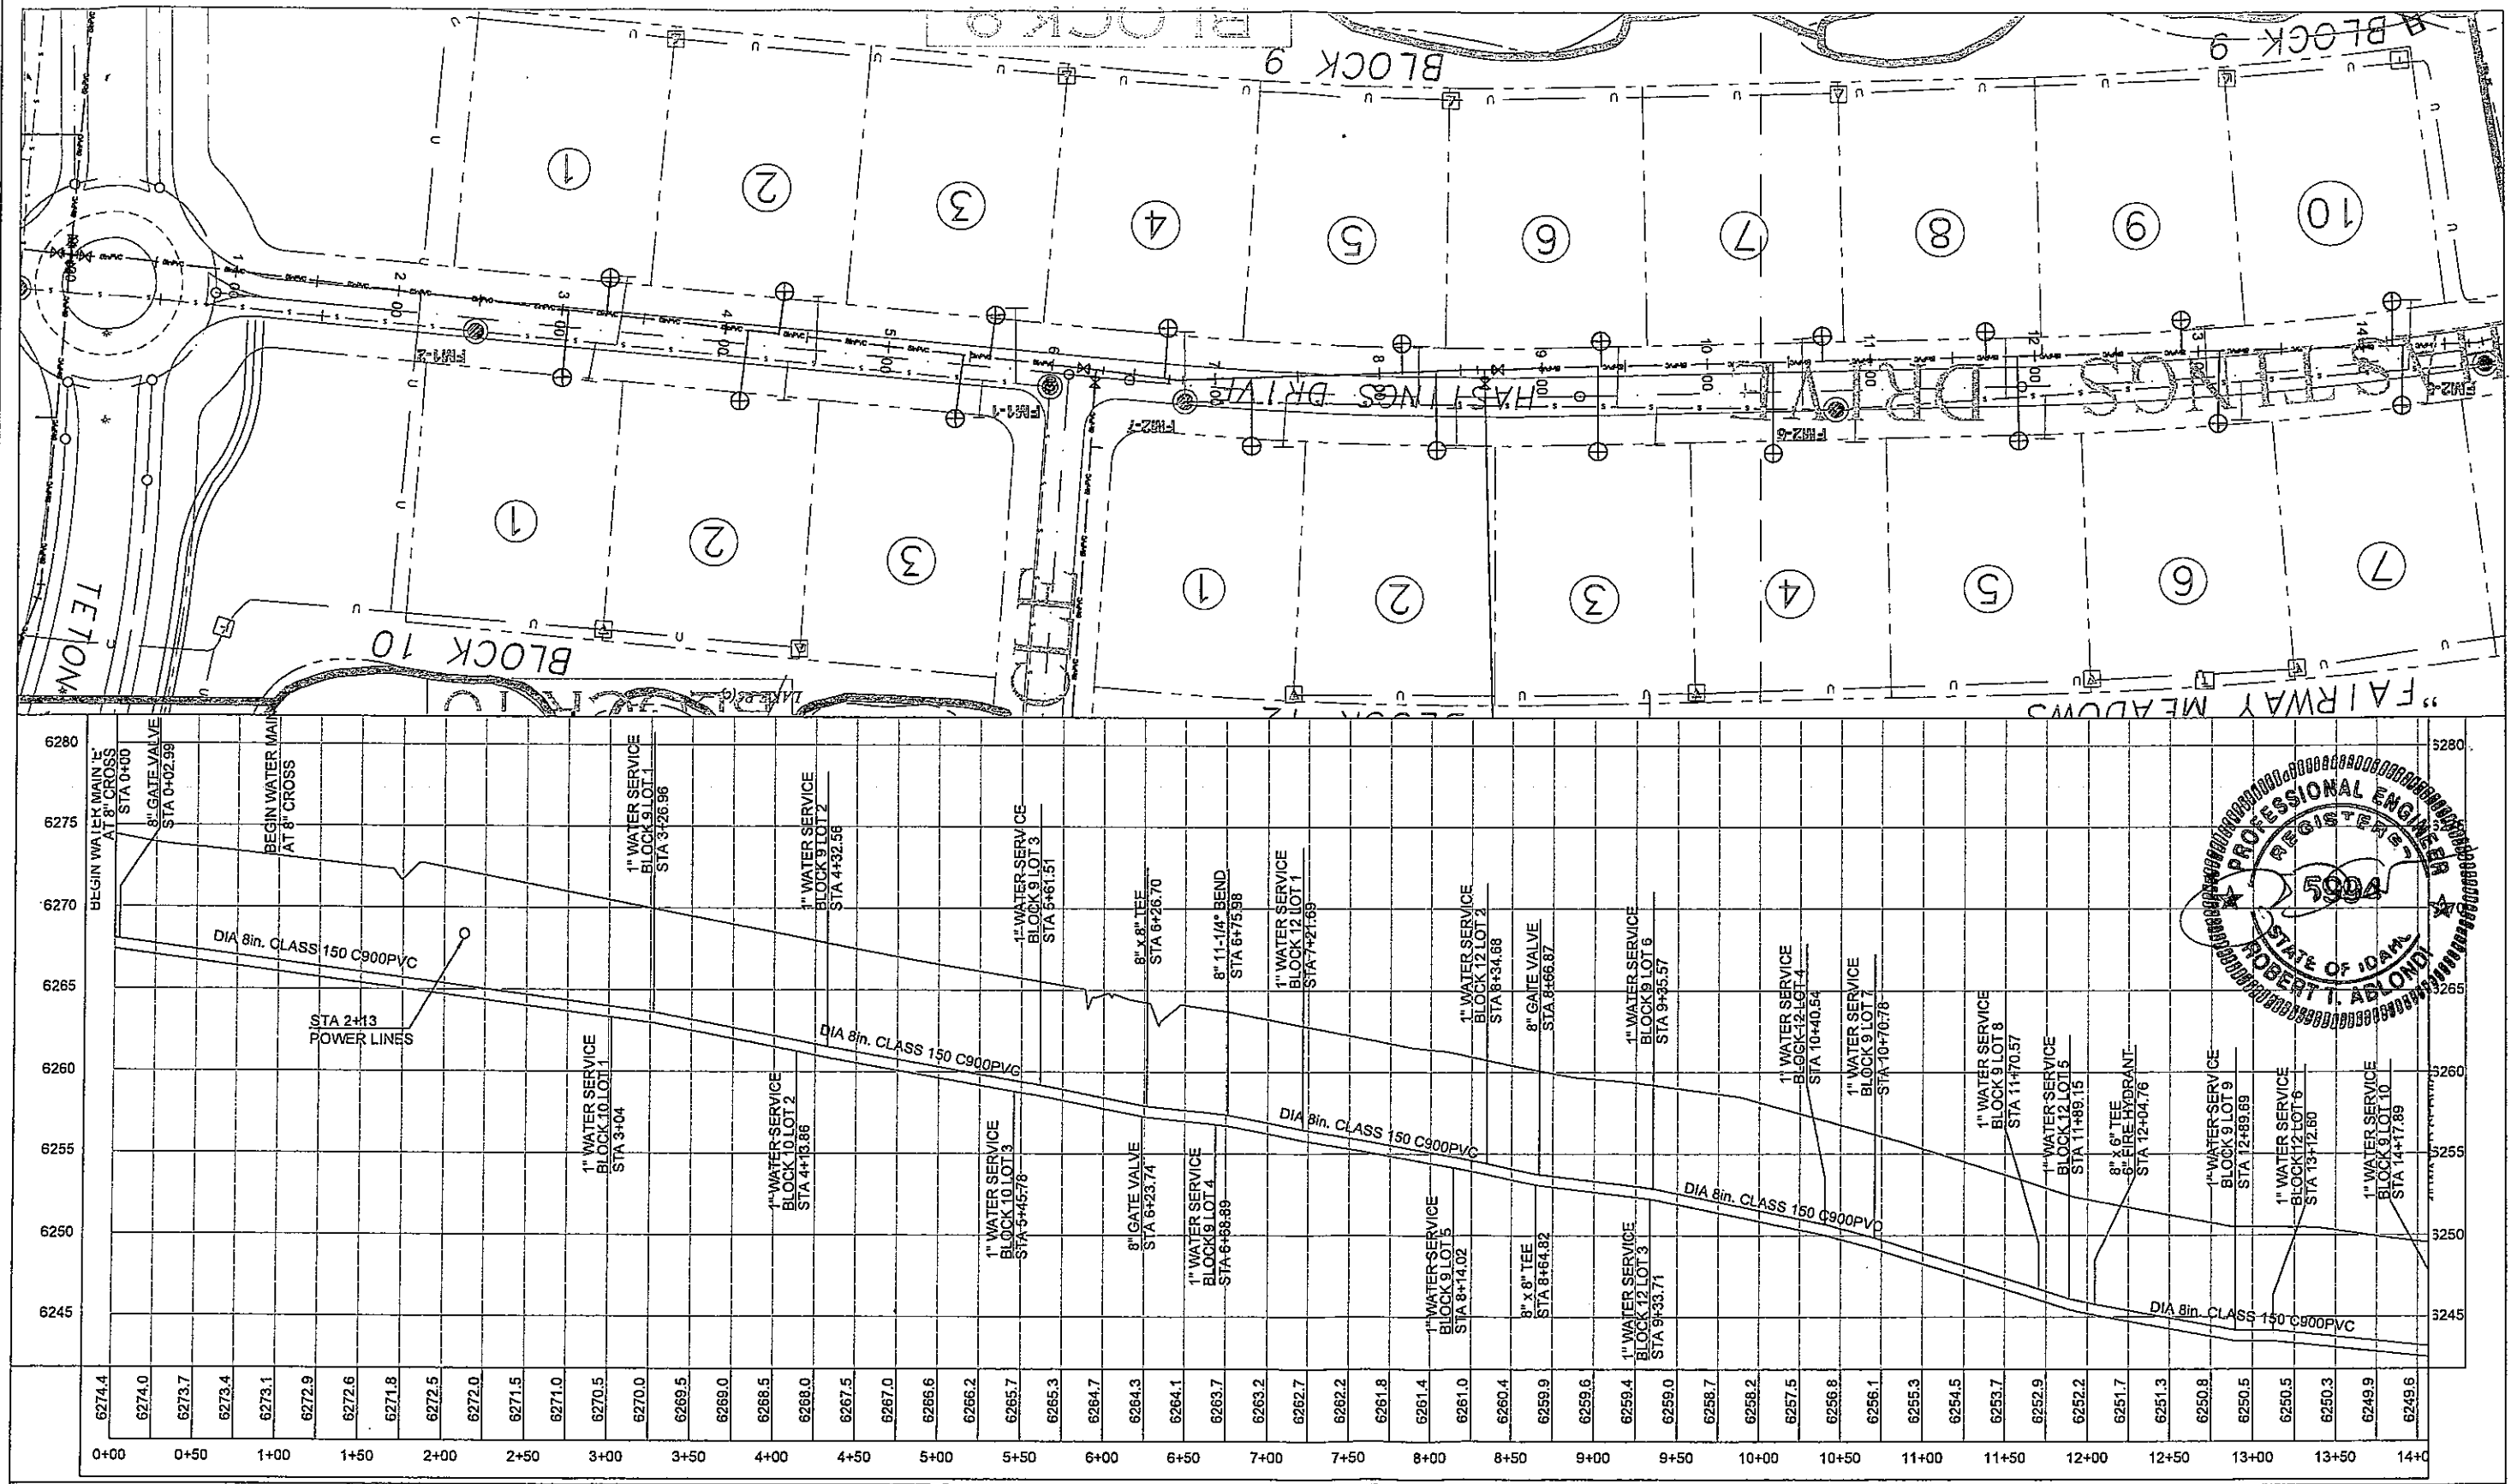

NOTES - THIS SHEET

GENERAL NOTES

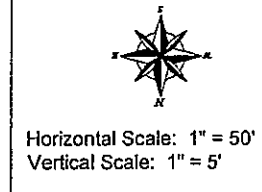

PROJECT TITLE:
TETON SPRINGS
RECORD DRAWINGS

PROJECT
NUMBER:
00-023

DRAWING
NUMBER:
ASBW19

DRAWING TITLE:
AS BUILT WATER PLAN & PROFILE
WATER MAIN 'E'
HASTINGS DRIVE

PROFESSIONAL ENGINEER
REGISTERED
STATE OF IDAHO
5994
ROBERT T. ABLENDI

RENDZVOUS ENGINEERING, P.C.

P.O. BOX 4859 JACKSON, WYOMING 83001
25 SOUTH GROS VENTURE STREET
PHONE - 307.733.9252 FAX - 307.733.2334

Prepared By: EDO



Date: 2003

Rev. Date:

Plot Info:

Date: 10/10/2003

Printed:

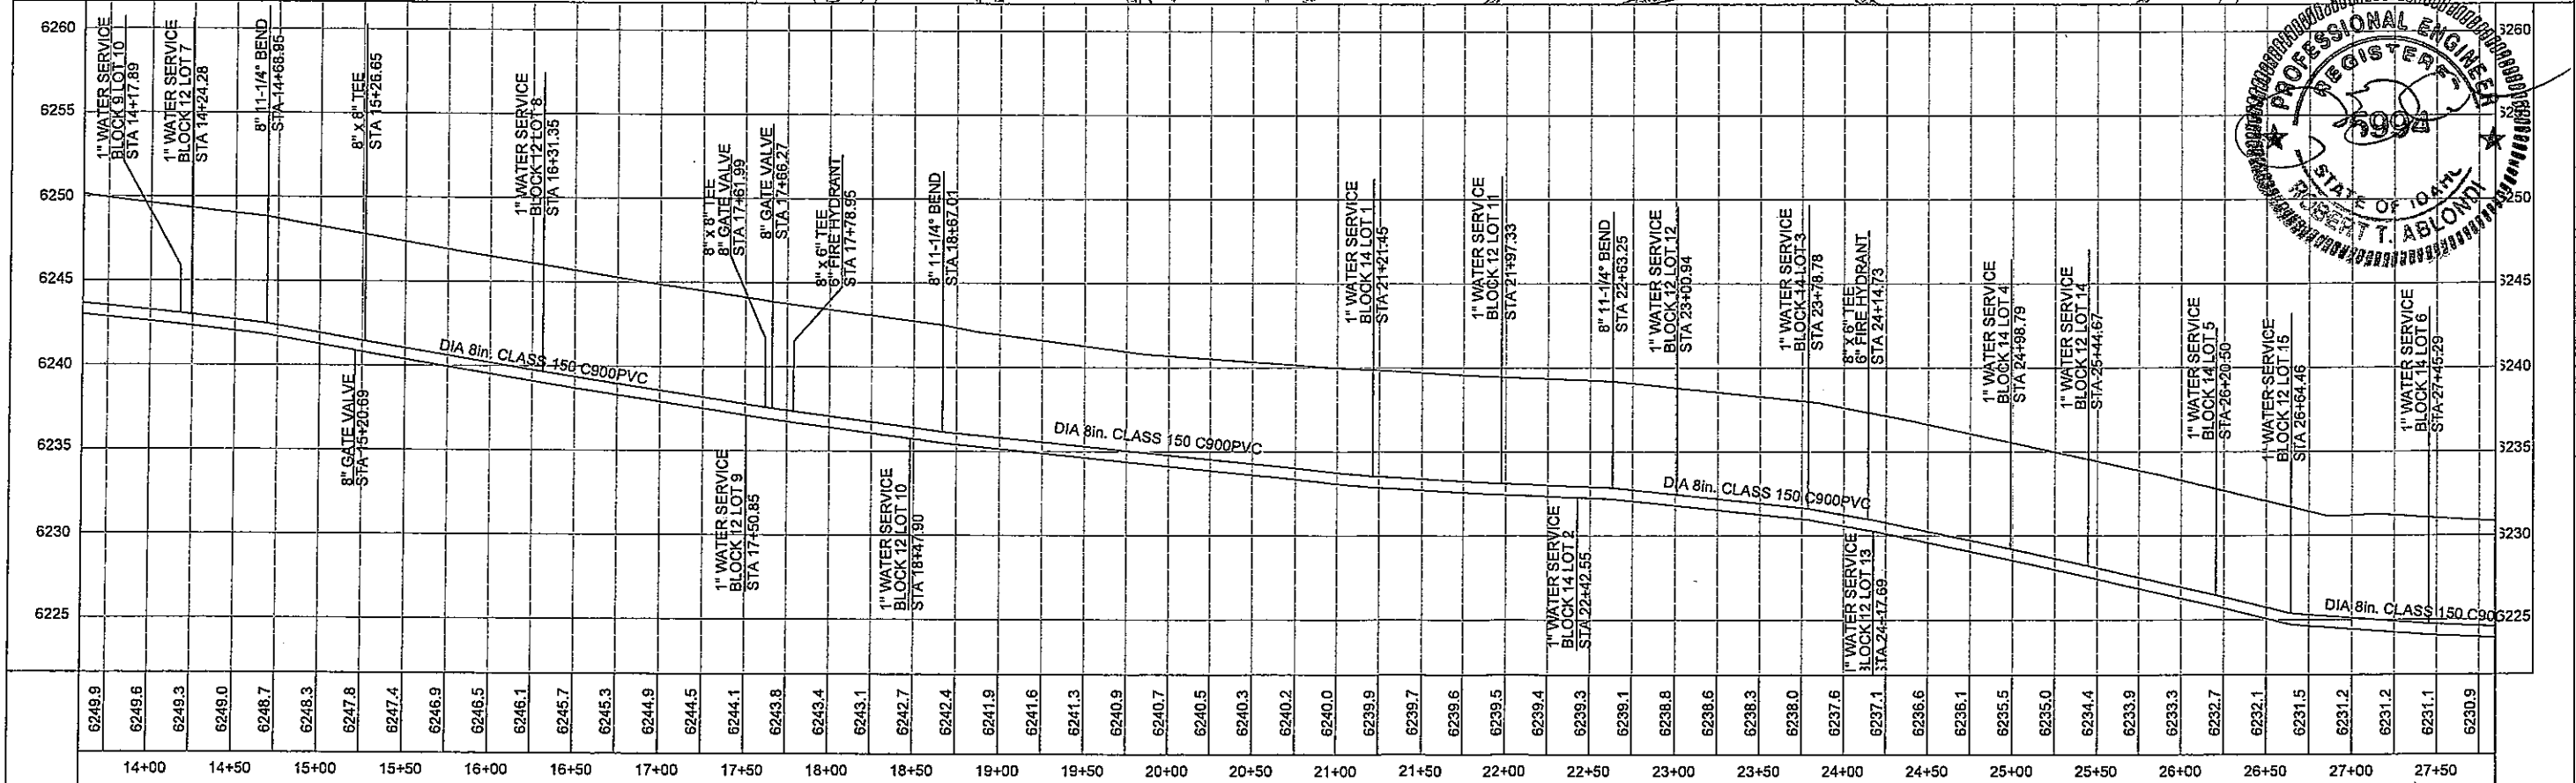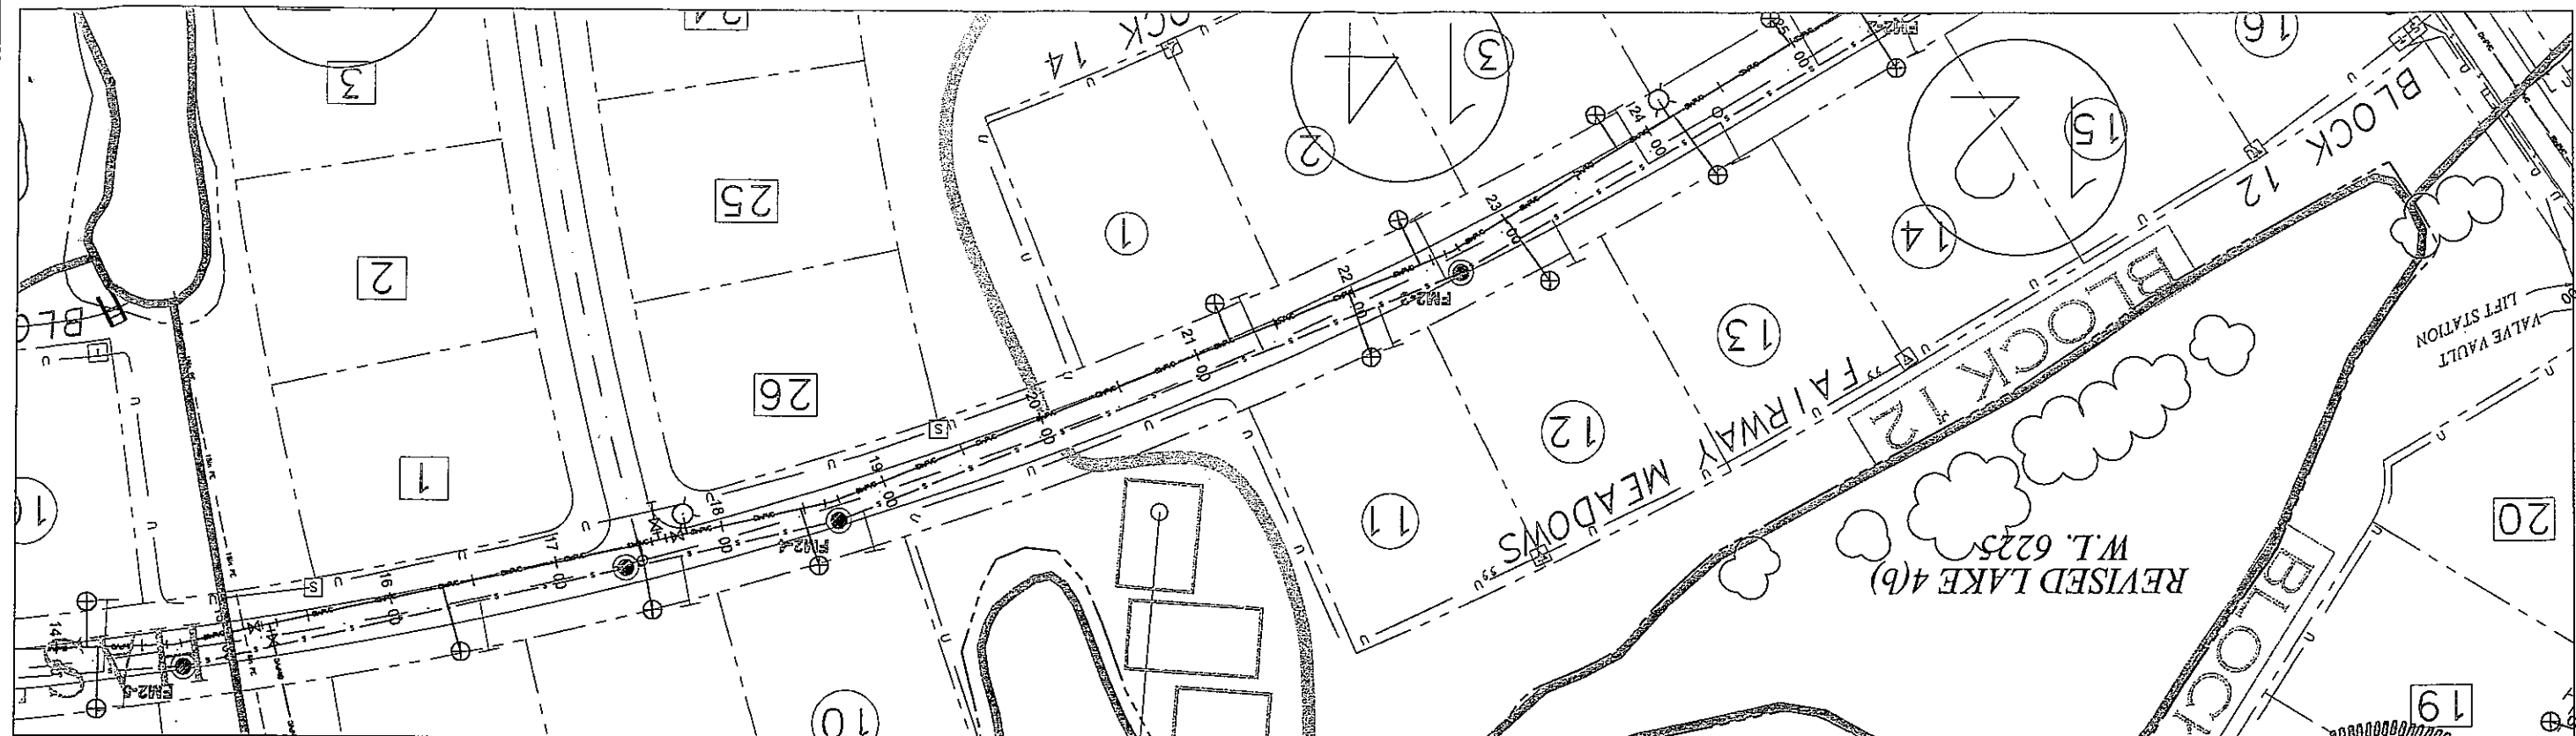

NOTES - THIS SHEET

GENERAL NOTES

Horizontal Scale: 1" = 50'
Vertical Scale: 1" = 5'

PROJECT TITLE:
TETON SPRINGS
RECORD DRAWINGS

PROJECT NUMBER:
00-023



DRAWING NUMBER:
ASBW20

DRAWING TITLE:
AS BUILT WATER PLAN & PROFILE
WATER MAIN 'E'
HASTINGS DRIVE

PROFESSIONAL ENGINEER
REGISTERED
STATE OF IDAHO
ROBERT T. ABLONNY
3992

RENDZVOUS ENGINEERING, P.C.
P.O. BOX 4858 JACKSON, WYOMING 83001
25 SOUTH CROSS VENTURE STREET
PHONE - 307.733.5252 FAX - 307.733.2334


Prepared By: EDO
Date: 200
Rev. Date:
Rev. Info:
Date:
Palt:

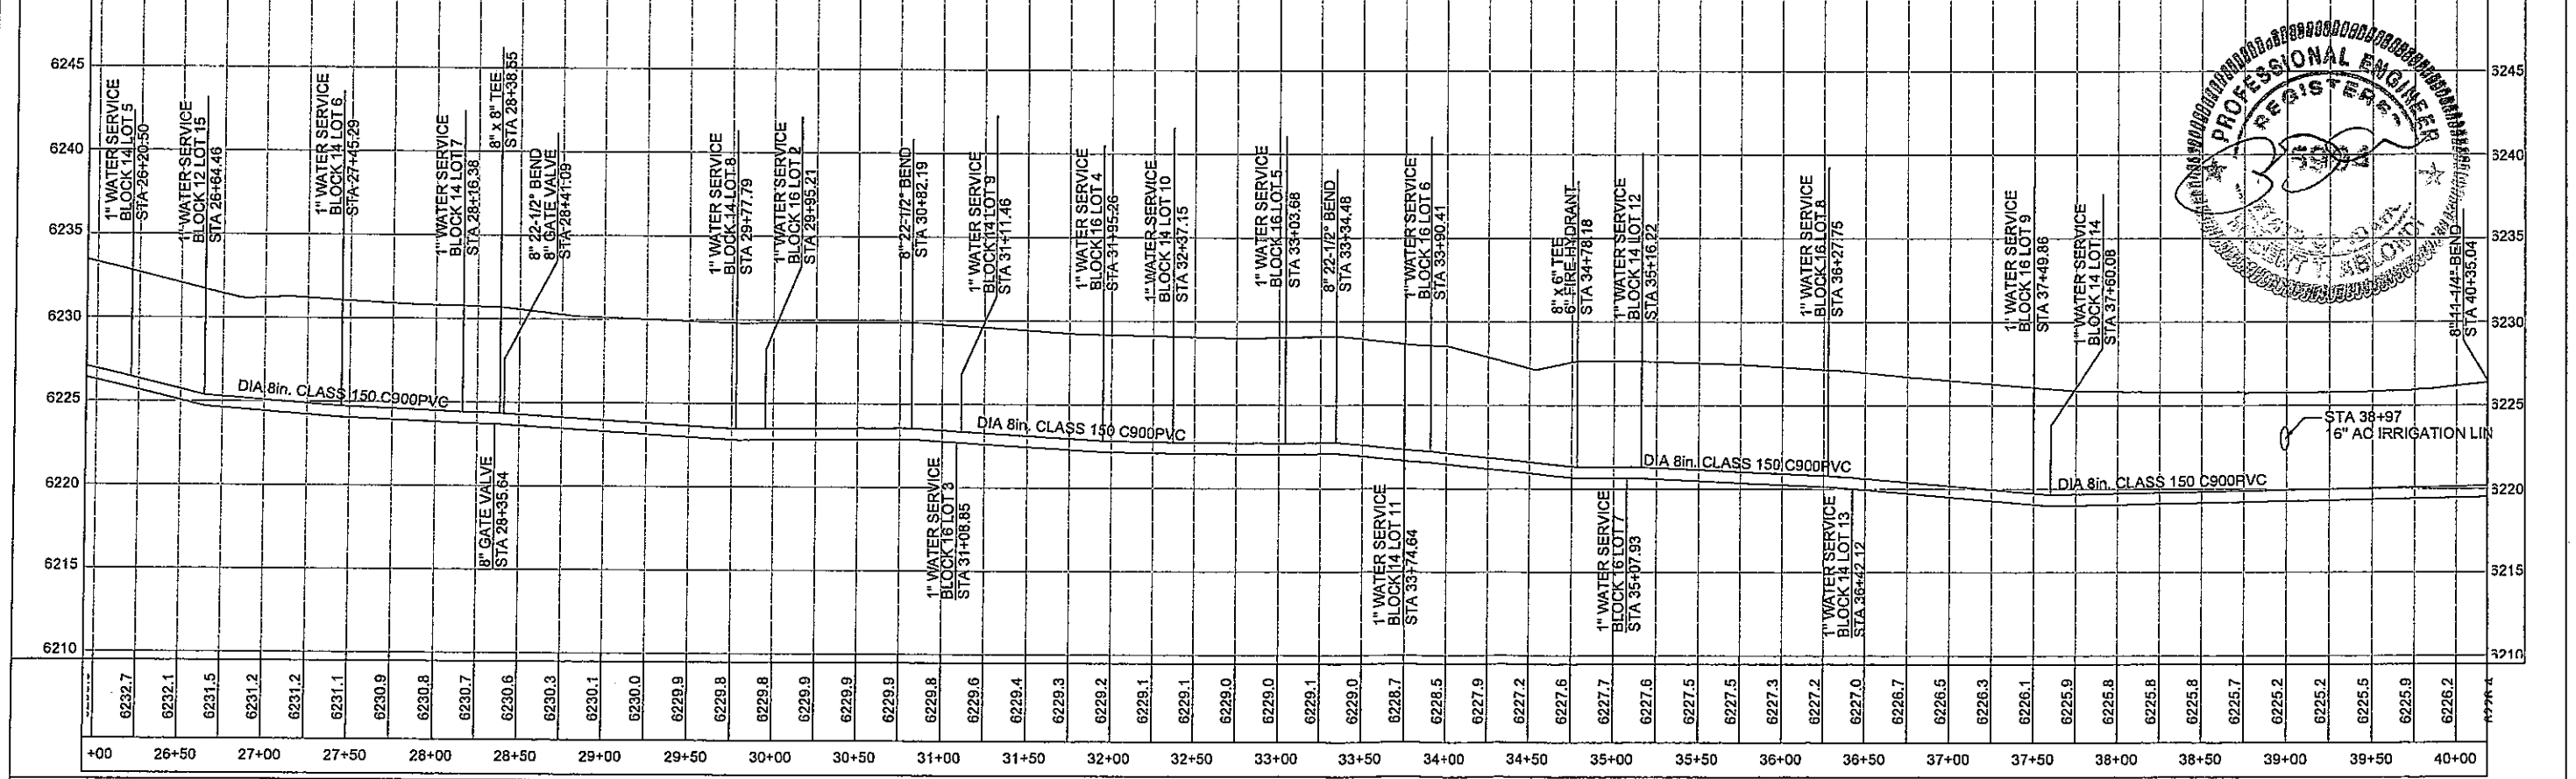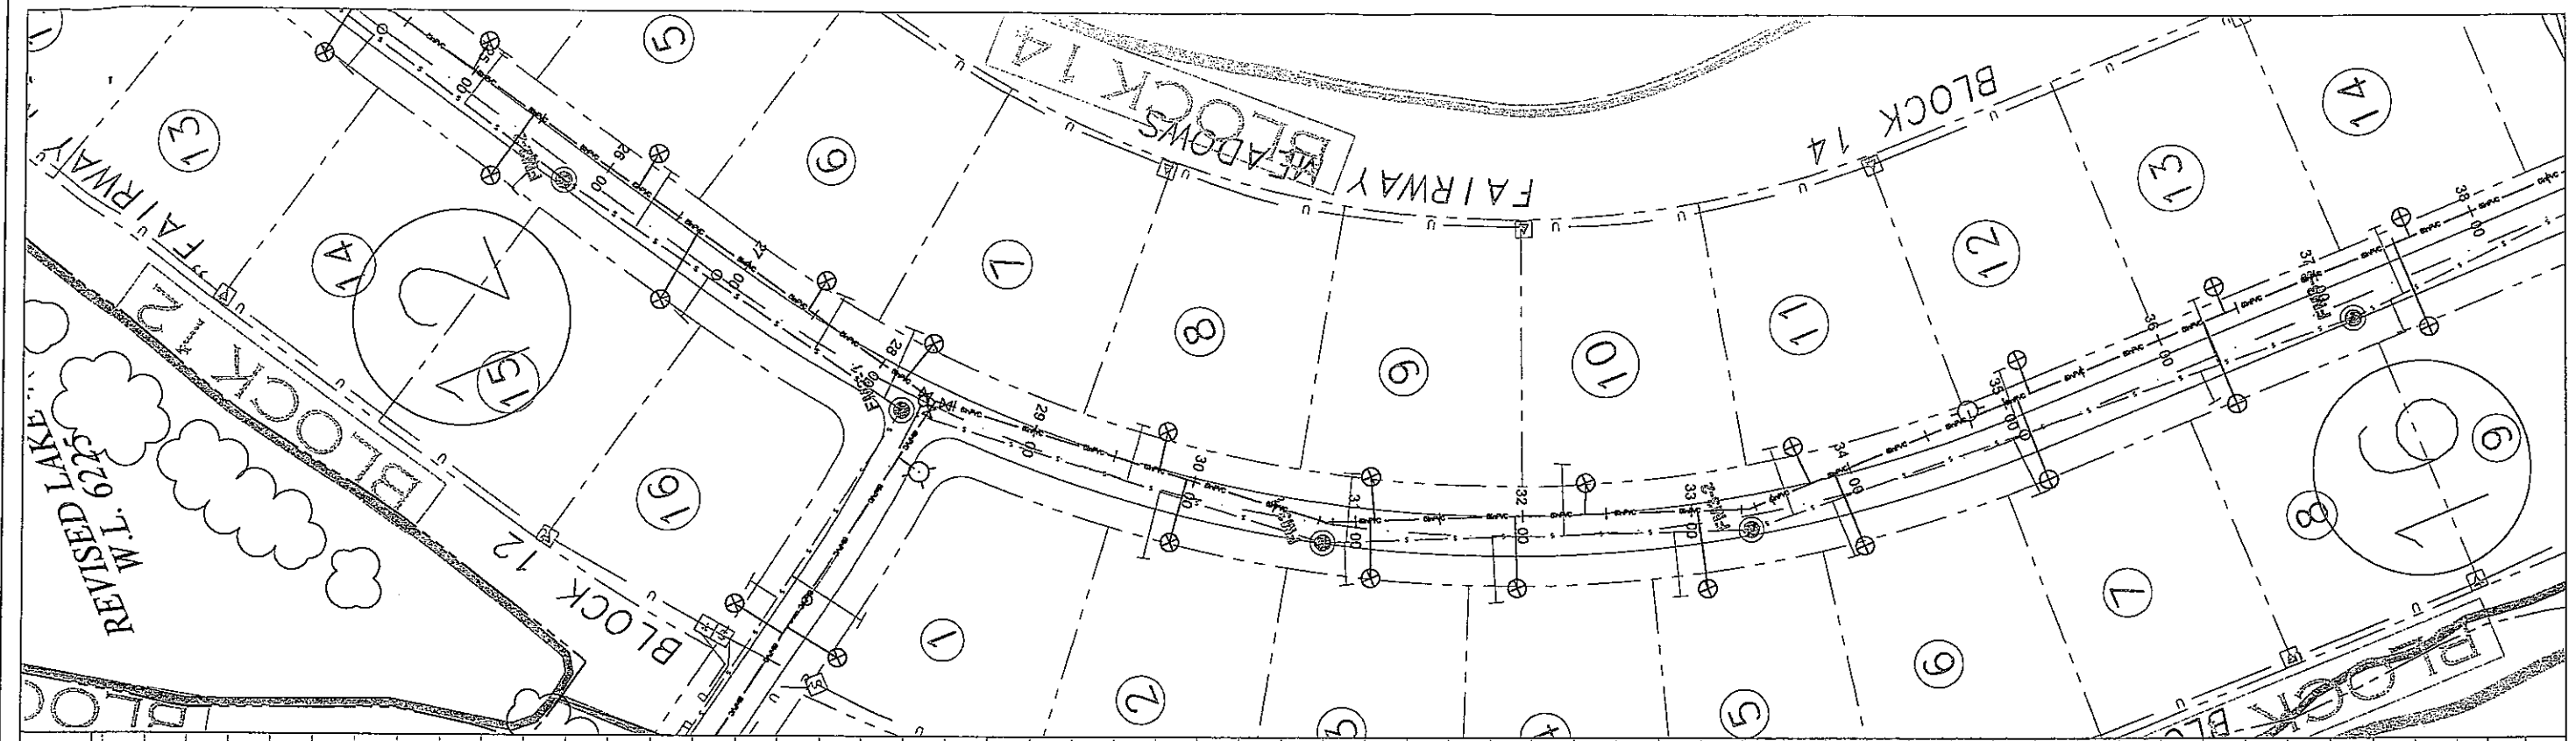

NOTES - THIS SHEET

GENERAL NOTES

Horizontal Scale: 1" = 50'
Vertical Scale: 1" = 5'

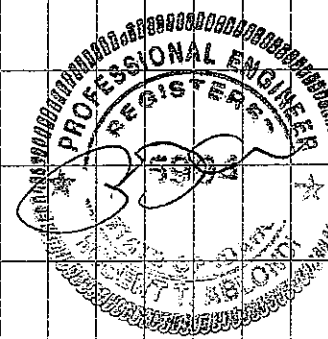

PROJECT TITLE:
TETON SPRINGS
RECORD DRAWINGS

PROJECT
NUMBER:
00-023



DRAWING
NUMBER:
ASBW21

DRAWING TITLE:
AS BUILT WATER PLAN & PROFILE
WATER MAIN 'E'
HASTINGS DRIVE

PREPARED BY: EDO
DATE: 2/03
REV. DATE:
PLOT INFO:
DATE: 10/10/03
PLOT: 10/10/03

RENDEZVOUS ENGINEERING, P.C.
P.O. BOX 4858 JACKSON, WYOMING 83001
25 SOUTH GROSVENTRE STREET
PHONE 307.733.5252 FAX 307.733.2334

1

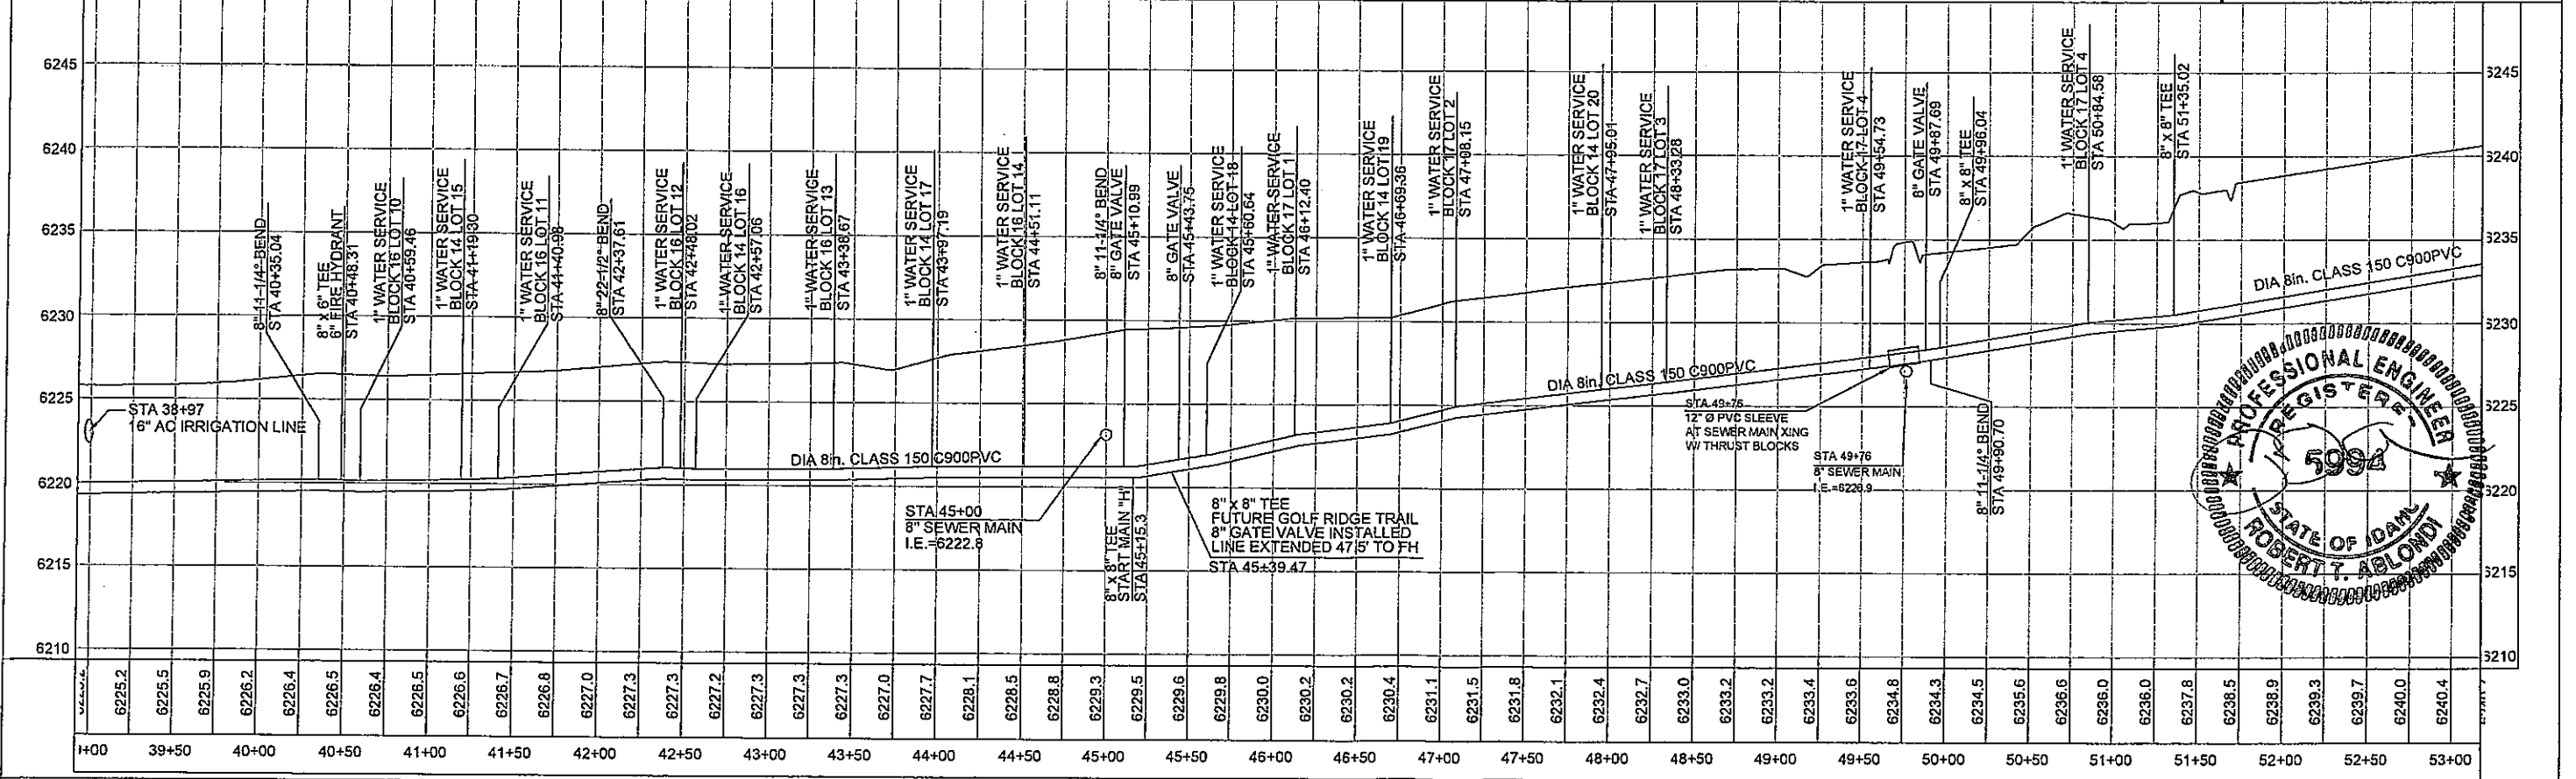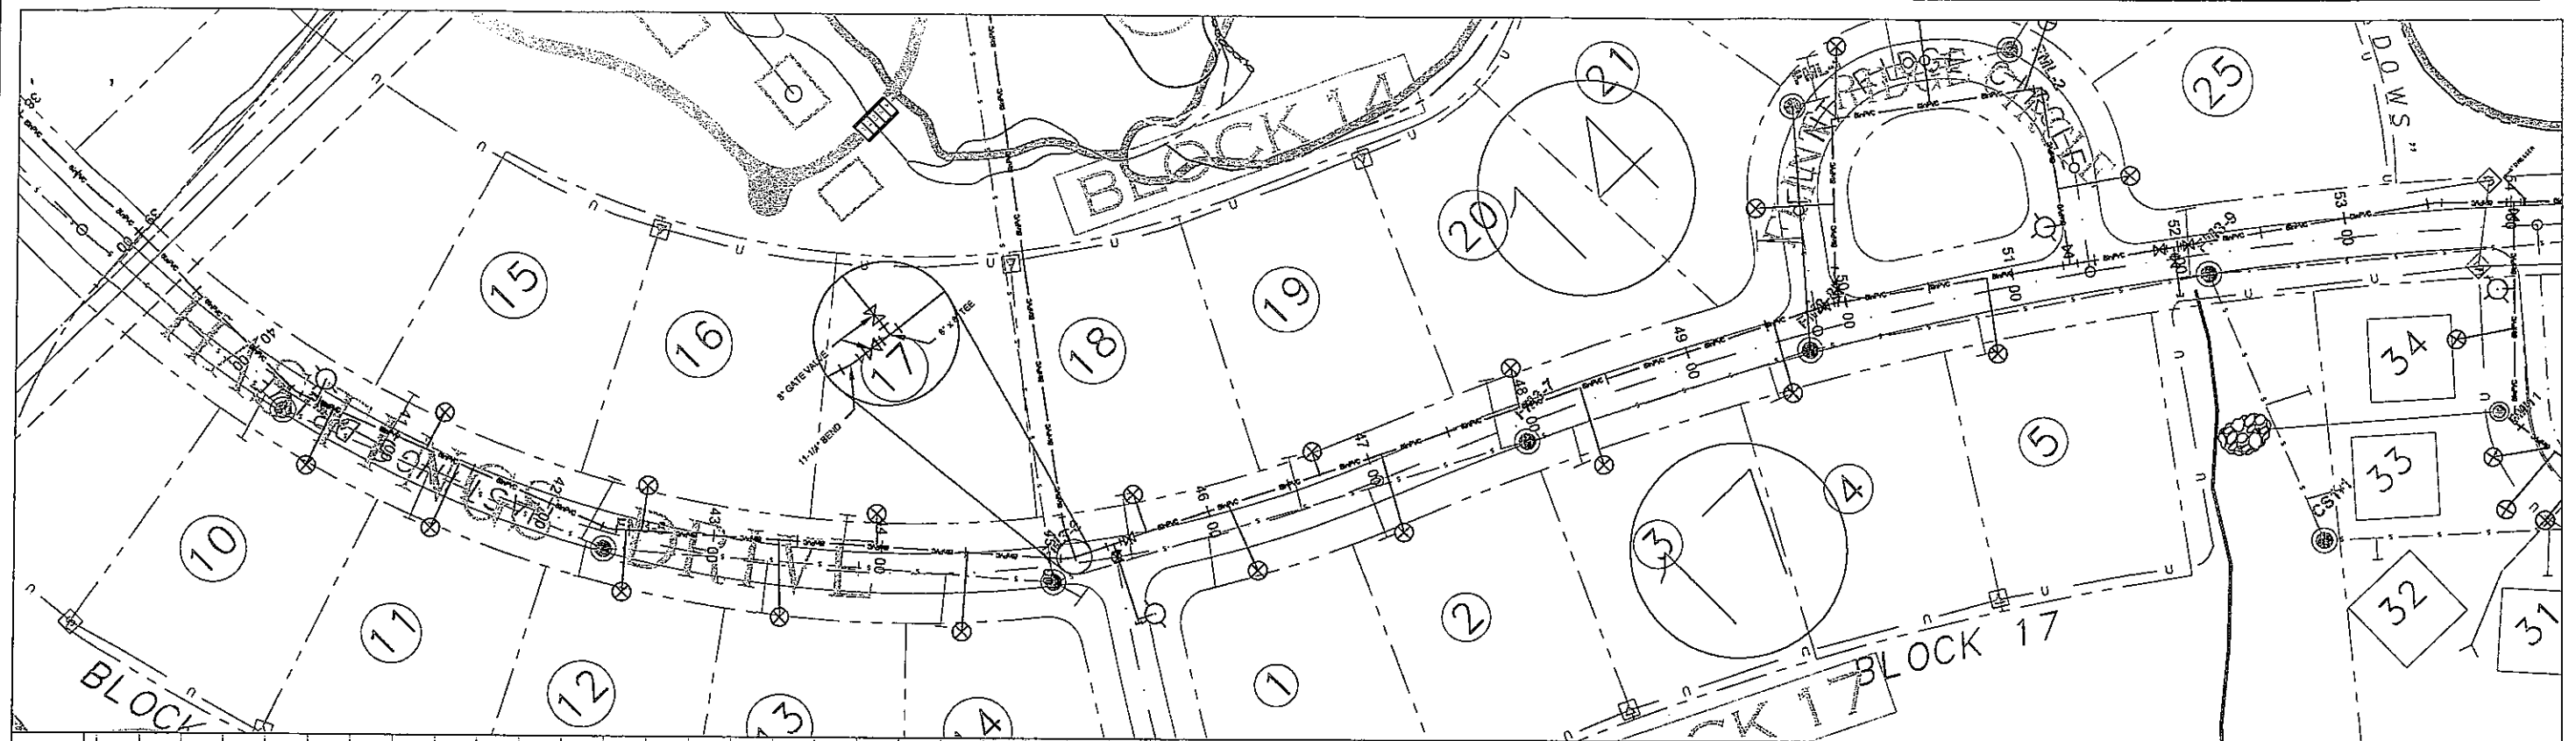

NOTES - THIS SHEET

GENERAL NOTES

Horizontal Scale: 1" = 50'
Vertical Scale: 1" = 5'

PROJECT TITLE:
**TETON SPRINGS
RECORD DRAWINGS**

PROJECT NUMBER:
00-023



DRAWING NUMBER:
ASBW22

DRAWING TITLE:
**AS BUILT WATER PLAN & PROFILE
WATER MAIN 'E'
HASTINGS DRIVE**

PROFESSIONAL ENGINEER
REGISTERED
5994
STATE OF IDAHO
ROBERT T. ABLONDI

RENEZVOUS ENGINEERING, P.C.
P.O. BOX 4858 JACKSON, WYOMING 83001
25 SOUTH GROES VENTURE STREET
PHONE - 307.733.5252 FAX - 307.733.2334


Prepared By: BDD
Date: 2/03
Rev. Date:
Plot Info:
Data Path:

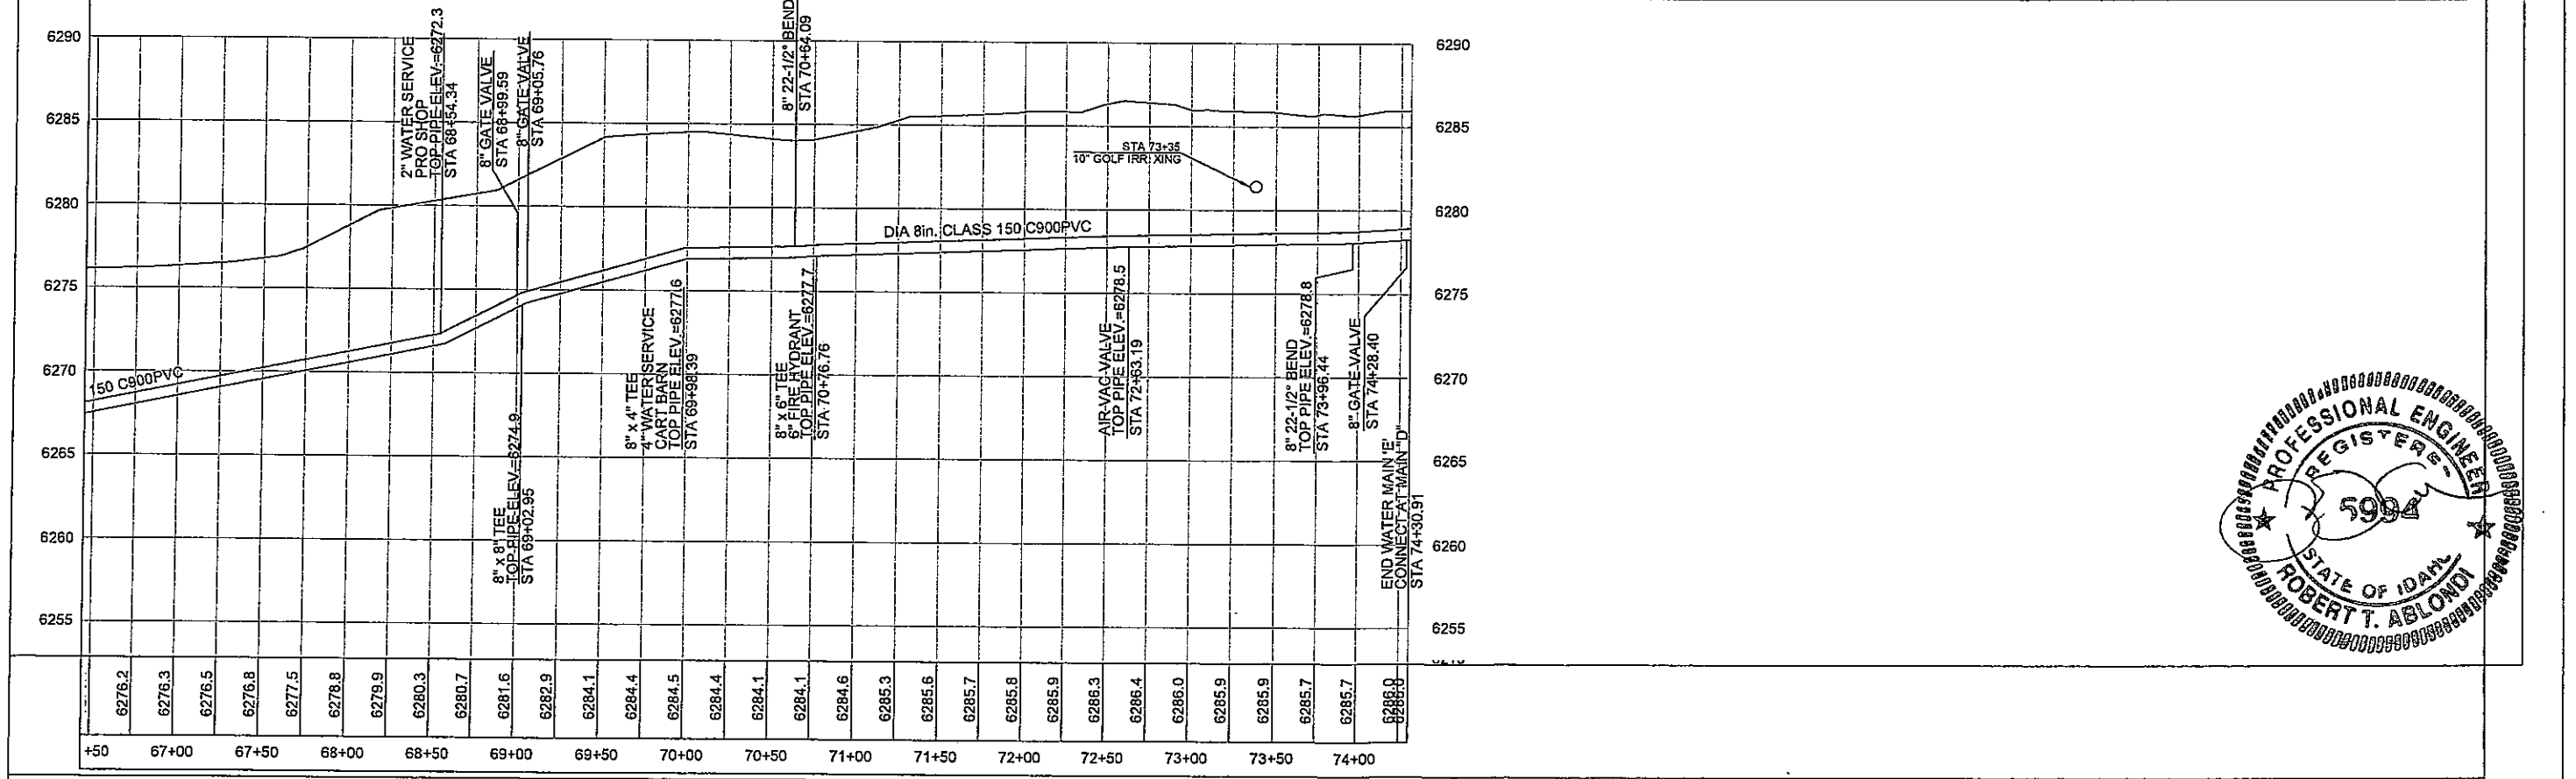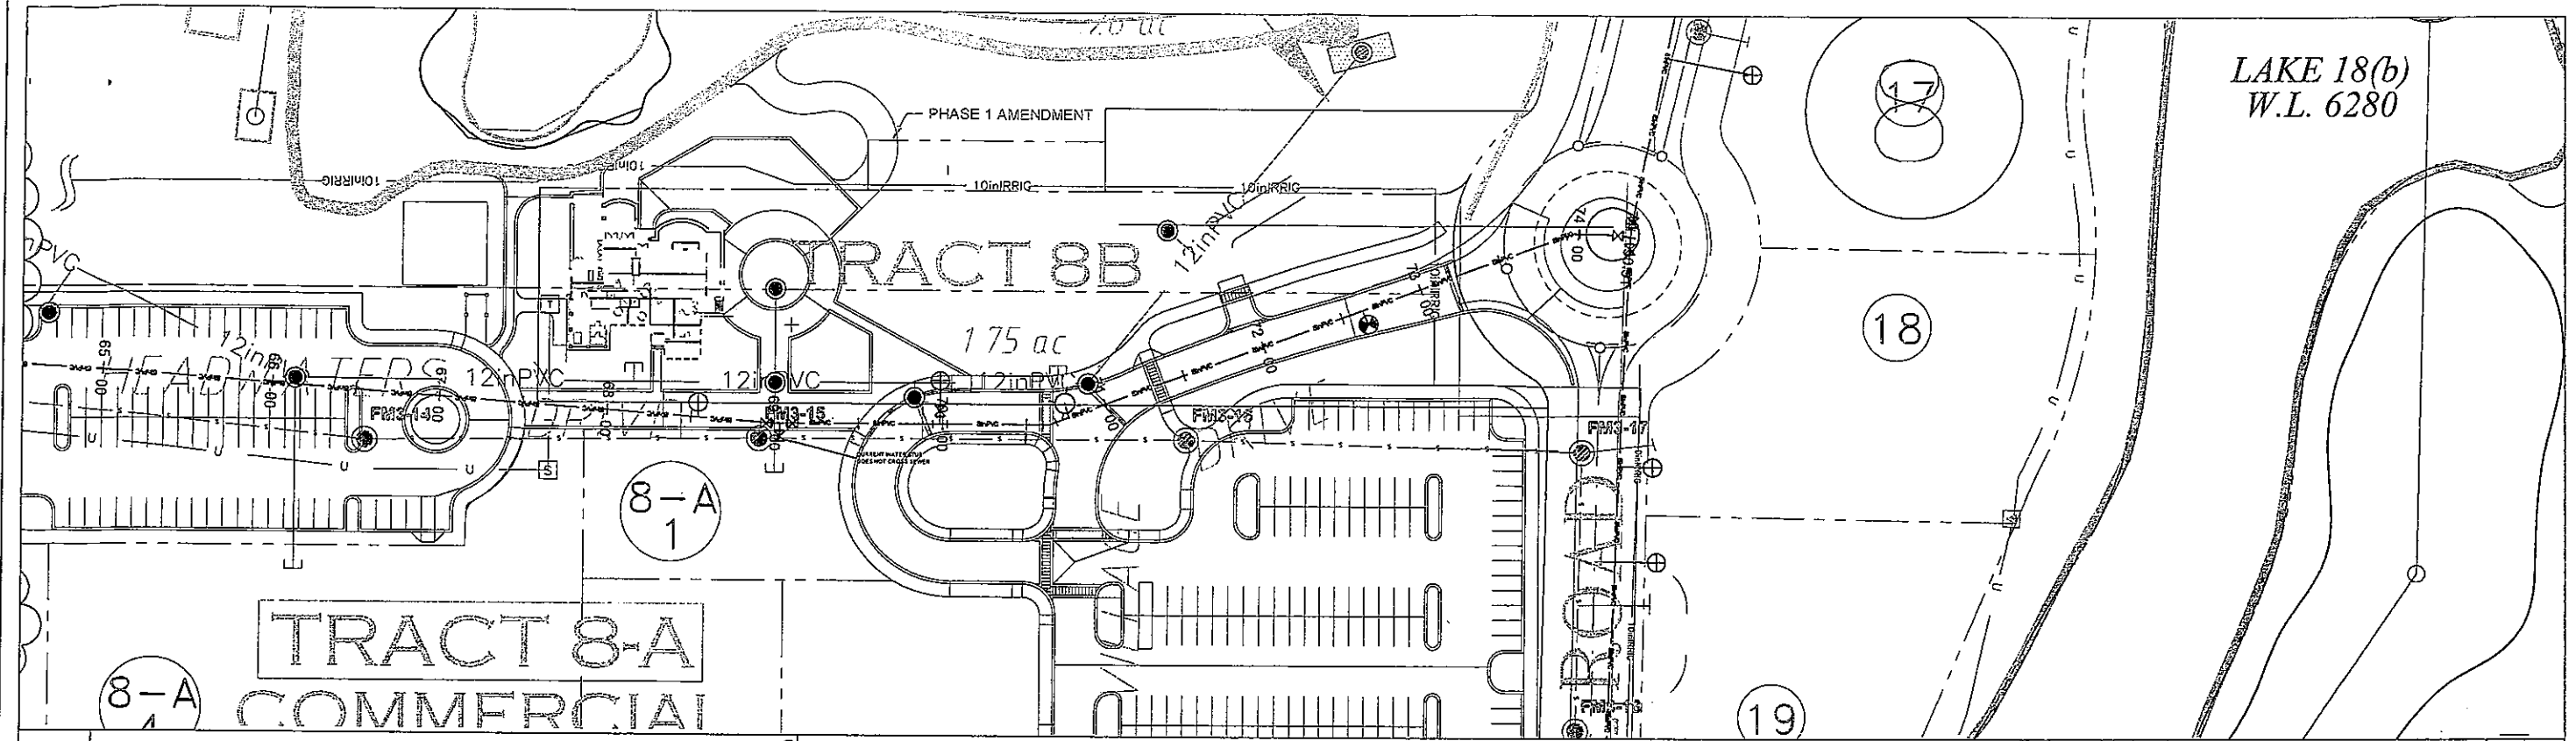

NOTES - THIS SHEET

GENERAL NOTES

Horizontal Scale: 1" = 50'
Vertical Scale: 1" = 5'

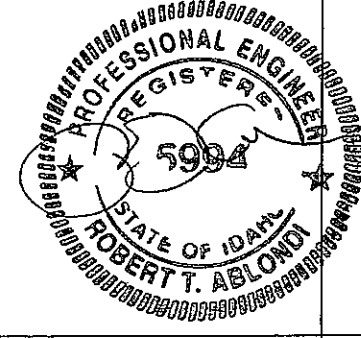

PROJECT TITLE:
TETON SPRINGS
RECORD DRAWINGS


PROJECT NUMBER:
00-023

DRAWING NUMBER:
ASBW24

DRAWING TITLE:
AS BUILT WATER PLAN & PROFILE
WATER MAIN 'E'
HASTINGS DRIVE TO COMMERCIAL AREA

RENDEZVOUS ENGINEERING, P.C.
P.O. BOX 4858 JACKSON, WYOMING 83001
PHONE - 307.733.5252 FAX - 307.733.2234

Prepared By: EDO
Date: 2003
Rev. Date:
Plot Info:
Data
Path

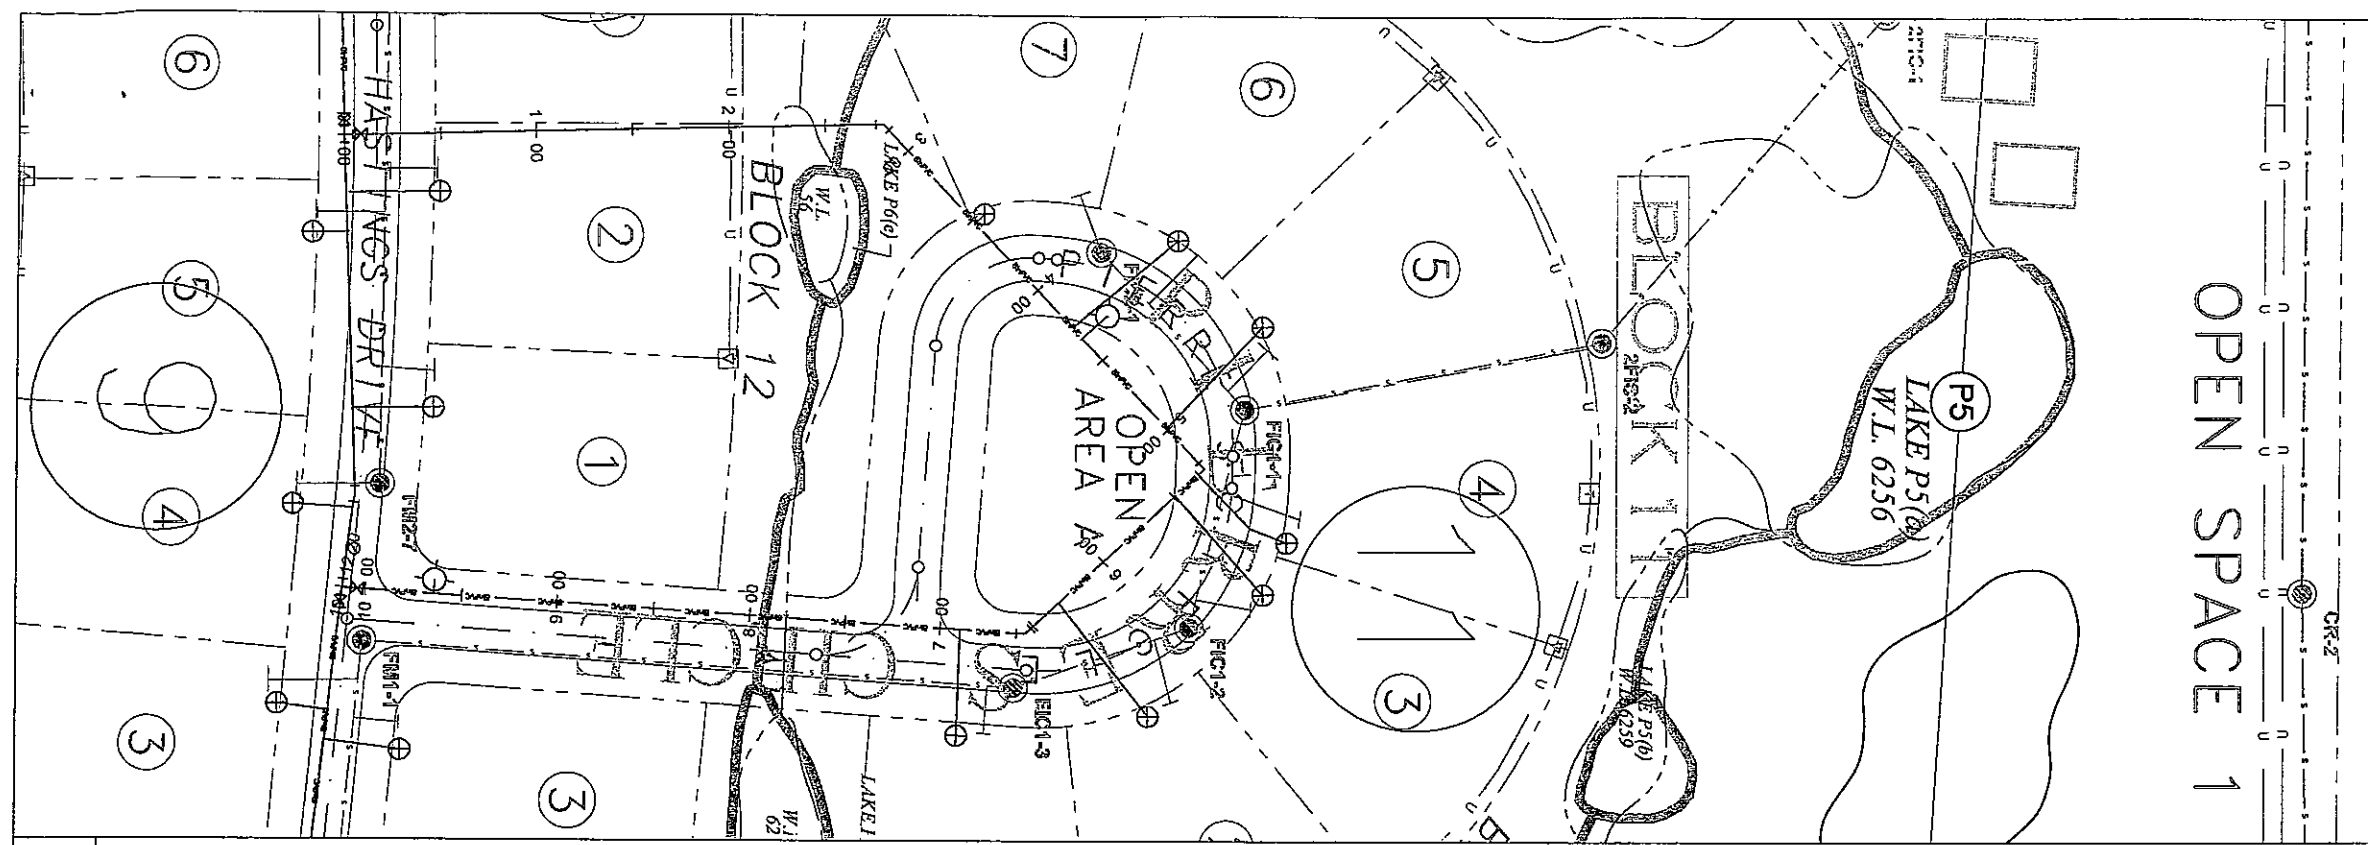


EMORY
ANDERSON
PROPERTY

OPEN SPACE 1


CR-2

WATER


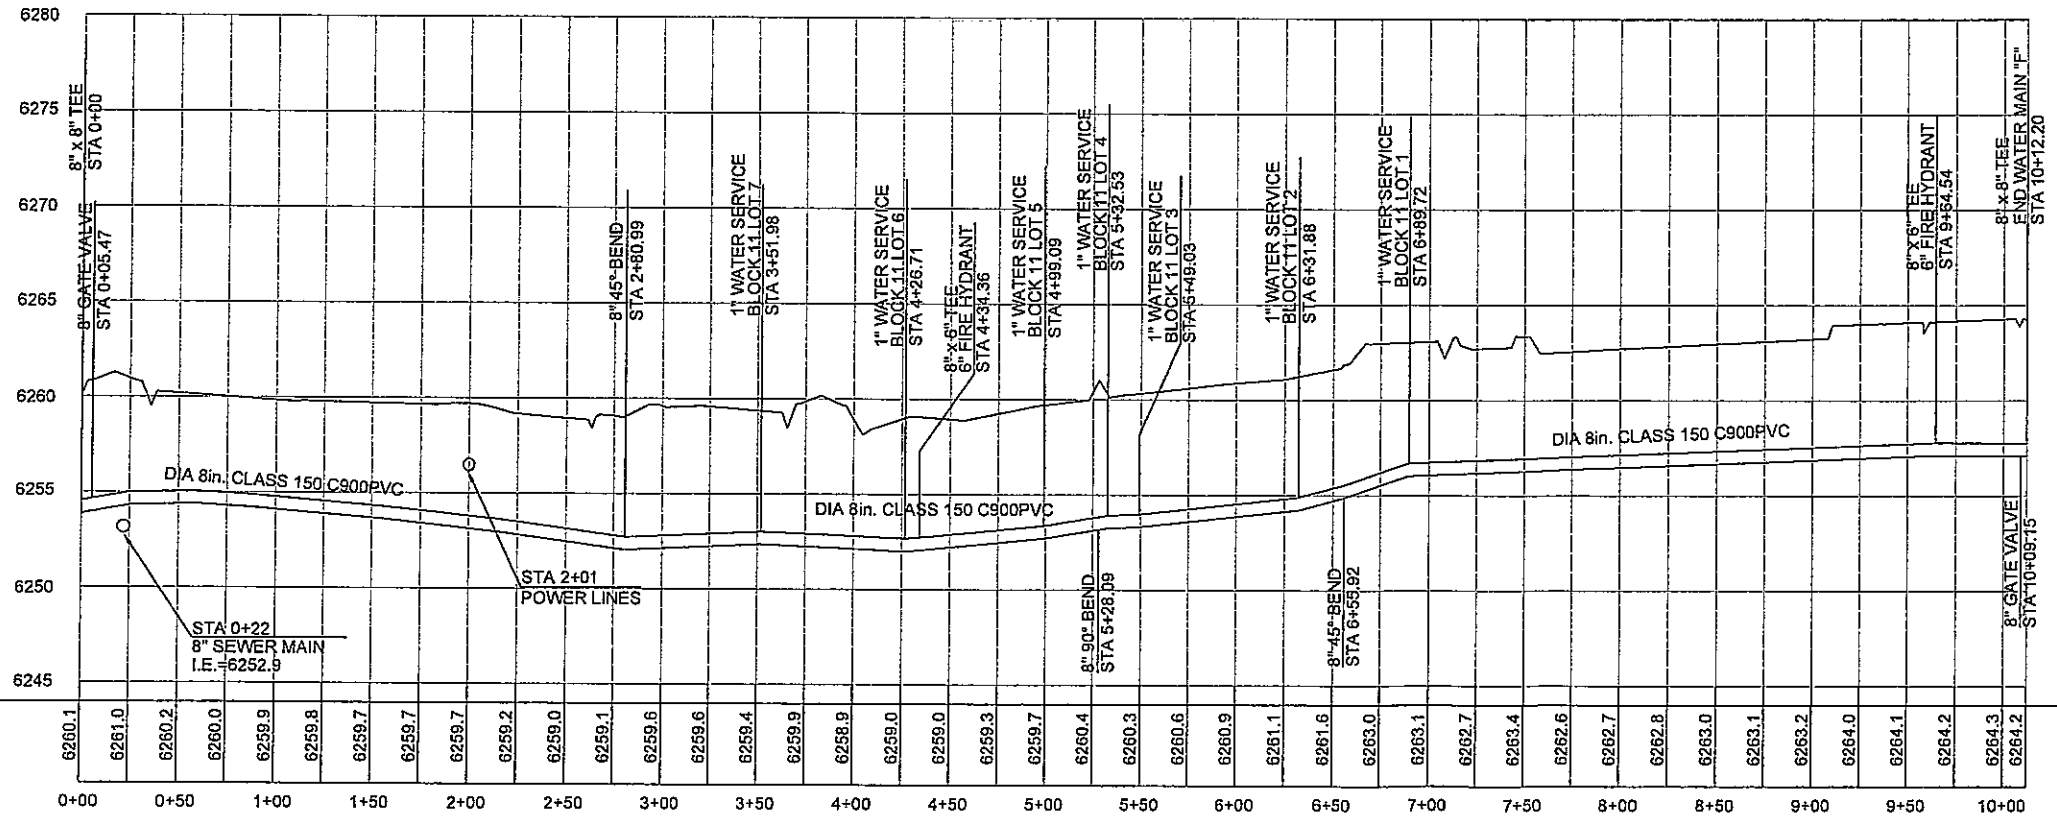


NOTES - THIS SHEET

GENERAL NOTES

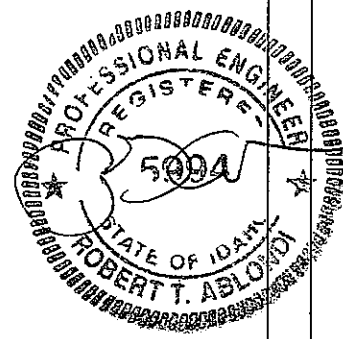

Horizontal Scale: 1" = 50'
Vertical Scale: 1" = 5'

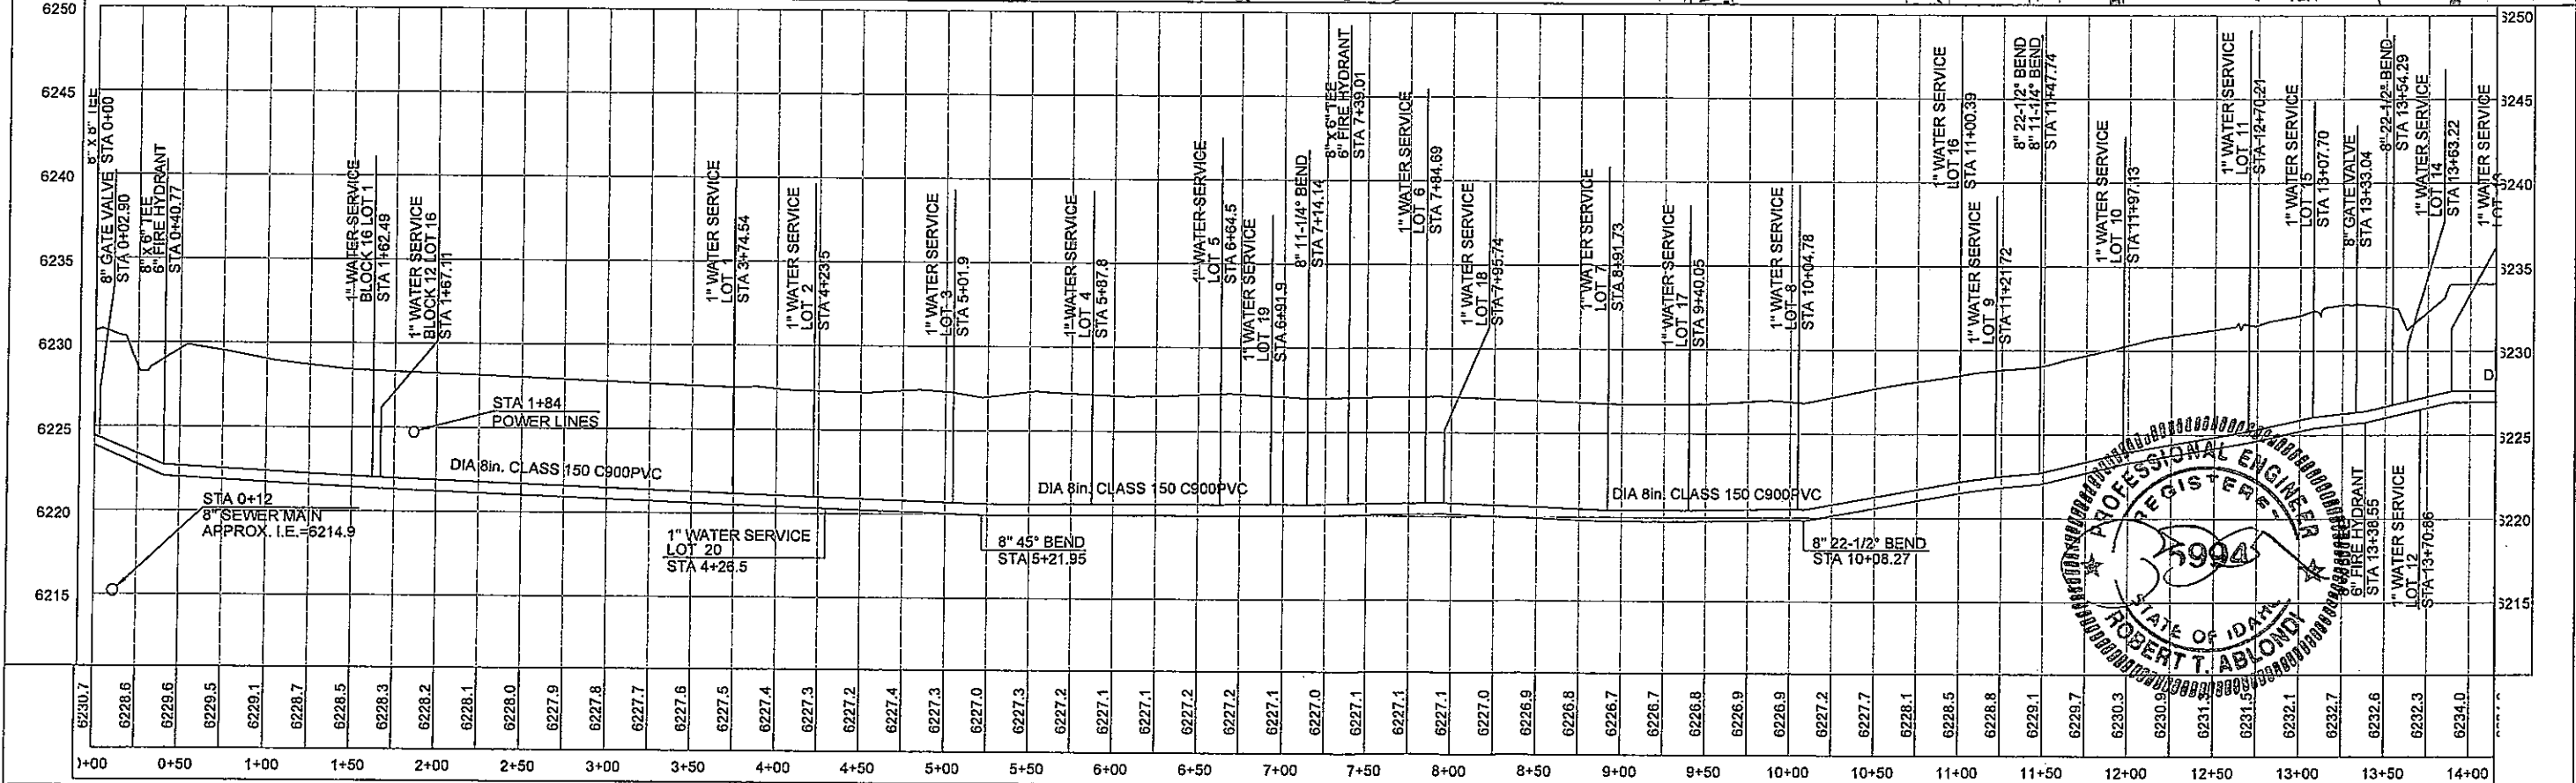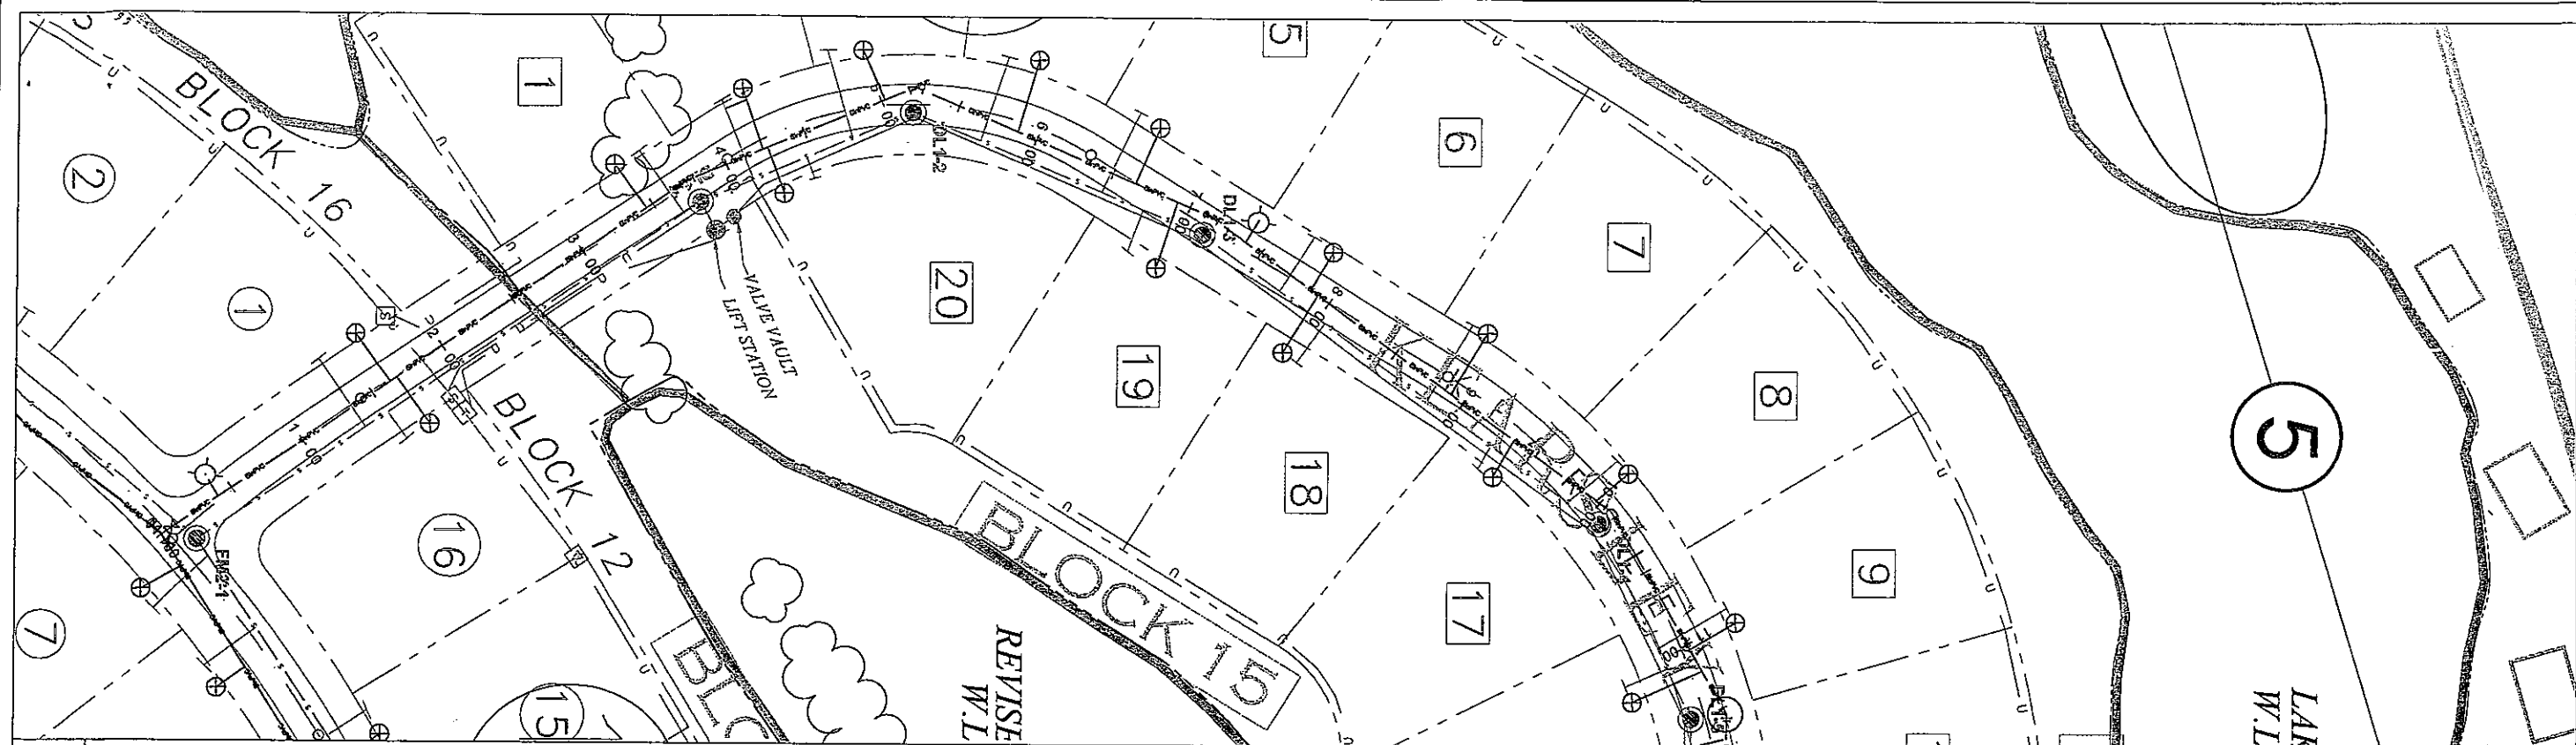

NOTES - THIS SHEET

GENERAL NOTES

Horizontal Scale: 1" = 50'
Vertical Scale: 1" = 5'

PROJECT TITLE:
**TETON SPRINGS
RECORD DRAWINGS**



DRAWING NUMBER:
00-023

DRAWING NUMBER:
ASBW26

DRAWING TITLE:
**AS BUILT WATER PLAN & PROFILE
WATER MAIN 'G'
KEARSLEY LANE**

PREPARED BY: **EO**
DATE: **2/26**
REV. DATE:
PILOT INFO:
DATE: **10/20/2024**
PART: **1**


RENDEZVOUS ENGINEERING, P.C.
P.O. BOX 4858 JACKSON, WYOMING 83001
25 SOUTH GROS VENTRE STREET
PHONE - 307.733.5252 FAX - 307.733.2334

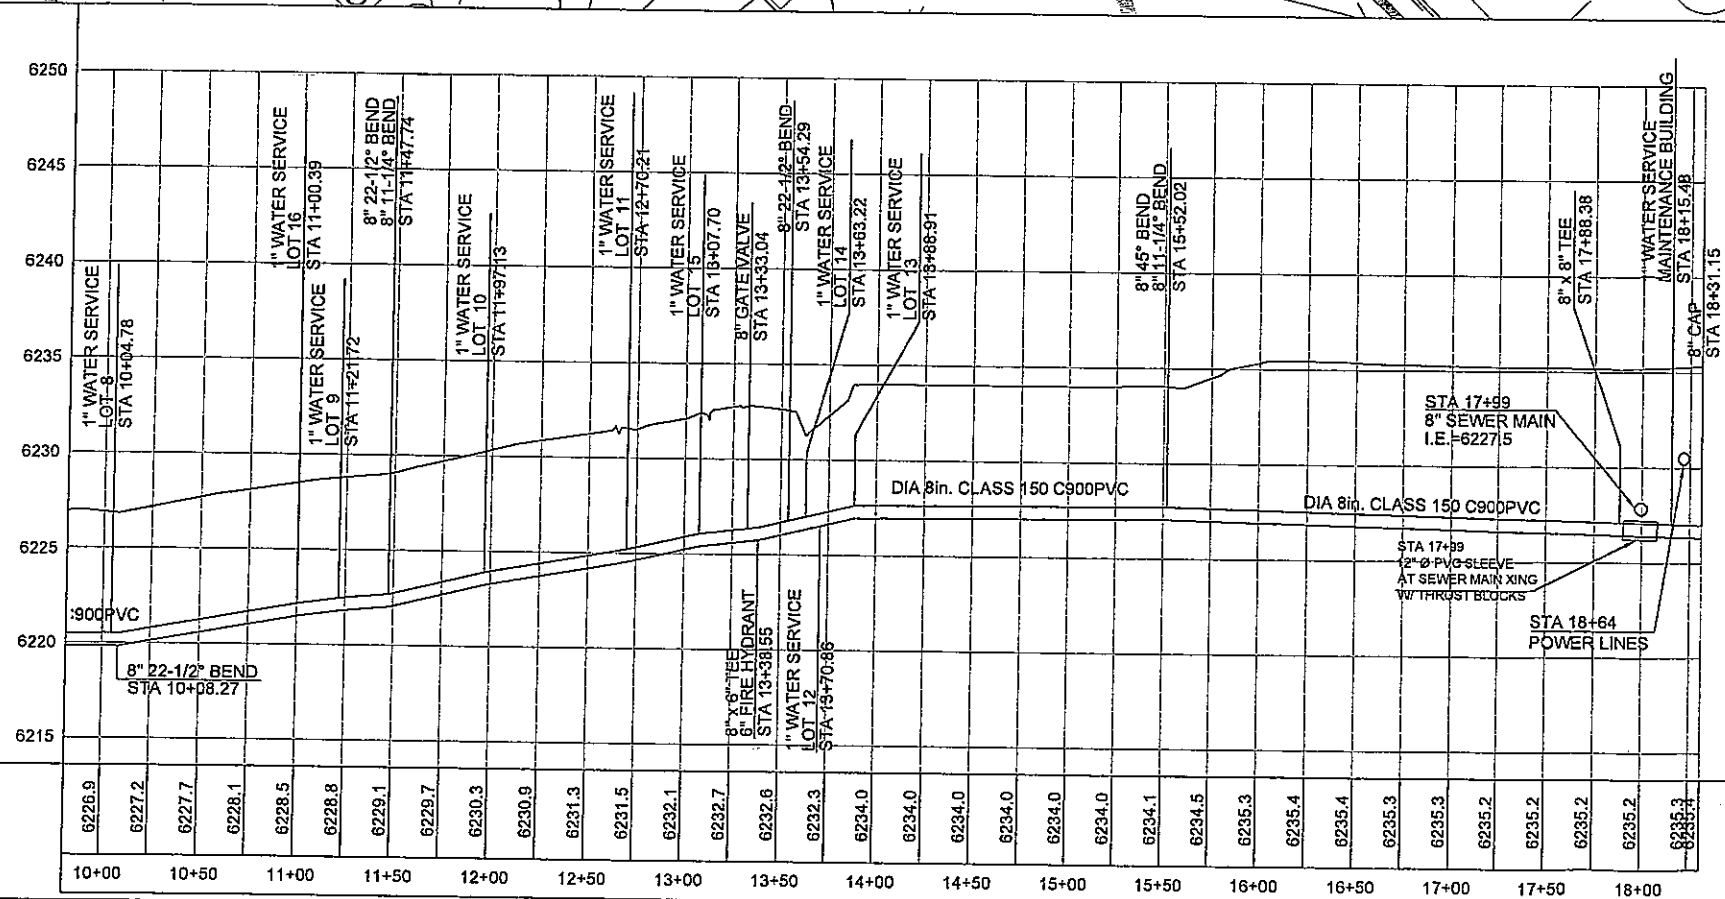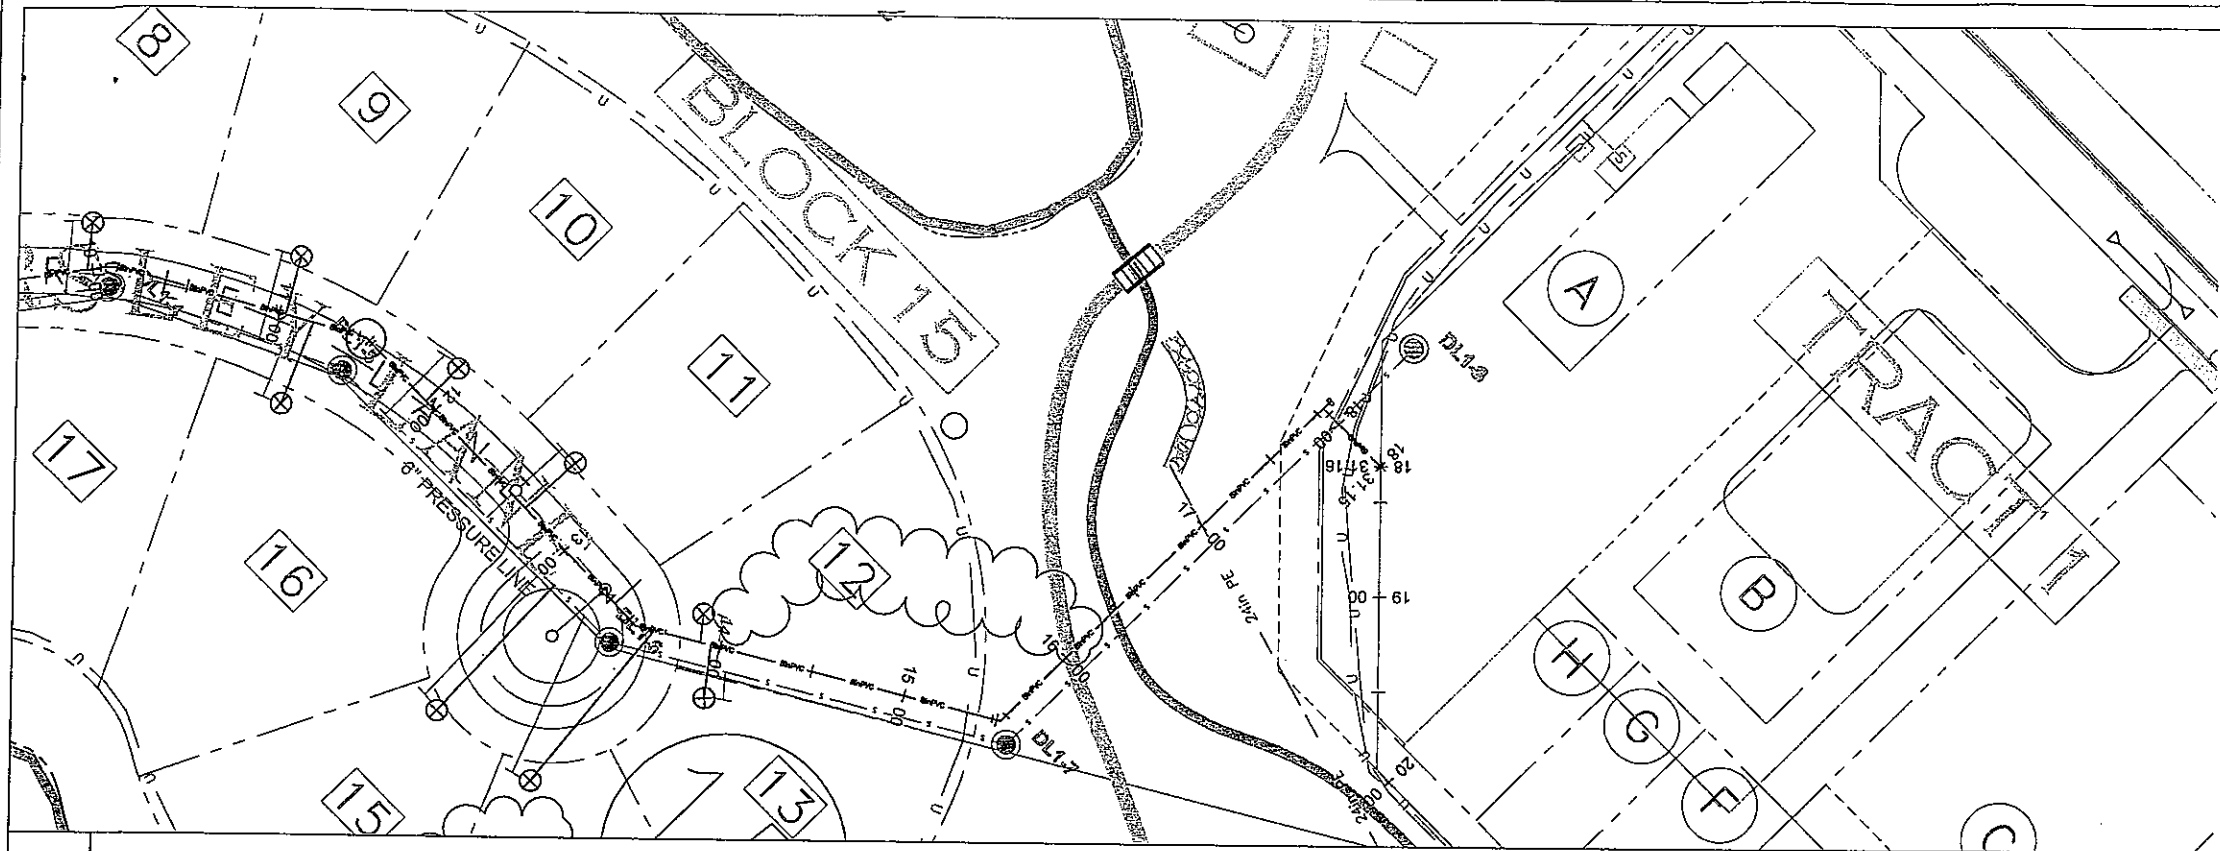

NOTES - THIS SHEET

GENERAL NOTES

Horizontal Scale: 1" = 50'
Vertical Scale: 1" = 5'

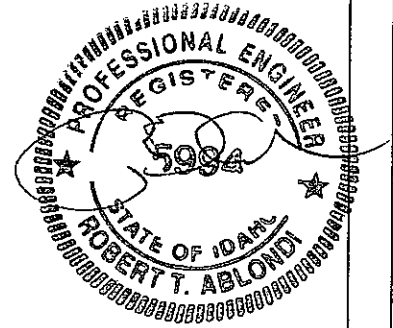

Prepared By: EDO
Date: 2/23
Rev. Date:
Plot Info:
Data:
Print:



RENDEZVOUS ENGINEERING, P.C.
P.O. BOX 4858 JACKSON, WYOMING 83001
25 SOUTH CROSS VENTURE STREET
PHONE • 307.733.5252 FAX • 307.733.2334

DRAWING TITLE:
AS BUILT WATER PLAN & PROFILE
WATER MAIN 'G'
KEARSLEY LANE TO O & M

PROJECT TITLE:
TETON SPRINGS
RECORD DRAWINGS

PROJECT NUMBER:
00-023

DRAWING NUMBER:
ASBW27

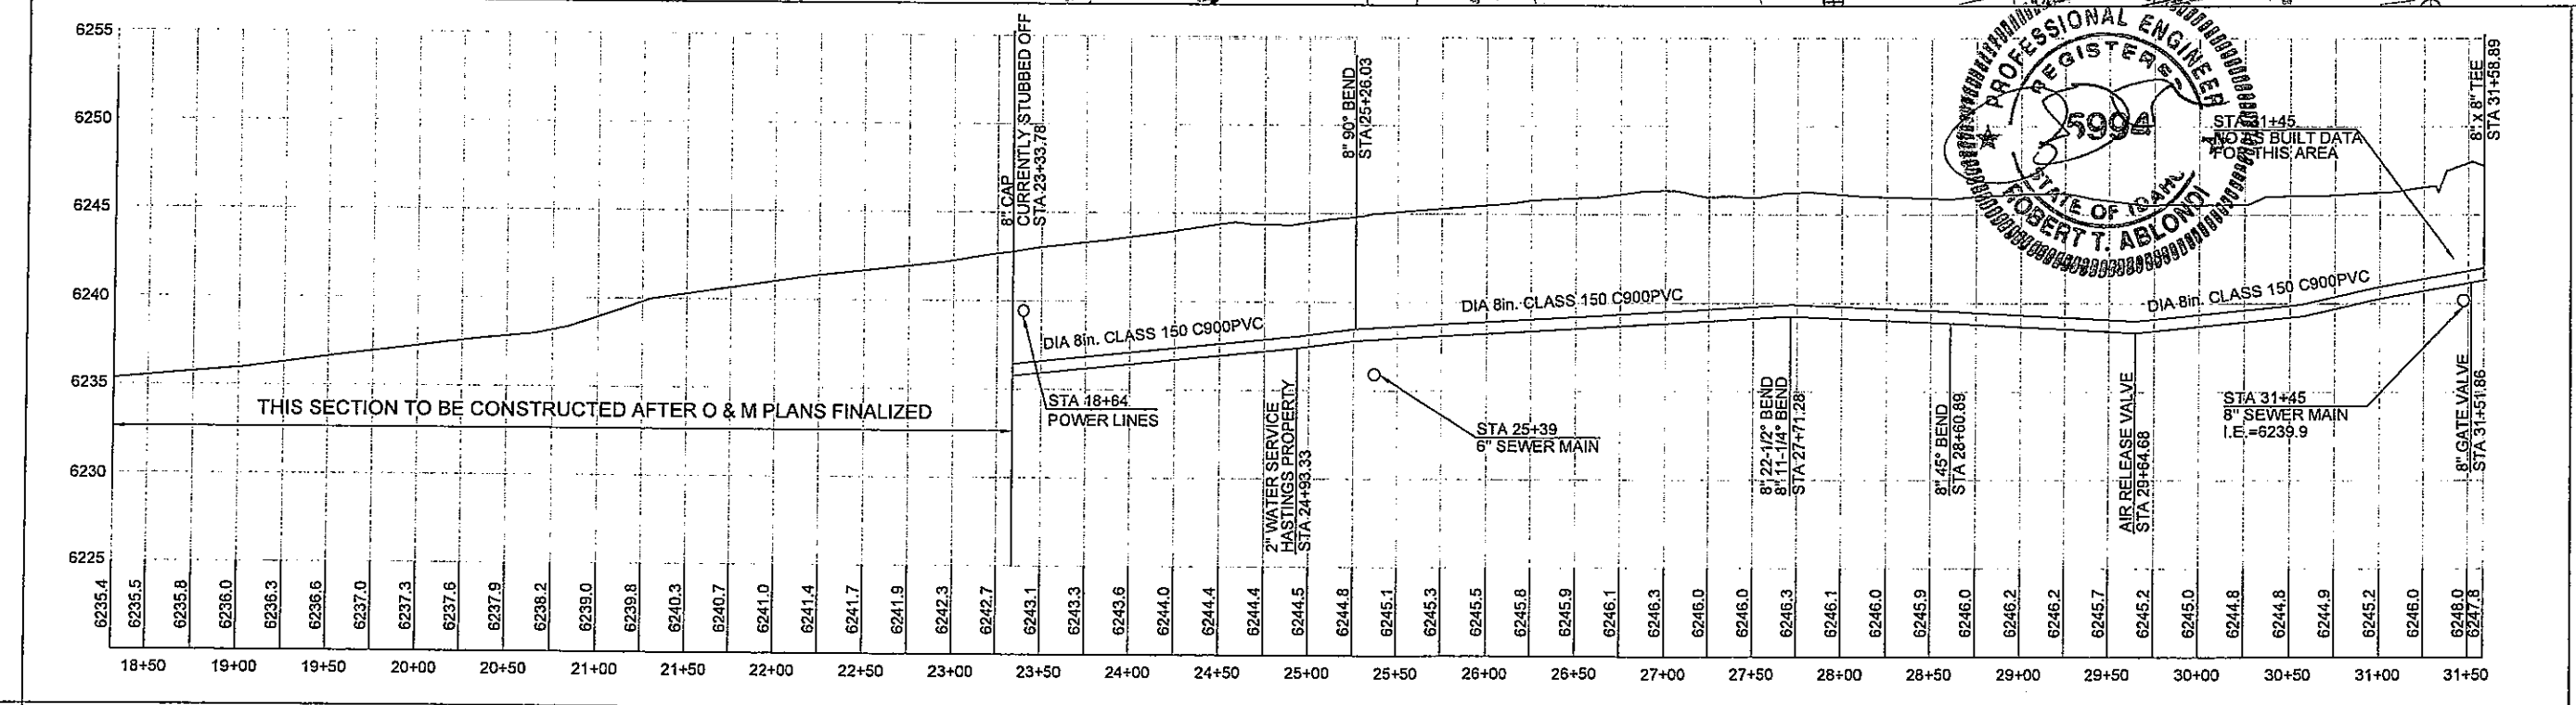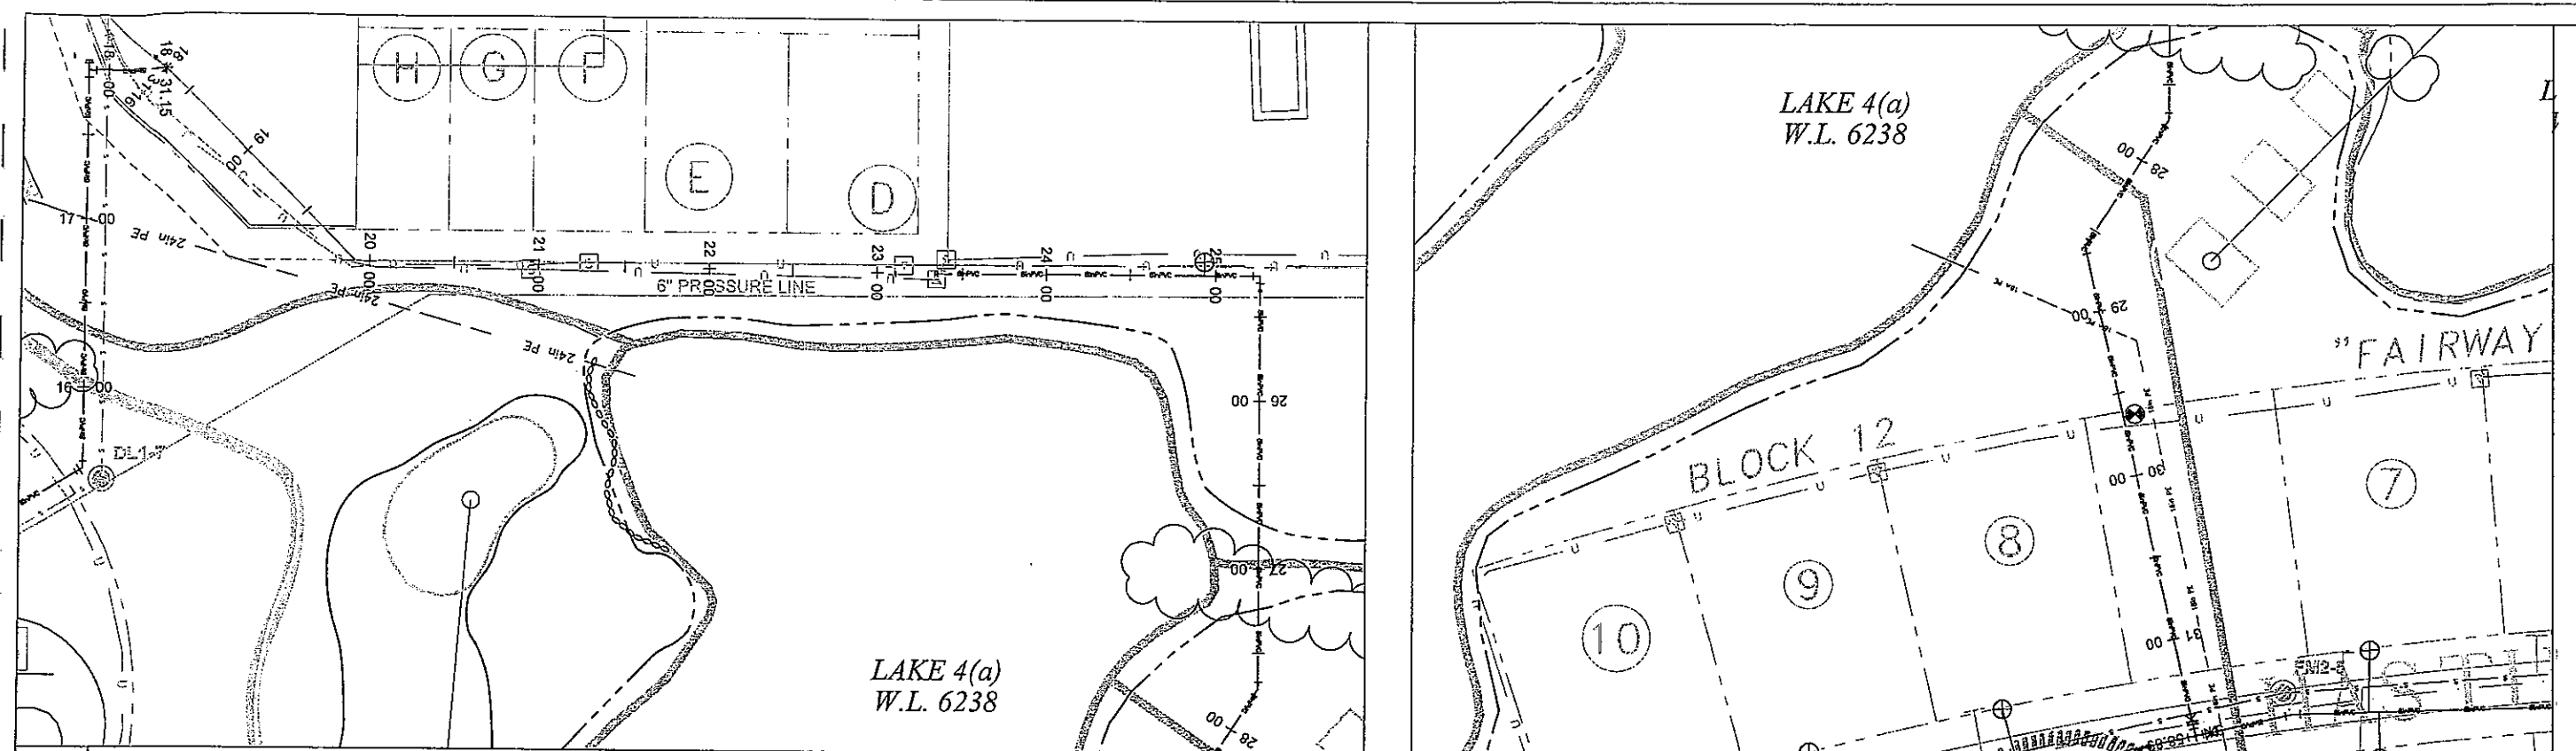

NOTES - THIS SHEET

GENERAL NOTES

Horizontal Scale: 1" = 50'
Vertical Scale: 1" = 5'

PROJECT TITLE:
TETON SPRINGS
RECORD DRAWINGS

PROJECT NUMBER:
00-023

DRAWING NUMBER:
ASBW28

DRAWING TITLE:
AS BUILT WATER PLAN & PROFILE
WATER MAIN 'G'
OPERATIONS & MAINTENANCE

PROFESSIONAL ENGINEER
REGISTERED
STATE OF IDAHO
ROBERT T. ABLONDI
5994

NO DATA BUILT DATA
FOR THIS AREA

RENDZVOUS ENGINEERING, P.C.

P.O. BOX 4855 JACKSON, WYOMING 83001
25 SOUTH GROS VENTRE STREET
PHONE - 307.733.5252 FAX - 307.733.2334

Prepared By: EDO




Date: 2003

Rev. Date:

Rev. Info:

Data

Path:

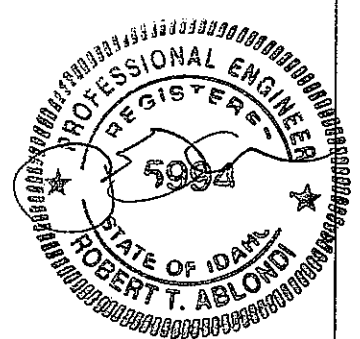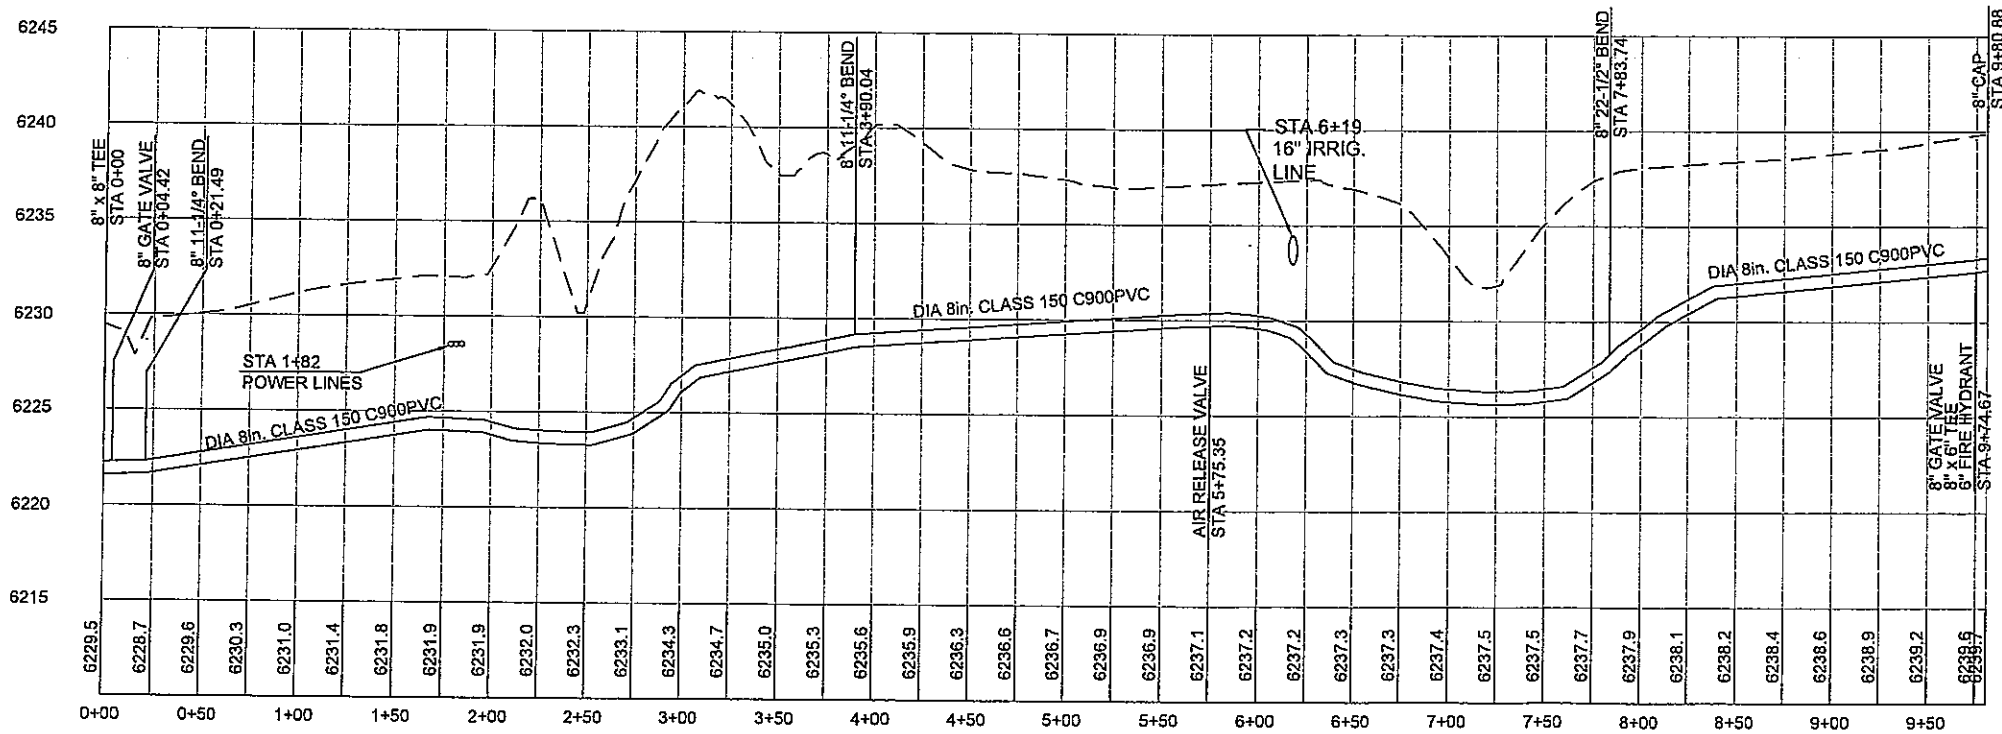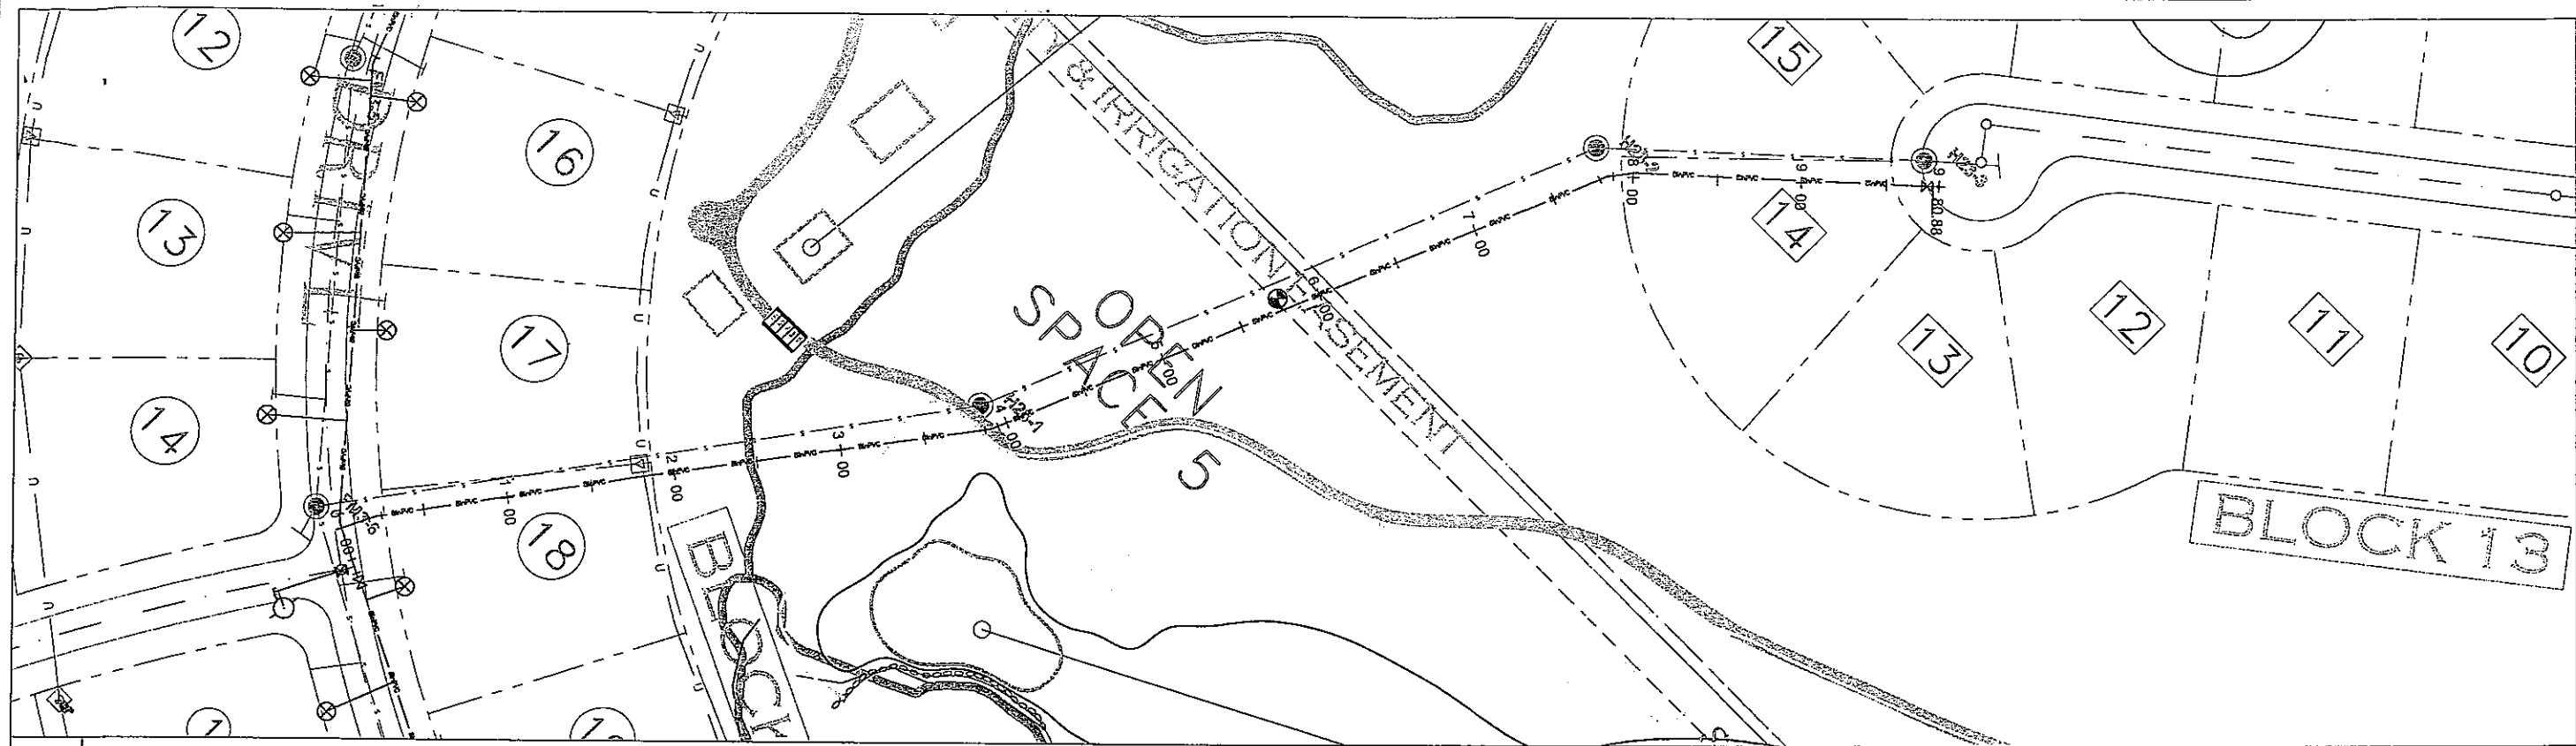

NOTES - THIS SHEET

1. FINISHED GROUND PROFILE IS APPROXIMATE

GENERAL NOTES



Horizontal Scale: 1" = 50'
Vertical Scale: 1" = 5'




Prepared By: EAD
Date: 200
Rev. Date:
Plot Info:
Date: 2000
Page: 4 of 4

RENDEZVOUS ENGINEERING, P.C.
P.O. BOX 4858 JACKSON, WYOMING 83001
25 SOUTH GROS VENTRE STREET
PHONE - 307.733.5552 FAX - 307.733.2334

DRAWING TITLE:
**AS BUILT WATER PLAN & PROFILE
WATER MAIN 'H'
HOLE #3 CROSSING**

PROJECT TITLE:
**TETON SPRINGS
RECORD DRAWINGS**

PROJECT NUMBER:
00-023
DRAWING NUMBER:
ASBW29

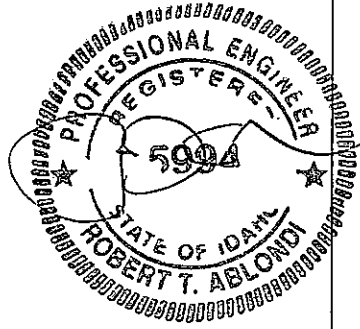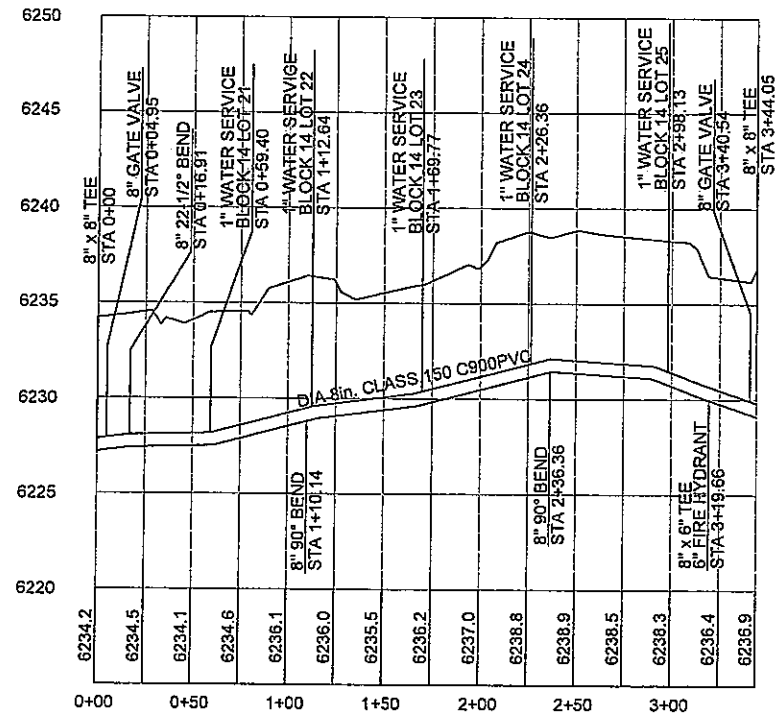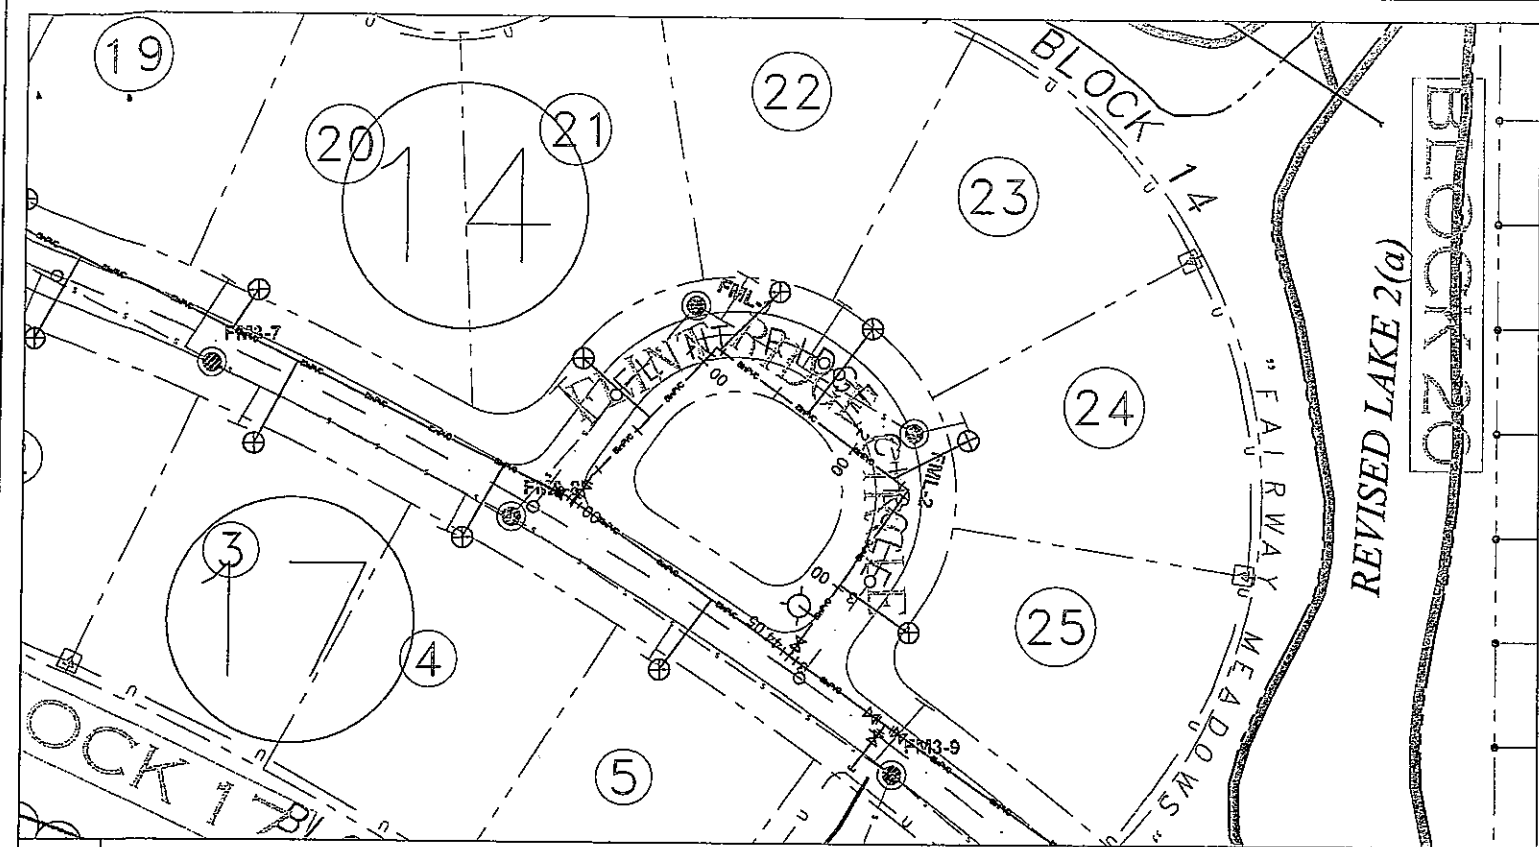

NOTES - THIS SHEET

GENERAL NOTES



Horizontal Scale: 1" = 50'
Vertical Scale: 1" = 5'

PROJECT TITLE:
TETON SPRINGS
RECORD DRAWINGS



00-023

DRAWING
NUMBER:
ASBW30

DRAWING TITLE:
AS BUILT WATER PLAN & PROFILE
WATER MAIN '1'
FLINT RIDGE CIRCLE

RENDEZVOUS ENGINEERING, P.C.
P.O. BOX 4858 JACKSON, WYOMING 83001
25 SOUTH GROS VENTRE STREET
PHONE • 307.733.5252 FAX • 307.733.2334


Prepared By: BDD
Date: 2/03
Rev. Date:
Plot Info:
Data:
Pilot:

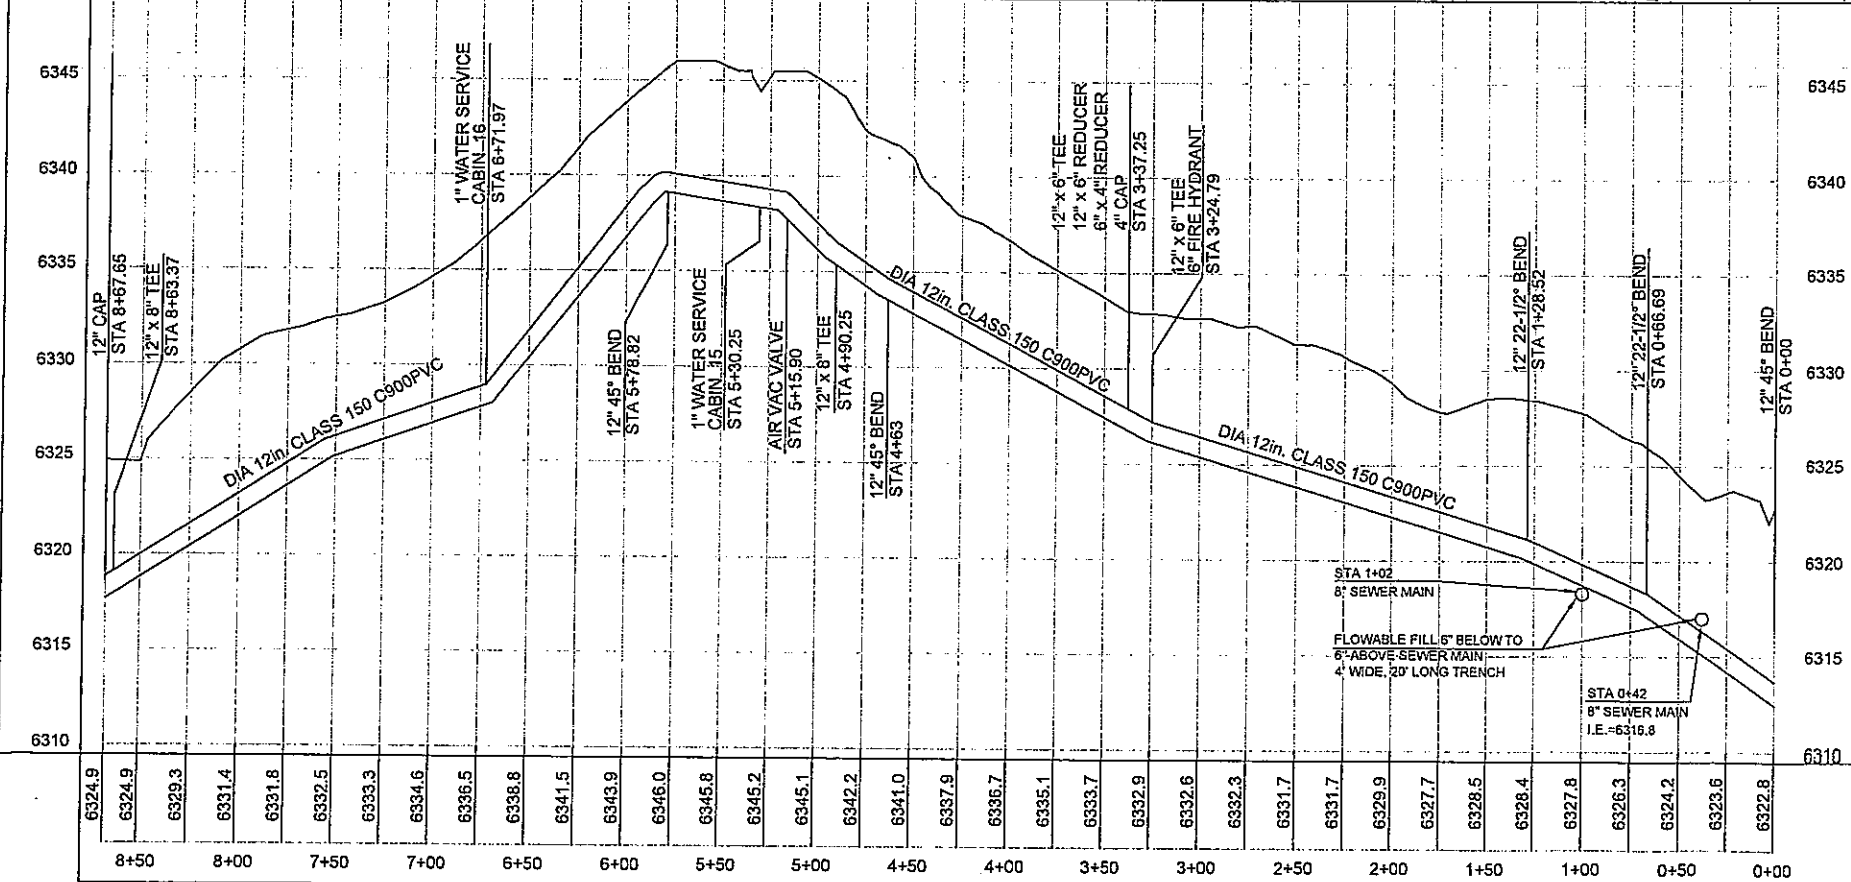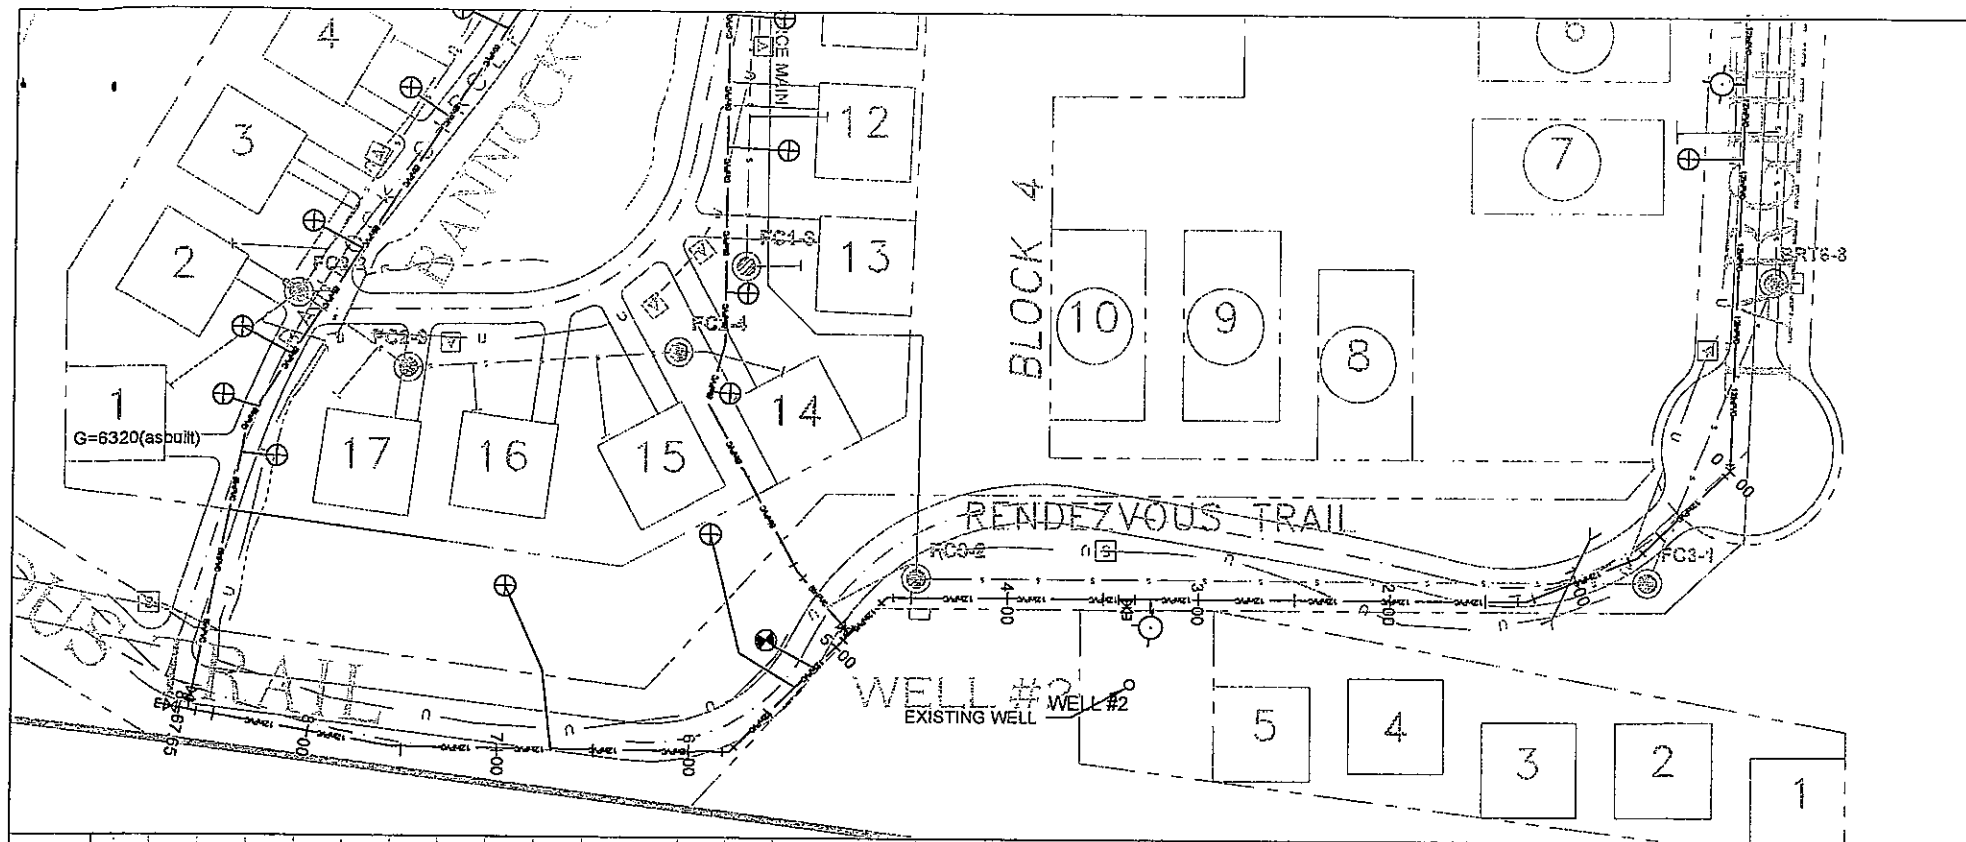



NOTES - THIS SHEET

GENERAL NOTES

Horizontal Scale: 1" = 50'
Vertical Scale: 1" = 5'

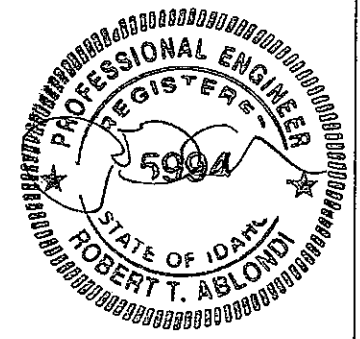

RENDZVOUS ENGINEERING, P.C. P.O. BOX 4858 JACKSON, WYOMING 83001 25 SOUTH CROSS CENTRE STREET PHONE - 307.753.9252 FAX - 307.753.9334		Prepared By: EDO Date: 200 Rev. Date: Rev. Info: Date: Path:
PROJECT TITLE: TETON SPRINGS RECORD DRAWINGS		DRAWING TITLE: AS BUILT WATER PLAN & PROFILE WATER MAIN 'K' RENDZVOUS TRAIL
PROJECT NUMBER: 00-023		
DRAWING NUMBER: ASBW31		

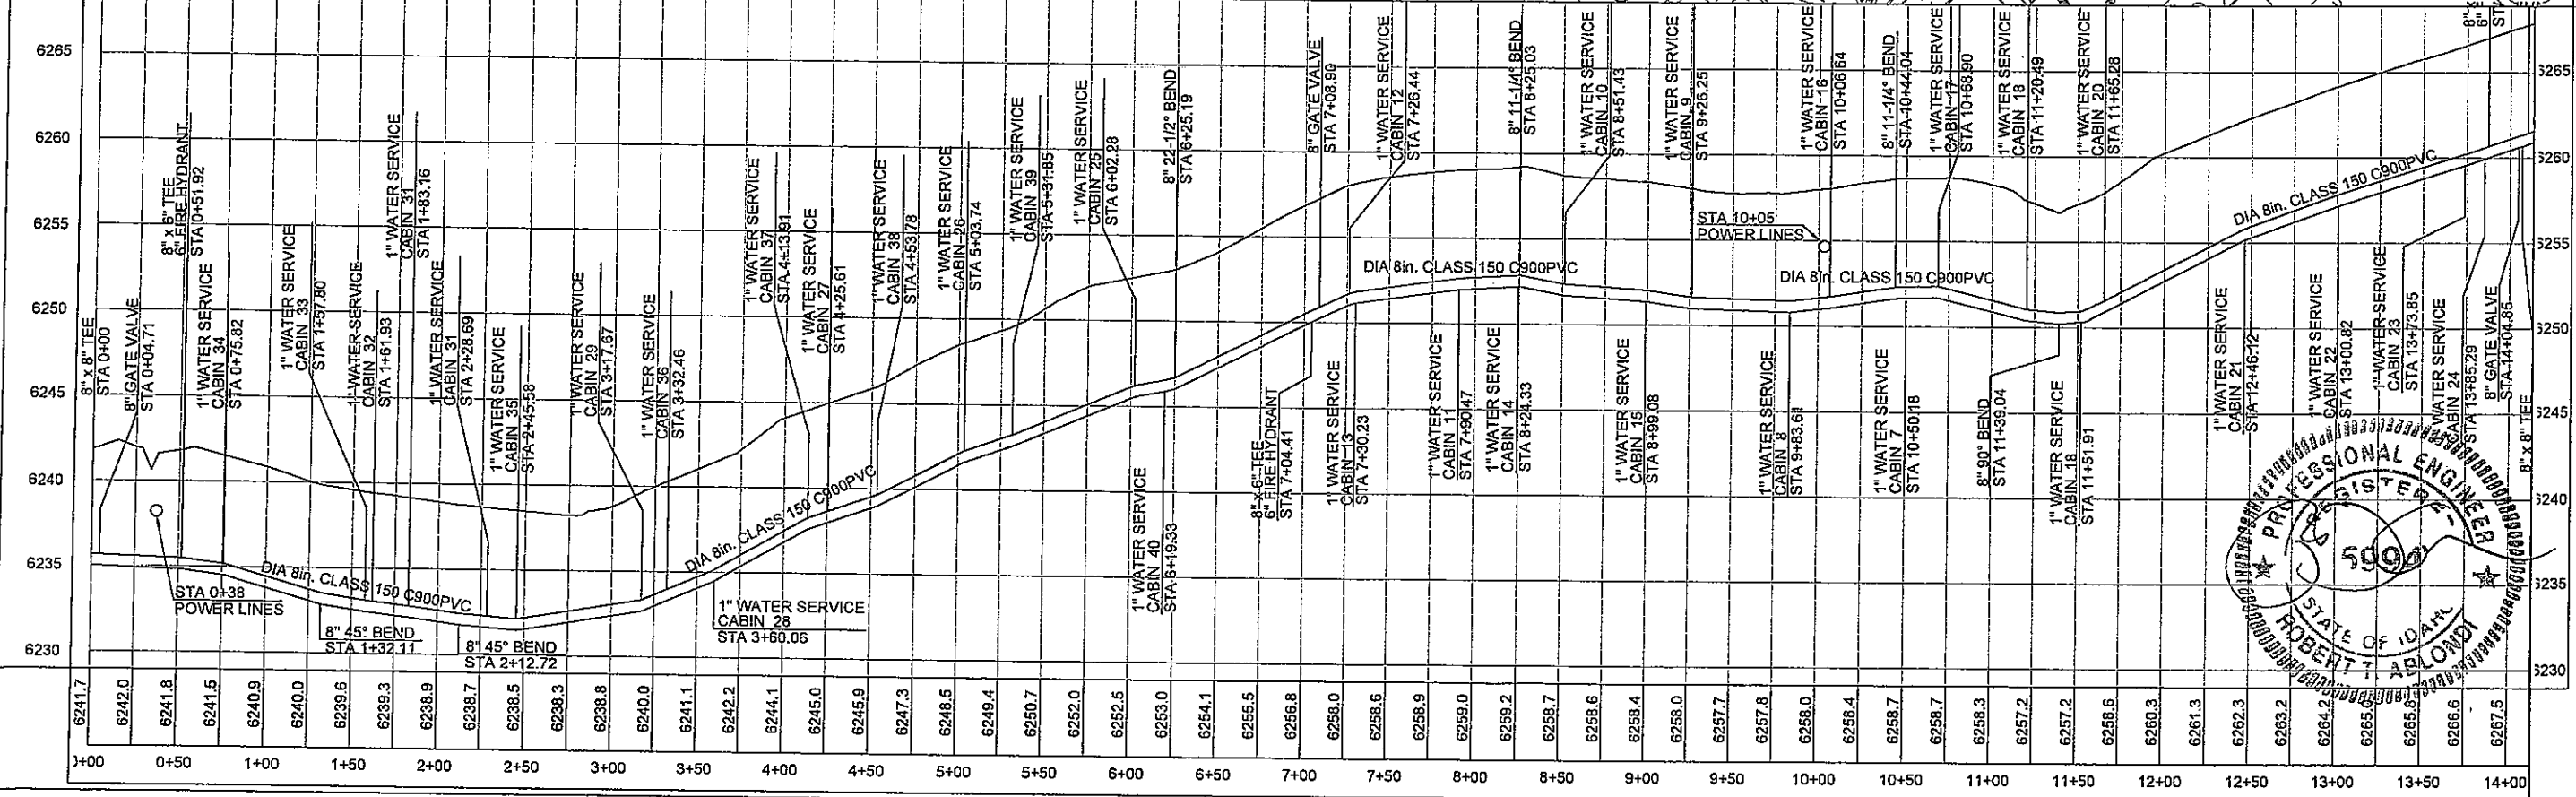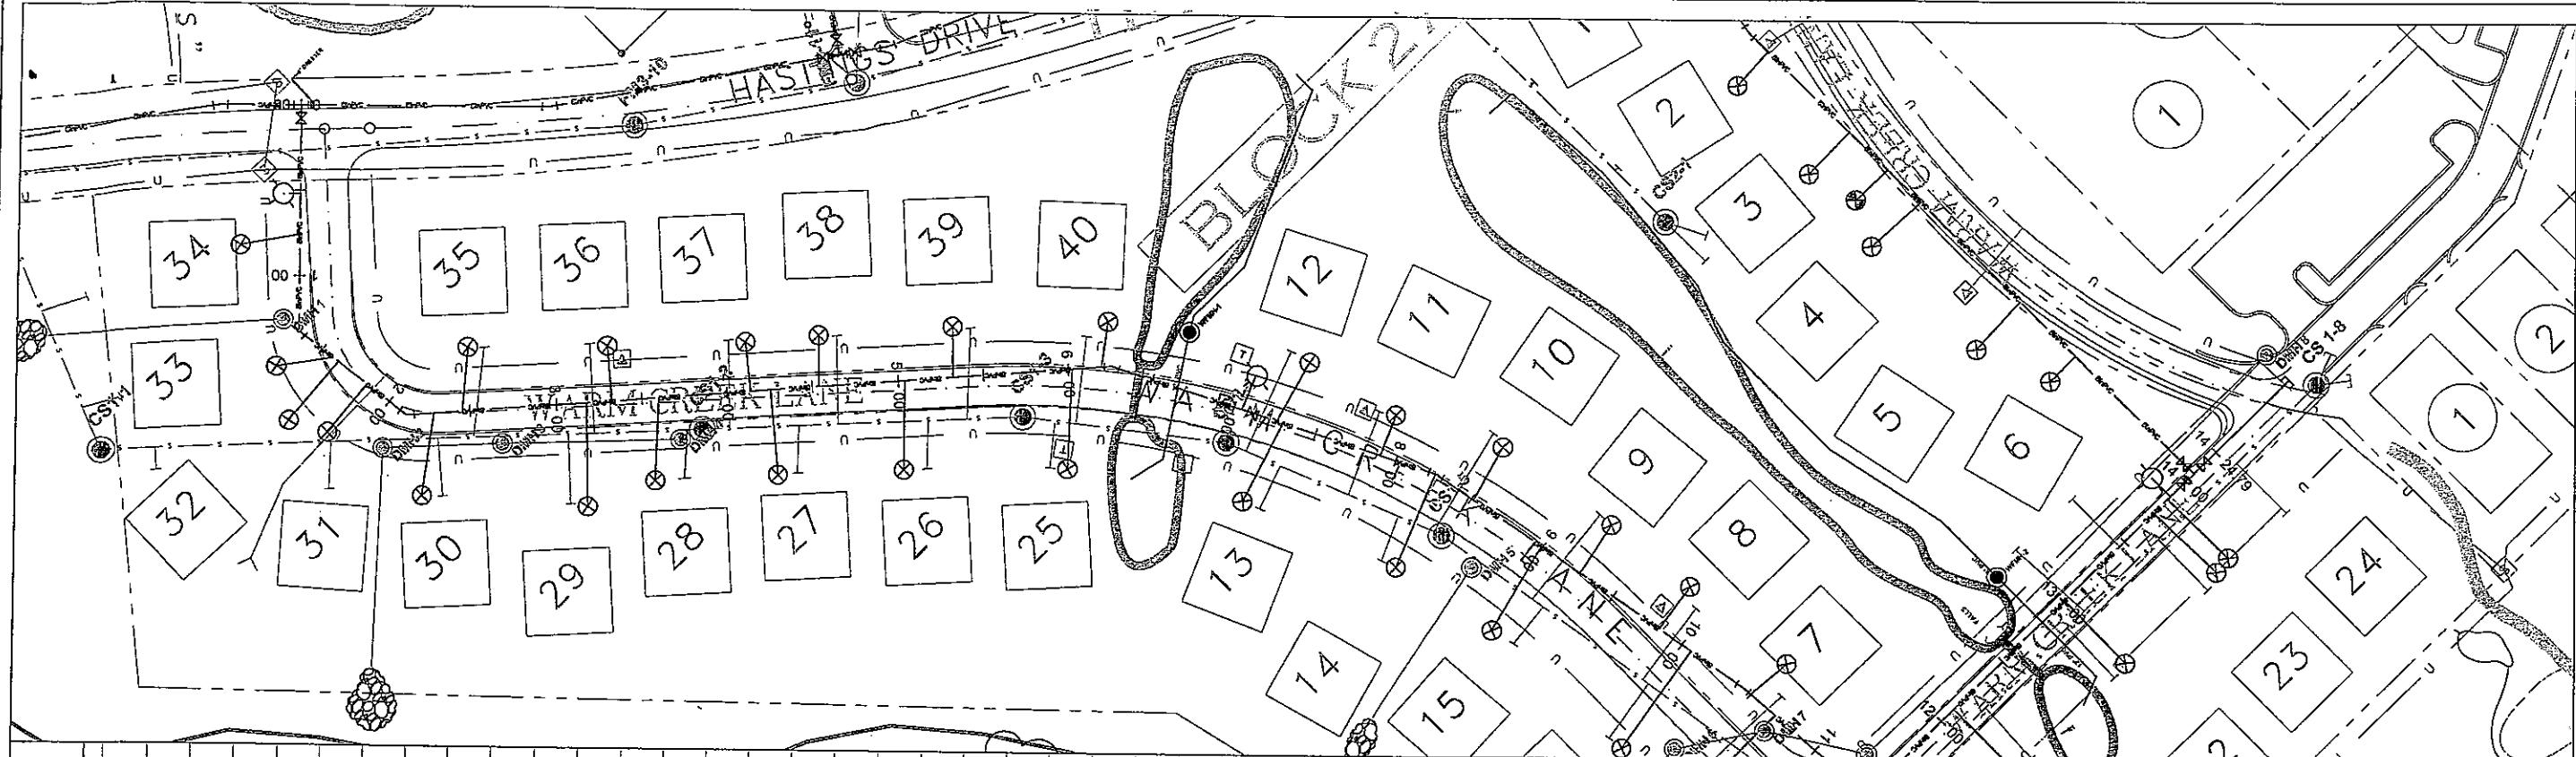


NOTES - THIS SHEET

GENERAL NOTES



Horizontal Scale: 1" = 50'
Vertical Scale: 1" = 5'

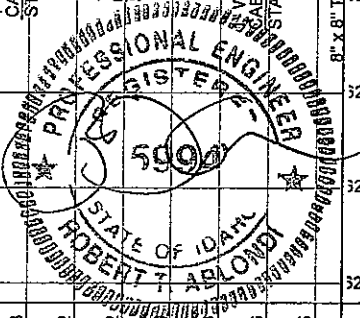

PROJECT TITLE:
TETON SPRINGS
RECORD DRAWINGS

PROJECT NUMBER:
00-023

DRAWING NUMBER:
ASBW32

DRAWING TITLE:
AS BUILT WATER PLAN & PROFILE
WATER MAIN 'L'
CREEKSIDEWARM CREEK

PREPARED BY: EDO

DATE: 2003

REV. DATE:

REV. INFO:

DATE: 2003

DATE: 2003




DATE: 2003

RENDEZVOUS ENGINEERING, P.C.

P.O. BOX 4858 JACKSON, WYOMING 83001

25 SOUTH GROSVENTRE STREET

PHONE - 307.733.5252 FAX - 307.733.2334

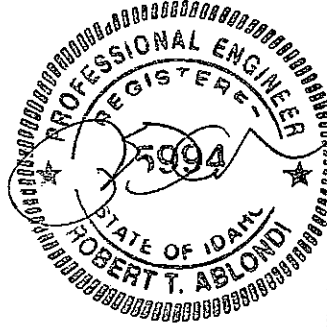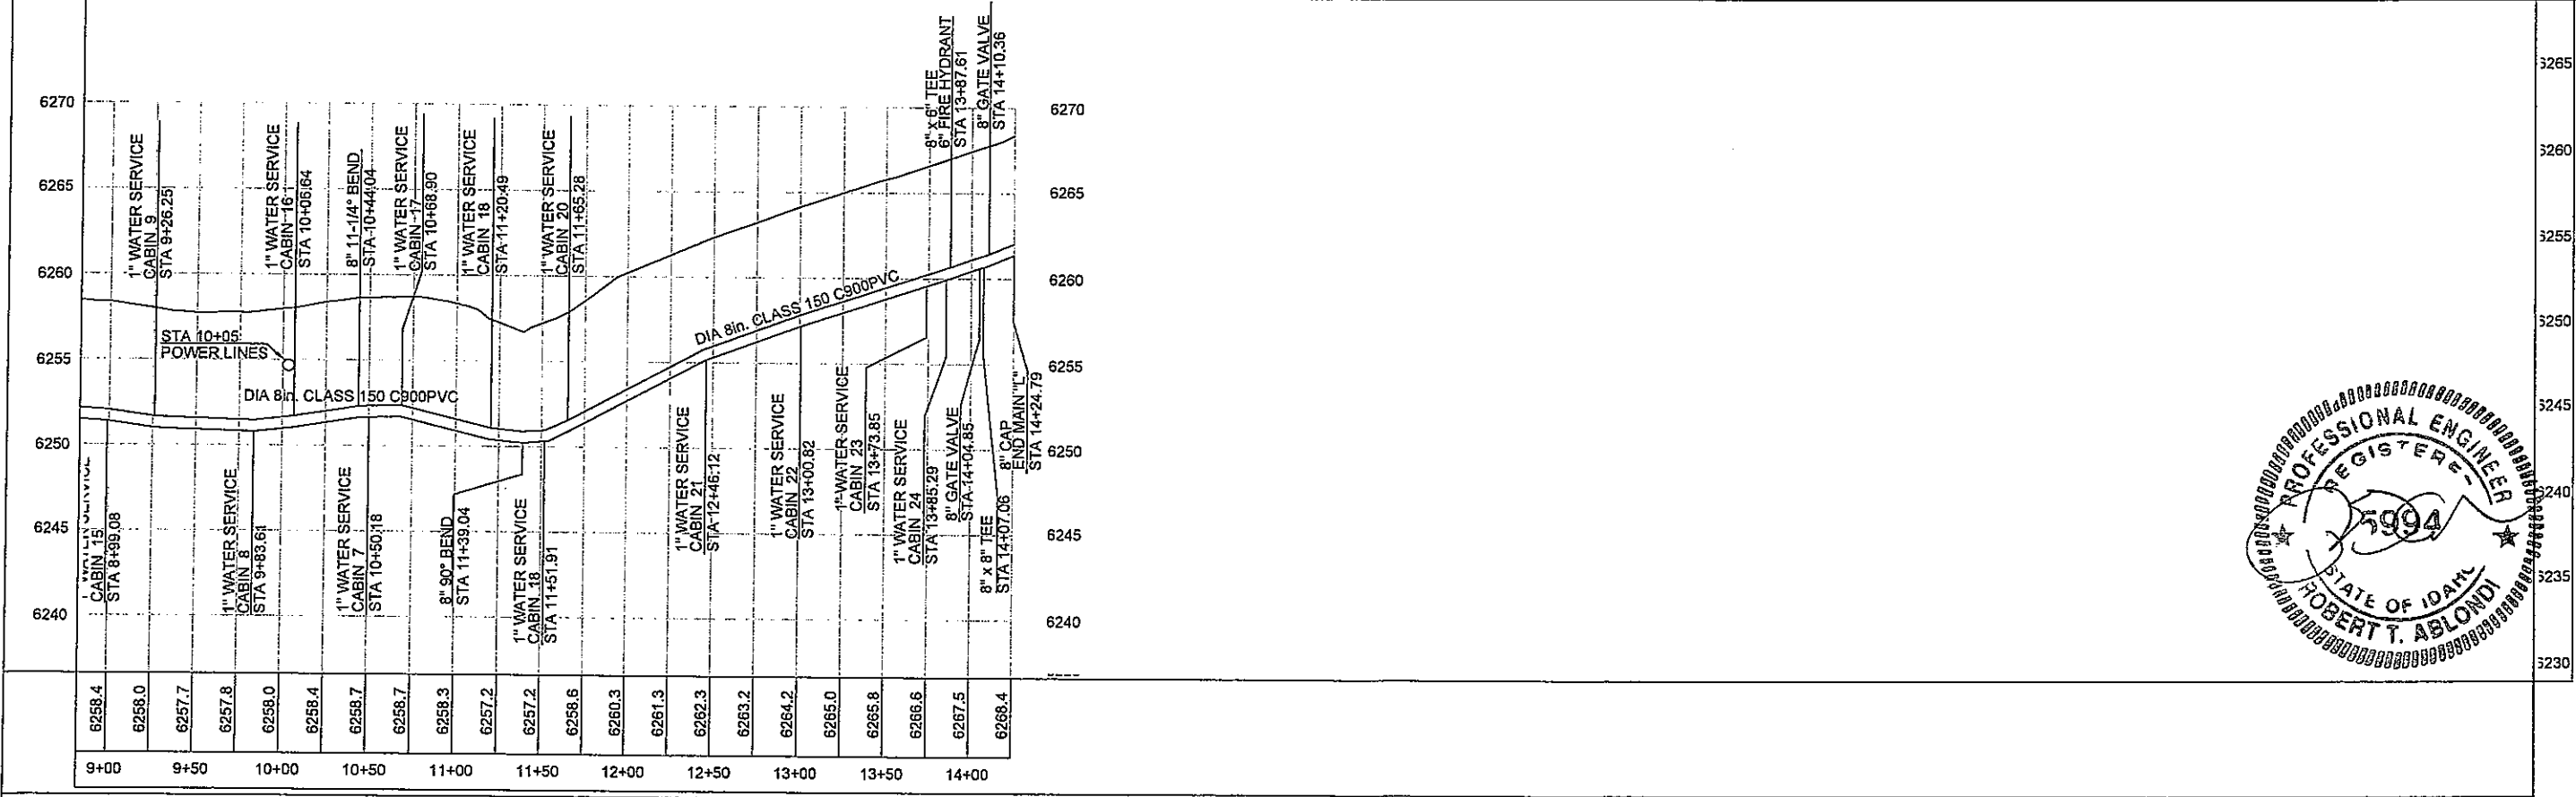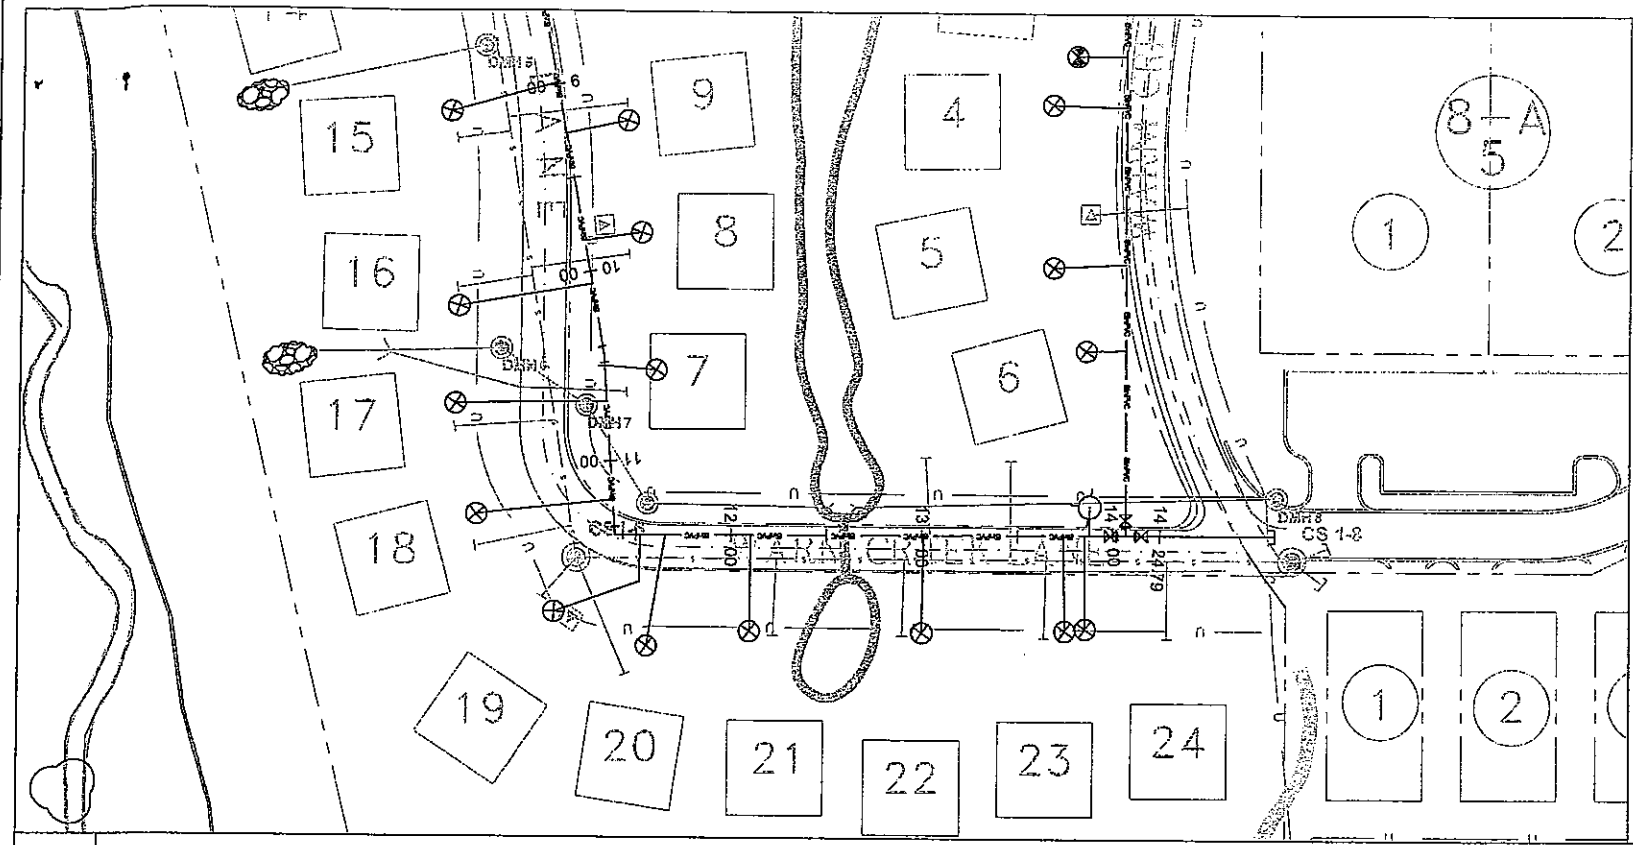

NOTES - THIS SHEET

GENERAL NOTES



Horizontal Scale: 1" = 50'
Vertical Scale: 1" = 5'

PROJECT TITLE:
TETON SPRINGS
RECORD DRAWINGS

PROJECT NUMBER:
00-023

DRAWING NUMBER:
ASBW33

DRAWING TITLE:
AS BUILT WATER PLAN & PROFILE
WATER MAIN "L"
CREEKSIDE/WARM CREEK

PREPARED BY: EDO

DATE: 2/03

REV. DATE:

REV. DATE:

DATE: 4/03




DATE: 4/03

RENDEZVOUS ENGINEERING, P.C.

P.O. BOX 4858 JACKSON, WYOMING 83001

25 SOUTH CROS VENTRE STREET

PHONE - 307.733.5252 FAX - 307.733.2334

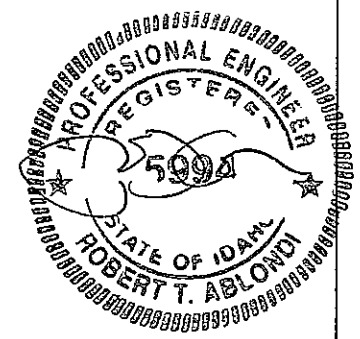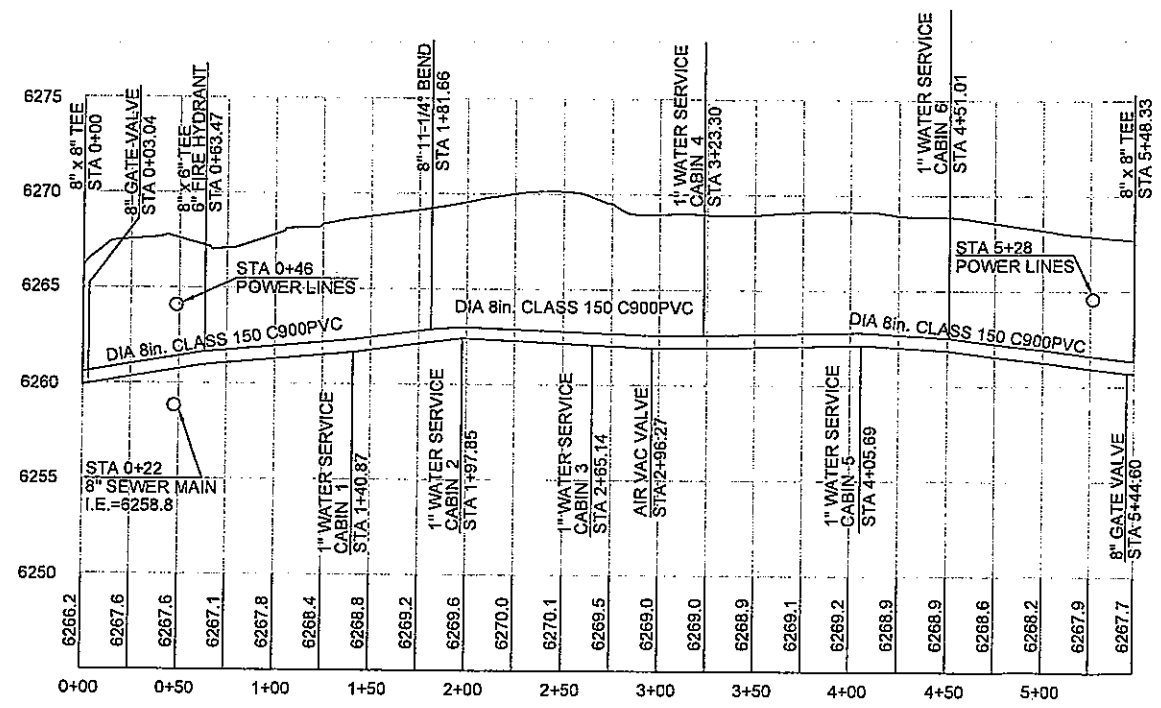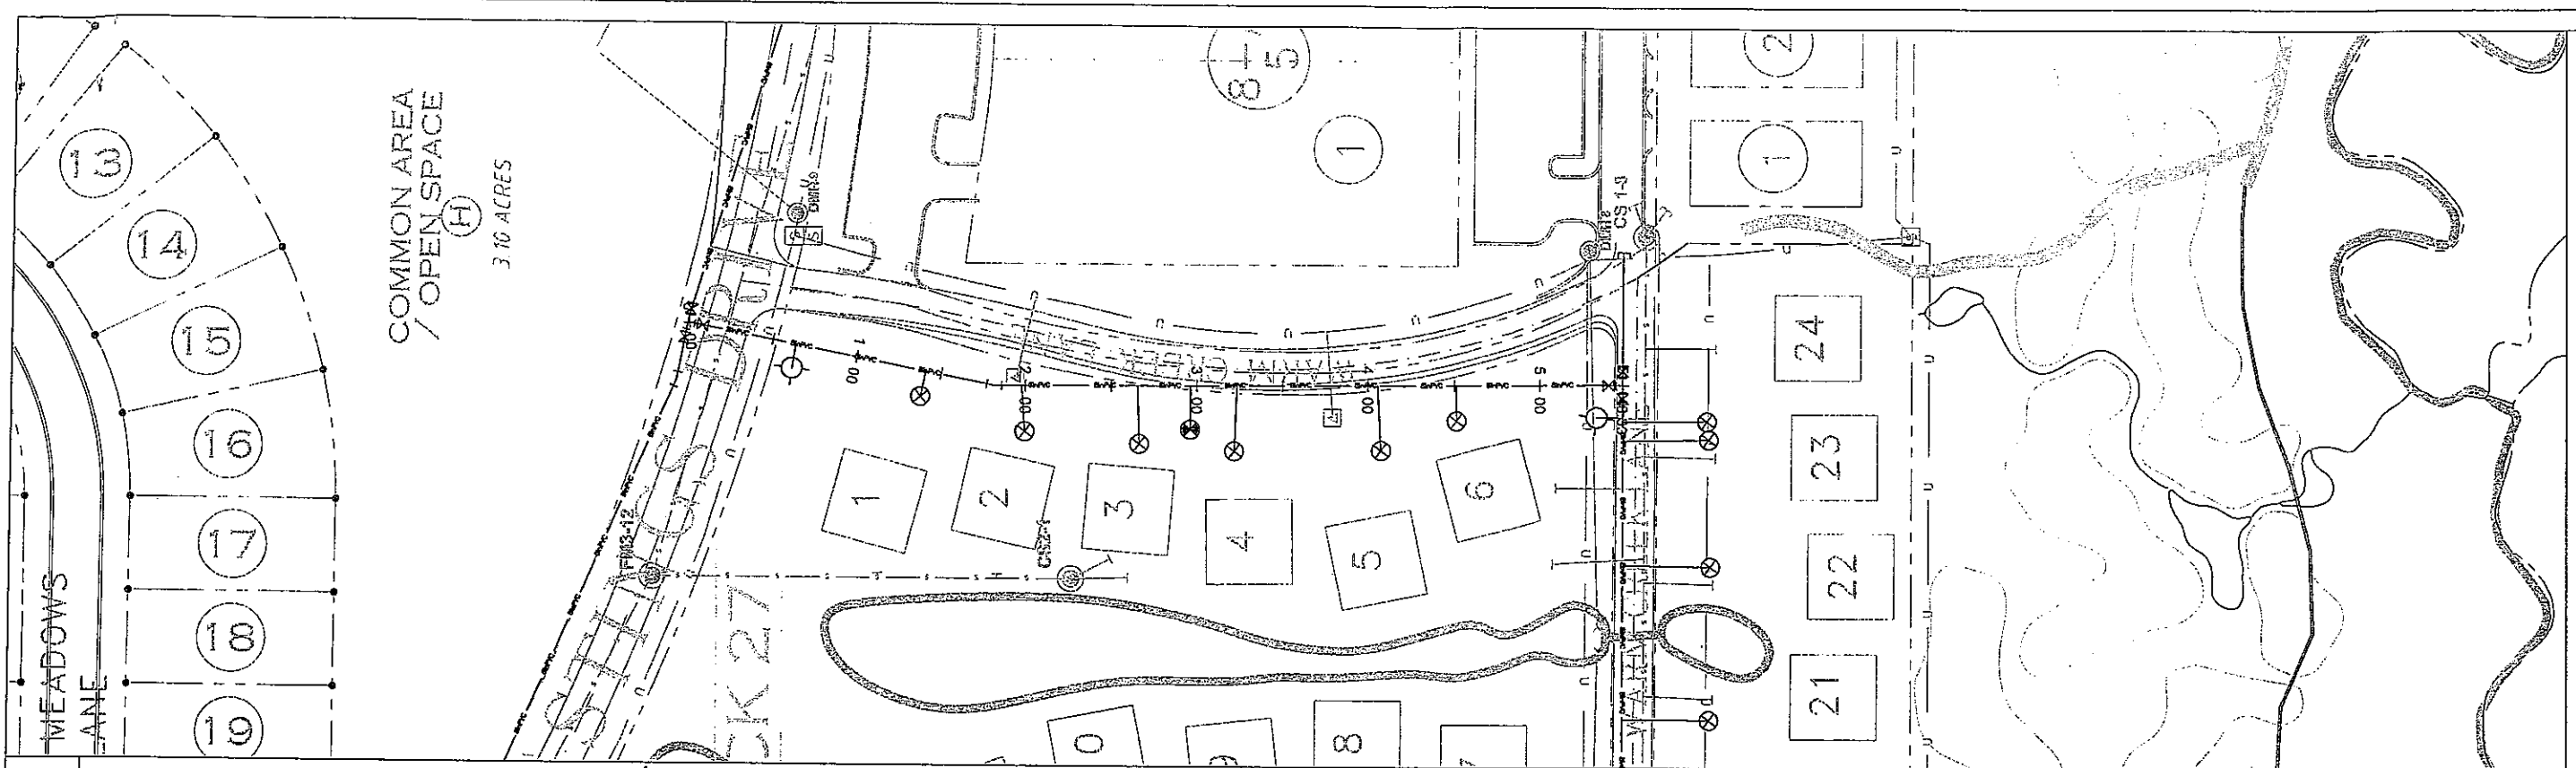

NOTES - THIS SHEET

GENERAL NOTES

Horizontal Scale: 1" = 50'
Vertical Scale: 1" = 5'

PROJECT TITLE:
**TETON SPRINGS
RECORD DRAWINGS**



PROJECT
NUMBER:
00-023

DRAWING
NUMBER:
ASBW34

DRAWING TITLE:
**AS BUILT WATER PLAN & PROFILE
WATER MAIN 'M'
CREEKSIDEWARM CREEK**


**RENDEZVOUS ENGINEERING, P.C.**
P.O. BOX 4859 JACKSON, WYOMING 83001
25 SOUTH GROS VENTRE STREET
PHONE - 307.733.5252 FAX - 307.733.2334

Prepared By: EDO
Date: 2/03
Rev. Date:
Plot Info:
Data:
Path:

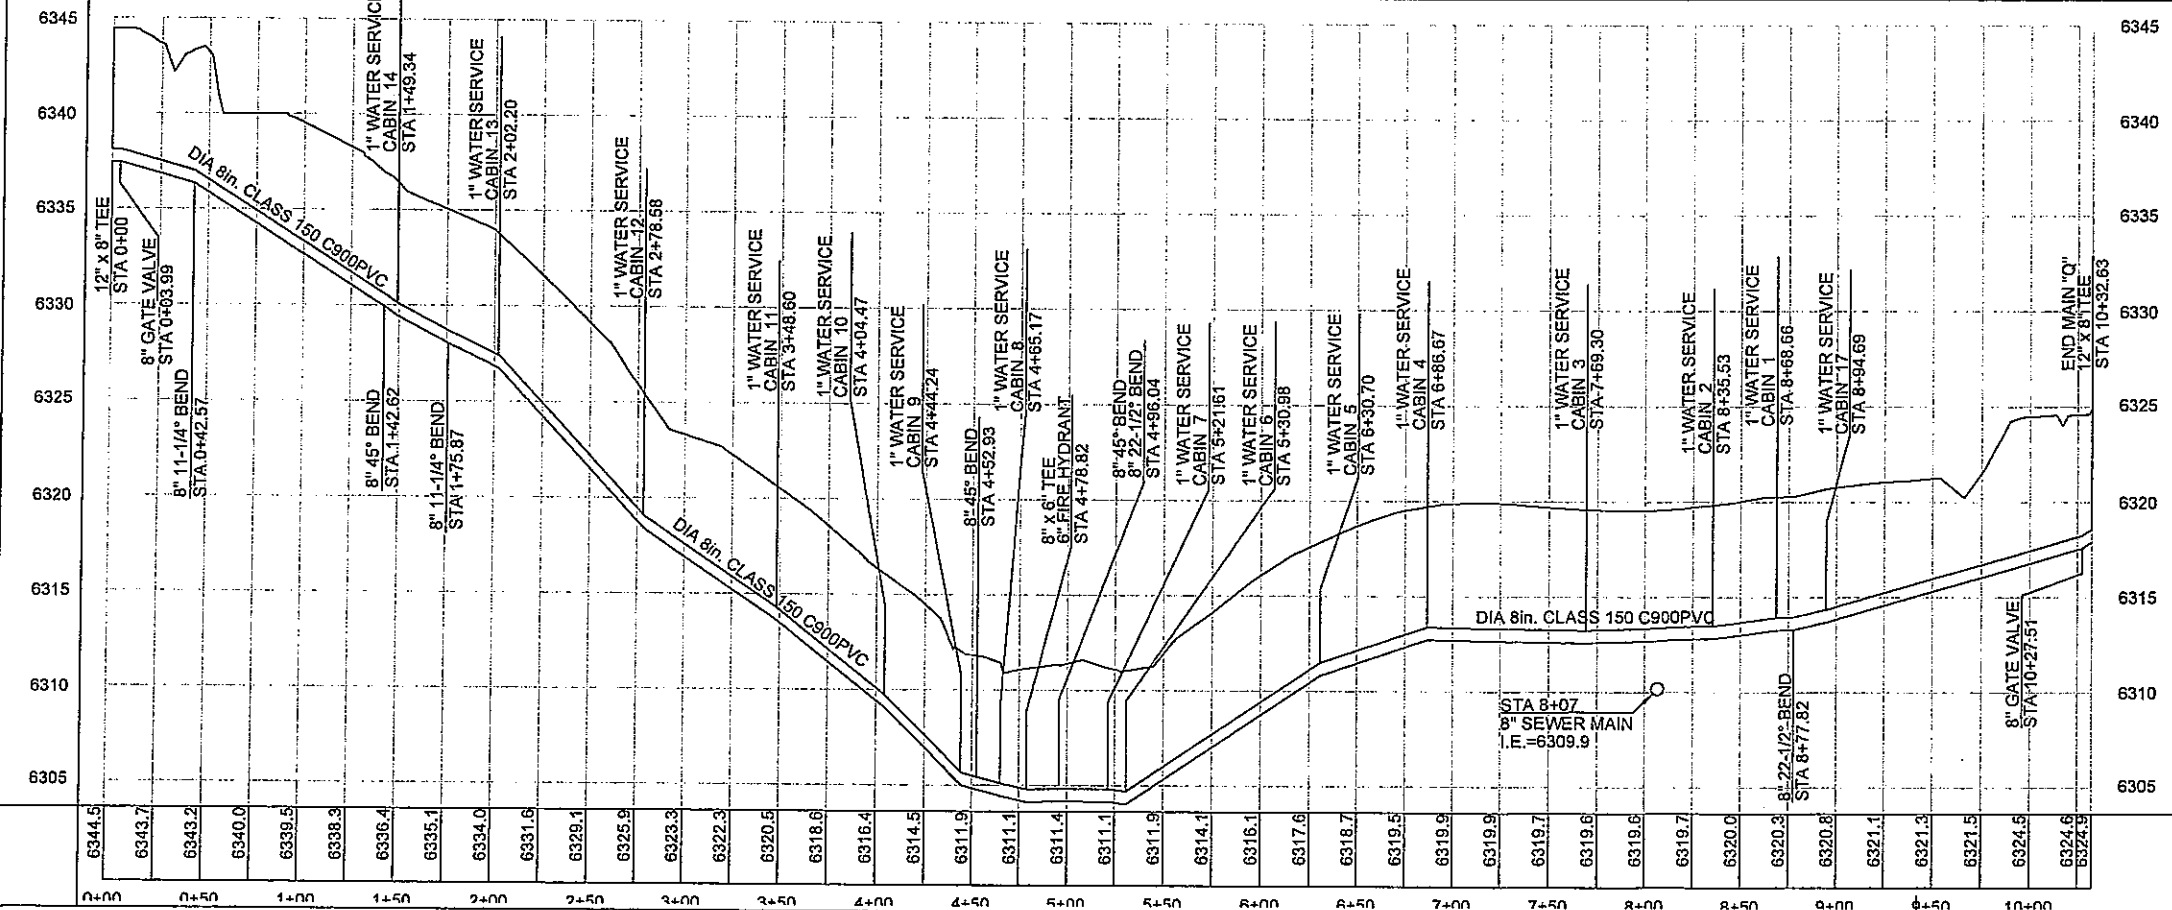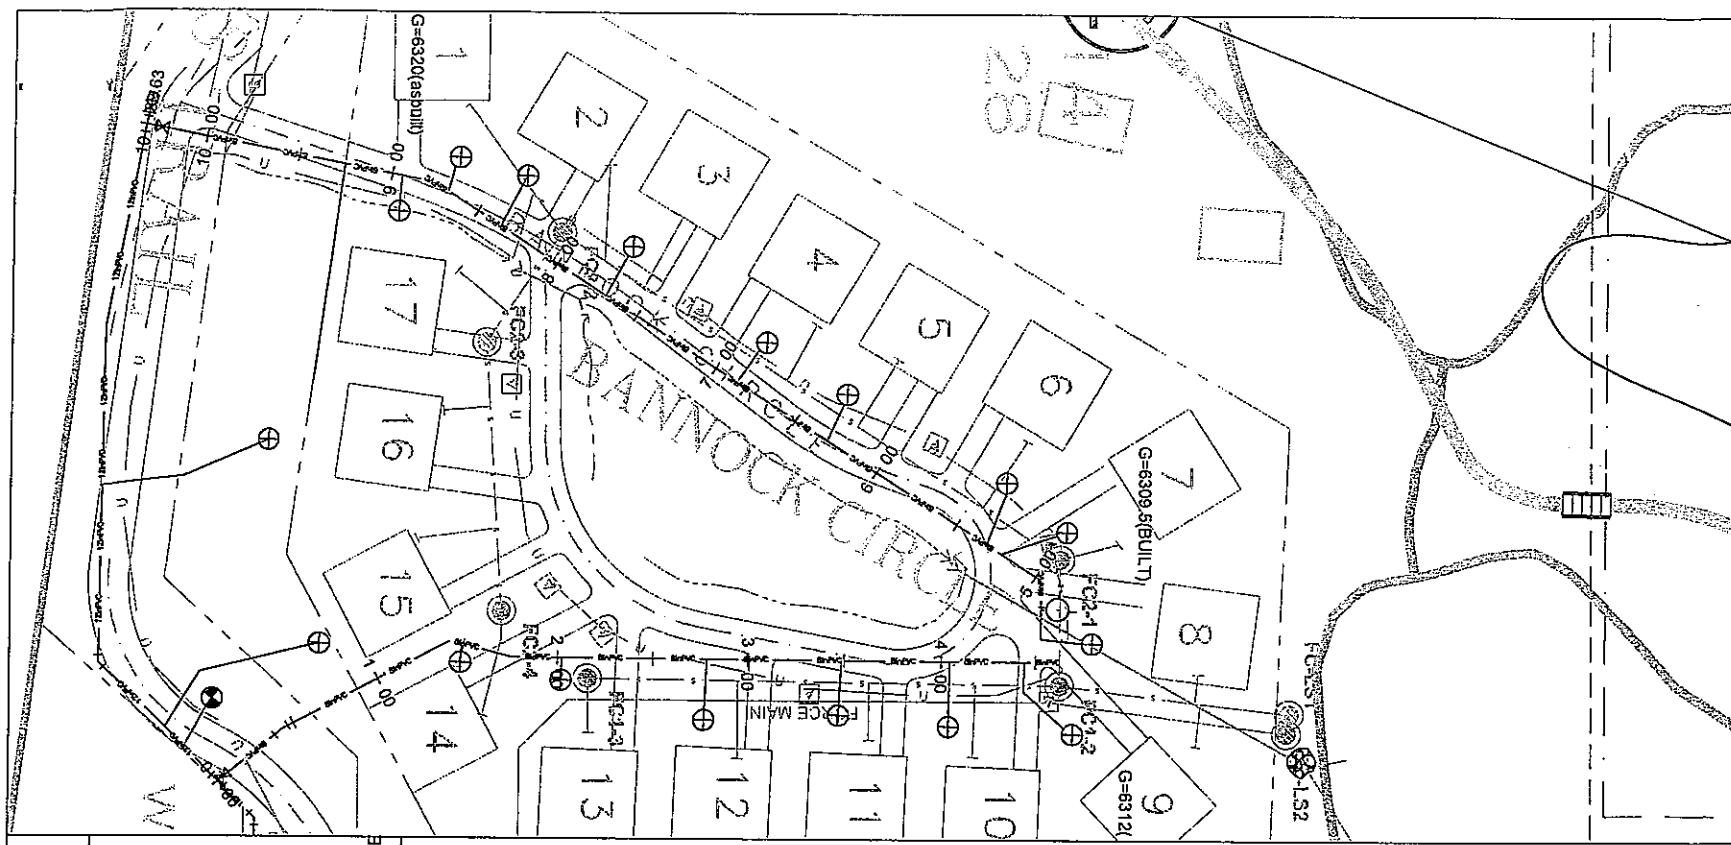

NOTES - THIS SHEET

GENERAL NOTES

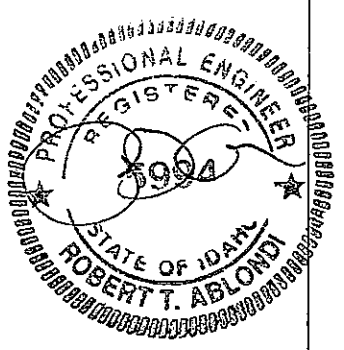

Horizontal Scale: 1" = 50'
Vertical Scale: 1" = 5'



Prepared By: EDD
Date: 2/03
Rev. Date:
Plot Info:
Data: 8/14/04, 1/14/05, 8/14/05
Palt:

RENDEZVOUS ENGINEERING, P.C.
P.O. BOX 4858 JACKSON, WYOMING 83001
25 SOUTH CROSS VENTRE STREET
PHONE - 307.753.5252 FAX - 307.753.2354

DRAWING TITLE:
**AS BUILT WATER PLAN & PROFILE
WATER MAIN 'Q'
FOREST CABINS/BANNOCK CIRCLE**


PROJECT TITLE:
**TETON SPRINGS
RECORD DRAWINGS**

PROJECT NUMBER:
00-023
DRAWING NUMBER:
ASBW35

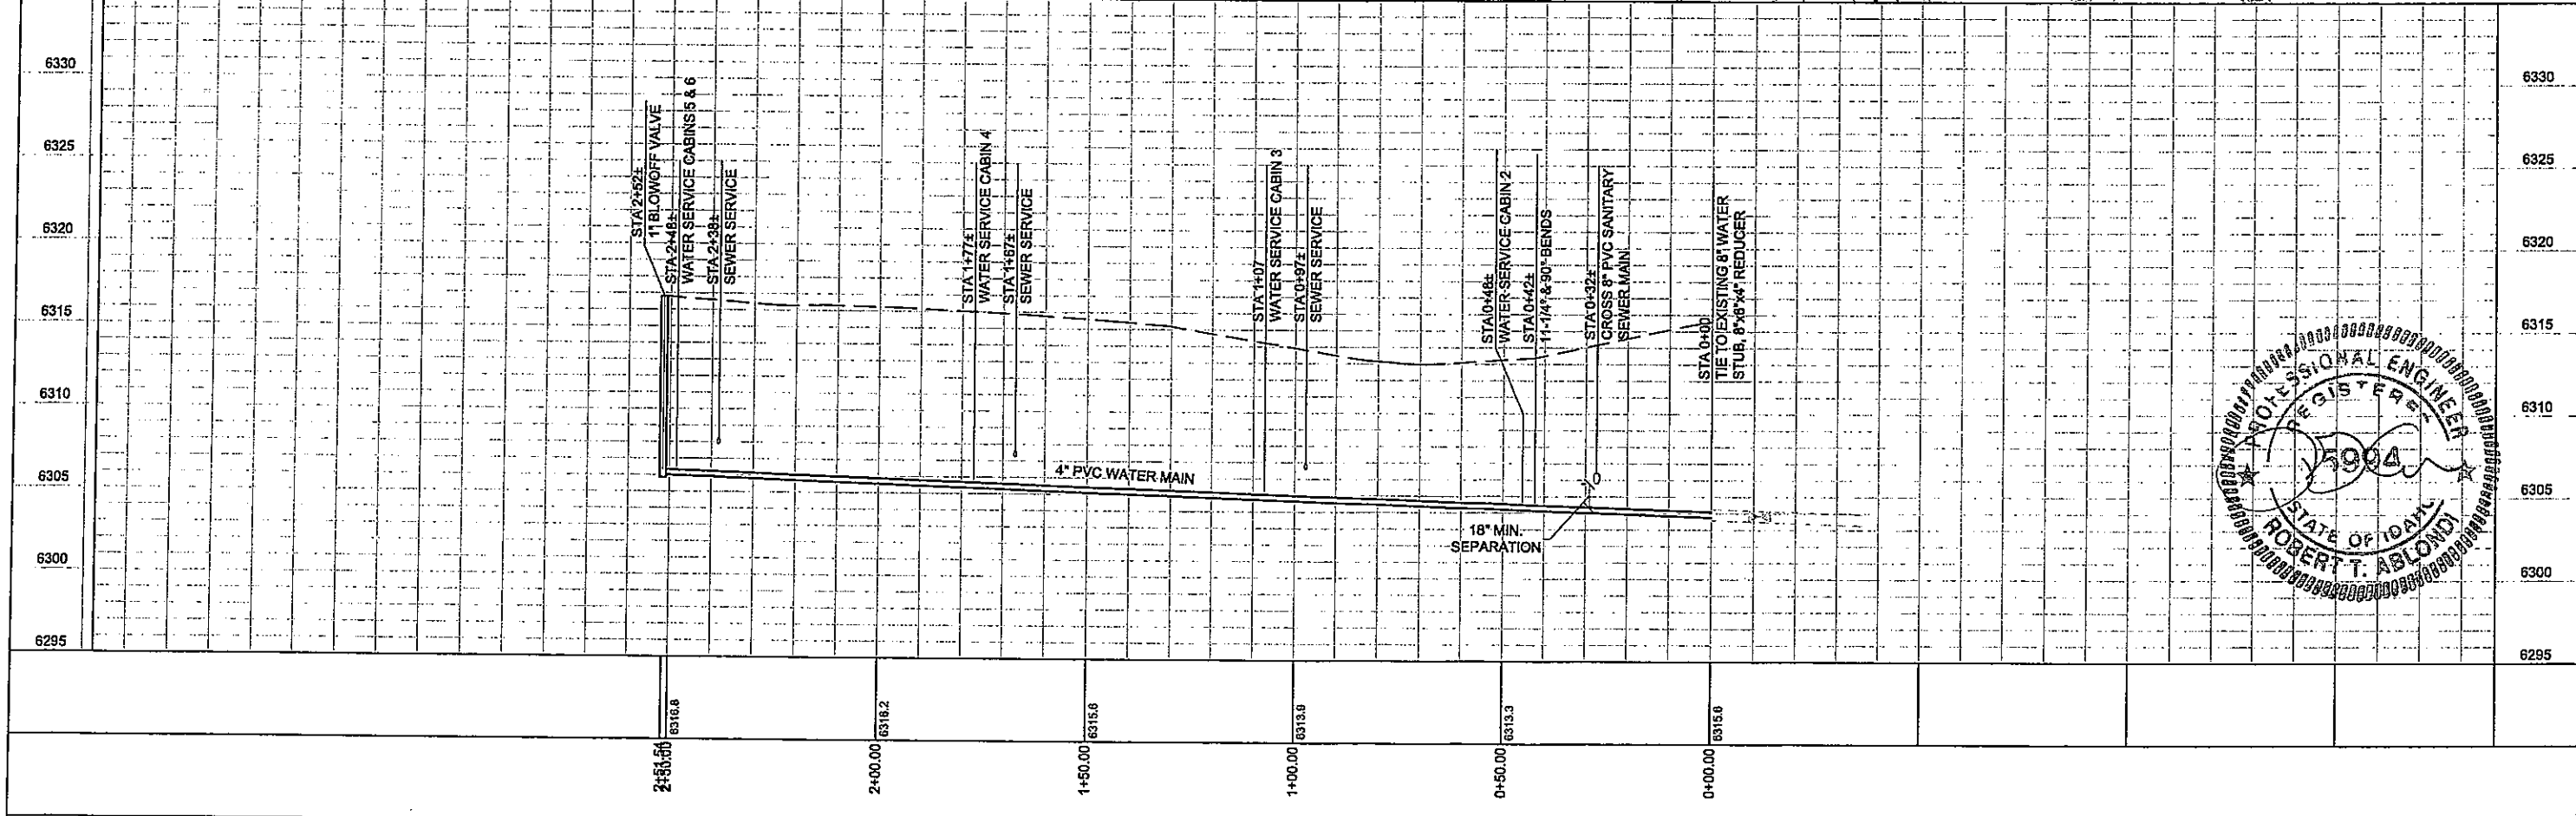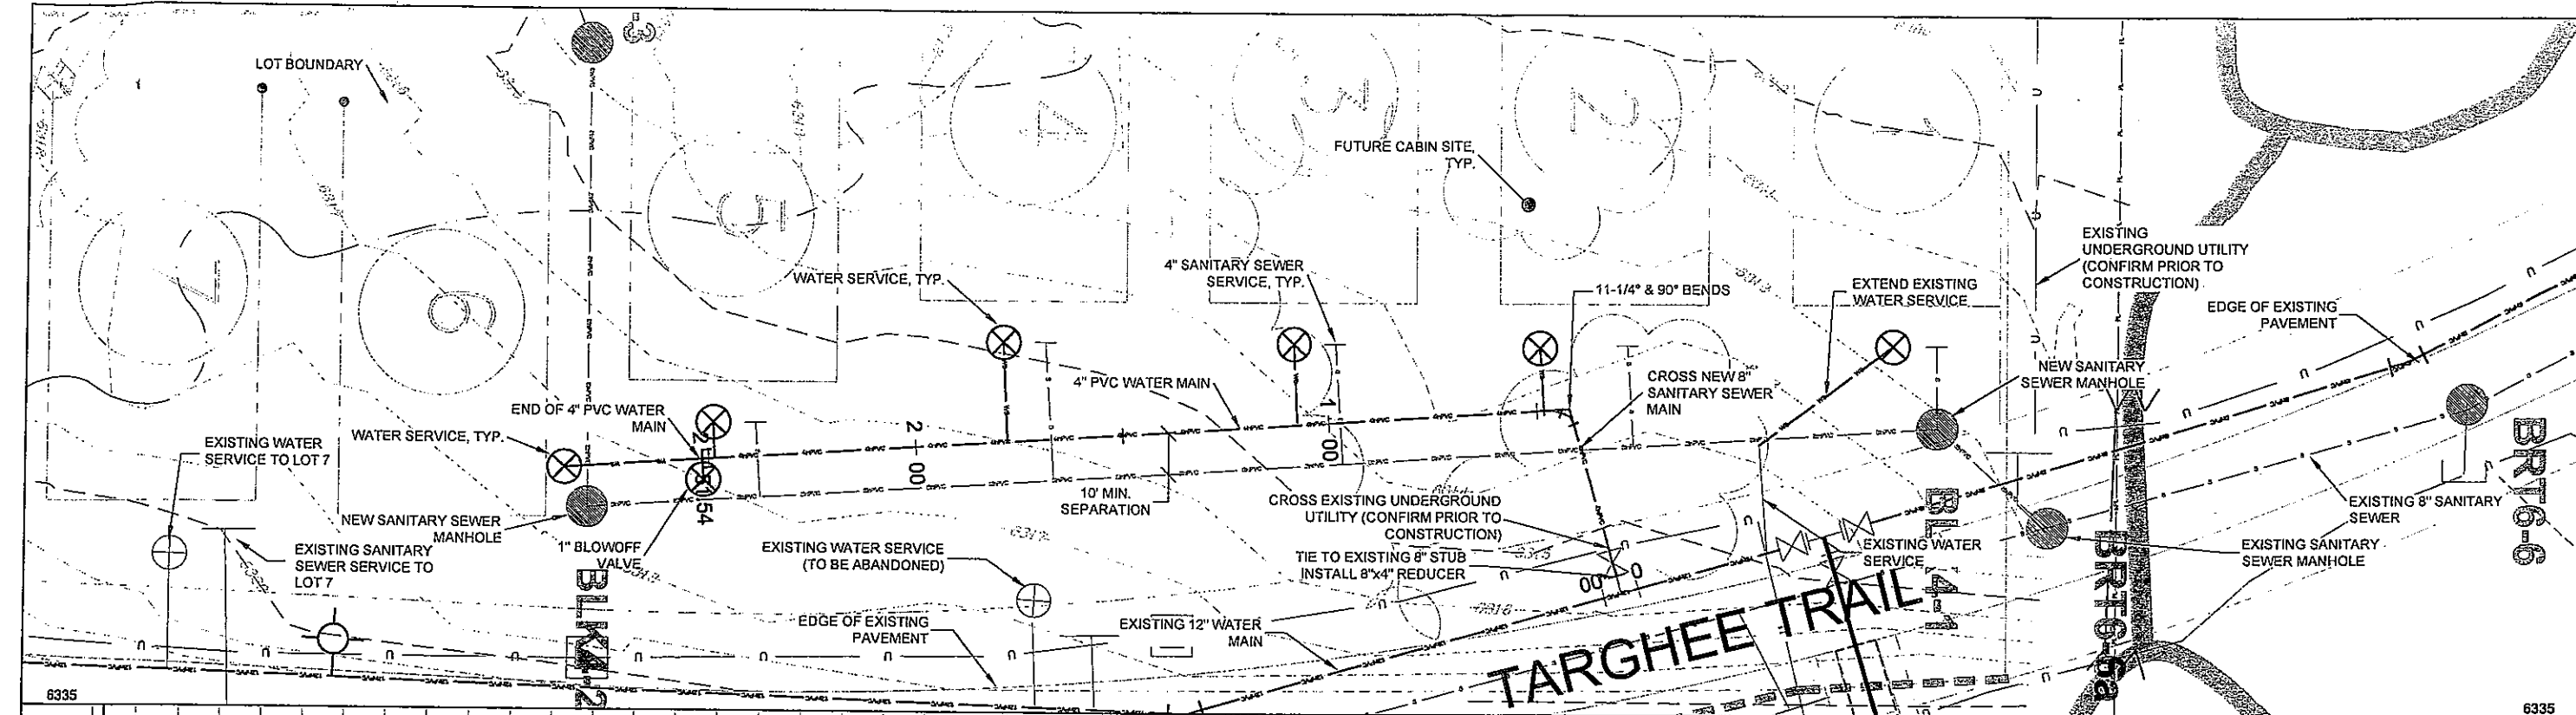

NOTES - THIS SHEET

GENERAL NOTES

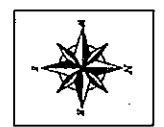

SCALE: 1" = 20' HORZ.
1" = 5' VERT.




Prepared By: JAC
Date: 10/07
Rev. Date:

RENDEZVOUS ENGINEERING, P.C.
P.O. BOX 4858 JACKSON, WYOMING 83001
25 SOUTH GROS VENTRE STREET
PHONE - 307.733.9322 FAX - 307.733.2334

DRAWING TITLE:
ASBUILT WATER MAIN
WATER MAIN 'R'
FOREST CABINS BLOCK 4

PROJECT TITLE:
RECORD DRAWINGS
TETON SPRINGS

PROJECT NUMBER:
04-002
1.5
DRAWING NUMBER:
ASBW-36

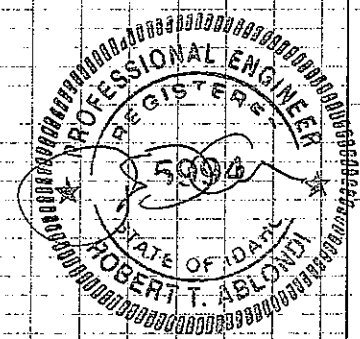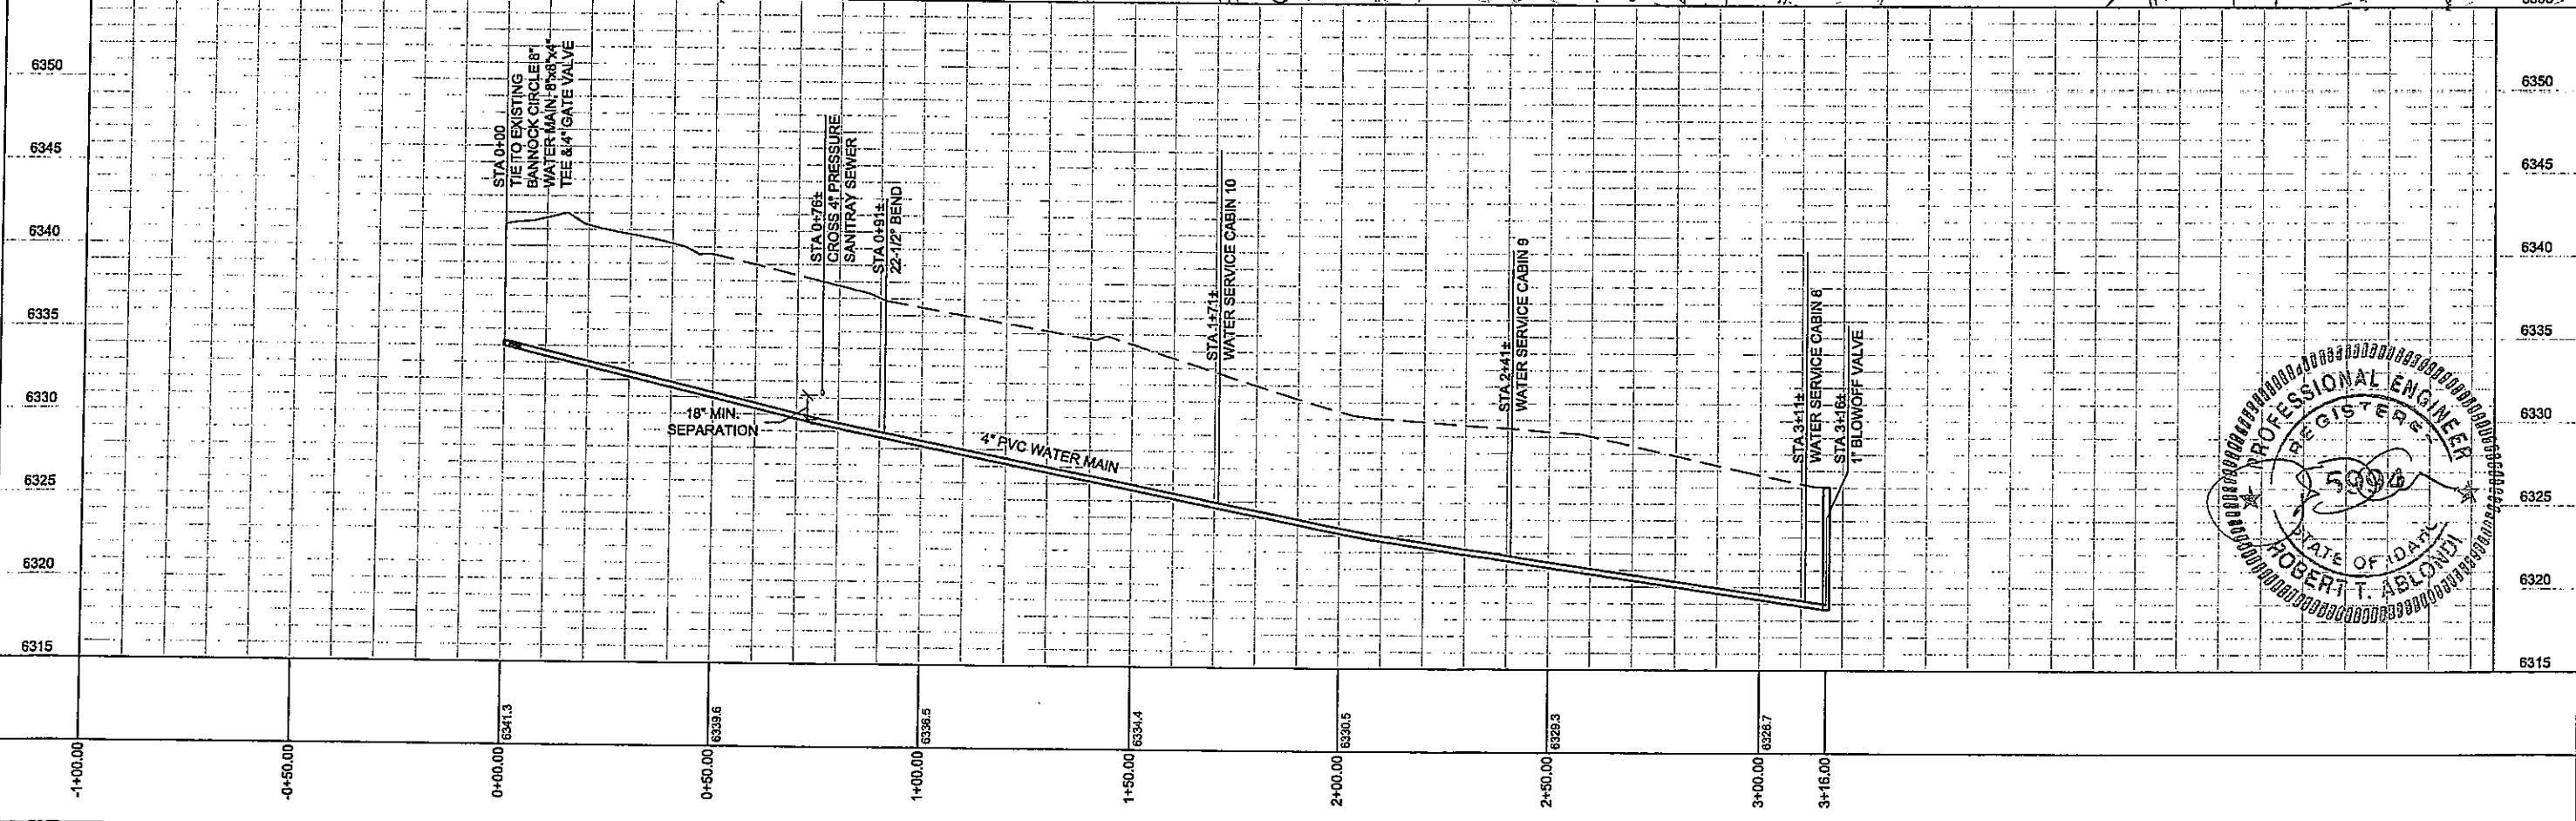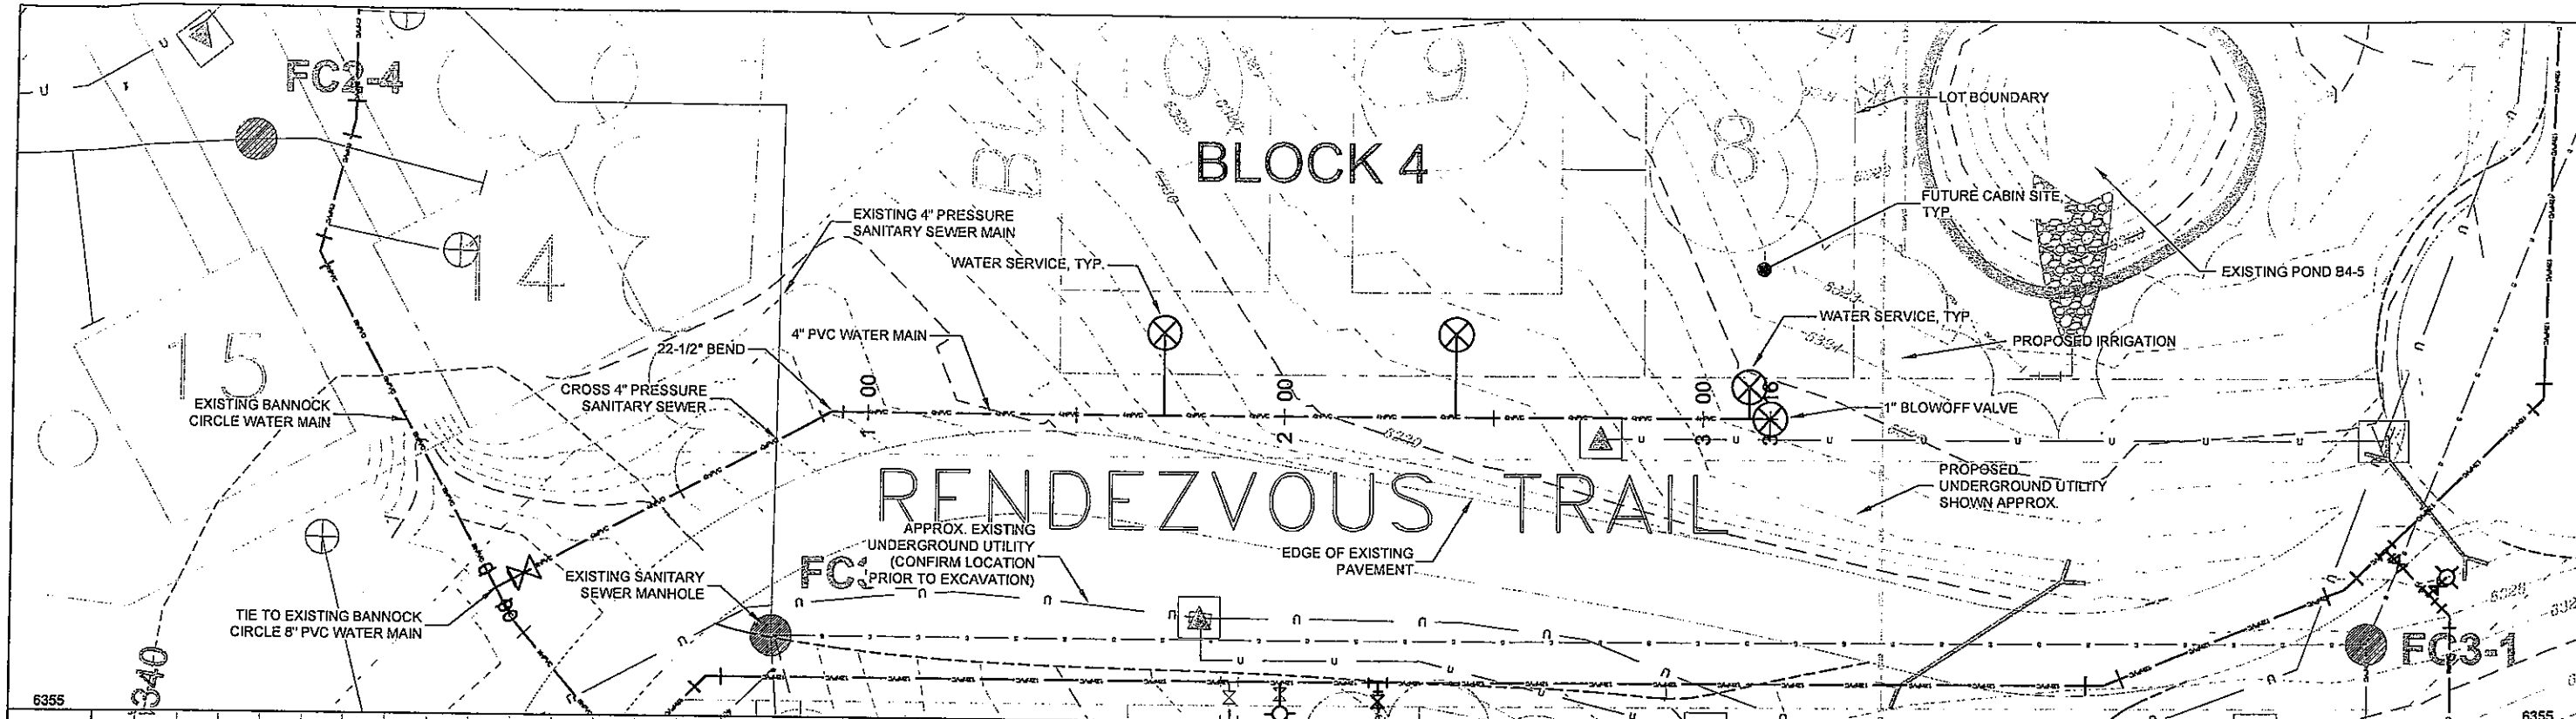

NOTES - THIS SHEET



EXISTING UTILITIES ARE SHOWN APPROXIMATE. CONFIRM LOCATION PRIOR TO EXCAVATION.

GENERAL NOTES





SCALE: 1" = 20' HORZ.
1" = 5' VERT.

Prepared By: JAC		Date: 10-07		Rev. Date:	
RENDEZVOUS ENGINEERING, P.C.					
P.O. BOX 4855 JACKSON, WYOMING 83001					
25 SOUTH GROES VENTRE STREET					
PHONE - 307.733.5252 FAX - 307.733.2334					
DRAWING TITLE: ASBUILT WATERMAIN WATER MAIN 'R' FOREST CABINS BLOCK 4					
PROJECT TITLE: RECORD DRAWINGS TETON SPRINGS					
PROJECT NUMBER: 04-002 1.5					
DRAWING NUMBER: ASBW-37					

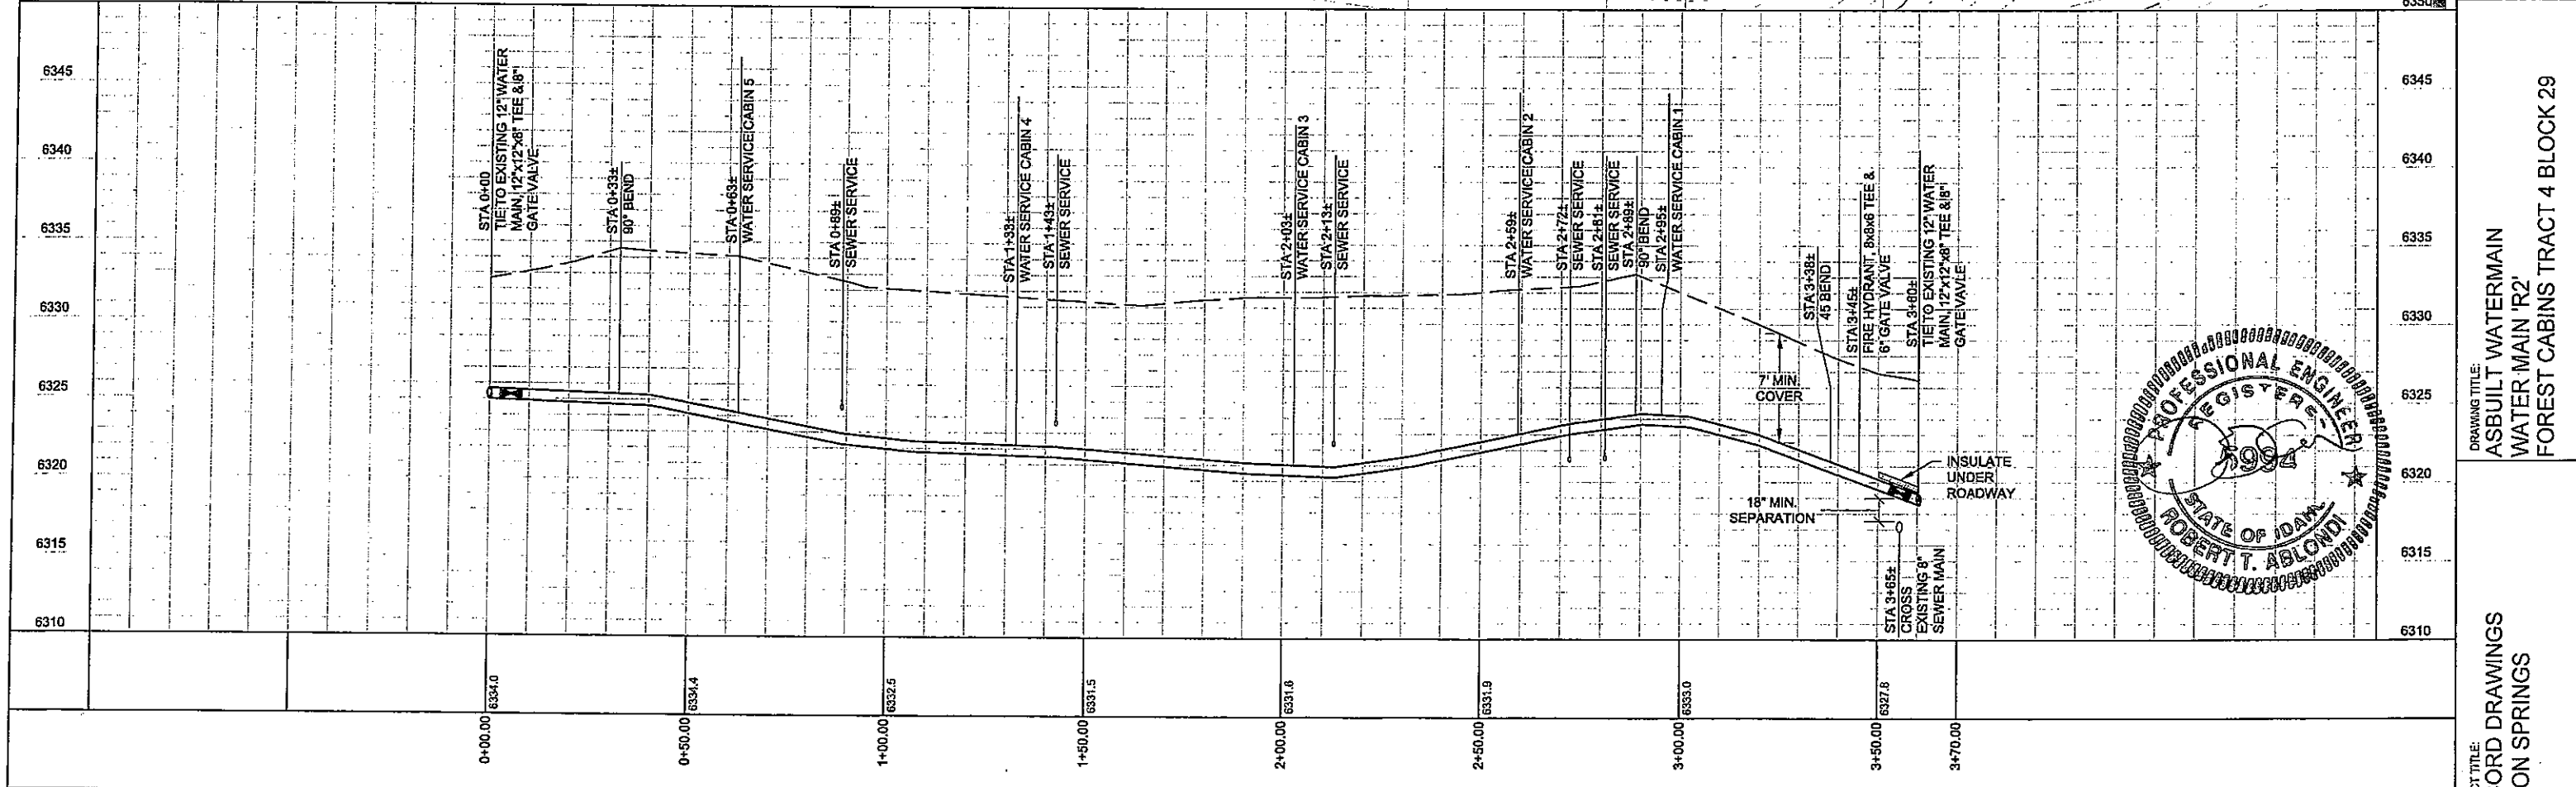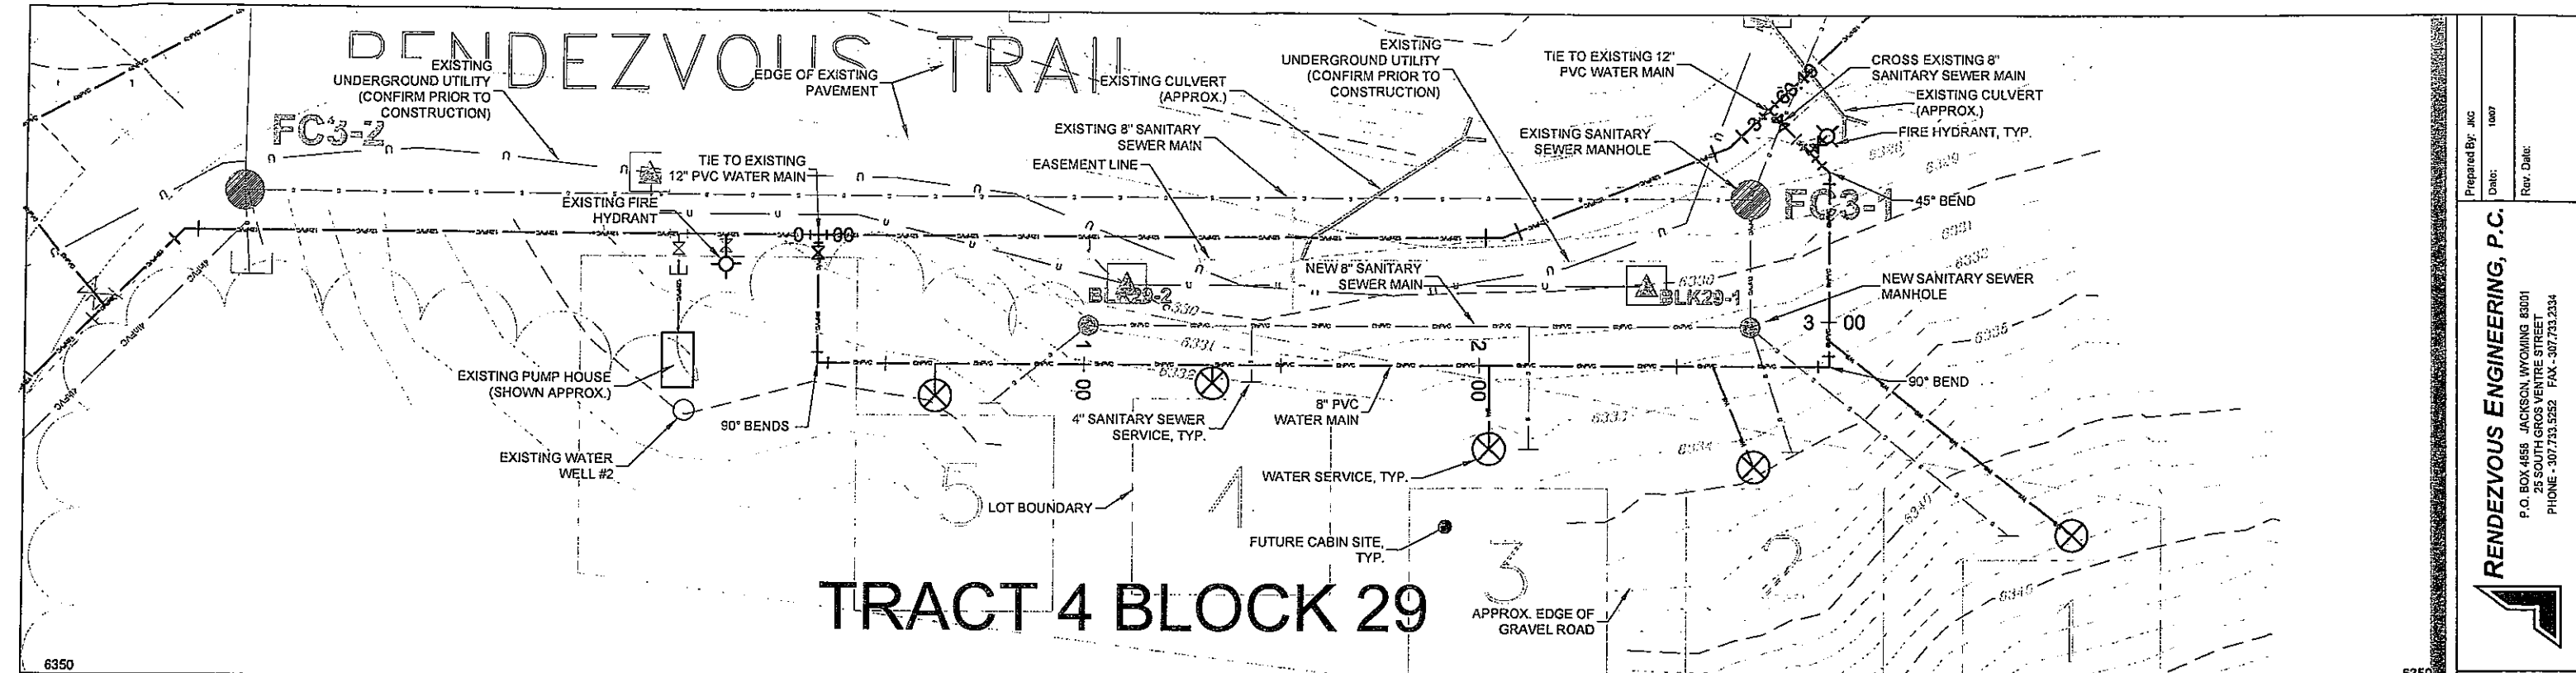

NOTES - THIS SHEET	GENERAL NOTES	 SCALE: 1" = 20' HORIZ. 1" = 5' VERT.	PROJECT TITLE: RECORD DRAWINGS TETON SPRINGS	PROJECT NUMBER: 04-002 1.5
			DRAWING TITLE: ASBUILT WATERMAIN WATER MAIN 'R2' FOREST CABINS TRACT 4 BLOCK 29	PREPARED BY: JAC DATE: 10/07 REV. DATE: P.O. BOX 4655 JACKSON, WYOMING 83001 25 SOUTH GROS VENTRE STREET PHONE: 307.733.5252 FAX: 307.733.2334

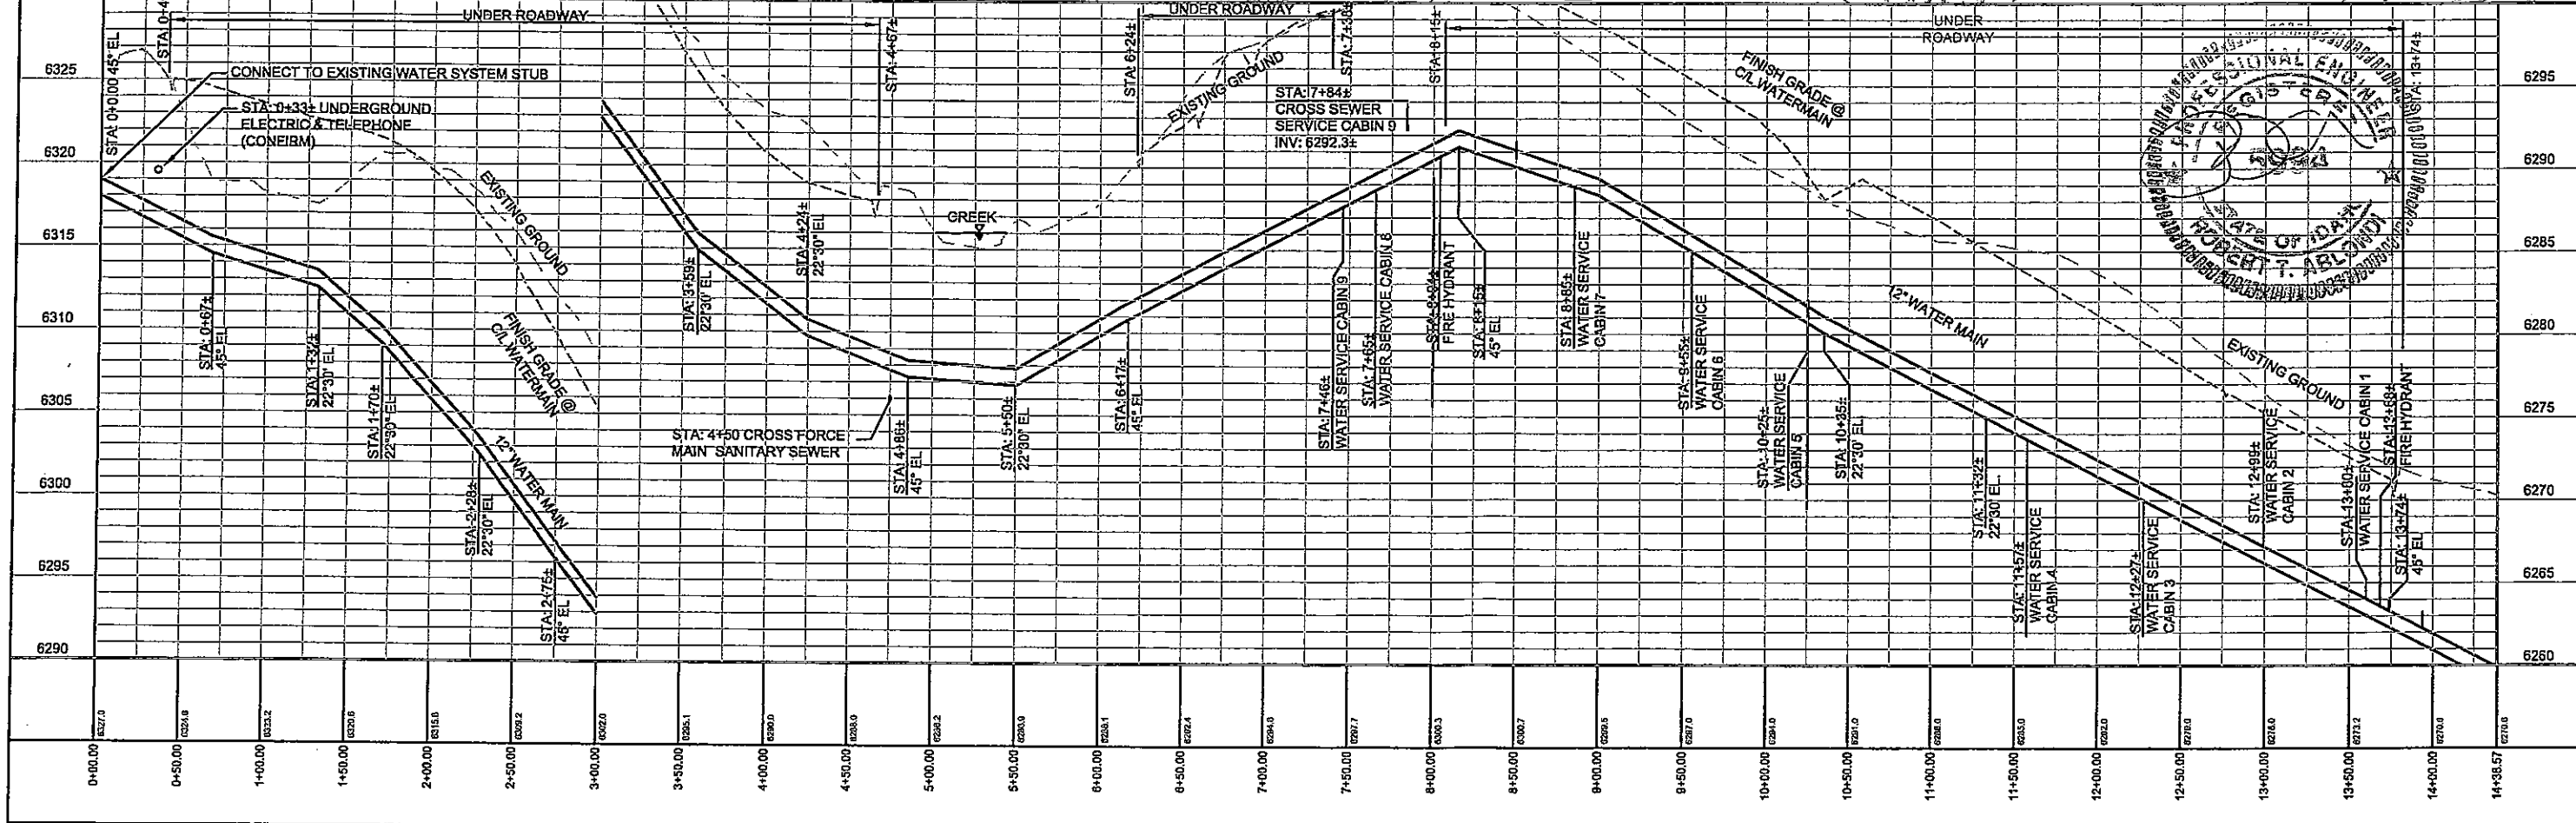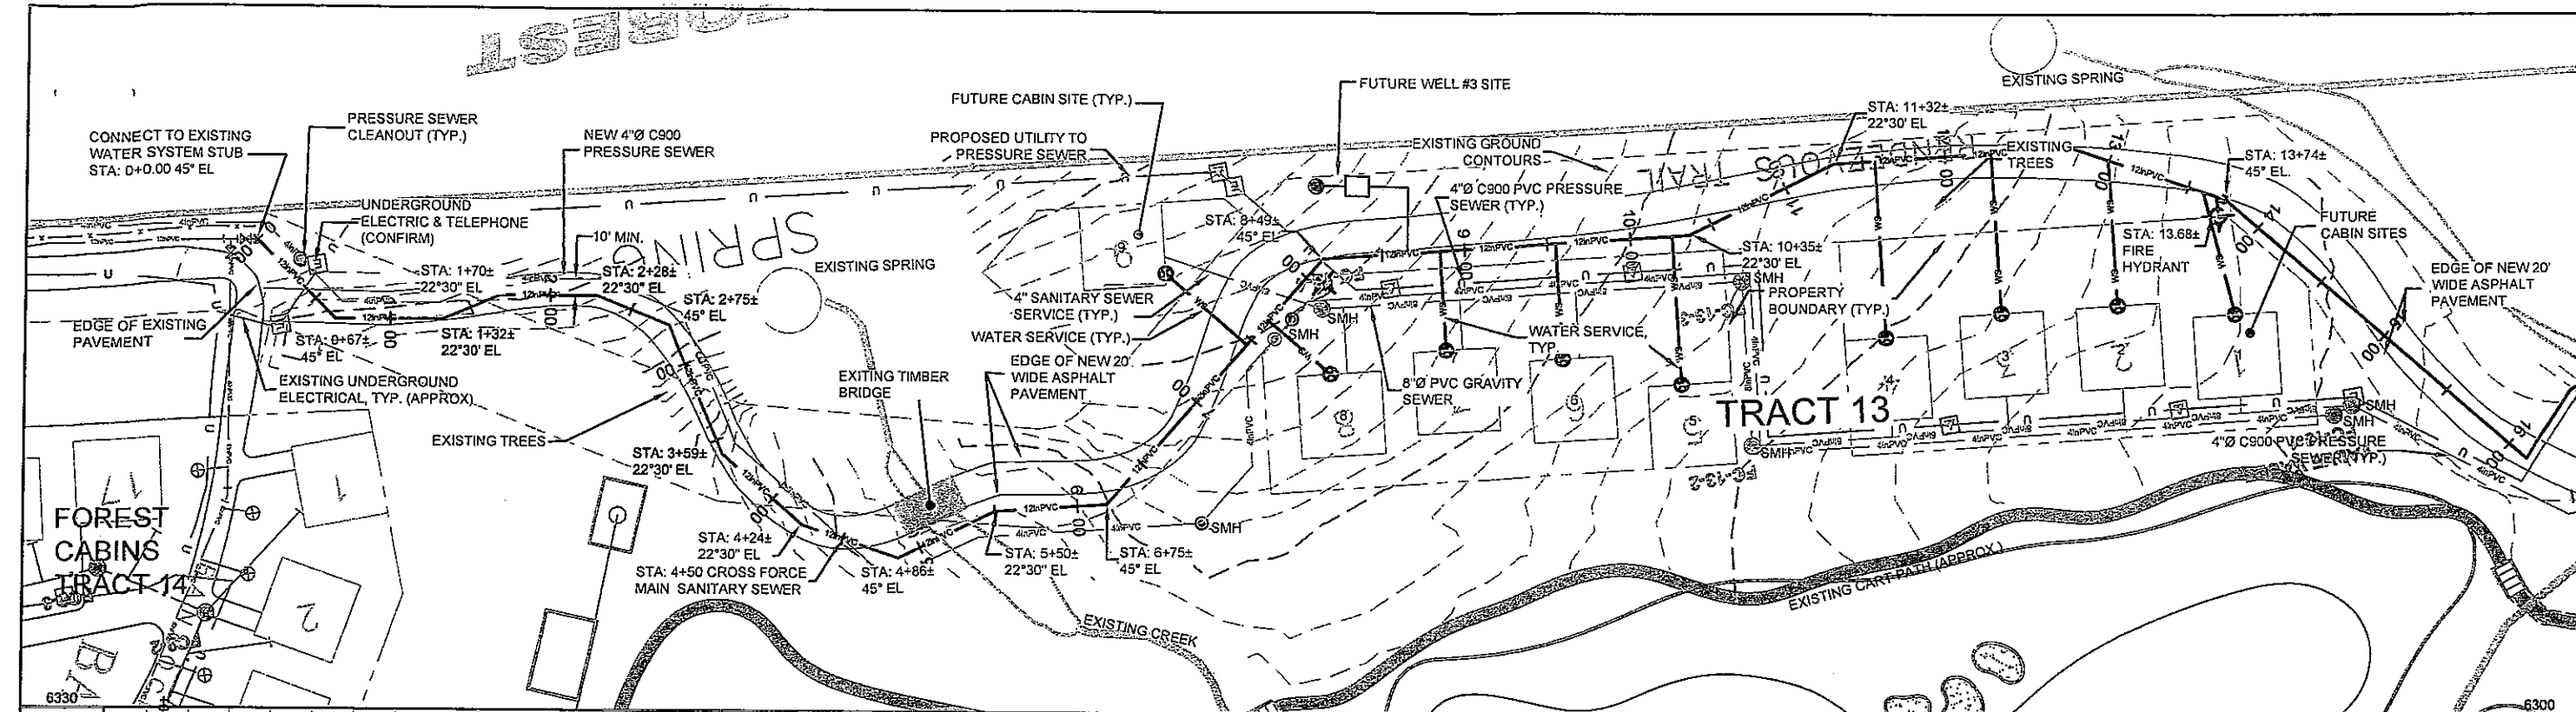

NOTES - THIS SHEET

GENERAL NOTES



SCALE: 1" = 50' HORZ.
1" = 5' VERT.

PROJECT TITLE:
**RECORD DRAWINGS
TETON SPRINGS**



PROJECT NUMBER:
**04-002
1.07**

DRAWING NUMBER:
ASBW-39

DRAWING TITLE:
**ASBUILT WATERMAIN
WATER MAIN 'S'
FOREST CABINS TRACTS 12 & 13**

PREPARED BY: JKC
DATE: 10/17
REV. DATE:
REV. INFO:
PLOT INFO:
DATE: 10/17/2017
PLOT: 10/17/2017

RENDEZVOUS ENGINEERING, P.C.
P.O. BOX 4658 JACKSON, WYOMING 83001
25 SOUTH GROS VENTRE STREET
PHONE - 307.733.5252 FAX - 307.733.2334

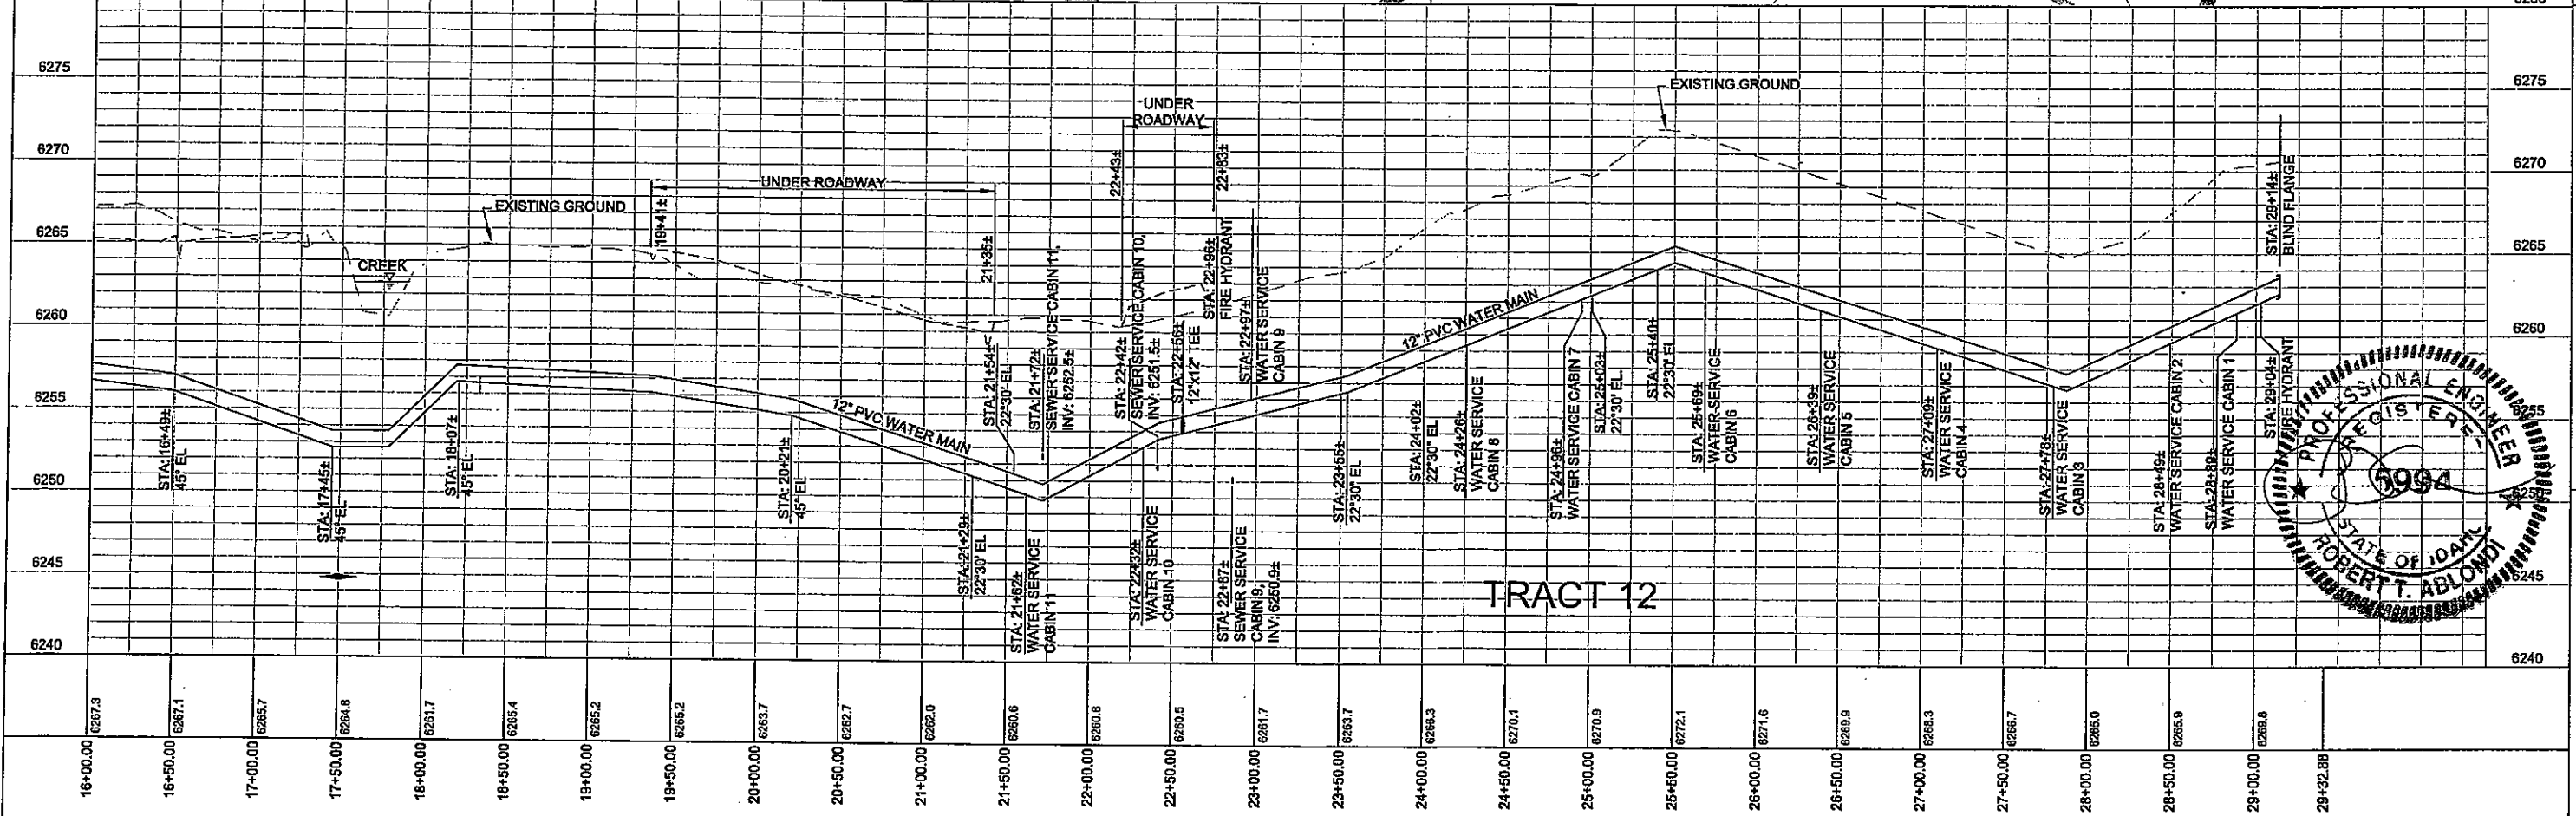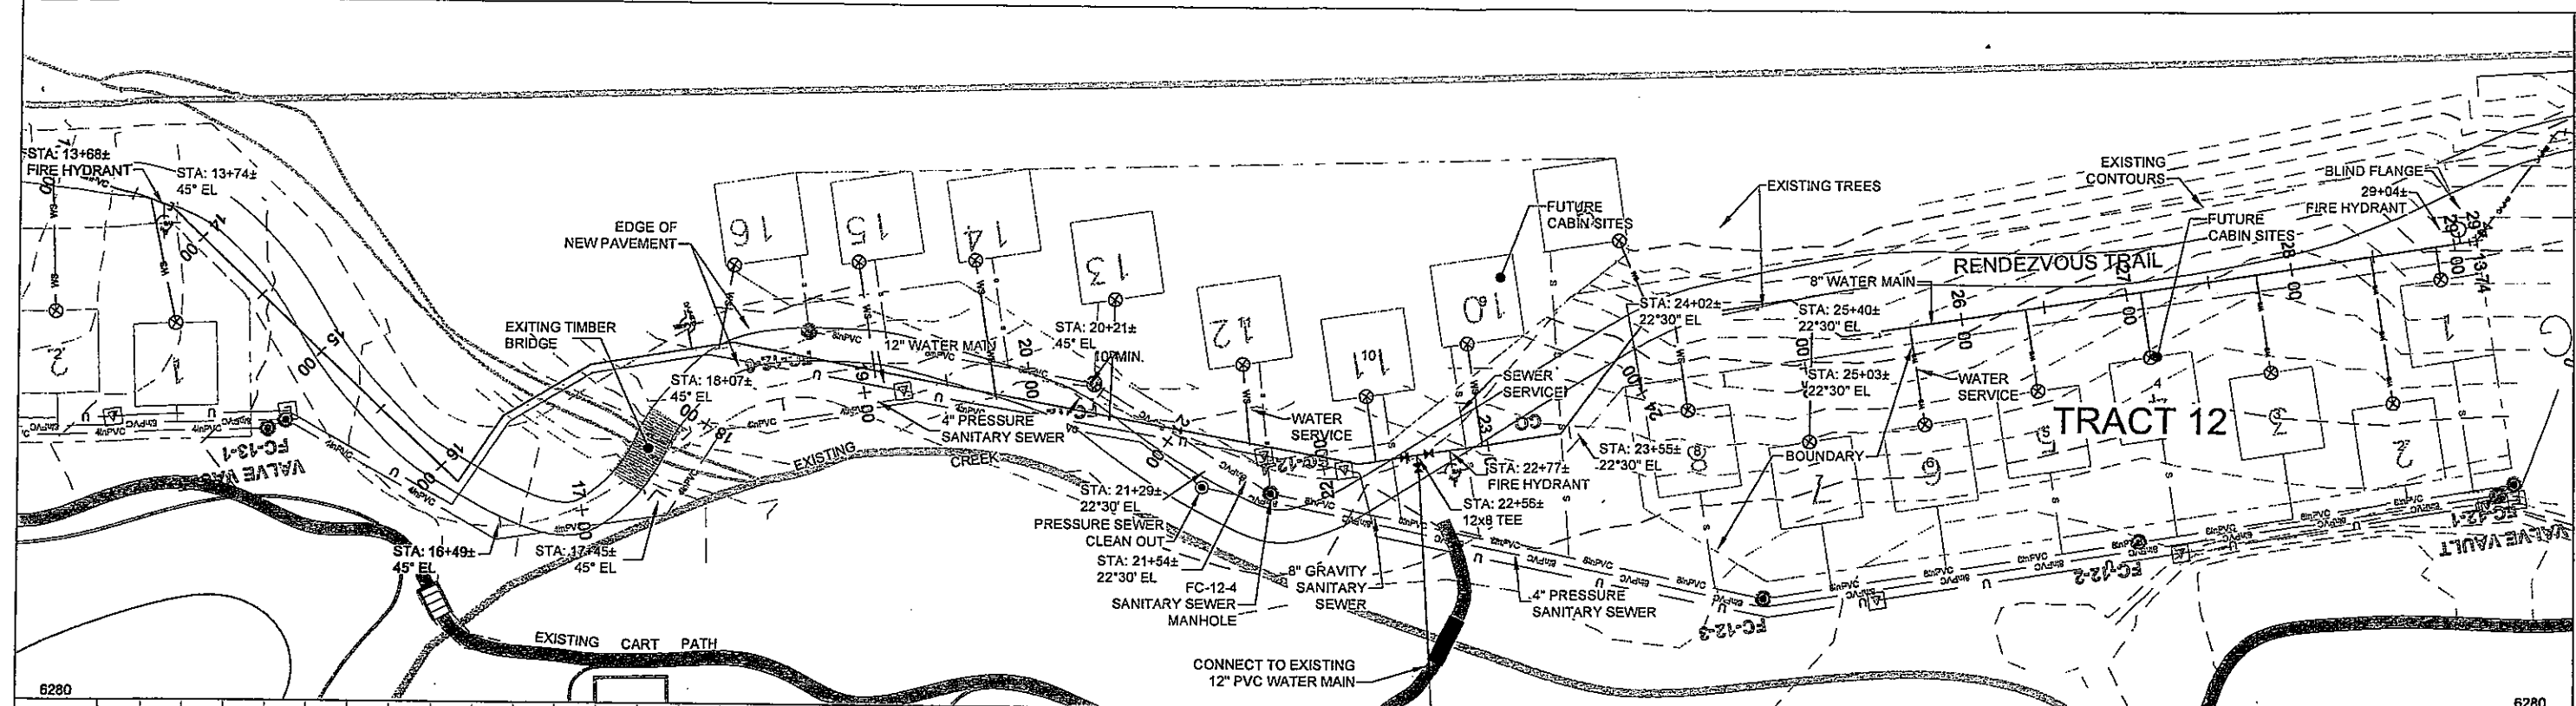

NOTES - THIS SHEET

GENERAL NOTES

SCALE: 1" = 50' HOR.
1" = 5' VERT.

PROJECT TITLE: **RECORD DRAWINGS TETON SPRINGS**

PROJECT NUMBER: **04-002 1.07**

DRAWING NUMBER: **ASBW-41**

DRAWING TITLE: **ASBUILT WATERMAIN WATER MAIN 'S' FOREST CABINS TRACTS 12 & 13**

DRAWING TITLE: **ASBUILT WATERMAIN WATER MAIN 'S' FOREST CABINS TRACTS 12 & 13**

PREPARED BY: JAC

DATE: 10/07

REV. DATE:

FILE INFO:

DATA: ASBUILT WATERMAIN, TETON SPRINGS, IDAHO

PATH: ASBUILT WATERMAIN, TETON SPRINGS, IDAHO

RENDERZVOUS ENGINEERING, P.C.

P.O. BOX 4858 JACKSON, WYOMING 83001

25 SOUTH GROS VENTRE STREET



PHONE - 307.733.5252 FAX - 307.733.2314

PROFESSIONAL ENGINEER

STATE OF IDAHO

ROBERT T. ABLOWDI


6094

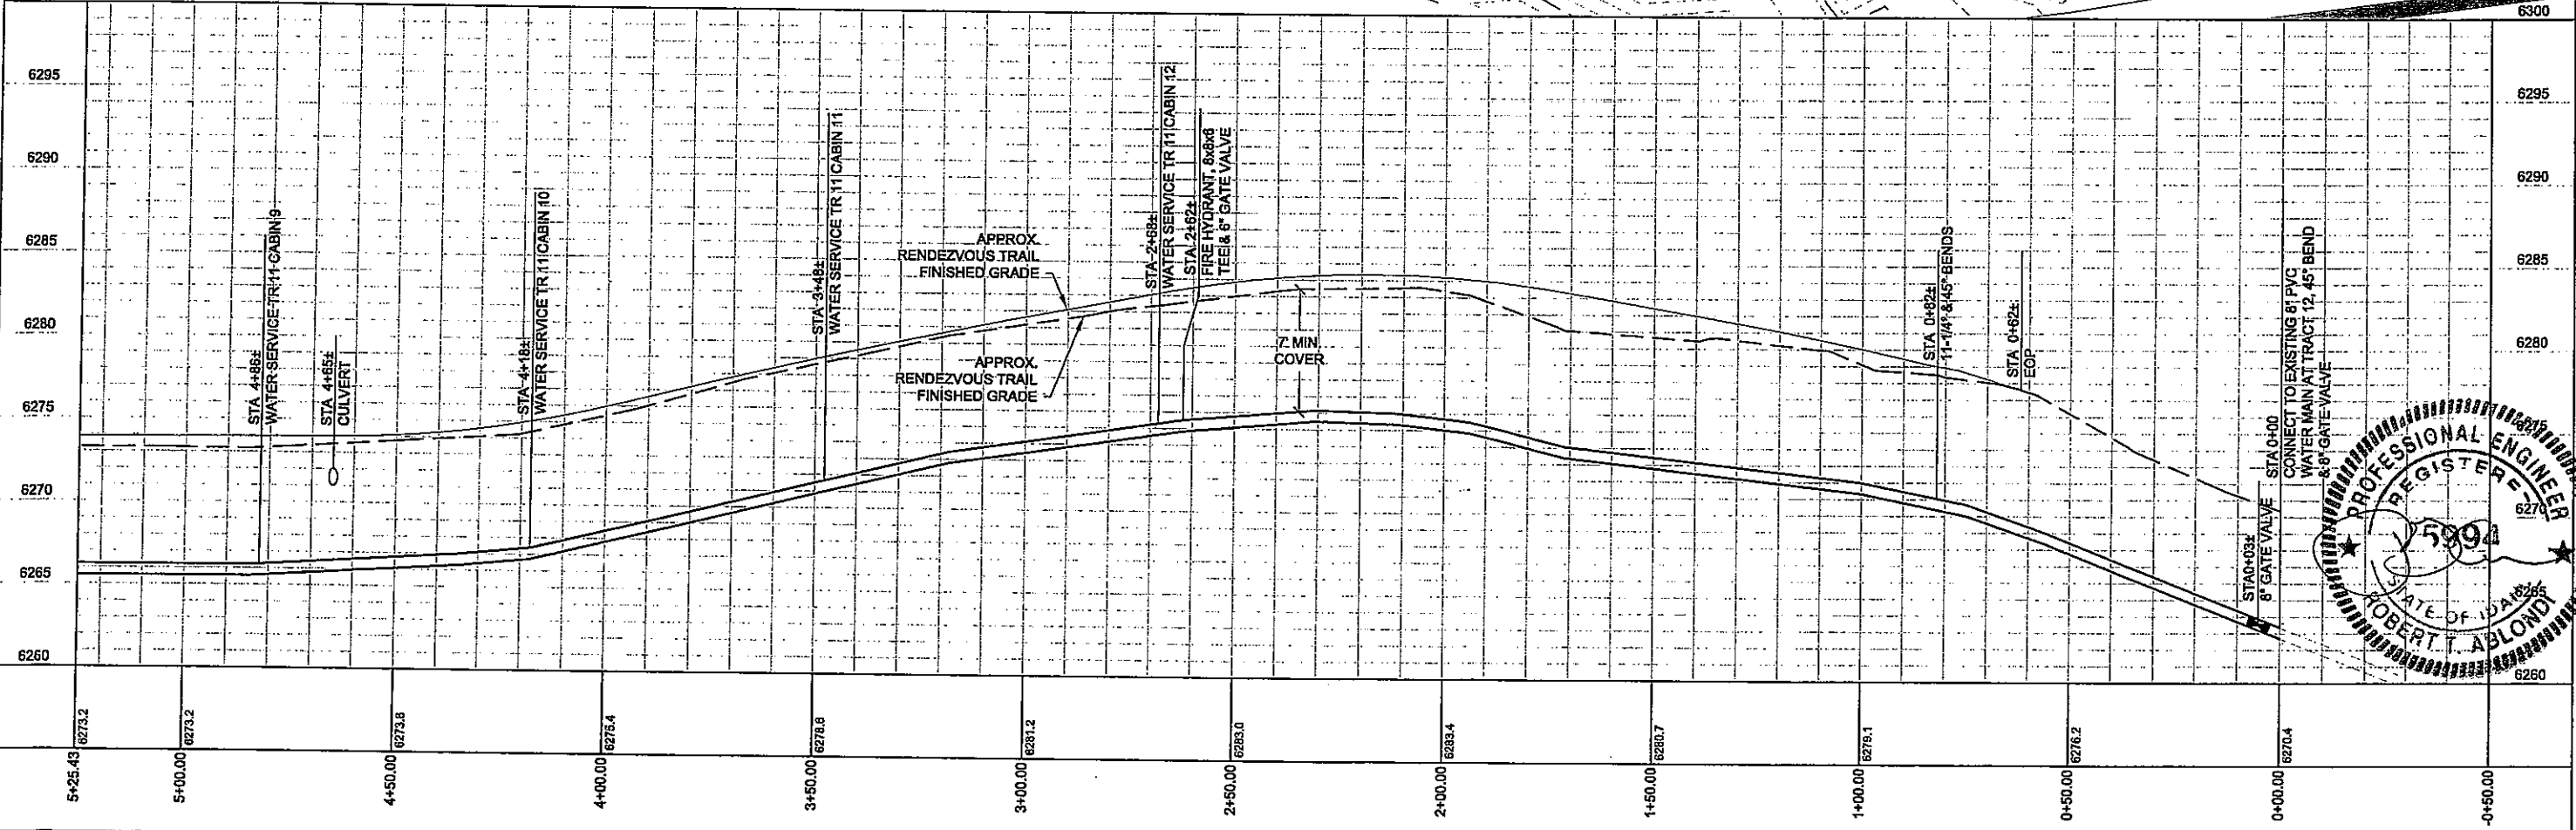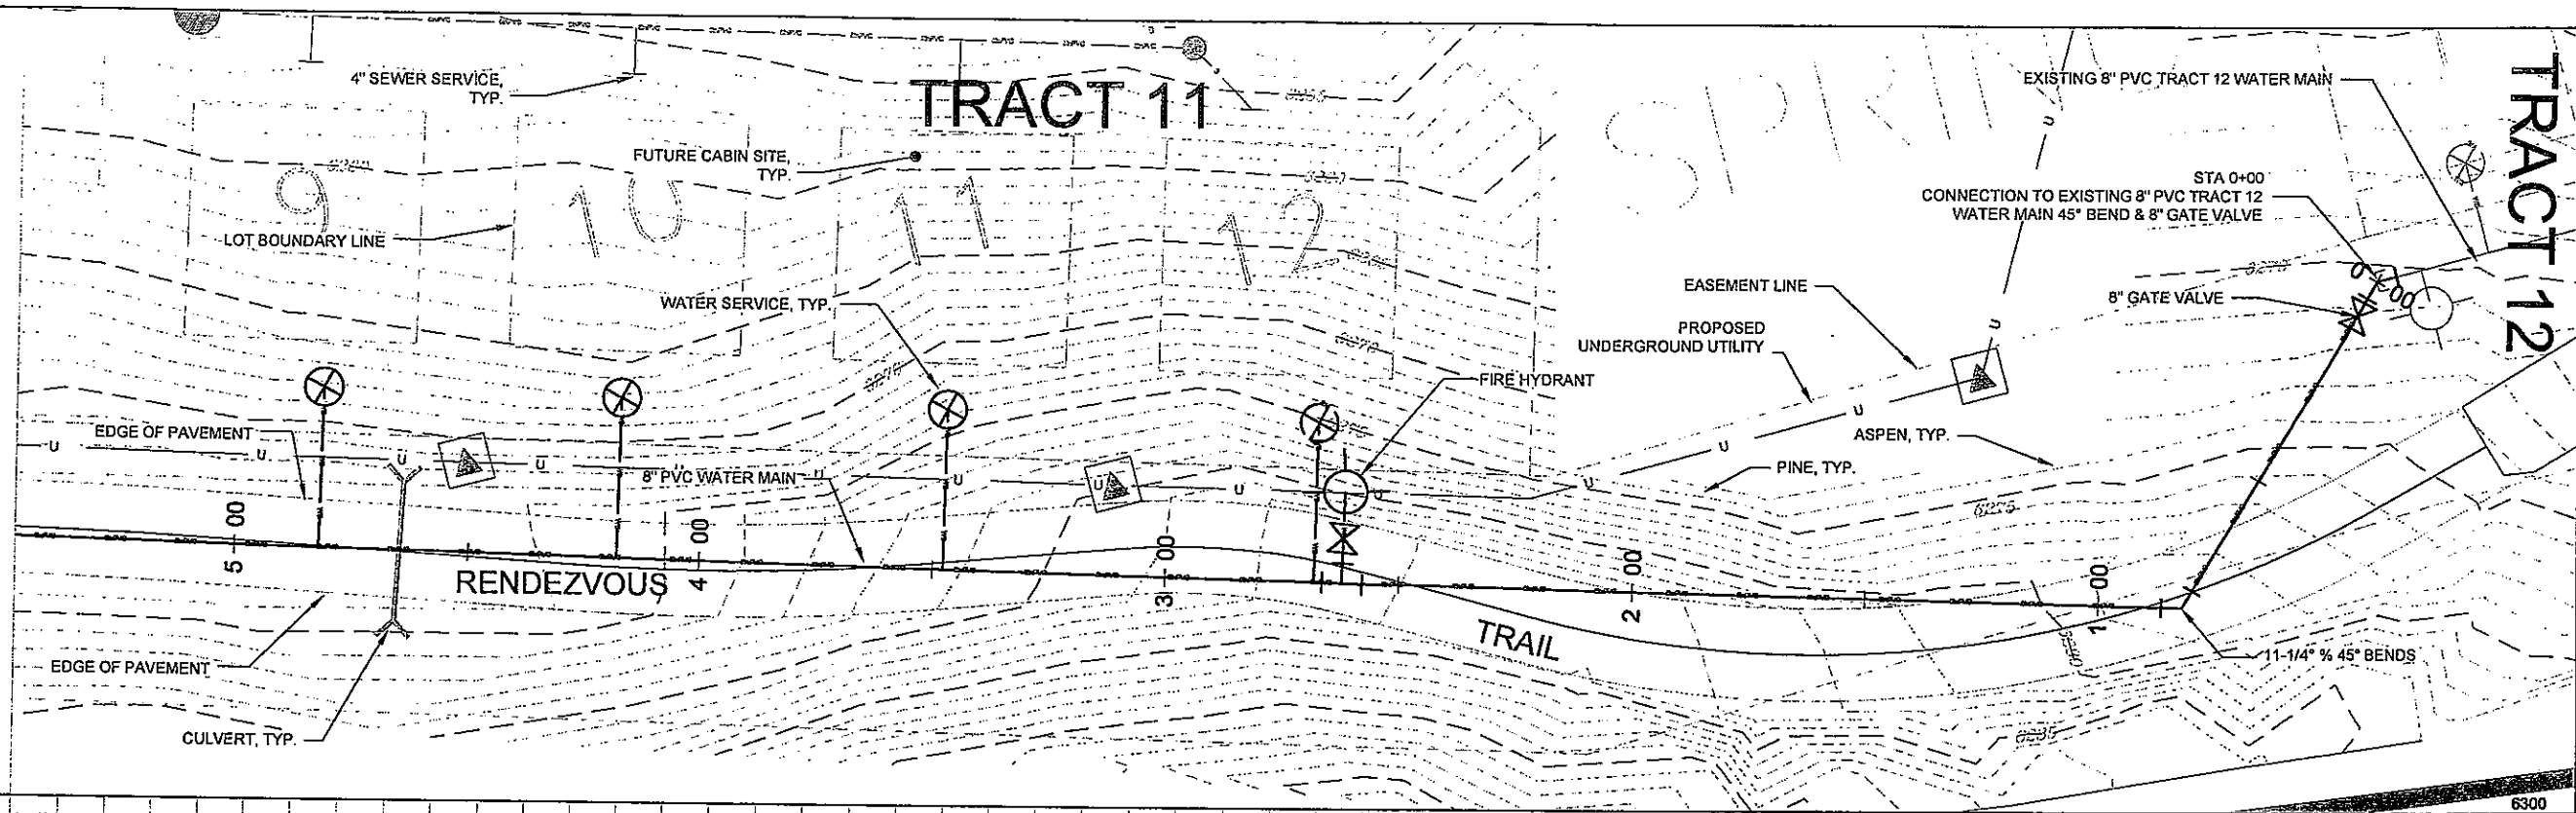



NOTES - THIS SHEET

GENERAL NOTES

SCALE: 1" = 20' HORZ.
1" = 5' VERT.

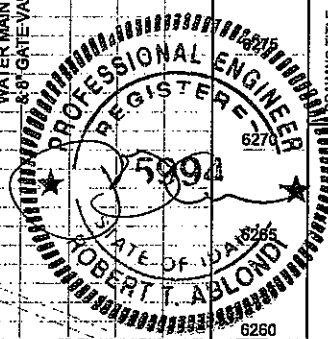

RENDZVOUS ENGINEERING, P.C. P.O. BOX 4858 JACKSON, WYOMING 83001 25 SOUTH GROS VENTRE STREET PHONE 307.733.5252 FAX 307.733.2334	
PROJECT TITLE: RECORD DRAWINGS TETON SPRINGS	DRAWING TITLE: ASBUILT WATERMAIN WATER MAIN 'T' FOREST CABINS TRACTS 10 & 11
PROJECT NUMBER: 04-002 1.08	DRAWING NUMBER: ASBW-42

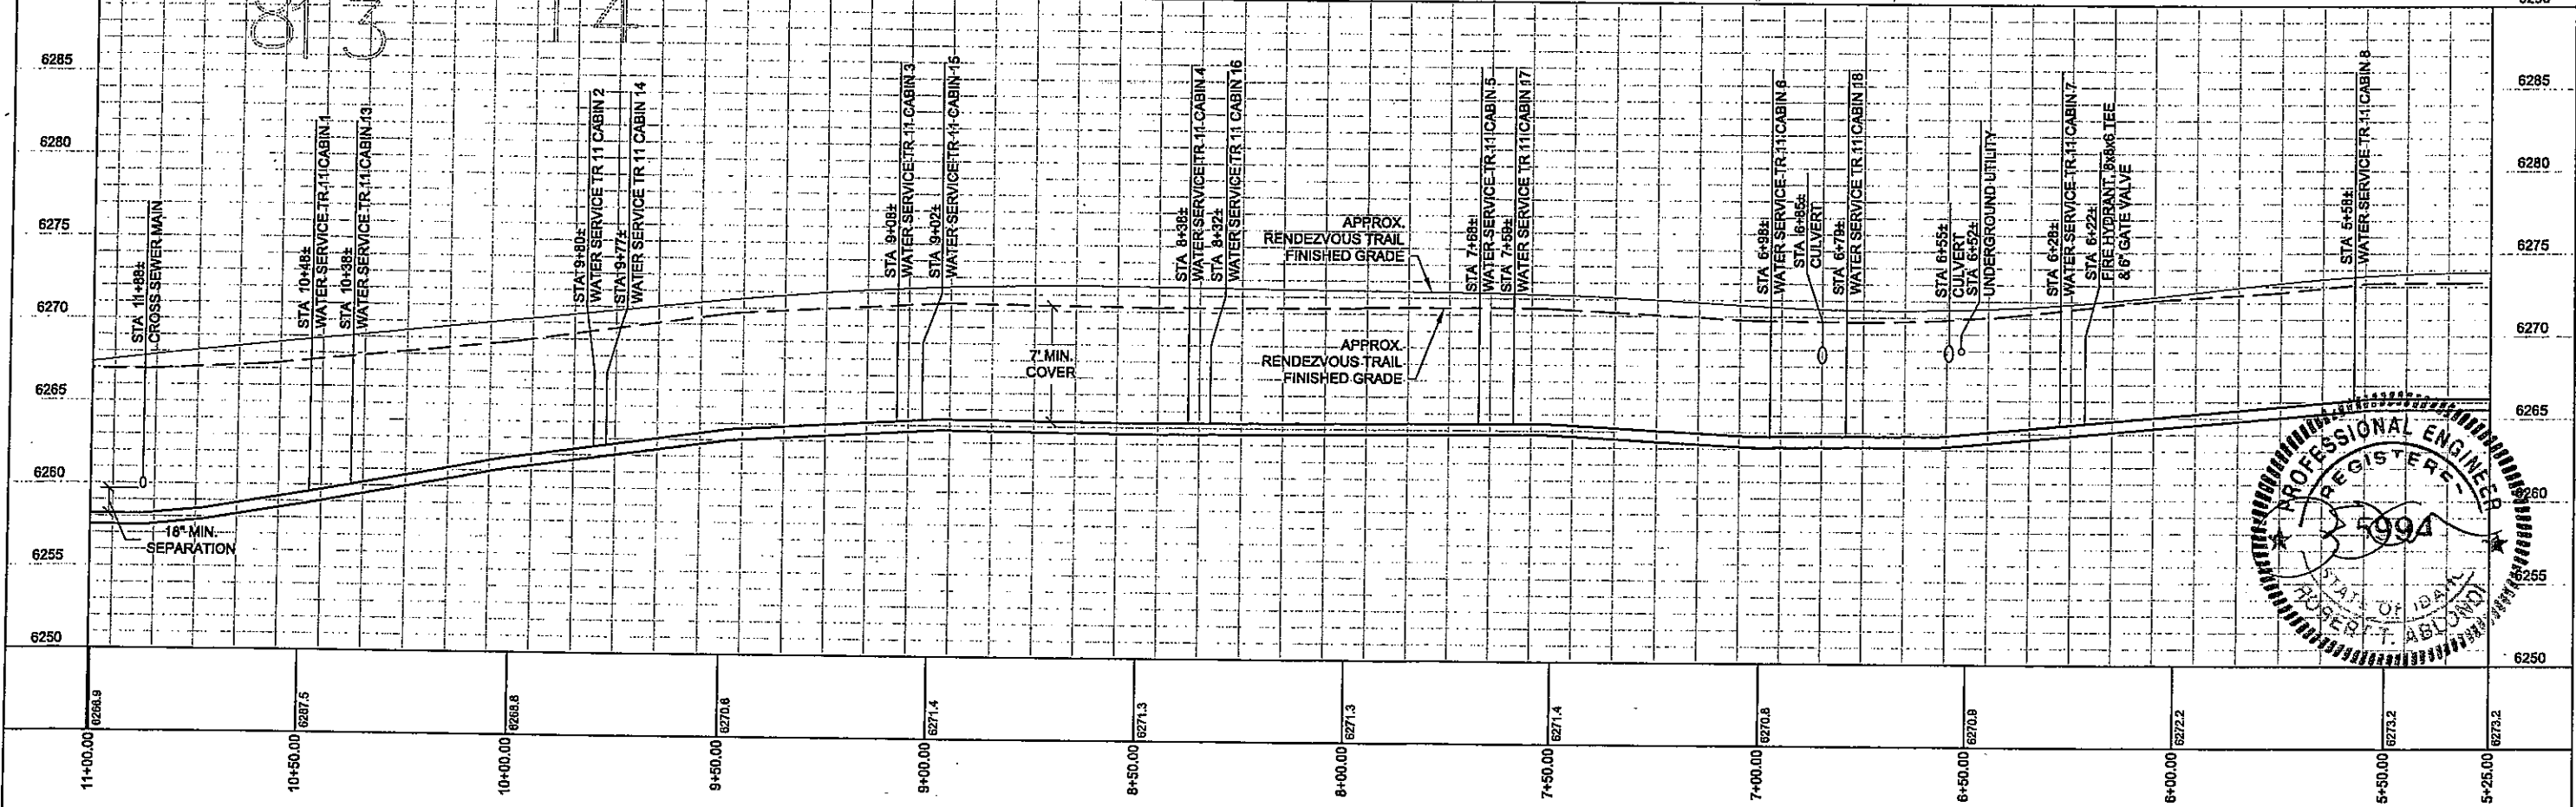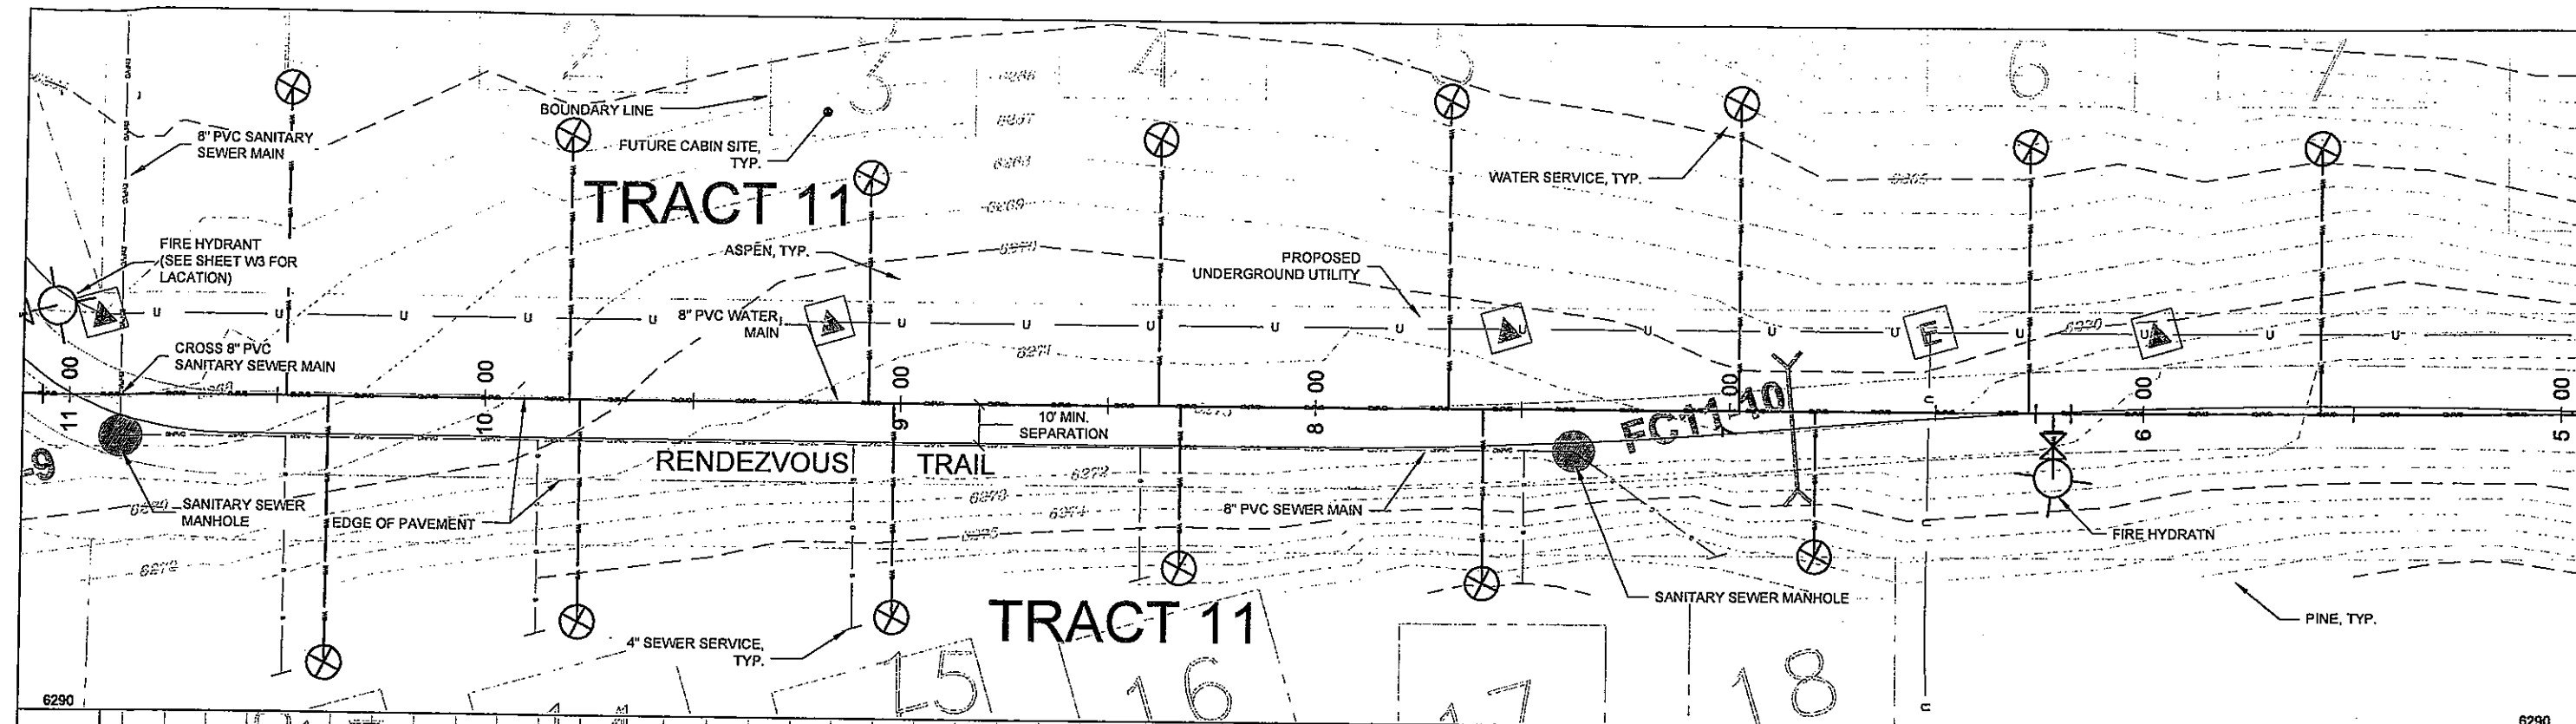


NOTES - THIS SHEET

GENERAL NOTES




SCALE: 1" = 20' HORZ.
1" = 5' VERT.

RENDEZVOUS ENGINEERING, P.C. P.O. BOX 4858 JACKSON WYOMING 83001 25 SOUTH GROES VENTRE STREET PHONE - 307.733.6252 FAX - 307.733.2334	
Prepared By: JKC	Date: 1007
Rev. Date:	
PROJECT TITLE: RECORD DRAWINGS TETON SPRINGS	
DRAWING TITLE: ASBUILT WATERMAIN WATER MAIN "T" FOREST CABINS TRACTS 10 & 11	
PROJECT NUMBER: 04-002 1.08	DRAWING NUMBER: ASBW-43

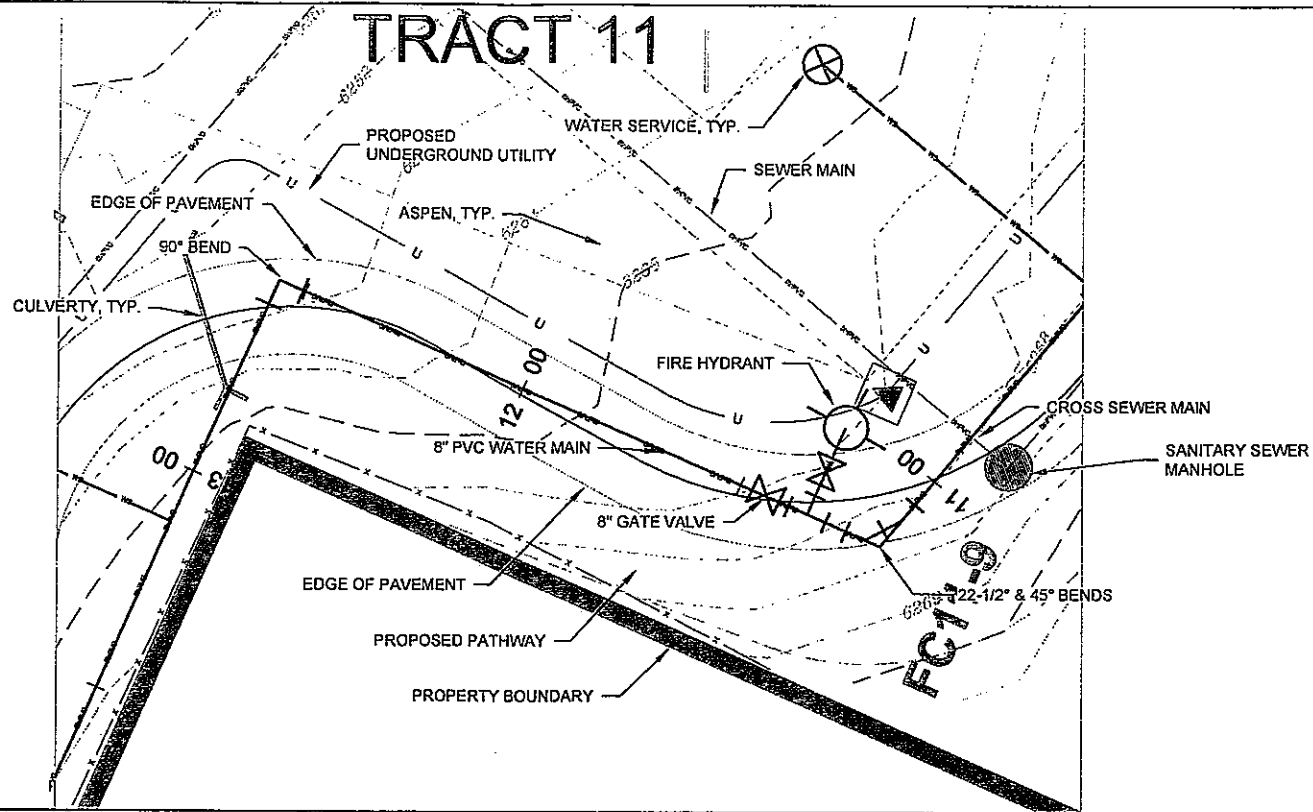

6290

6290

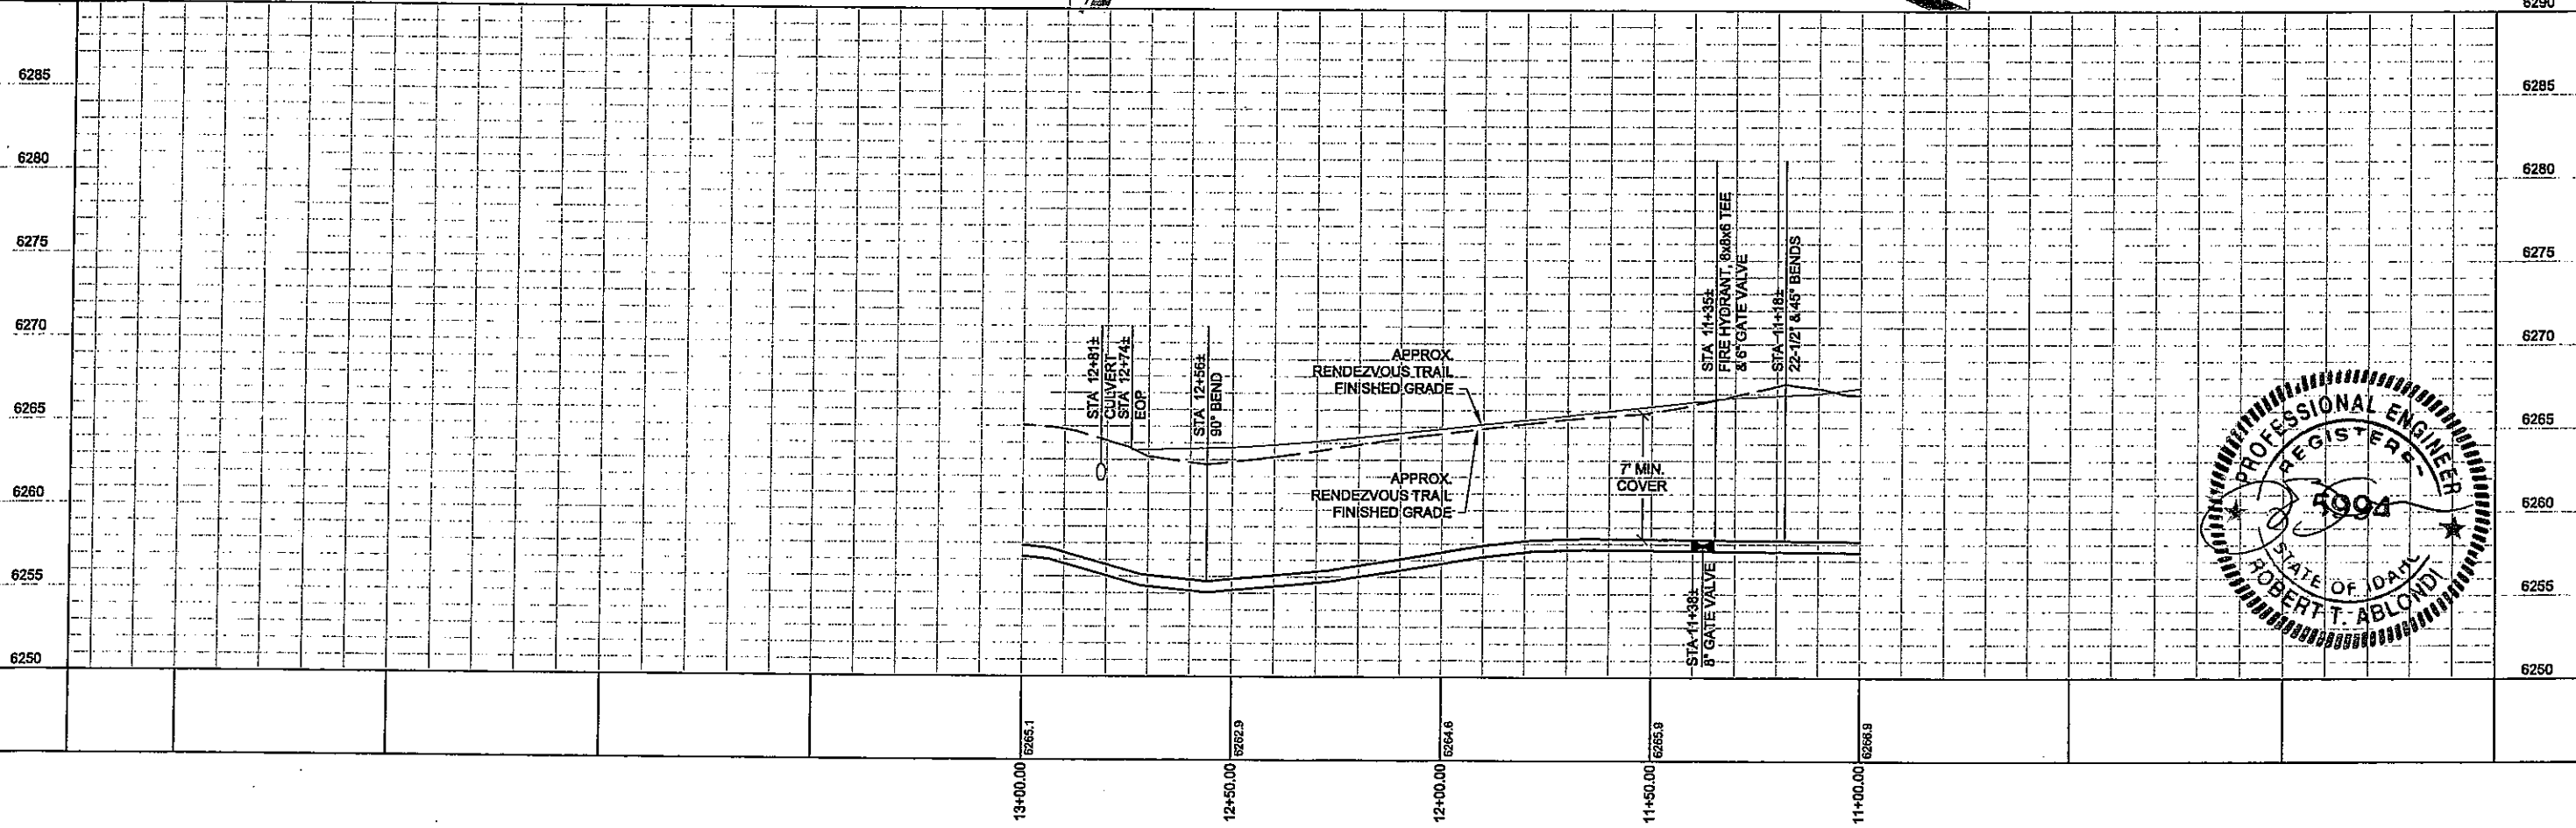

6250

6250

NOTES - THIS SHEET

GENERAL NOTES



SCALE: 1" = 20' HORZ.
1" = 5' VERT.

Prepared By: JKC

Date: 10/07

Rev. Date:

RENDEZVOUS ENGINEERING, P.C.


P.O. BOX 4858 JACKSON, WYOMING 83001
25 SOUTH GROS VENTRE STREET
PHONE - 307.733.2252 FAX - 307.733.2334



DRAWING TITLE:
**ASBUILT WATERMAIN
WATER MAIN 'T'
FOREST CABINS TRACTS 10 & 11**

PROJECT TITLE:
**RECORD DRAWINGS
TETON SPRINGS**

PROJECT
NUMBER:
04-002
1.08

DRAWING
NUMBER:
ASBW-44

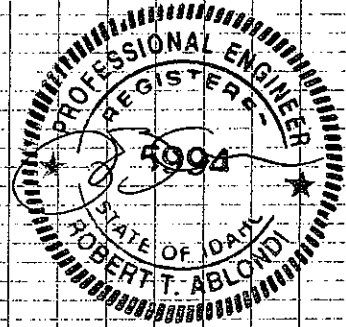

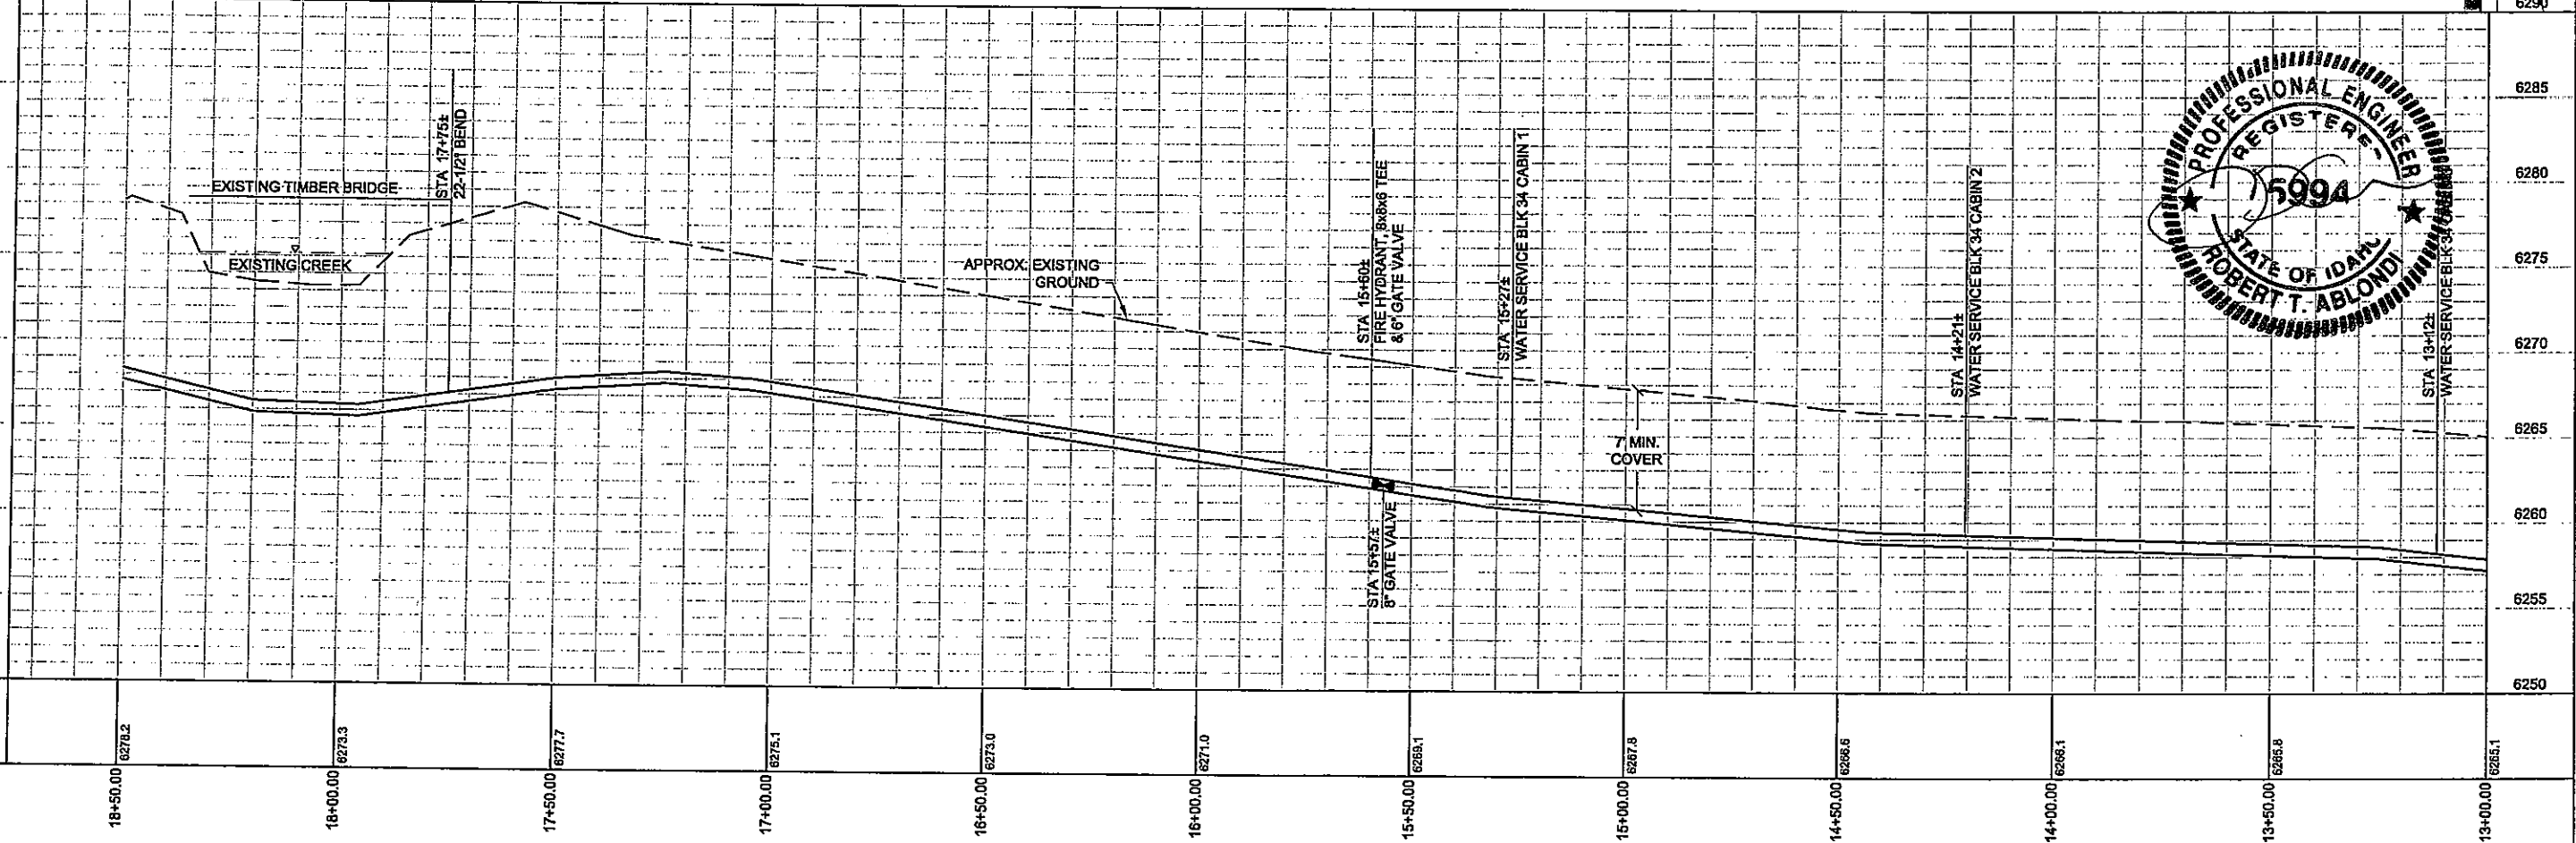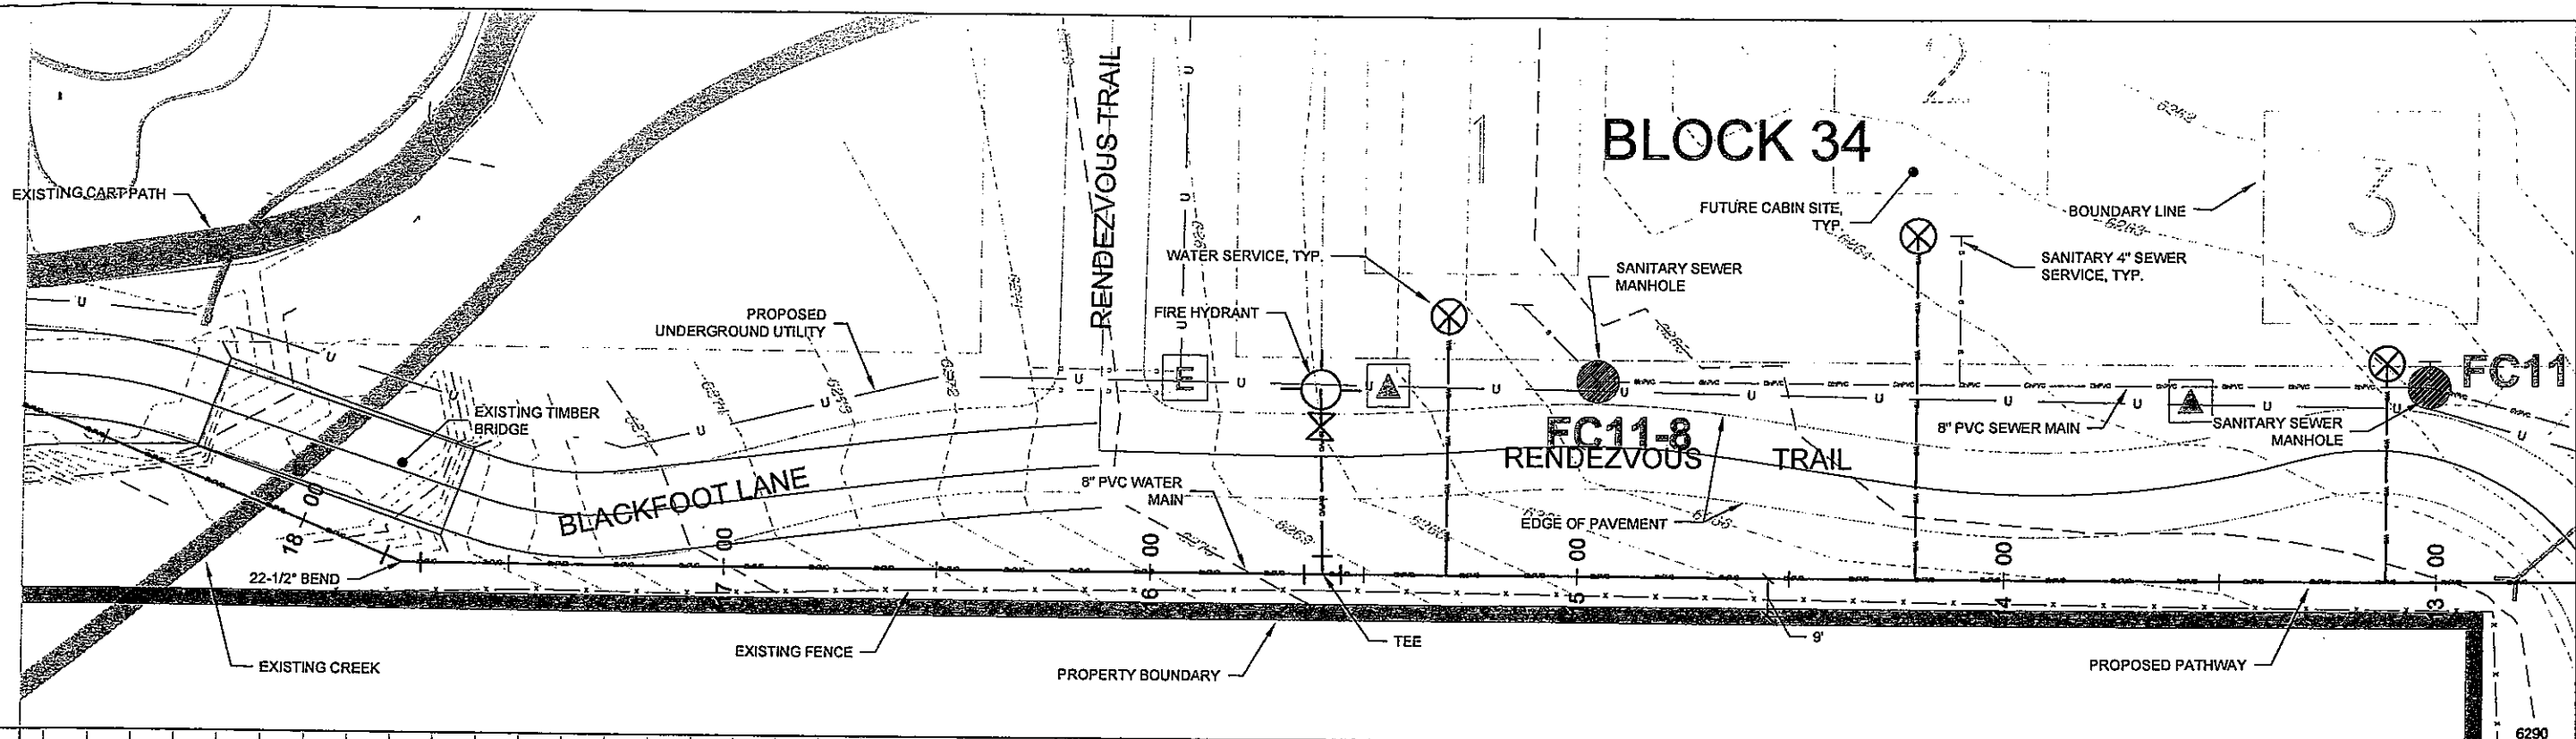




NOTES - THIS SHEET

GENERAL NOTES



SCALE: 1" = 20' HORIZ.
1" = 5' VERT.

RENDZVOUS ENGINEERING, P.C. P.O. BOX 455 JACKSON, WYOMING 83001 25 SOUTH GROSVENOR STREET PHONE - 307.733.5252 FAX - 307.733.2334		Prepared By: JCC Date: 10/07 Rev. Date:
DRAWING TITLE: ASBUILT WATERMAIN WATER MAIN 'T' FOREST CABINS TRACTS 10 & 11		PROJECT TITLE: RECORD DRAWINGS TETON SPRINGS
PROJECT NUMBER: 04-002 1.08		
DRAWING NUMBER: ASBW-45		

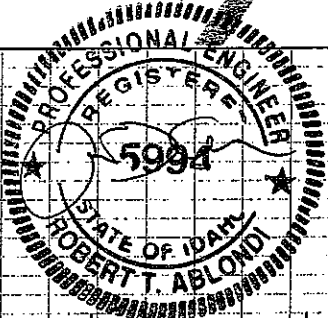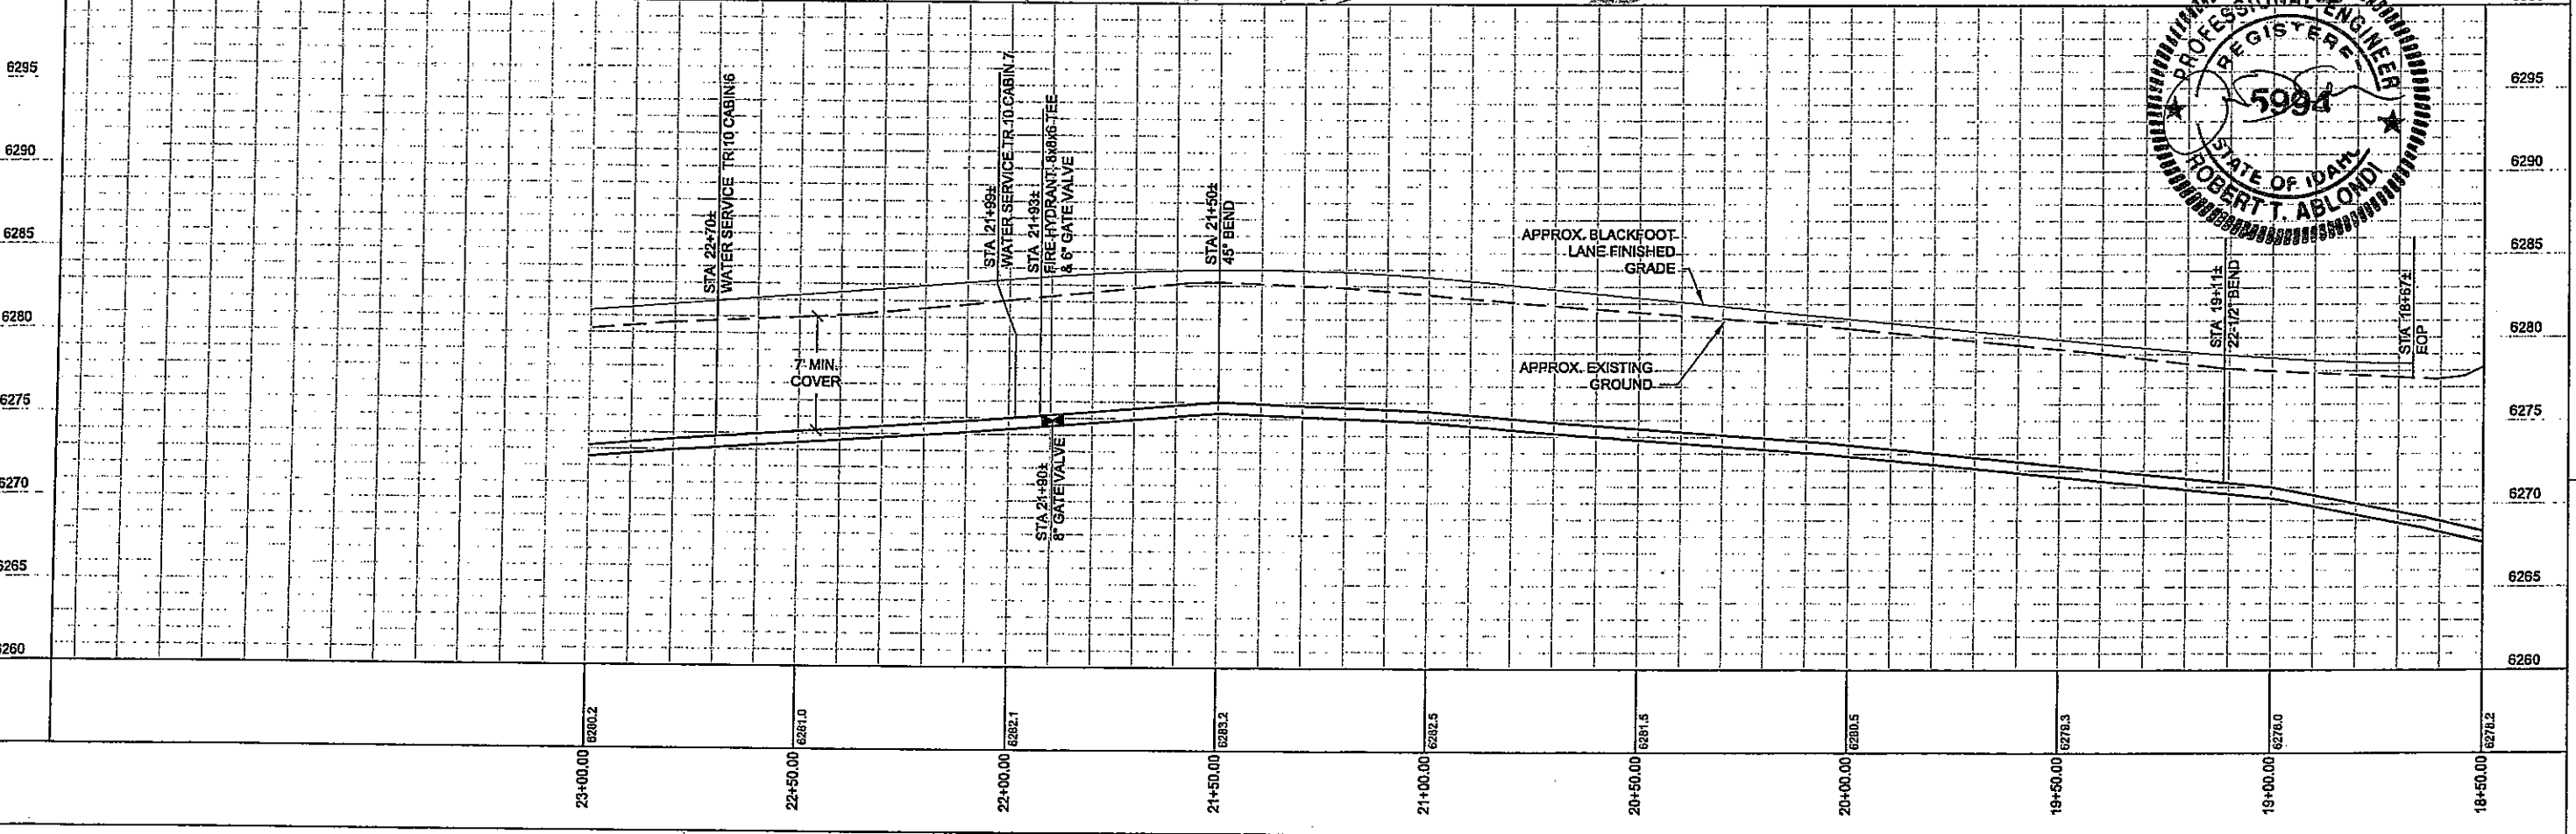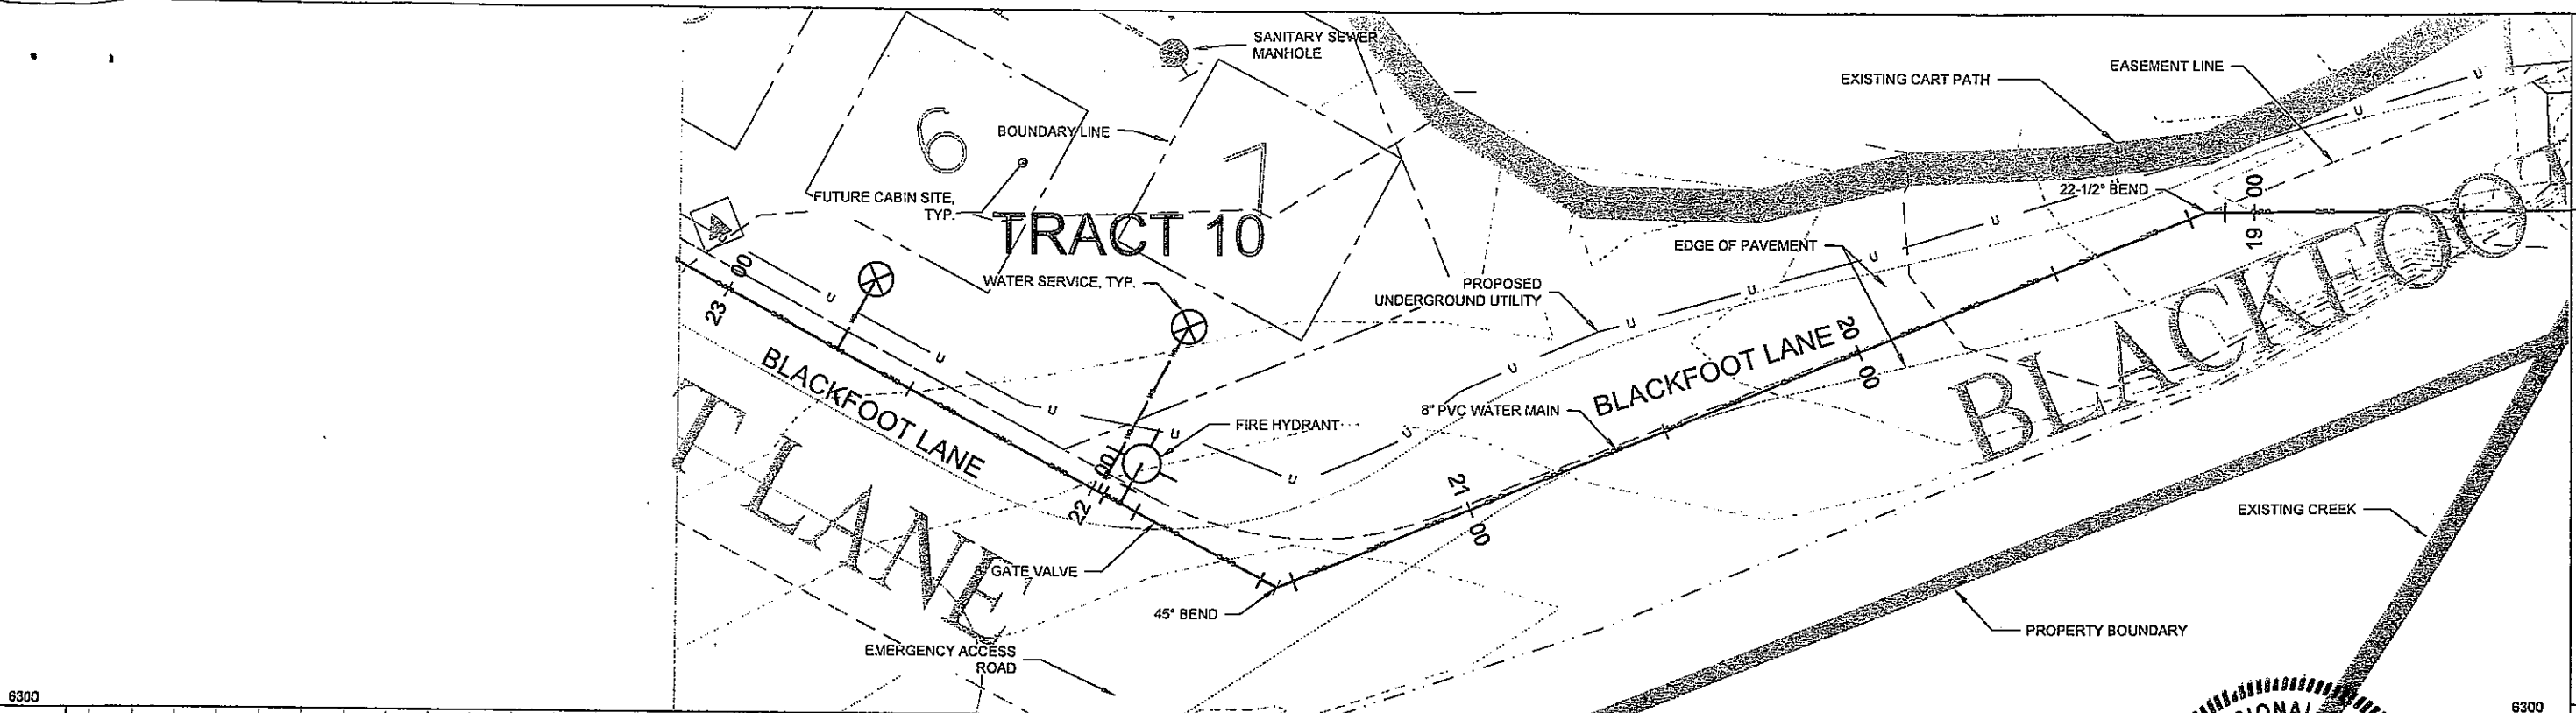



NOTES - THIS SHEET

GENERAL NOTES



SCALE: 1" = 20' HORZ.
1" = 5' VERT.

Prepared By: JKC Date: 10/07	
Rev. Date:	
RENDEZVOUS ENGINEERING, P.C. P.O. BOX 4658 JACKSON WYOMING 83001 35 SOUTH CROSS VENTURE STREET PHONE - 307.733.9332 FAX - 307.733.2334	
DRAWING TITLE: ASBUILT WATERMAIN WATER MAIN "T" FOREST CABINS TRACTS 10 & 11	
PROJECT TITLE: RECORD DRAWINGS TETON SPRINGS	PROJECT NUMBER: 04-002 1.08
DRAWING NUMBER: ASBW-46	

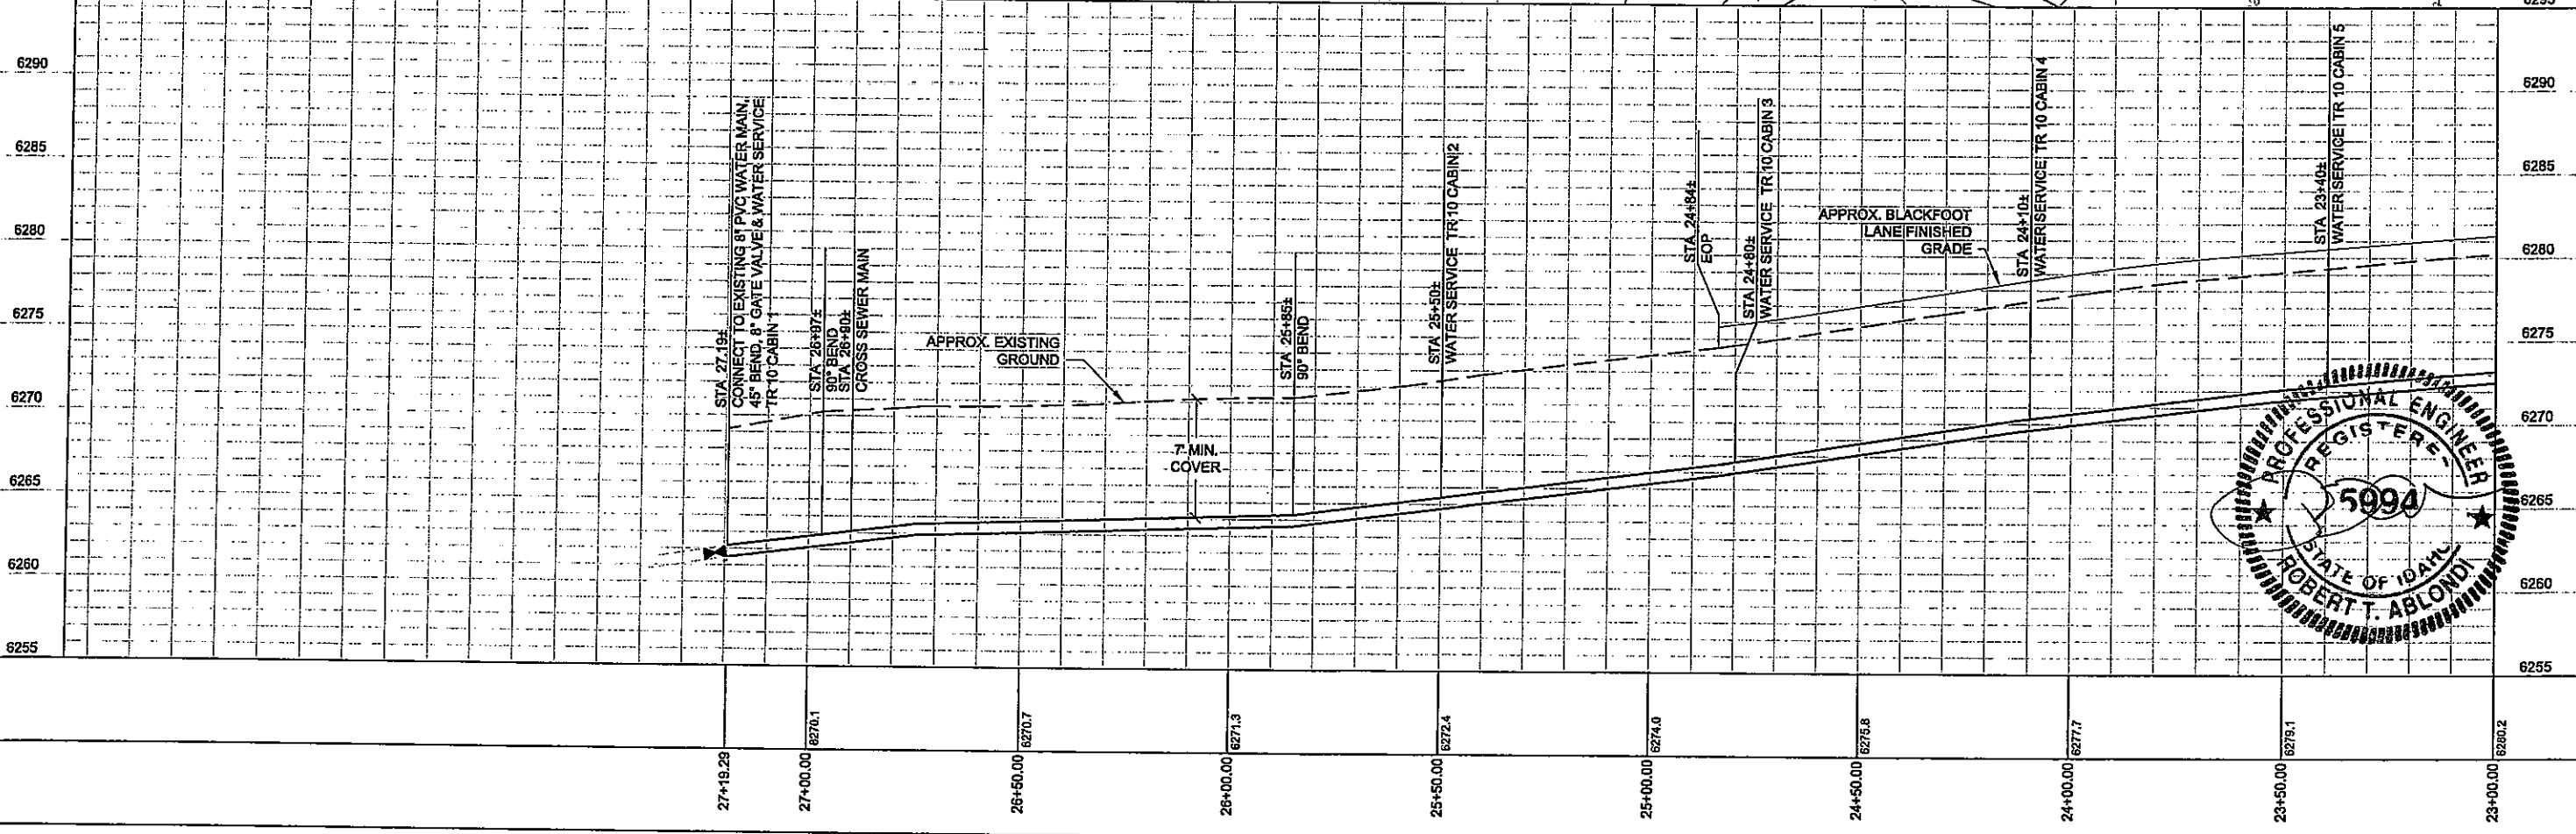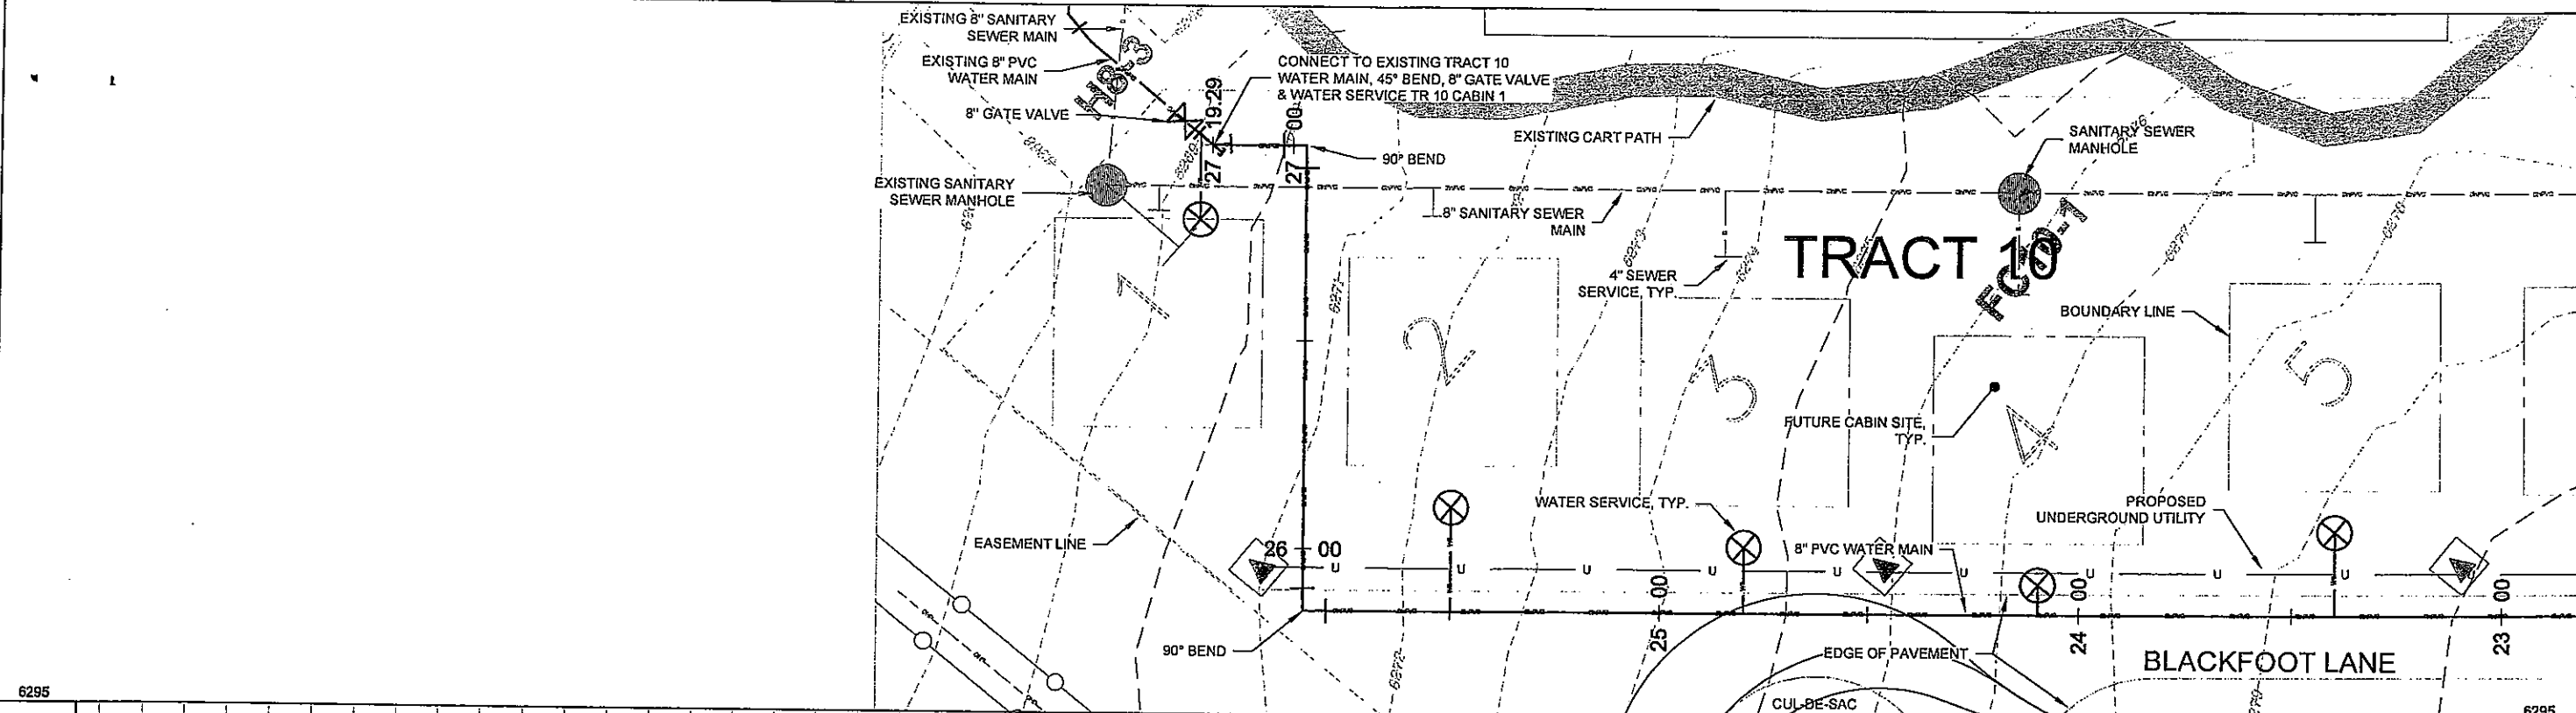

NOTES - THIS SHEET

GENERAL NOTES

SCALE: 1" = 20' HORZ.
1" = 5' VERT.

Prepared By: JNC
Date: 10/07
Rev. Date:



RENDEZVOUS ENGINEERING, P.C.
P.O. BOX 4188 JACKSON, WYOMING 83001
25 SOUTH GROS VENTRE STREET
PHONE - 307.733.5252 FAX - 307.733.2334

DRAWING TITLE:
**ASBUILT WATERMAIN
WATER MAIN "T"
FOREST CABINS TRACTS 10 & 11**

PROJECT TITLE:
**RECORD DRAWINGS
TETON SPRINGS**

PROJECT NUMBER:
04-002
1.08

DRAWING NUMBER:
ASBW-47

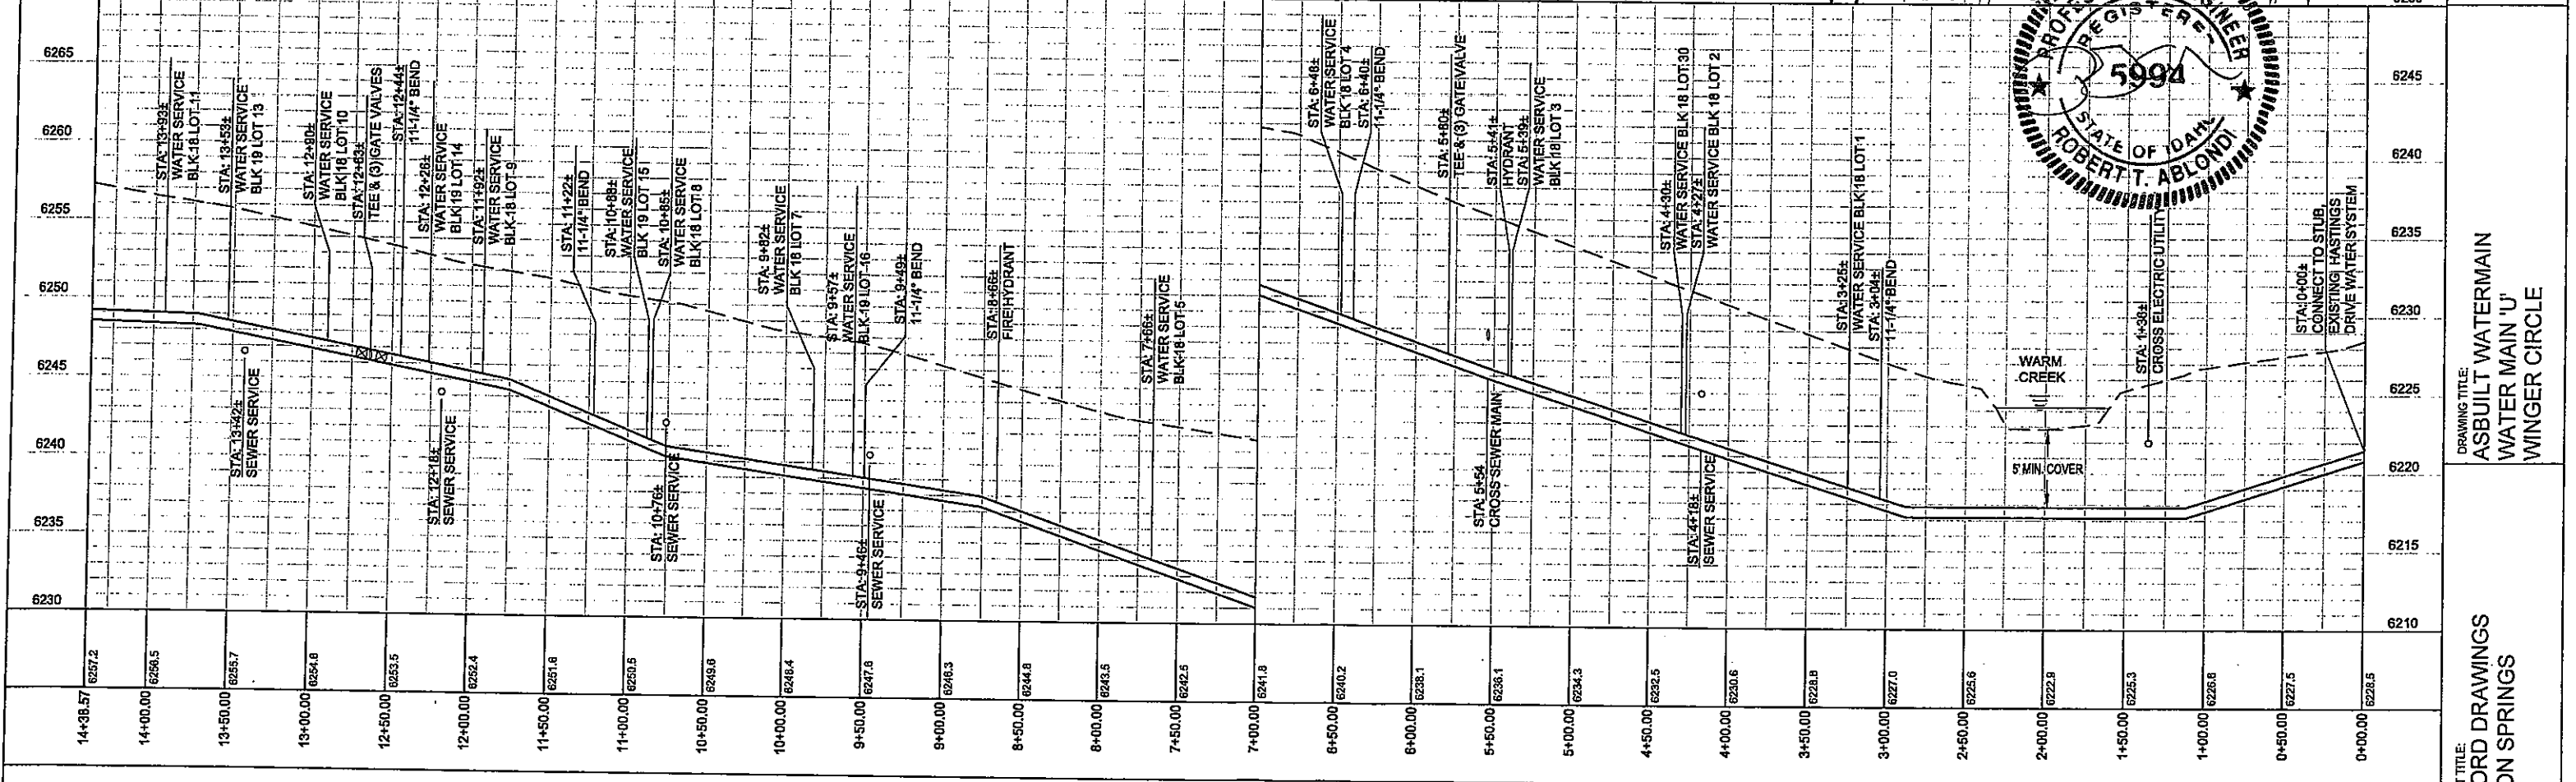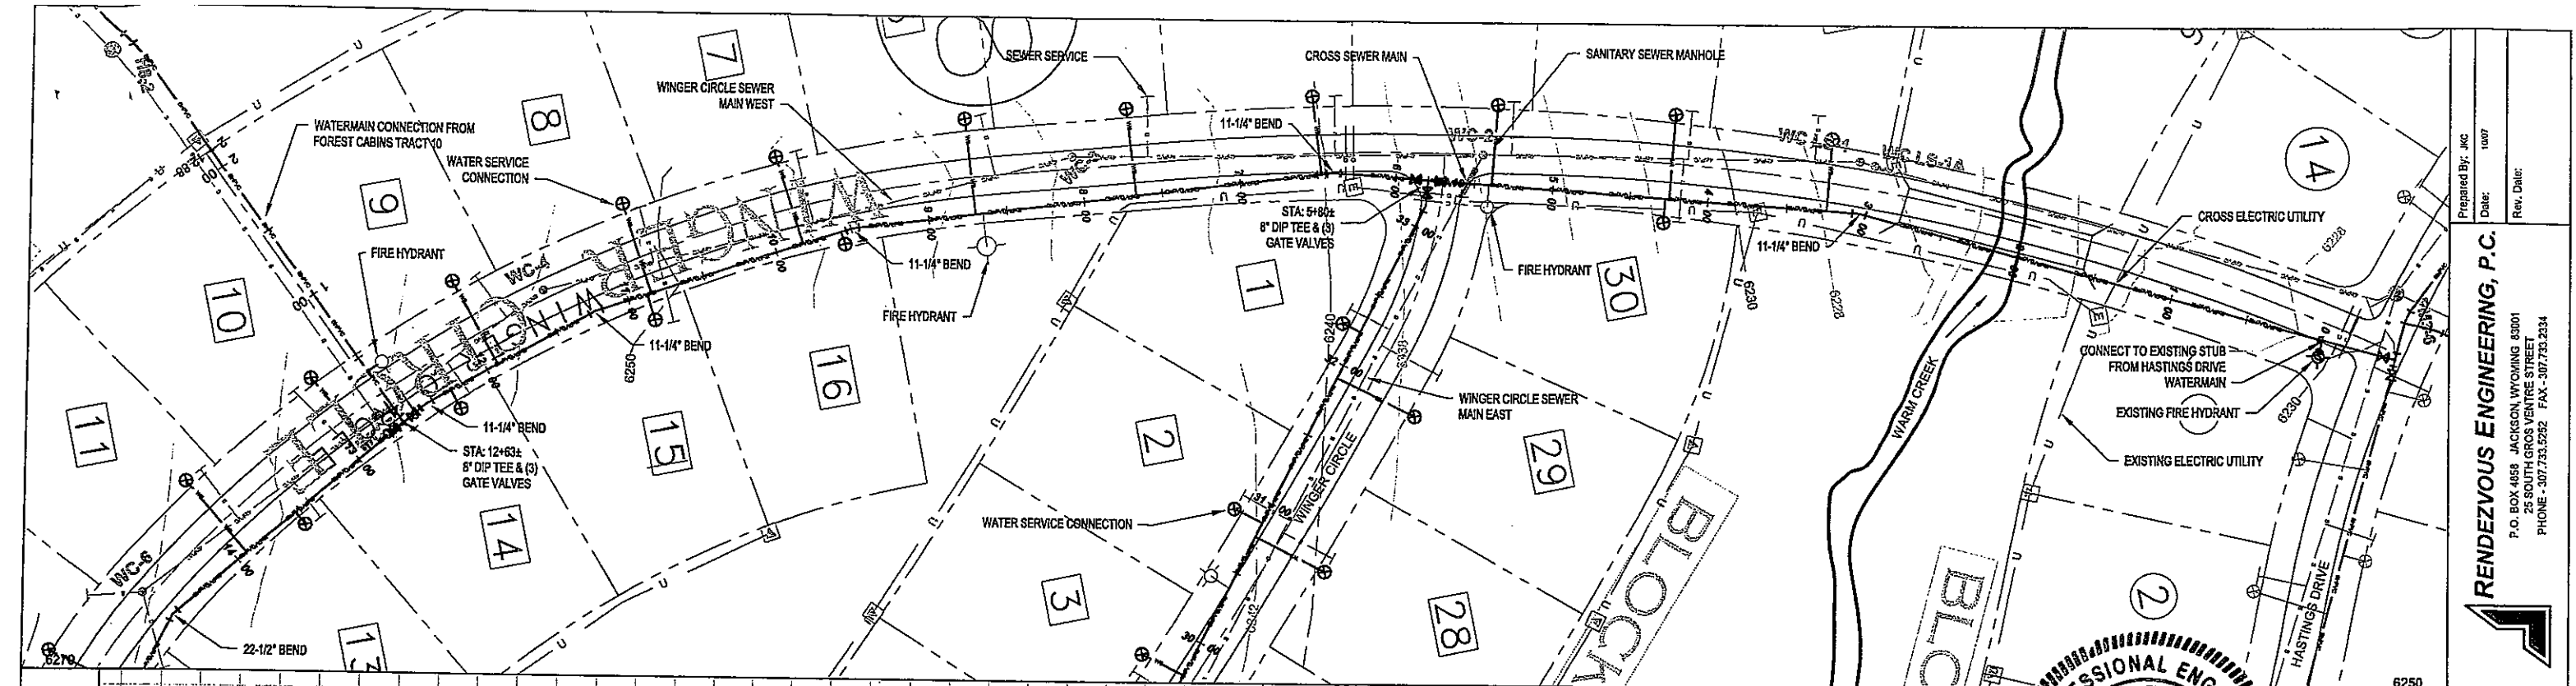

NOTES - THIS SHEET

GENERAL NOTES

SCALE: 1" = 50' HORIZ.
1" = 5' VERT.

PROJECT TITLE:
RECORD DRAWINGS
TETON SPRINGS

PROJECT NUMBER:
04-002


DRAWING NUMBER:
ASBW-48

DRAWING TITLE:
ASBUILT WATERMAIN
WATER MAIN "U"
WINGER CIRCLE

DRAWING TITLE:
RECORD DRAWINGS
TETON SPRINGS

PROFESSIONAL ENGINEER
REGISTERED
5994
STATE OF IDAHO
ROBERT T. ABLONDI

RENDZVOUS ENGINEERING, P.C.
P.O. BOX 4858 JACKSON WYOMING 83001
25 SOUTH GROS VENTRE STREET
PHONE - 307.733.5252 FAX - 307.733.2334

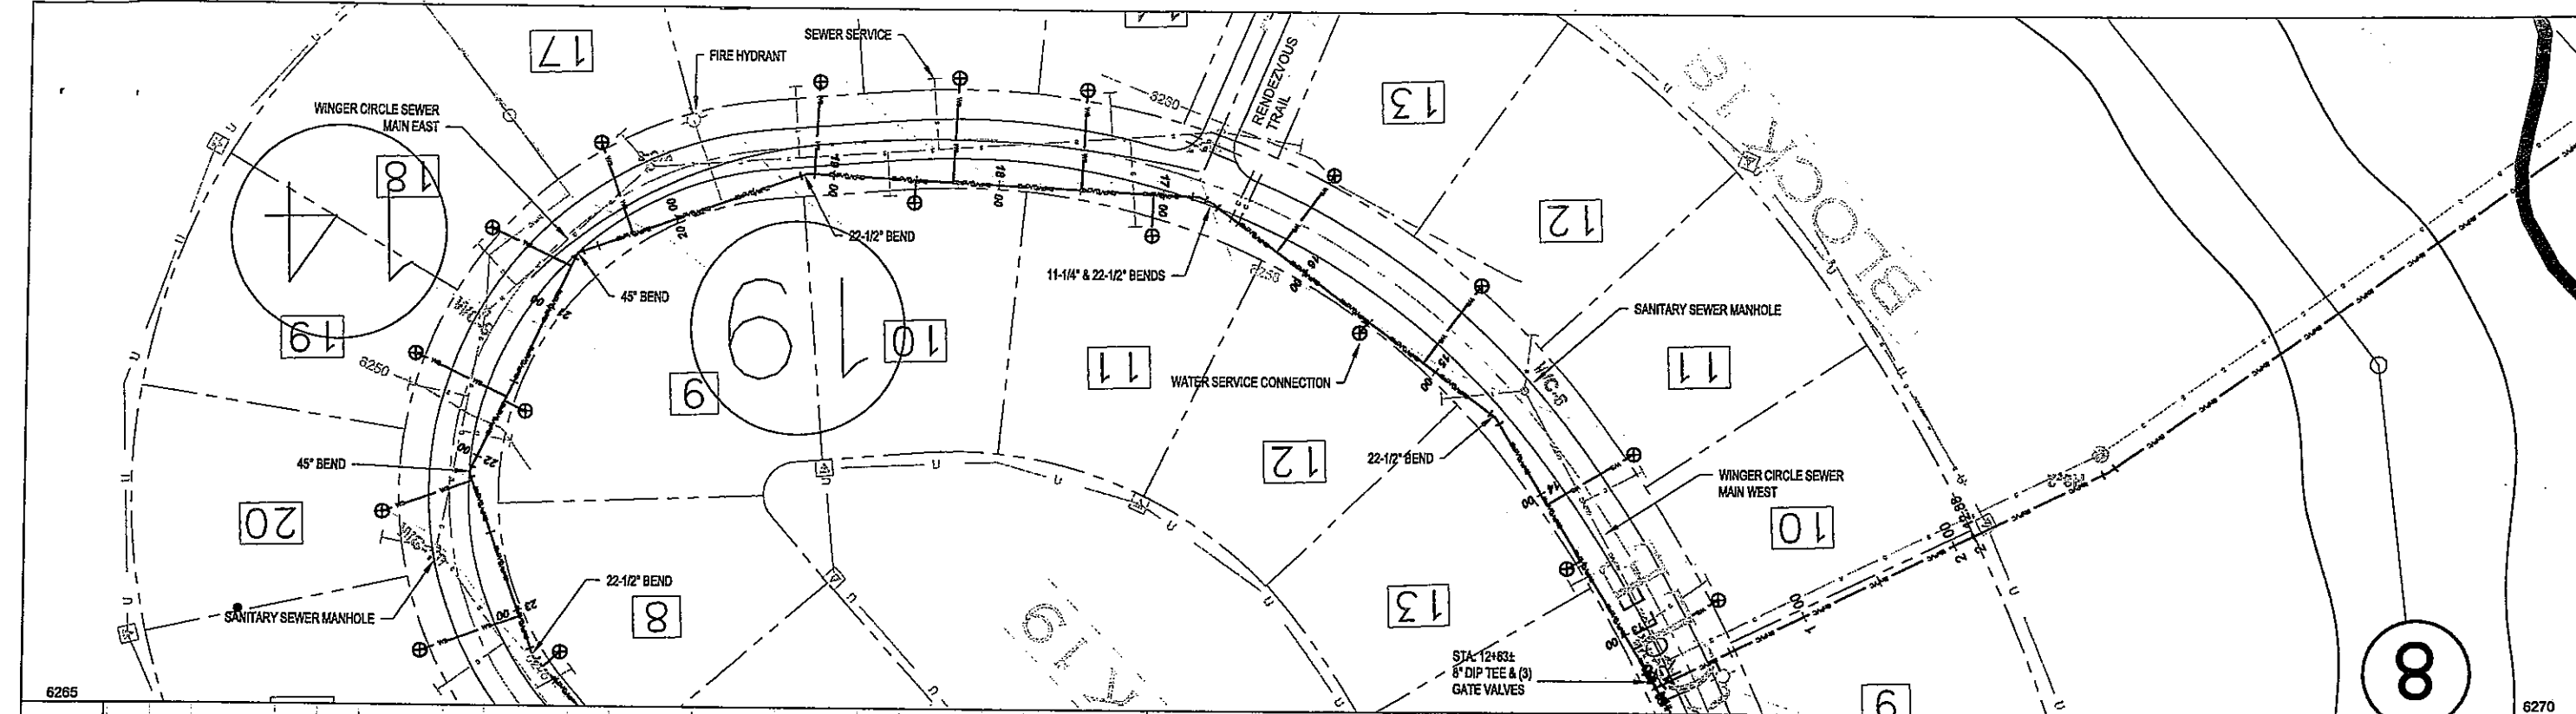


6260	6255	6250	6245	6240	6235	6230	6225																																																																																																																																																																																																																																																																																																																																																																																																																																																																																																																																																													
6265	6260	6255	6250	6245	6240	6235	6230																																																																																																																																																																																																																																																																																																																																																																																																																																																																																																																																																													
STA: 28+49+ WATER SERVICE BLK 18 LOT 26 STA: 28+28+ WATER SERVICE BLK 19 LOT 4	STA: 27+39+ WATER SERVICE BLK 18 LOT 25 STA: 27+16+ WATER SERVICE BLK 19 LOT 5	STA: 26+14+ WATER SERVICE BLK 18 LOT 24 STA: 25+32+ WATER SERVICE BLK 19 LOT 6	STA: 25+37+ FIRE HYDRANT	STA: 24+93+ WATER SERVICE BLK 18 LOT 23 STA: 24+72+ WATER SERVICE BLK 19 LOT 7	STA: 23+83+ WATER SERVICE BLK 18 LOT 22	STA: 23+38+ WATER SERVICE BLK 19 LOT 8 22-1/2" BEND STA: 23+04+ WATER SERVICE BLK 18 LOT 21	STA: 22+16+ WATER SERVICE BLK 18 LOT 20 STA: 22+11+ 45" BEND	STA: 21+63+ WATER SERVICE BLK 19 LOT 9 STA: 21+80+ WATER SERVICE BLK 18 LOT 19	STA: 20+72+ WATER SERVICE BLK 18 LOT 18 STA: 20+67+ 45" BEND	STA: 20+28+ WATER SERVICE BLK 18 LOT 17	STA: 19+71+ FIRE HYDRANT	STA: 19+16+ 22-1/2" BEND STA: 18+12+ WATER SERVICE BLK 18 LOT 16	STA: 18+50+ WATER SERVICE BLK 19 LOT 10 STA: 18+28+ WATER SERVICE BLK 18 LOT 15	STA: 17+50+ WATER SERVICE BLK 18 LOT 14	STA: 17+06+ WATER SERVICE BLK 19 LOT 11 STA: 16+74+ 11-1/4" & 22-1/2" BENDS	STA: 16+21+ WATER SERVICE BLK 18 LOT 13	STA: 15+51+ WATER SERVICE BLK 19 LOT 12	STA: 15+08+ WATER SERVICE BLK 18 LOT 12	STA: 14+54+ 22-1/2" BEND																																																																																																																																																																																																																																																																																																																																																																																																																																																																																																																																																	
STA: 28+39+ SEWER SERVICE	STA: 27+26+ SEWER SERVICE	STA: 26+02+ SEWER SERVICE	STA: 24+83+ SEWER SERVICE	STA: 22+87+ SEWER SERVICE	STA: 21+87+ SEWER SERVICE	STA: 20+87+ SEWER SERVICE	STA: 19+87+ SEWER SERVICE	STA: 18+87+ SEWER SERVICE	STA: 17+87+ SEWER SERVICE	STA: 16+87+ SEWER SERVICE	STA: 15+87+ SEWER SERVICE	STA: 14+87+ SEWER SERVICE	STA: 13+87+ SEWER SERVICE	STA: 12+87+ SEWER SERVICE	STA: 11+87+ SEWER SERVICE	STA: 10+87+ SEWER SERVICE	STA: 9+87+ SEWER SERVICE	STA: 8+87+ SEWER SERVICE	STA: 7+87+ SEWER SERVICE	STA: 6+87+ SEWER SERVICE	STA: 5+87+ SEWER SERVICE	STA: 4+87+ SEWER SERVICE	STA: 3+87+ SEWER SERVICE	STA: 2+87+ SEWER SERVICE	STA: 1+87+ SEWER SERVICE	STA: 0+87+ SEWER SERVICE	STA: -1+87+ SEWER SERVICE	STA: -2+87+ SEWER SERVICE	STA: -3+87+ SEWER SERVICE	STA: -521+87+ SEWER SERVICE	STA: -522+87+

NOTES - THIS SHEET

GENERAL NOTES

SCALE: 1" = 50' HORZ.
1" = 5' VERT.

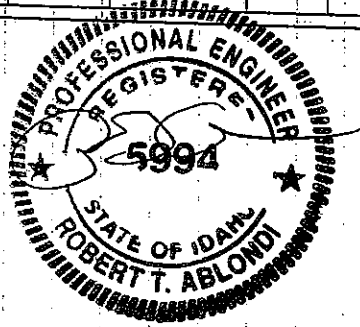

PROJECT TITLE:
RECORD DRAWINGS
TETON SPRINGS

PROJECT NUMBER:
04-002

DRAWING NUMBER:
ASBW-49

DRAWING TITLE:
ASBUILT WATERMAIN
WATER MAIN 'U'
WINGER CIRCLE

DATE: 10/07

REV. DATE: 10/07

PREPARED BY: JAC

DATE: 10/07



REV. DATE: 10/07

RENDEZVOUS ENGINEERING, P.C.

P.O. BOX 4858 JACKSON, WYOMING 83001

25 SOUTH GROS VENTRE STREET

PHONE - 307.733.5252 FAX - 307.733.2334

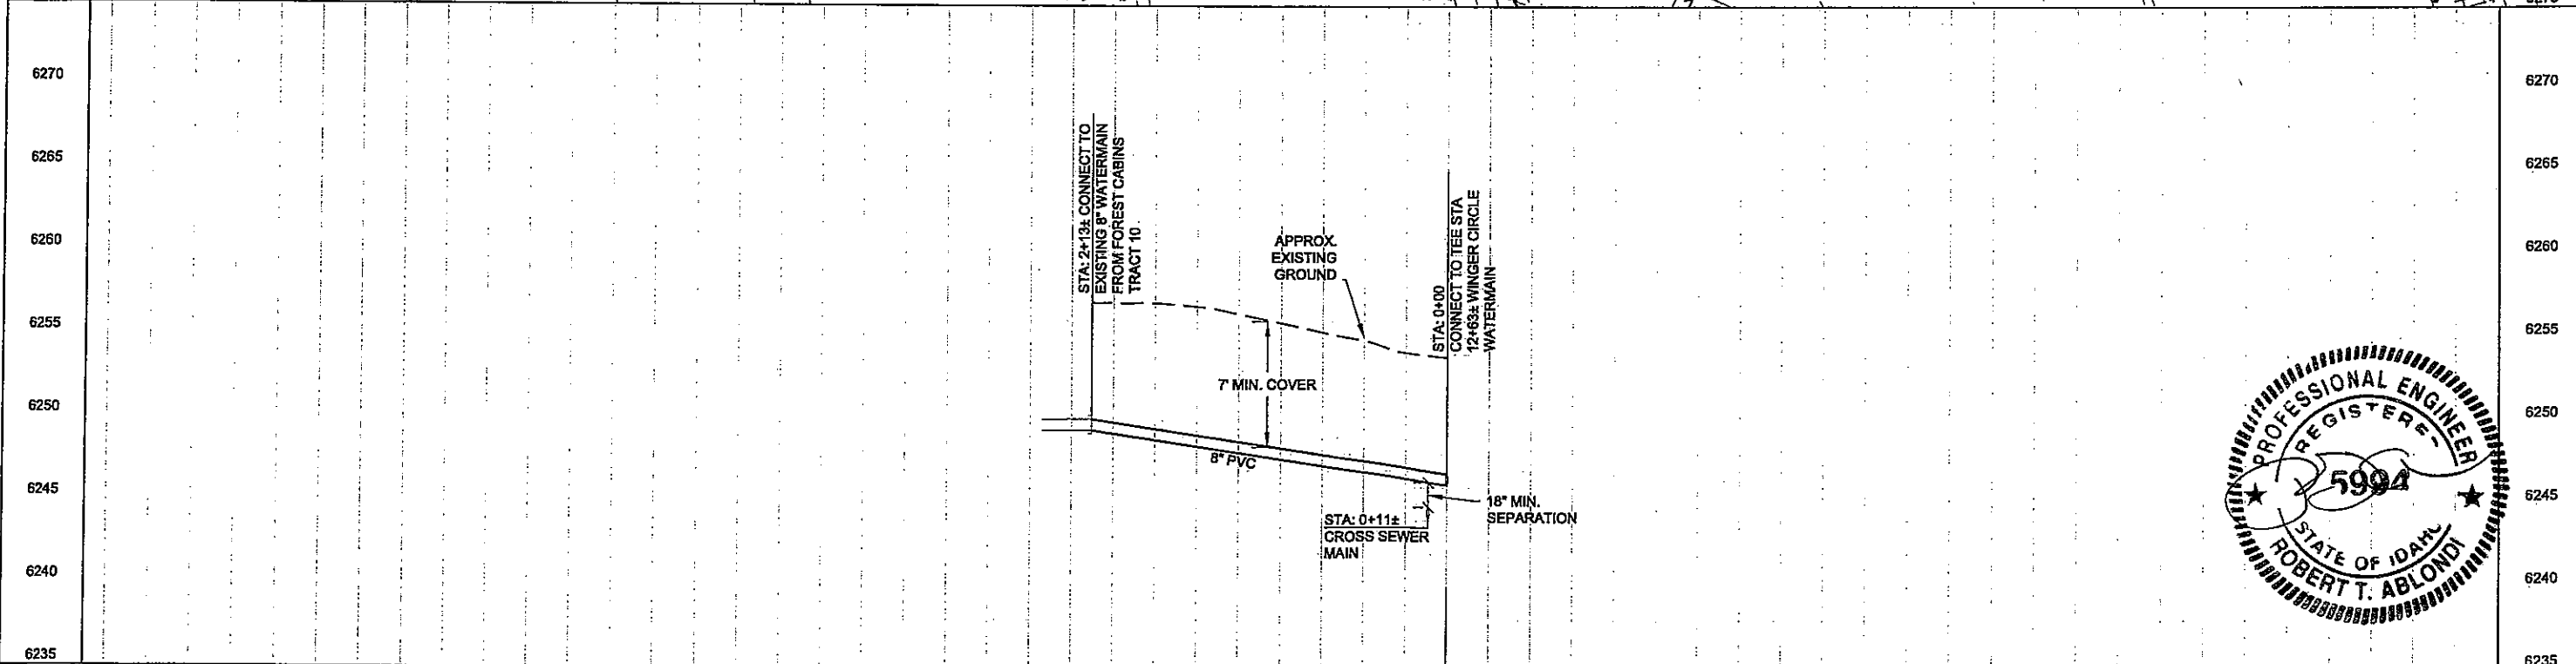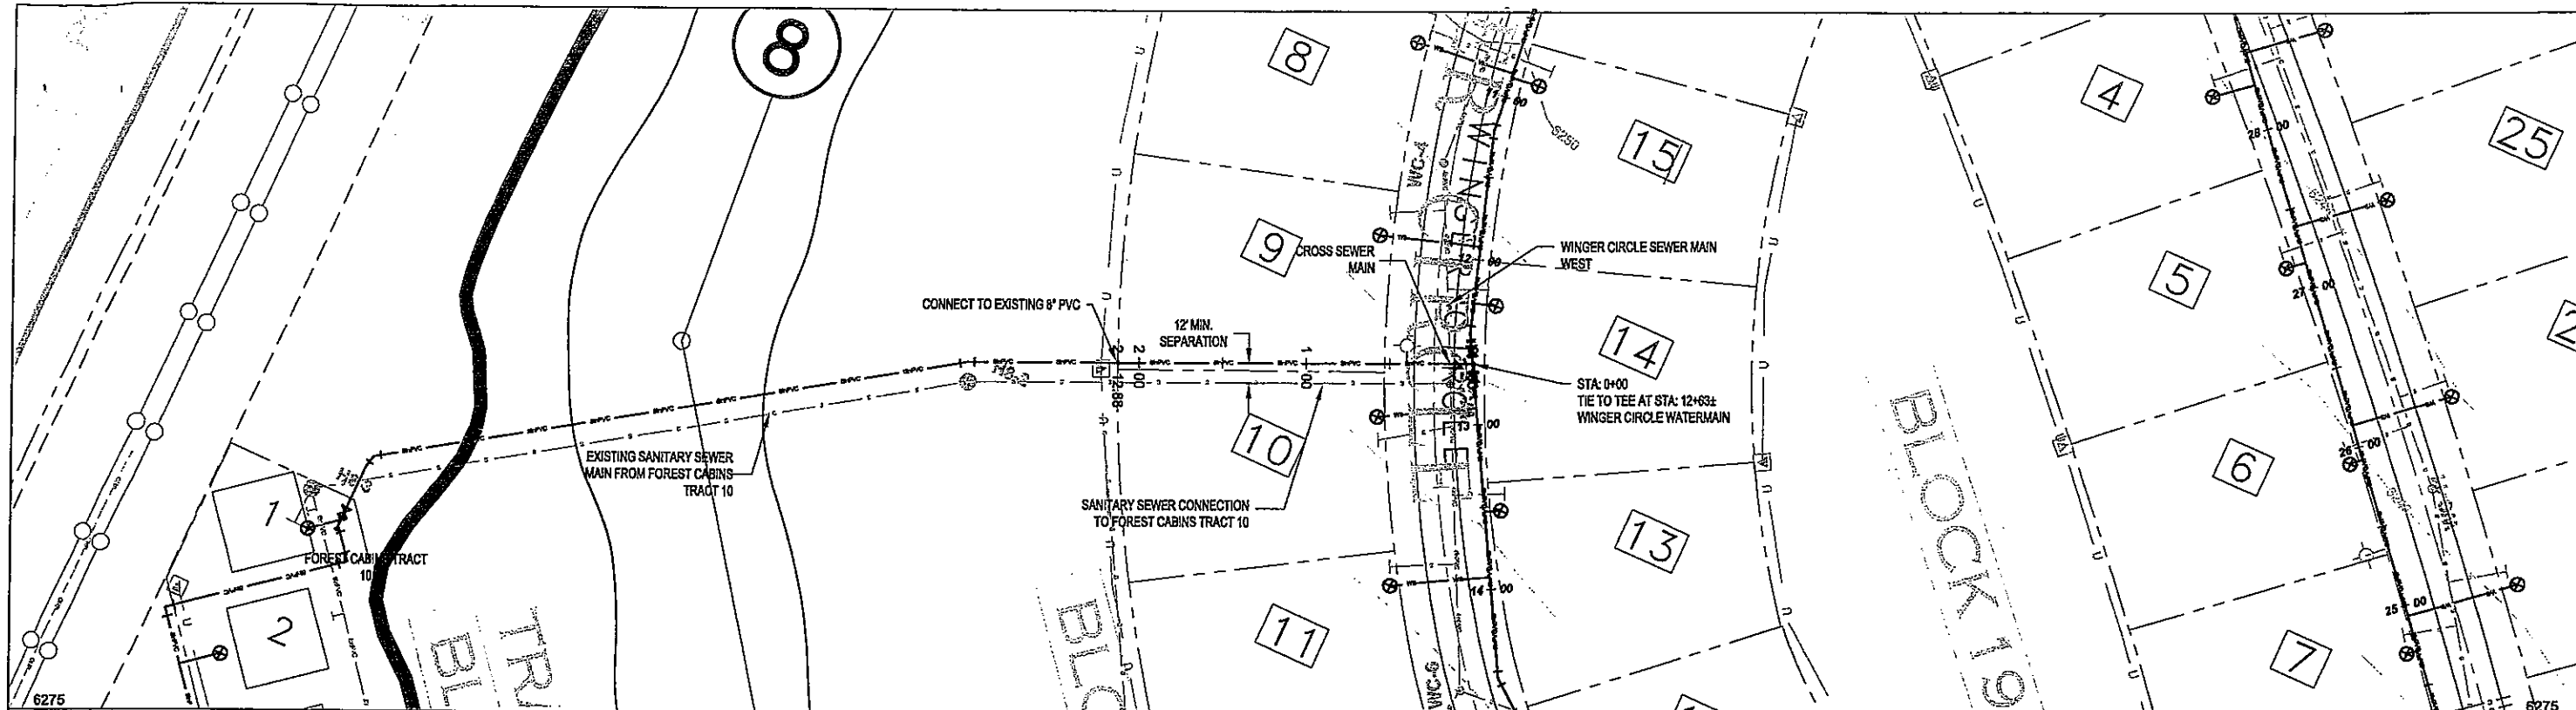


2+12.88	2+00.00	1+50.00	1+00.00	0+50.00	0+00.00
6257.1	6256.0	6255.0	6254.8	6253.5	

NOTES - THIS SHEET

GENERAL NOTES



SCALE: 1" = 50' HORIZ.
1" = 5' VERT.

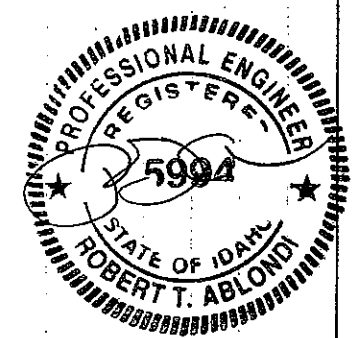

Prepared By: JGC
Date: 10/07
Rev. Date:



RENDEZVOUS ENGINEERING, P.C.
P.O. BOX 4858 JACKSON, WYOMING 83001
25 SOUTH GROS VENTRE STREET
PHONE - 307.733.5252 FAX - 307.733.2334

DRAWING TITLE:
ASBUILT WATERMAIN
WATER MAIN 'U1'
WINGER CIRCLE

PROJECT TITLE:
RECORD DRAWINGS
TETON SPRINGS


PROJECT NUMBER:
04-002

DRAWING NUMBER:
ASBW-51

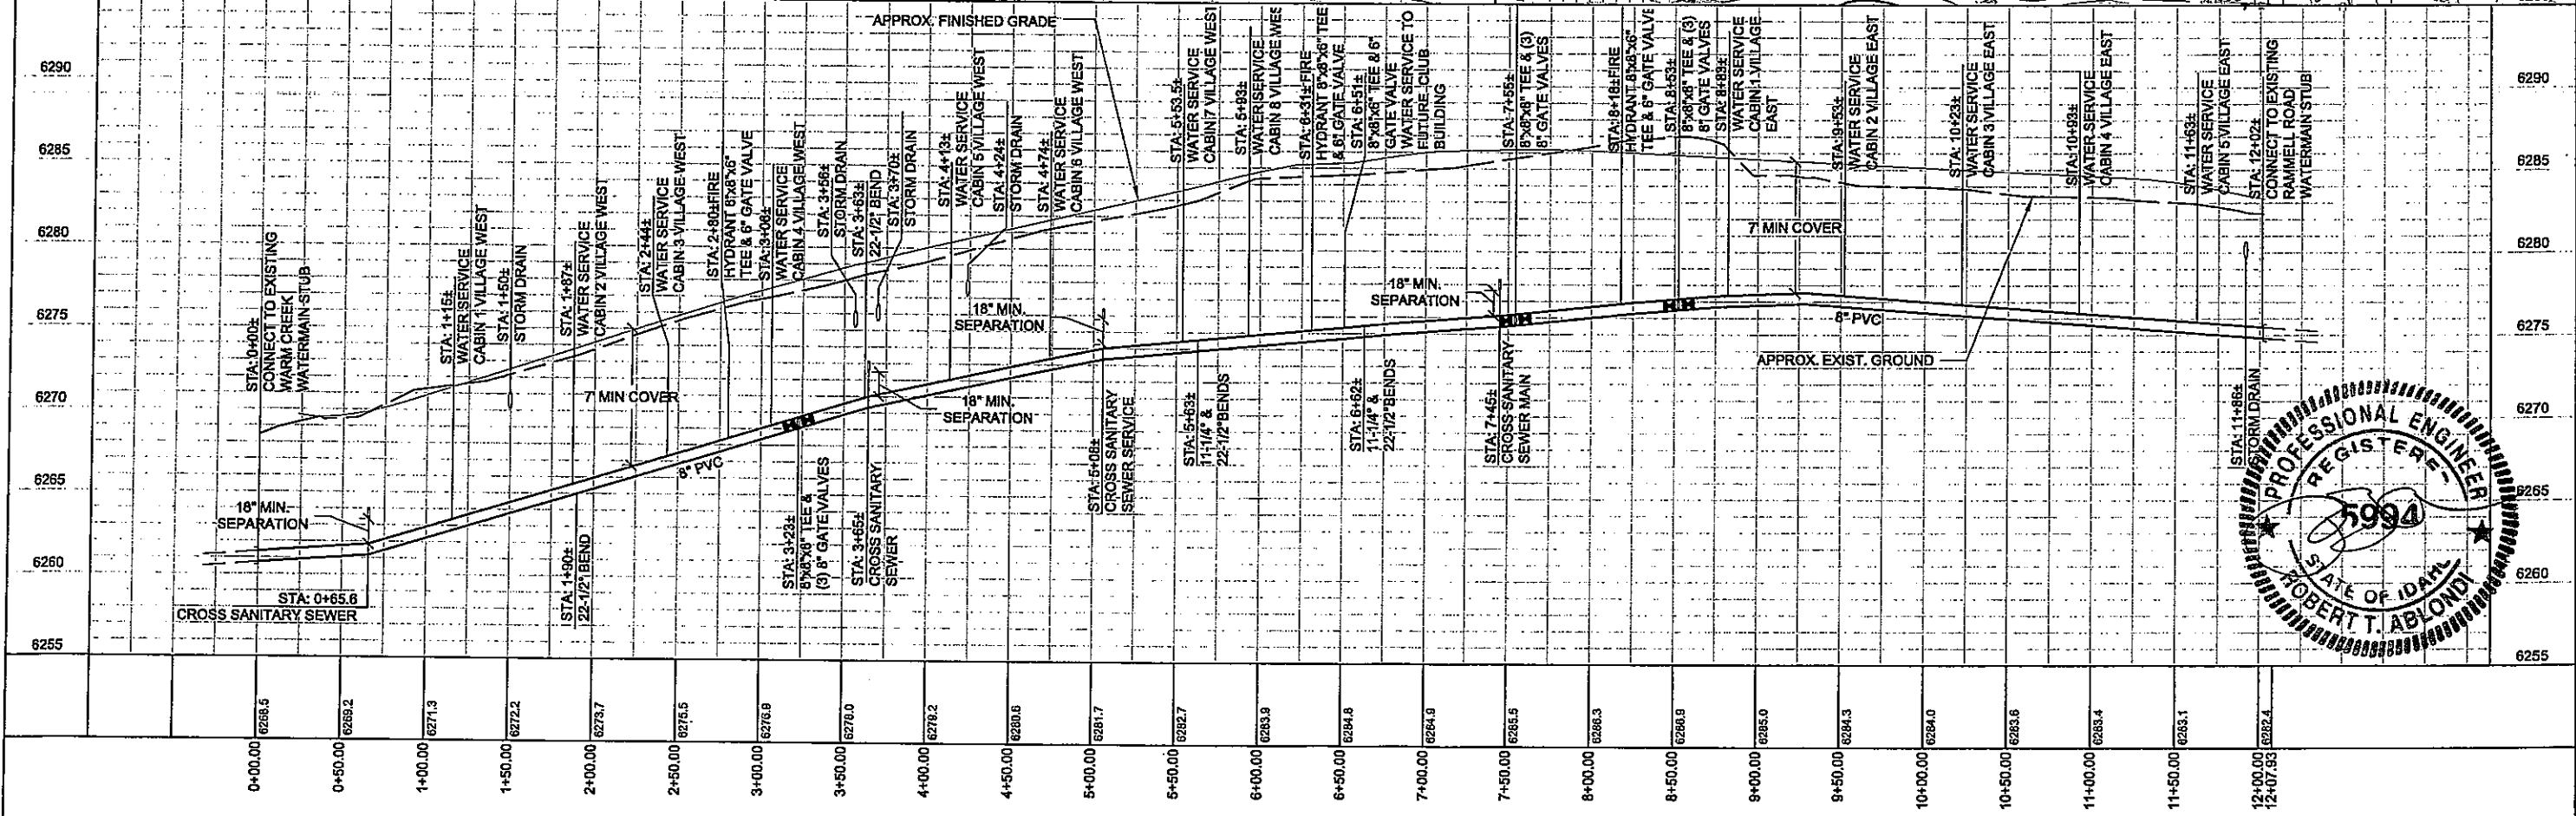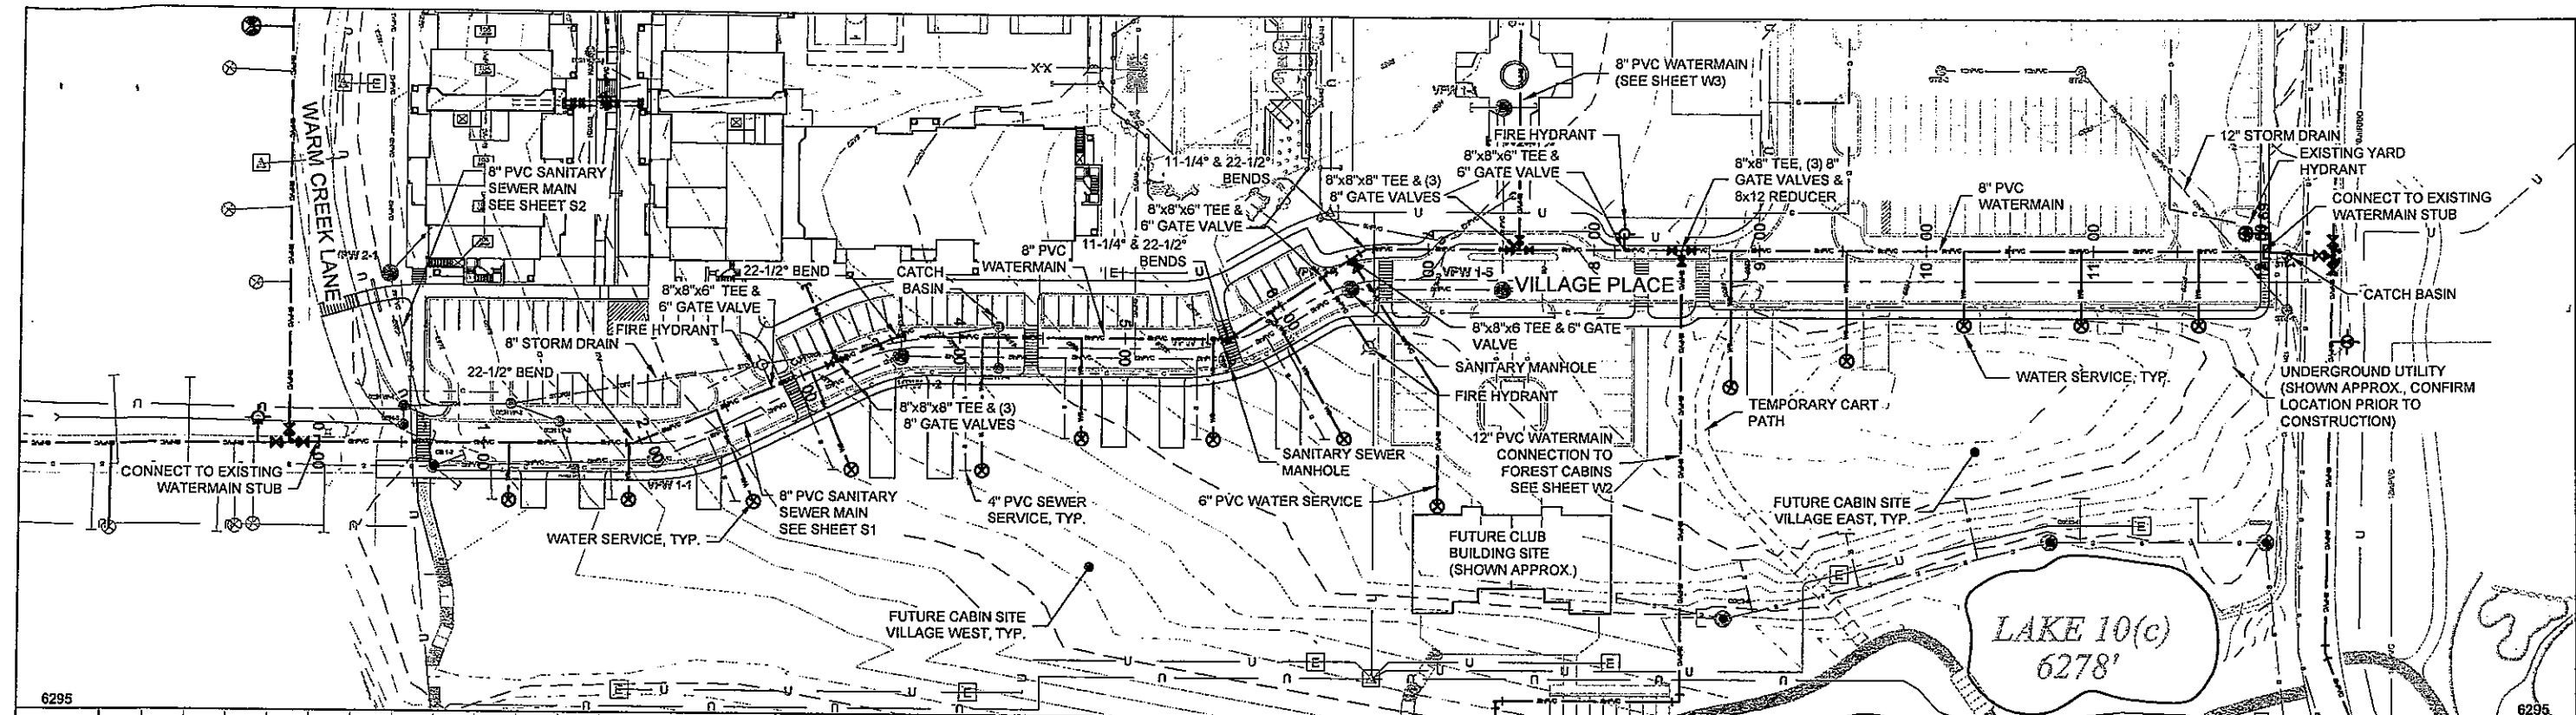

NOTES - THIS SHEET

GENERAL NOTES

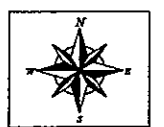

SCALE: 1" = 50' HORZ.
1" = 5' VERT.

Prepared By: JLC
Date: 10/07
Rev. Date: 08/06



RENDEZVOUS ENGINEERING, P.C.
P.O. BOX 468 JACKSON WYOMING 83001
25 SOUTH GROSVENOR STREET
PHONE: 307.733.5352 FAX: 307.733.2334

DRAWING TITLE:
ASBUILT WATERMAIN
WATER MAIN 'V1'
VILLAGE PLACE

PROJECT TITLE:
RECORD DRAWINGS
TETON SPRINGS

PROJECT NUMBER:
04-002
1.032

DRAWING NUMBER:
ASBW-52

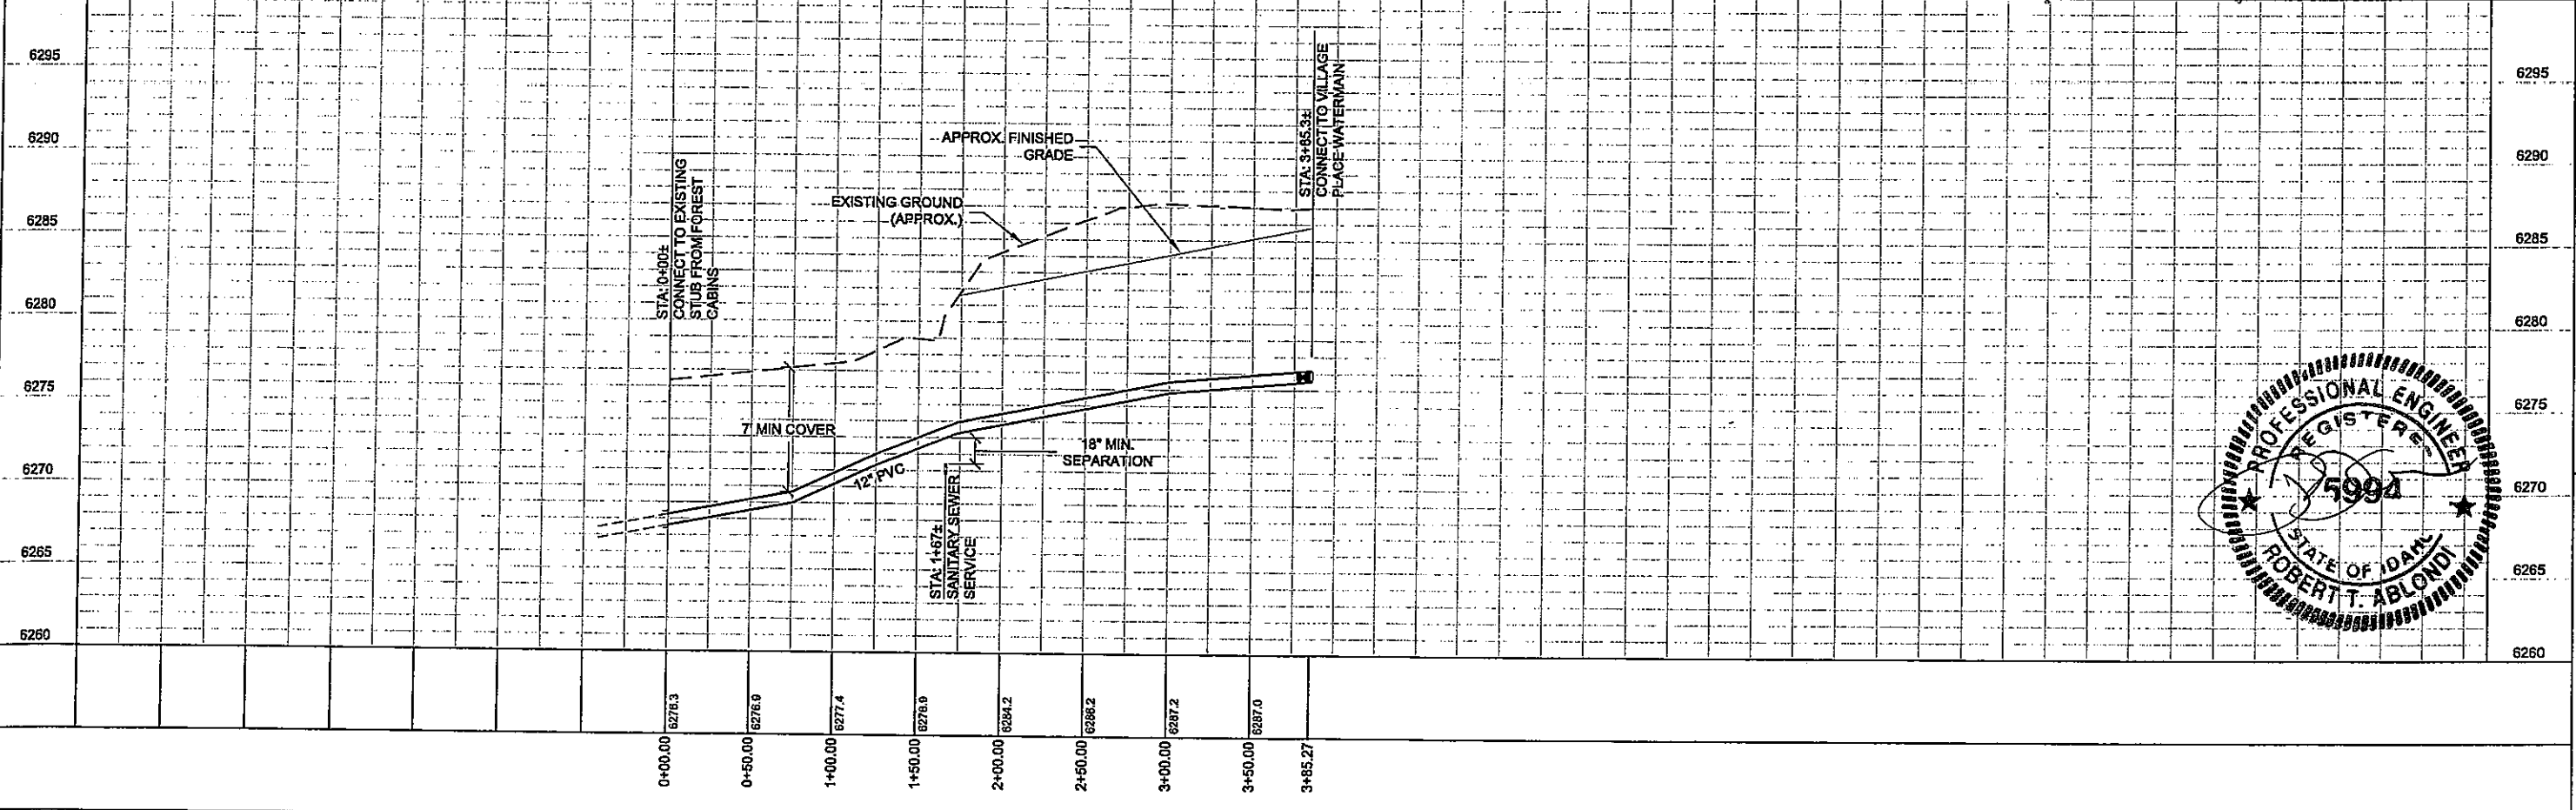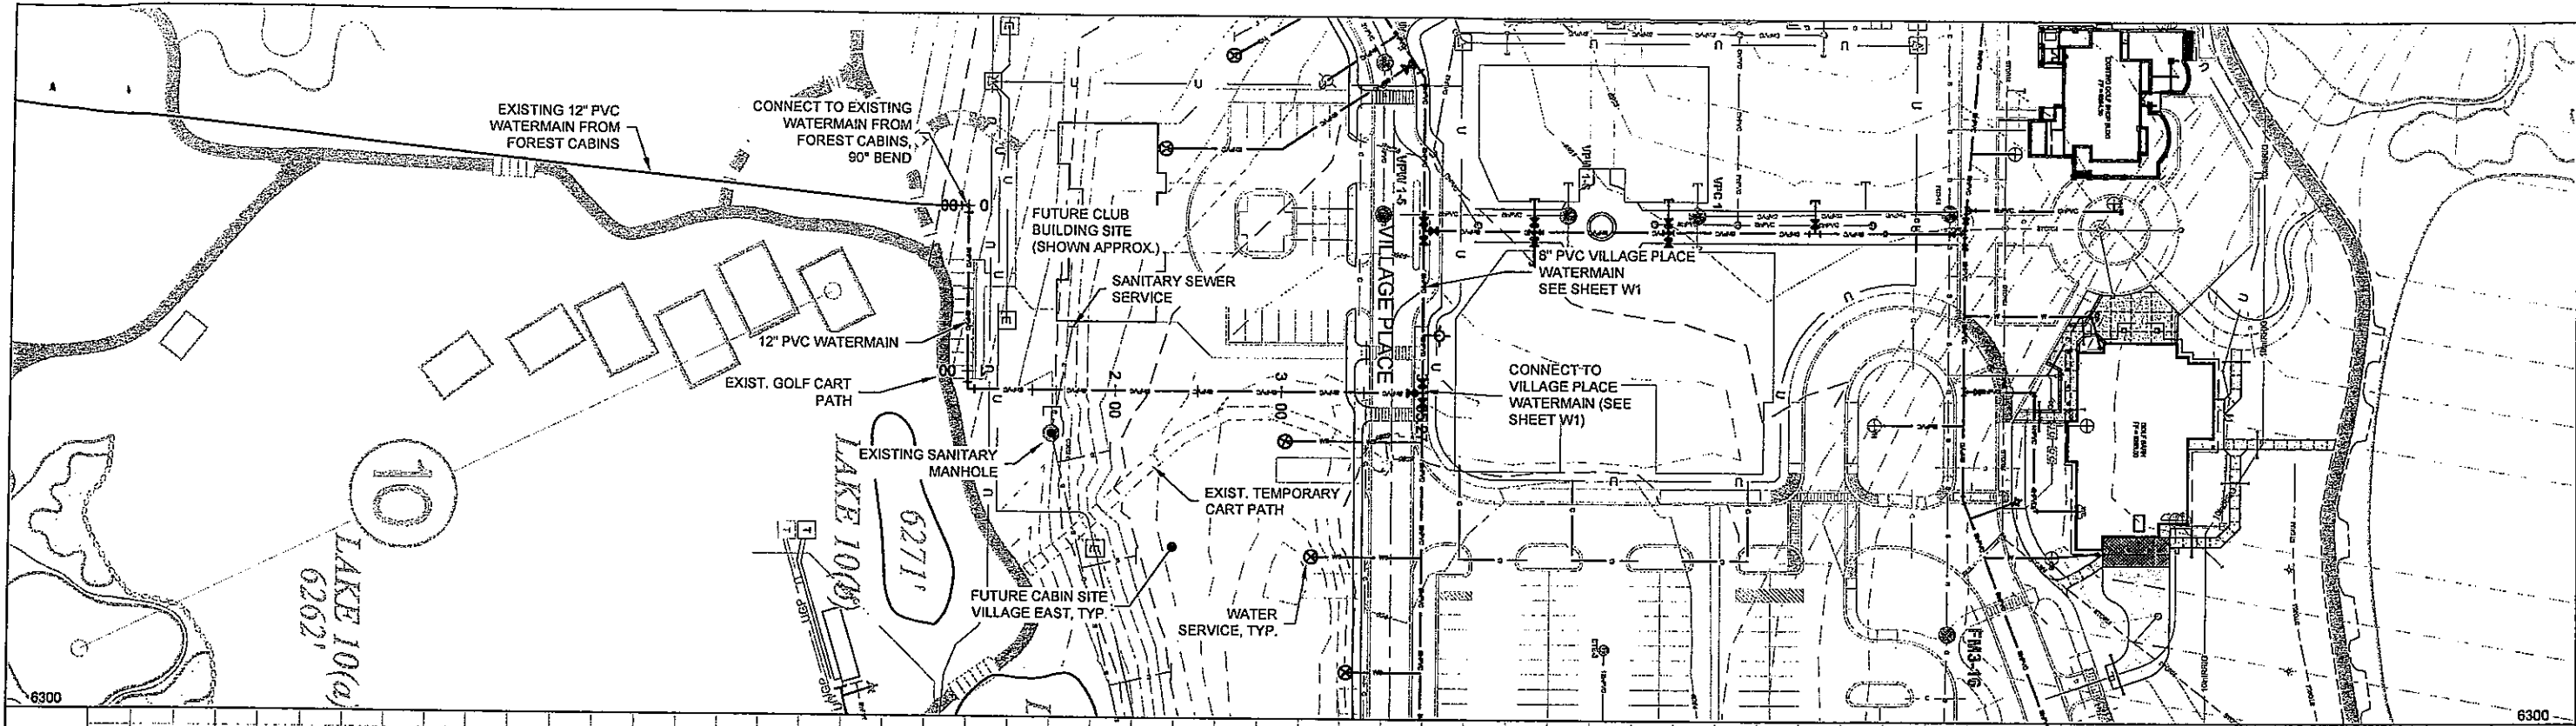


NOTES - THIS SHEET

GENERAL NOTES



SCALE: 1" = 50' HORZ.
1" = 5' VERT.

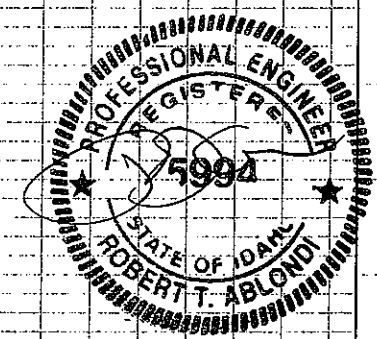

Prepared By: JAC
Date: 10/07
Rev. Date:





RENDEZVOUS ENGINEERING, P.C.
P.O. BOX 4855 JACKSON, WYOMING 83001
25 SOUTH GROS VENTRE STREET
PHONE - 307.733.5252 FAX - 307.733.2334

DRAWING TITLE:
ASBUILT WATERMAIN
WATER MAIN "V2"
COMMERCIAL CENTER

PROJECT TITLE:
RECORD DRAWINGS
TETON SPRINGS


PROJECT NUMBER:
04-002
1.032

DRAWING NUMBER:
ASBW-53

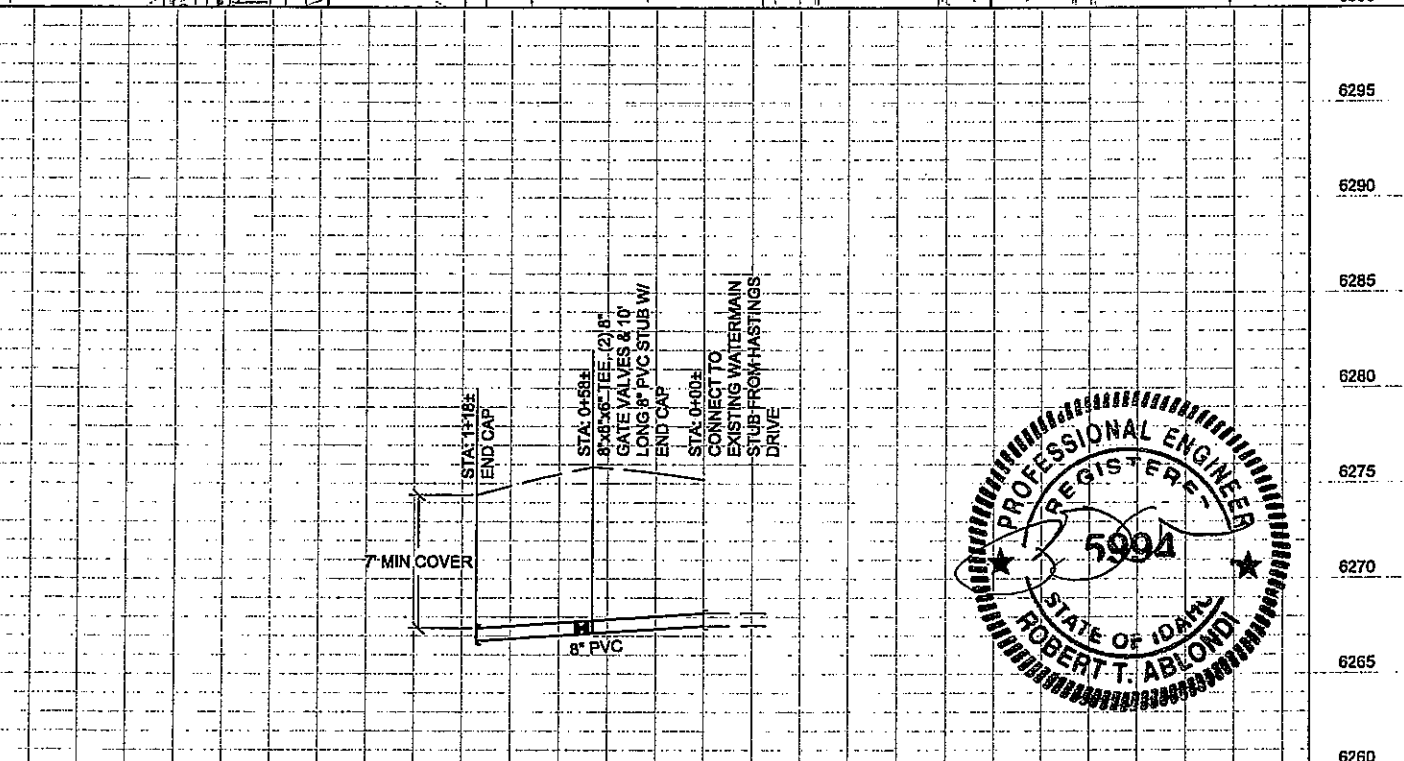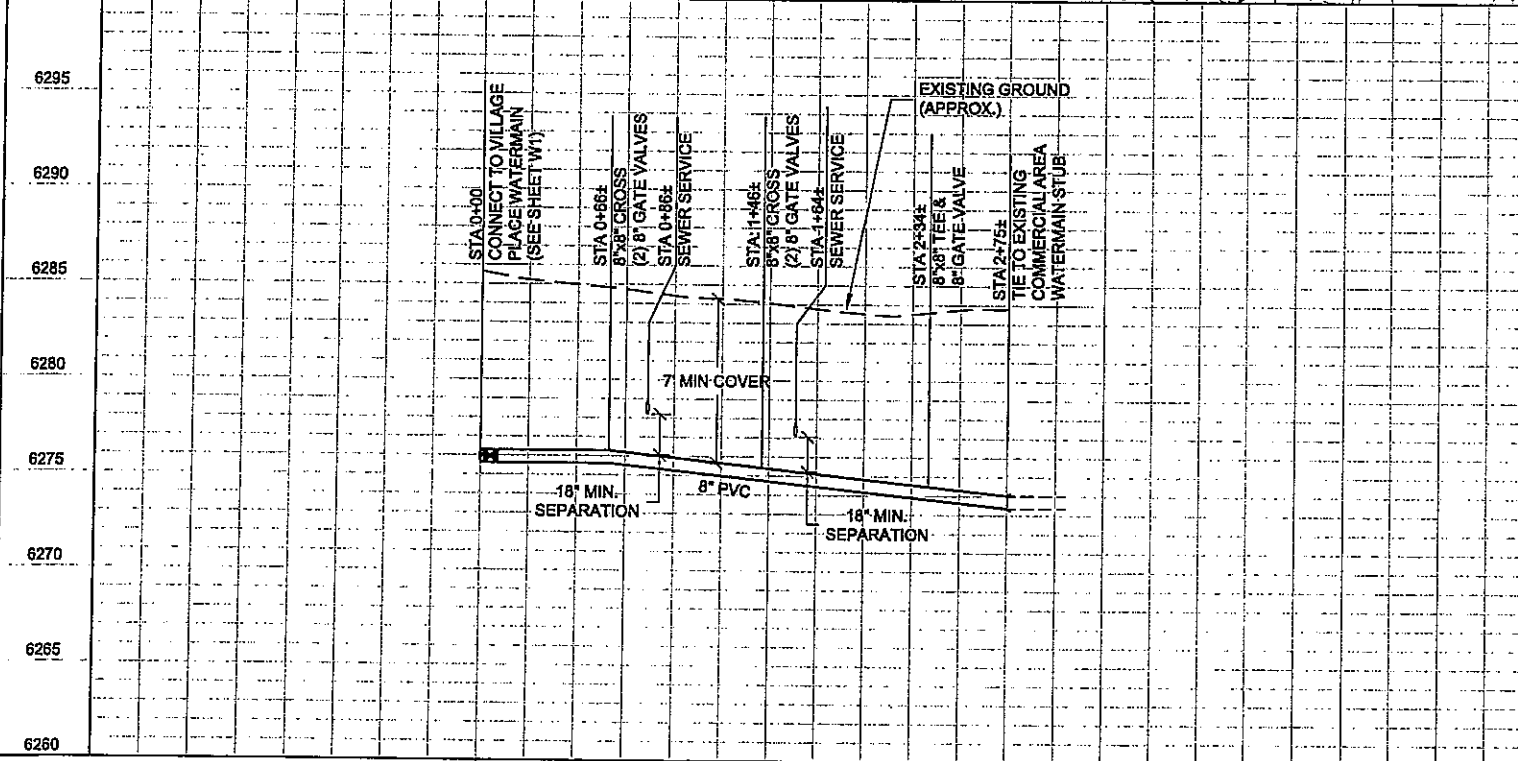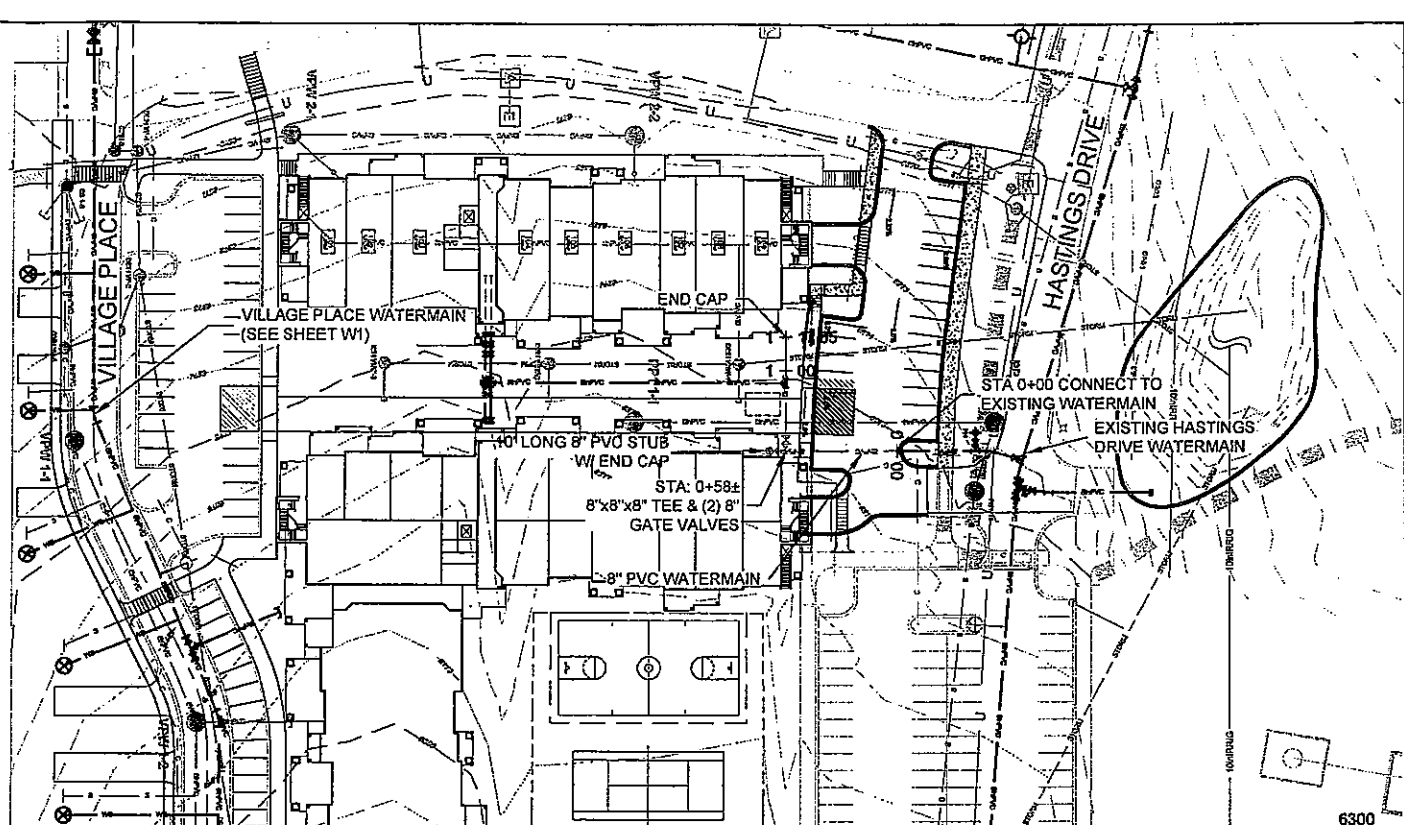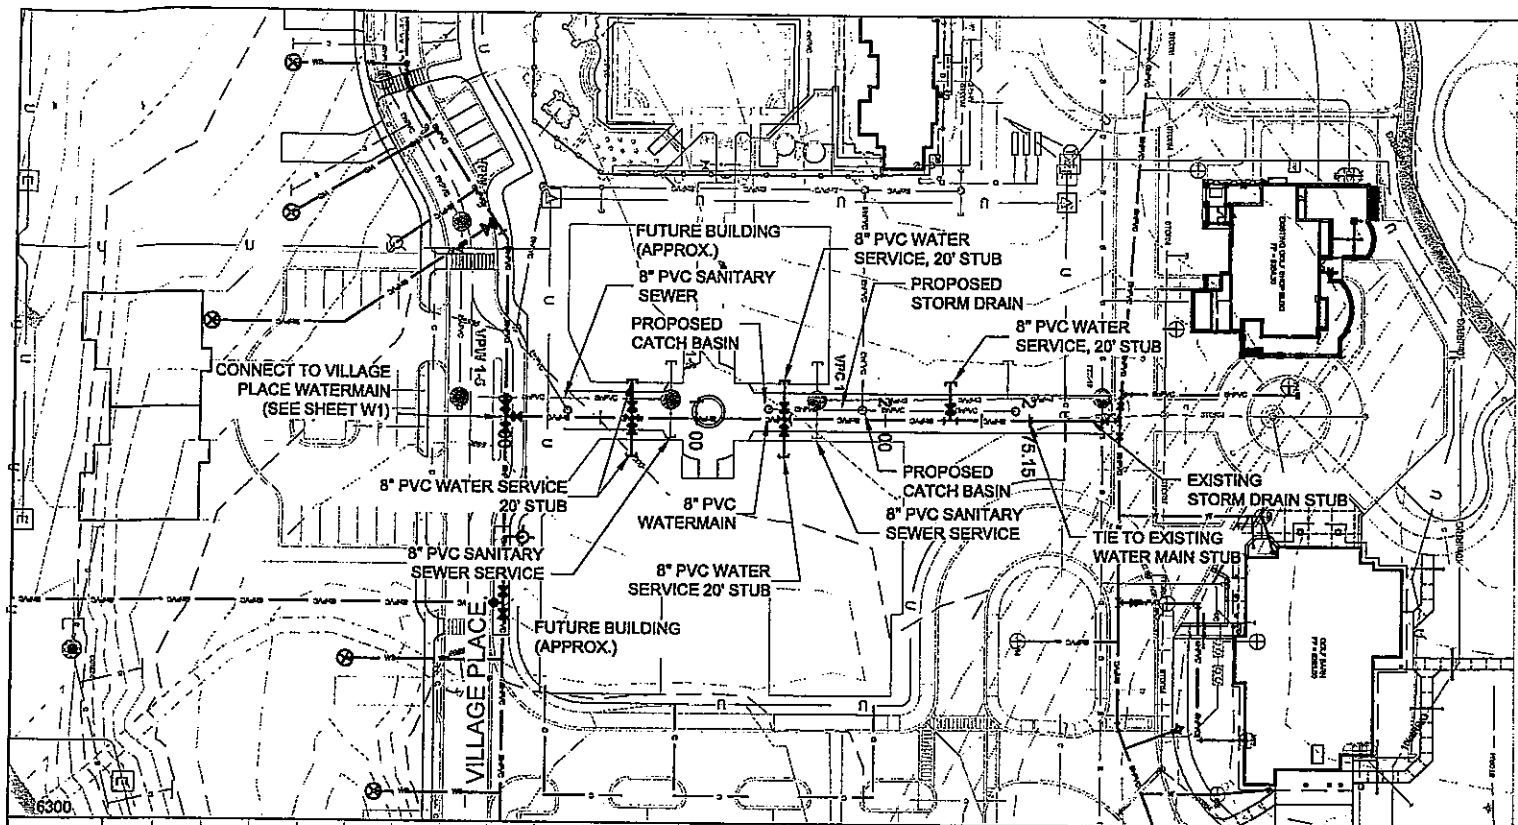

NOTES - THIS SHEET

GENERAL NOTES

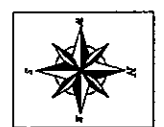

SCALE: 1" = 50' HORZ.
1" = 5' VERT.


RENDEZVOUS ENGINEERING, P.C.
P.O. BOX 4858 JACKSON, WYOMING 83001
PHONE - 307.733.5232 FAX - 307.733.2334


DRAWING TITLE:
**ASBUILT WATERMAIN
WATER MAIN 'V3'
COMMERCIAL CENTER**

PROJECT TITLE:
**RECORD DRAWINGS
TETON SPRINGS**

PROJECT NUMBER:
**04-002
1.032**
DRAWING NUMBER:
ASBW-54


Prepared By: JKC
Date: 10/07
Rev. Date:

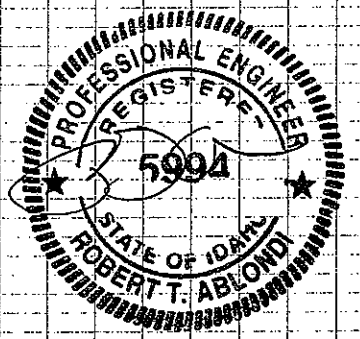

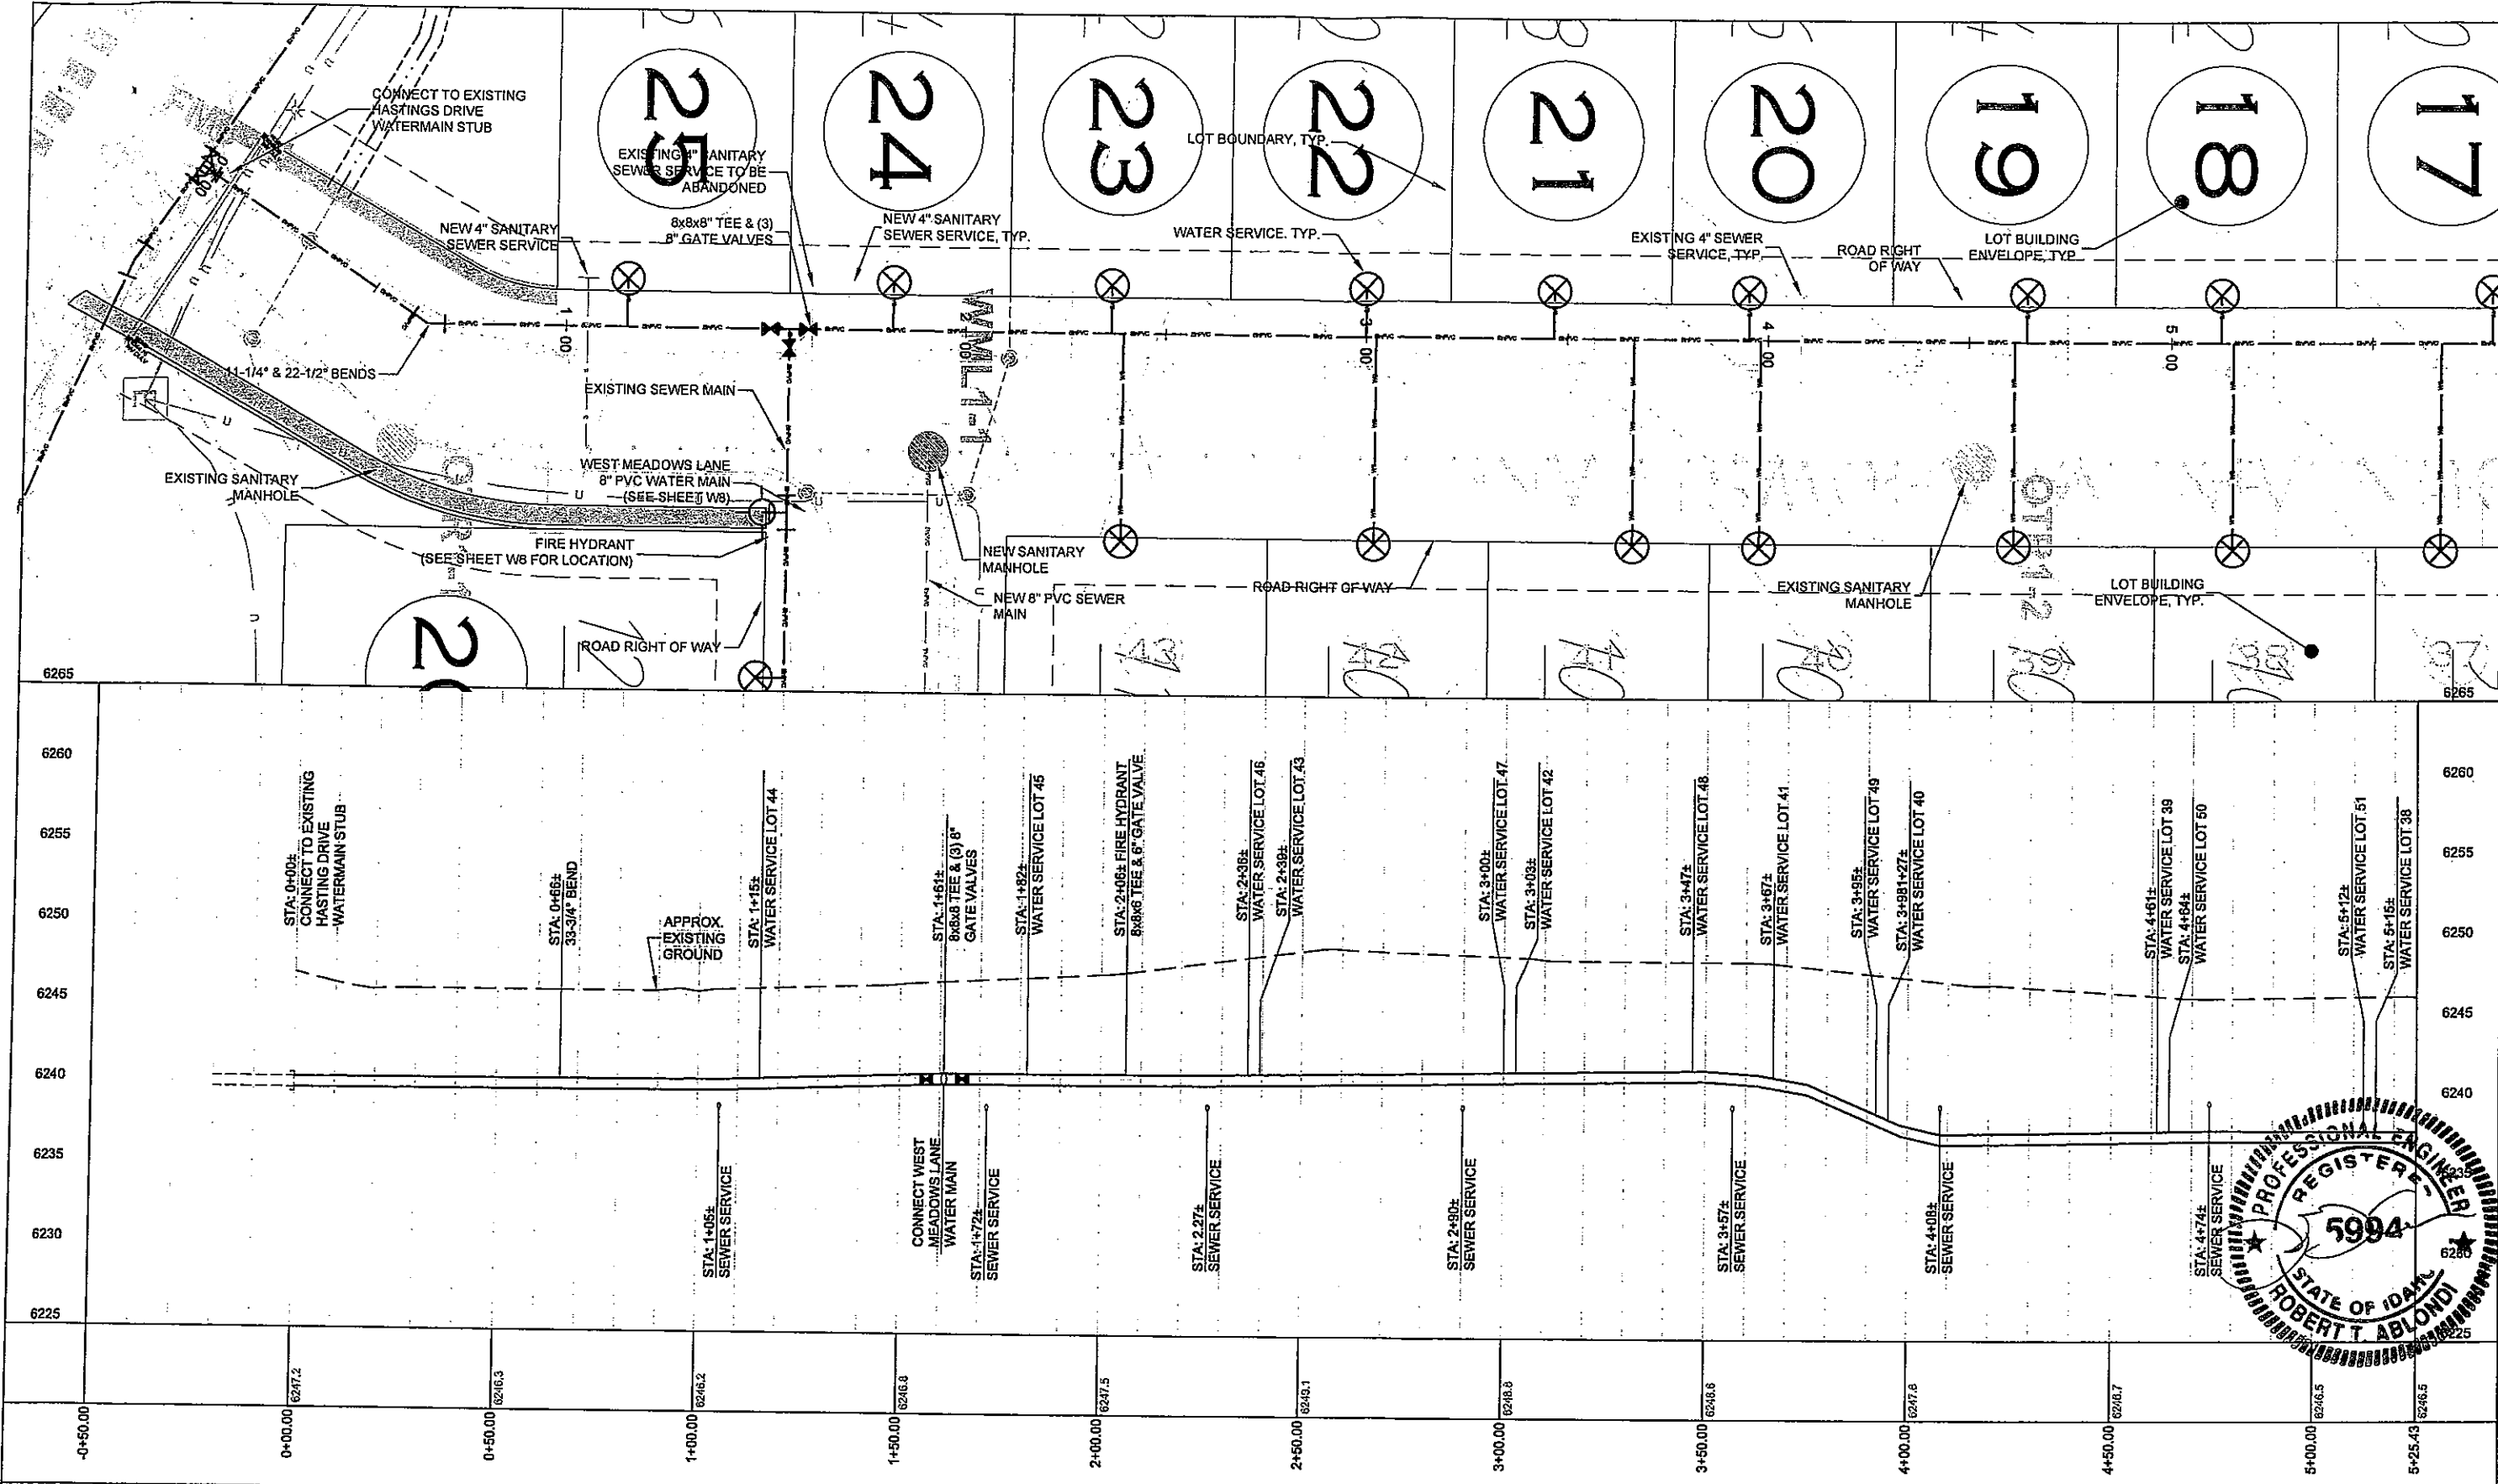



NOTES - THIS SHEET

GENERAL NOTES

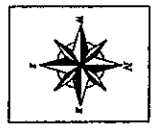

SCALE: 1" = 20' HORZ.
1" = 5' VERT.

PROJECT TITLE: RECORD DRAWINGS TETON SPRINGS		PROJECT NUMBER: 04-002 1.40	DRAWING NUMBER: ASBW-55
DRAWING TITLE: ASBUILT WATERMAIN WATER MAIN 'W1' MOUNTAIN MEADOWS LANE		PREPARED BY: JNC DATE: 10/07 REV. DATE:	
RENDEZVOUS ENGINEERING, P.C. P.O. BOX 4858 JACKSON, WYOMING 83301 25 SOUTH GROS VENTRE STREET PHONE - 307.733.5252 FAX - 307.733.2334			

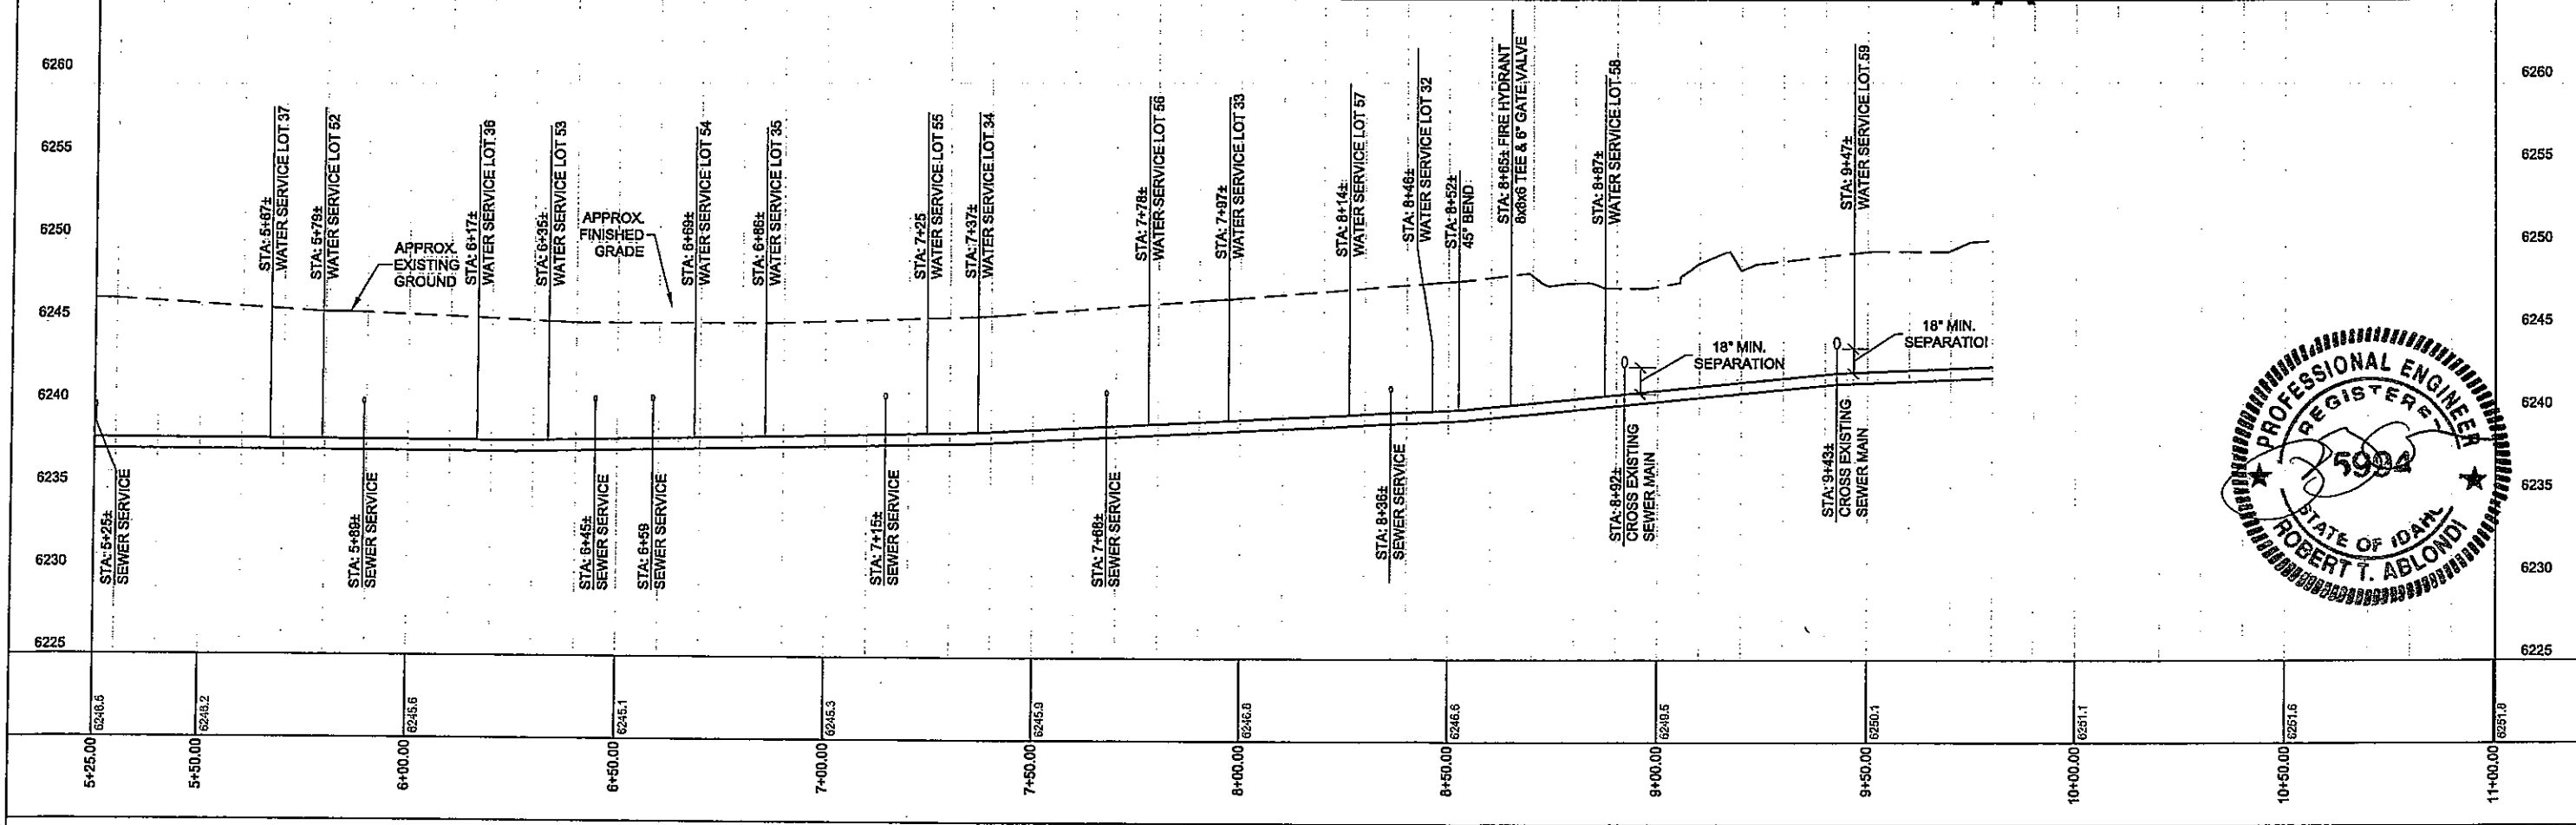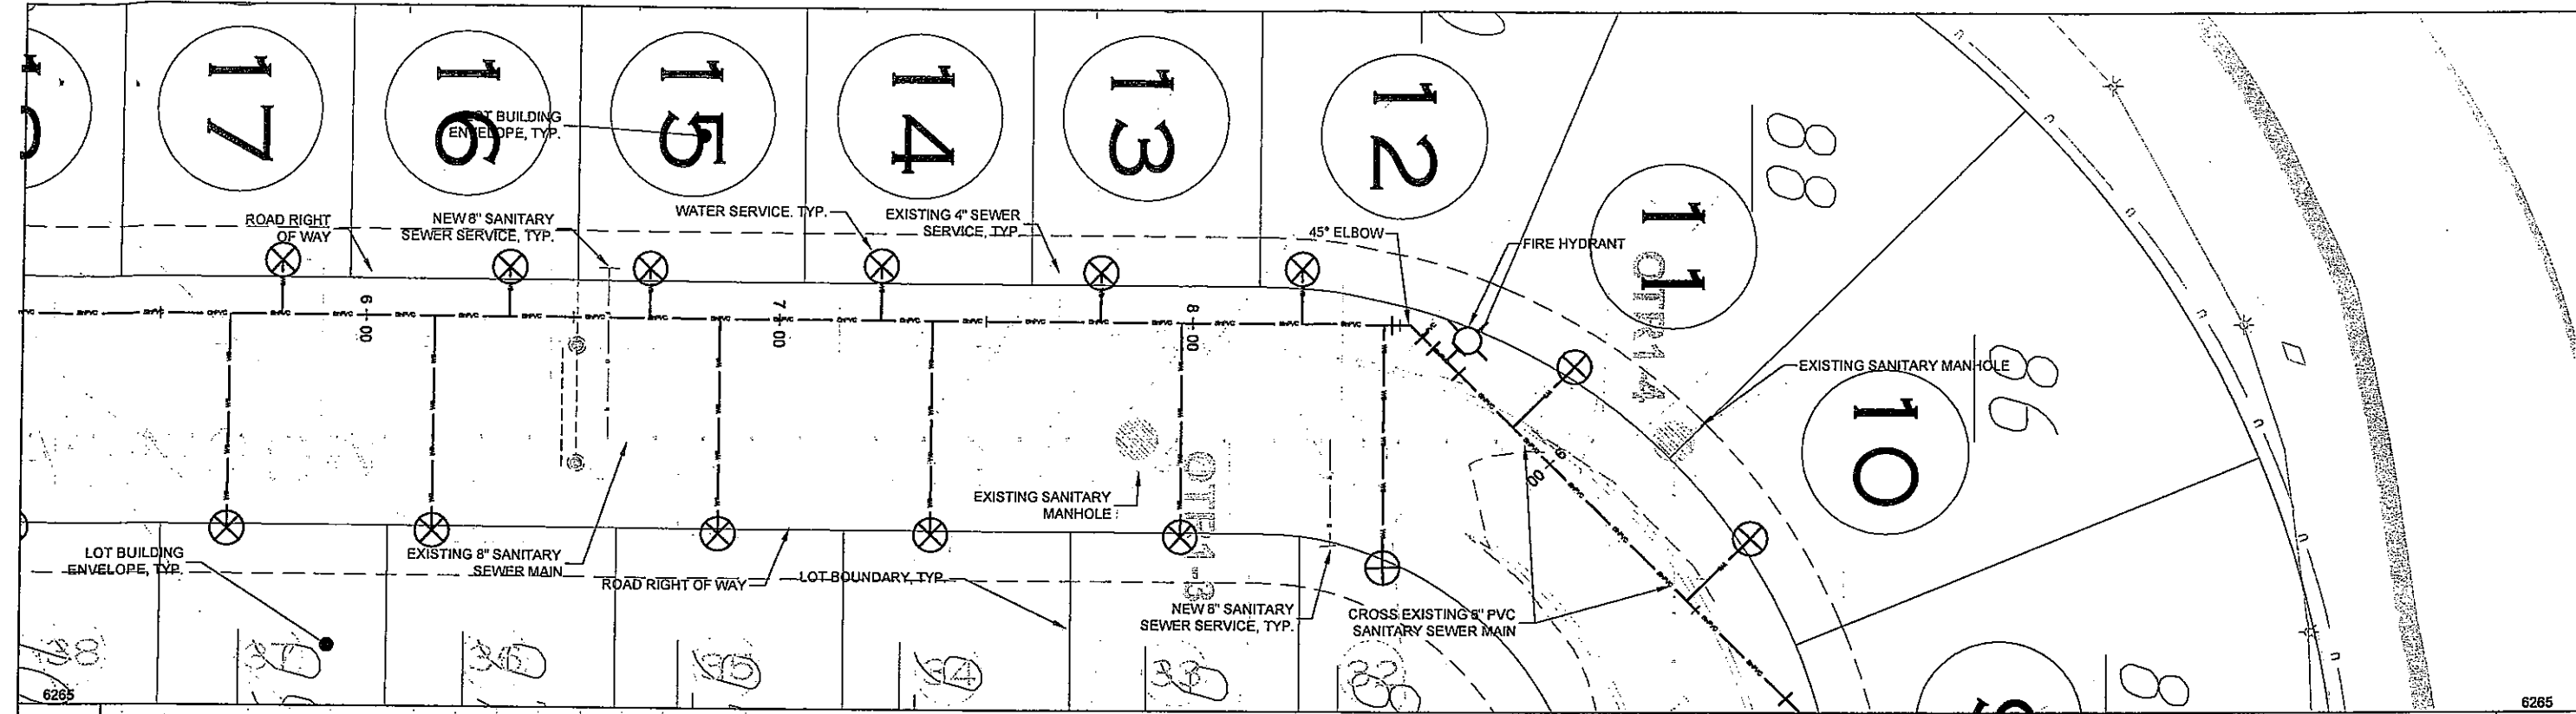

NOTES - THIS SHEET

GENERAL NOTES

SCALE: 1" = 20' HORIZ.
1" = 5' VERT.

PROJECT TITLE:
RECORD DRAWINGS
TETON SPRINGS

PROJECT NUMBER:
04-002
1.40


DRAWING NUMBER:
ASBW-56

DRAWING TITLE:
ASBUILT WATERMAIN
WATER MAIN 'W1'
MOUNTAIN MEADOWS LANE

PROFESSIONAL ENGINEER
REGISTERED
5994
STATE OF IDAHO
ROBERT T. ABLONDI

Prepared By: JKC
Date: 10/07
Rev. Date:

RENDEZVOUS ENGINEERING, P.C.
P.O. BOX 4858 JACKSON, WYOMING 83001
25 SOUTH GROS VENTRE STREET
PHONE - 307.733.5252 FAX - 307.733.2334

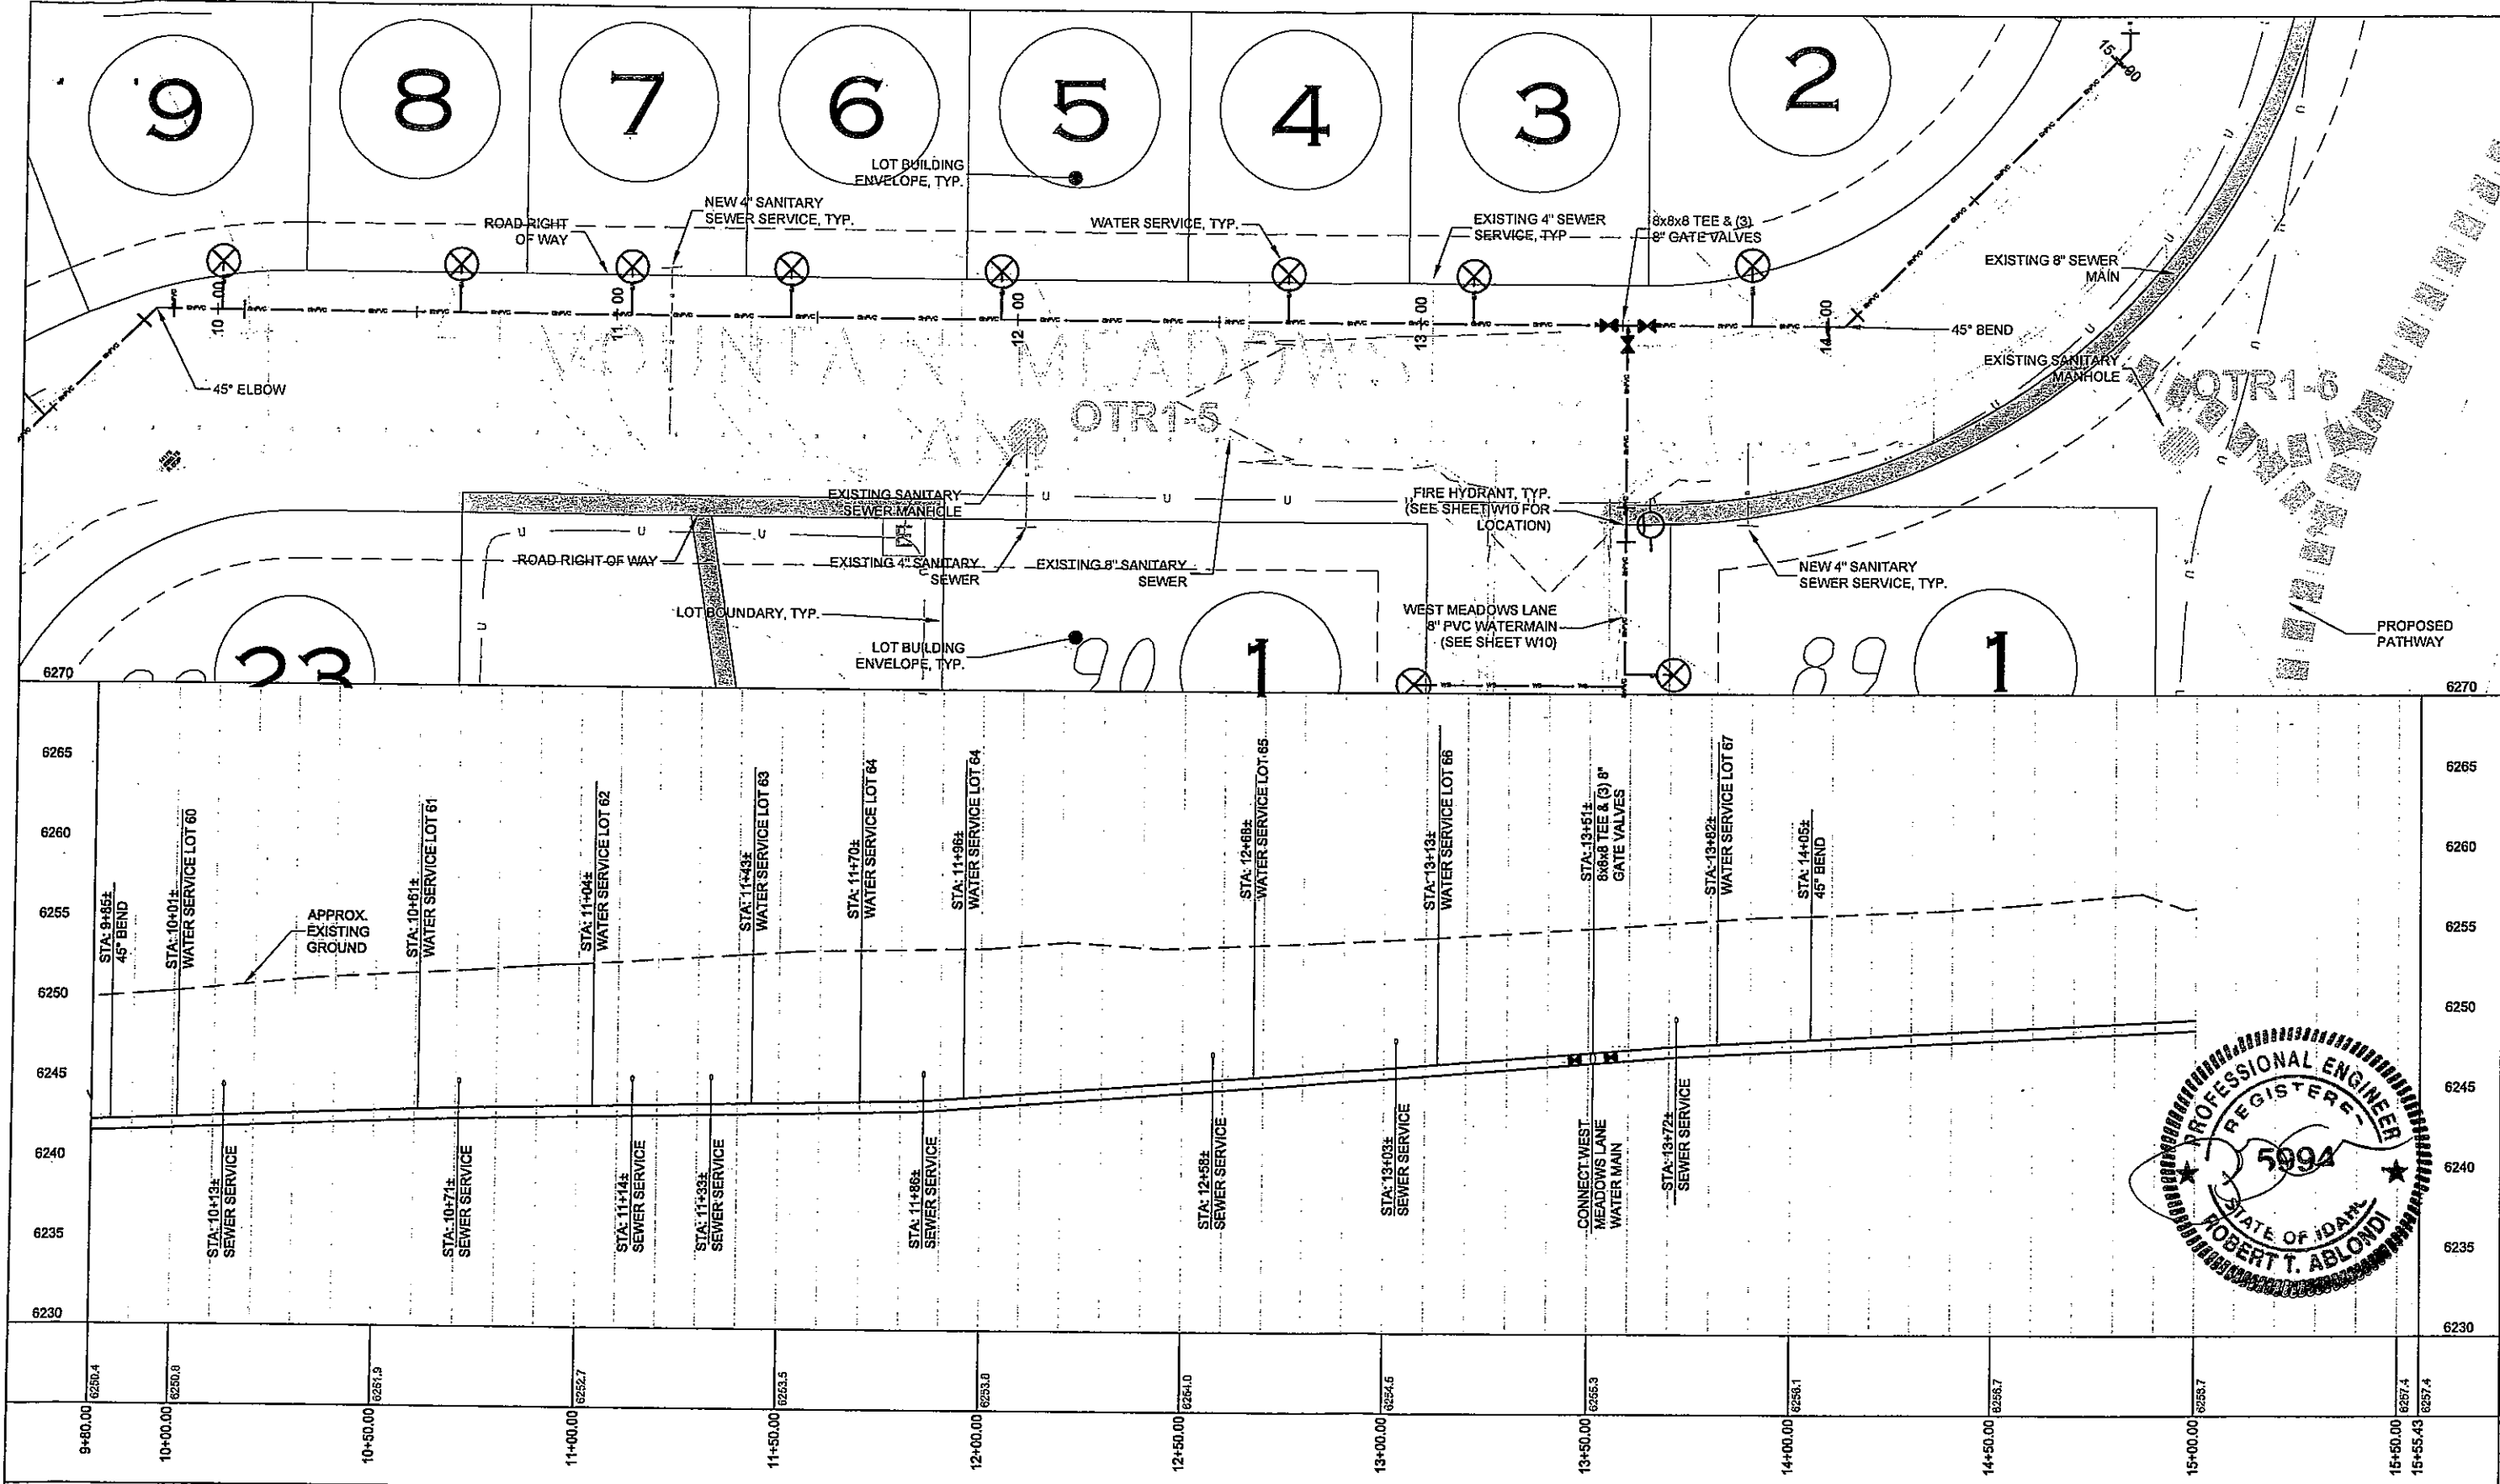

NOTES - THIS SHEET

GENERAL NOTES

SCALE: 1" = 20' HORIZ.
1" = 5' VERT.

RENDZVOUS ENGINEERING, P.C.
P.O. BOX 4858 JACKSON, WYOMING 83001
25 SOUTH GROS VENTRE STREET
PHONE - 307.733.5252 FAX - 307.733.2334

PROJECT TITLE:
RECORD DRAWINGS
TETON SPRINGS


PROJECT NUMBER:
04-002
1.40

DRAWING NUMBER:
ASBW-57

DRAWING TITLE:
ASBUILT WATERMAIN
WATER MAIN 'W1'
MOUNTAIN MEADOWS LANE

PROFESSIONAL ENGINEER
REGISTERED
5094
STATE OF IDAHO
ROBERT T. ABLONDI

PREPARED BY: JWC
DATE: 10/07
REV. DATE:

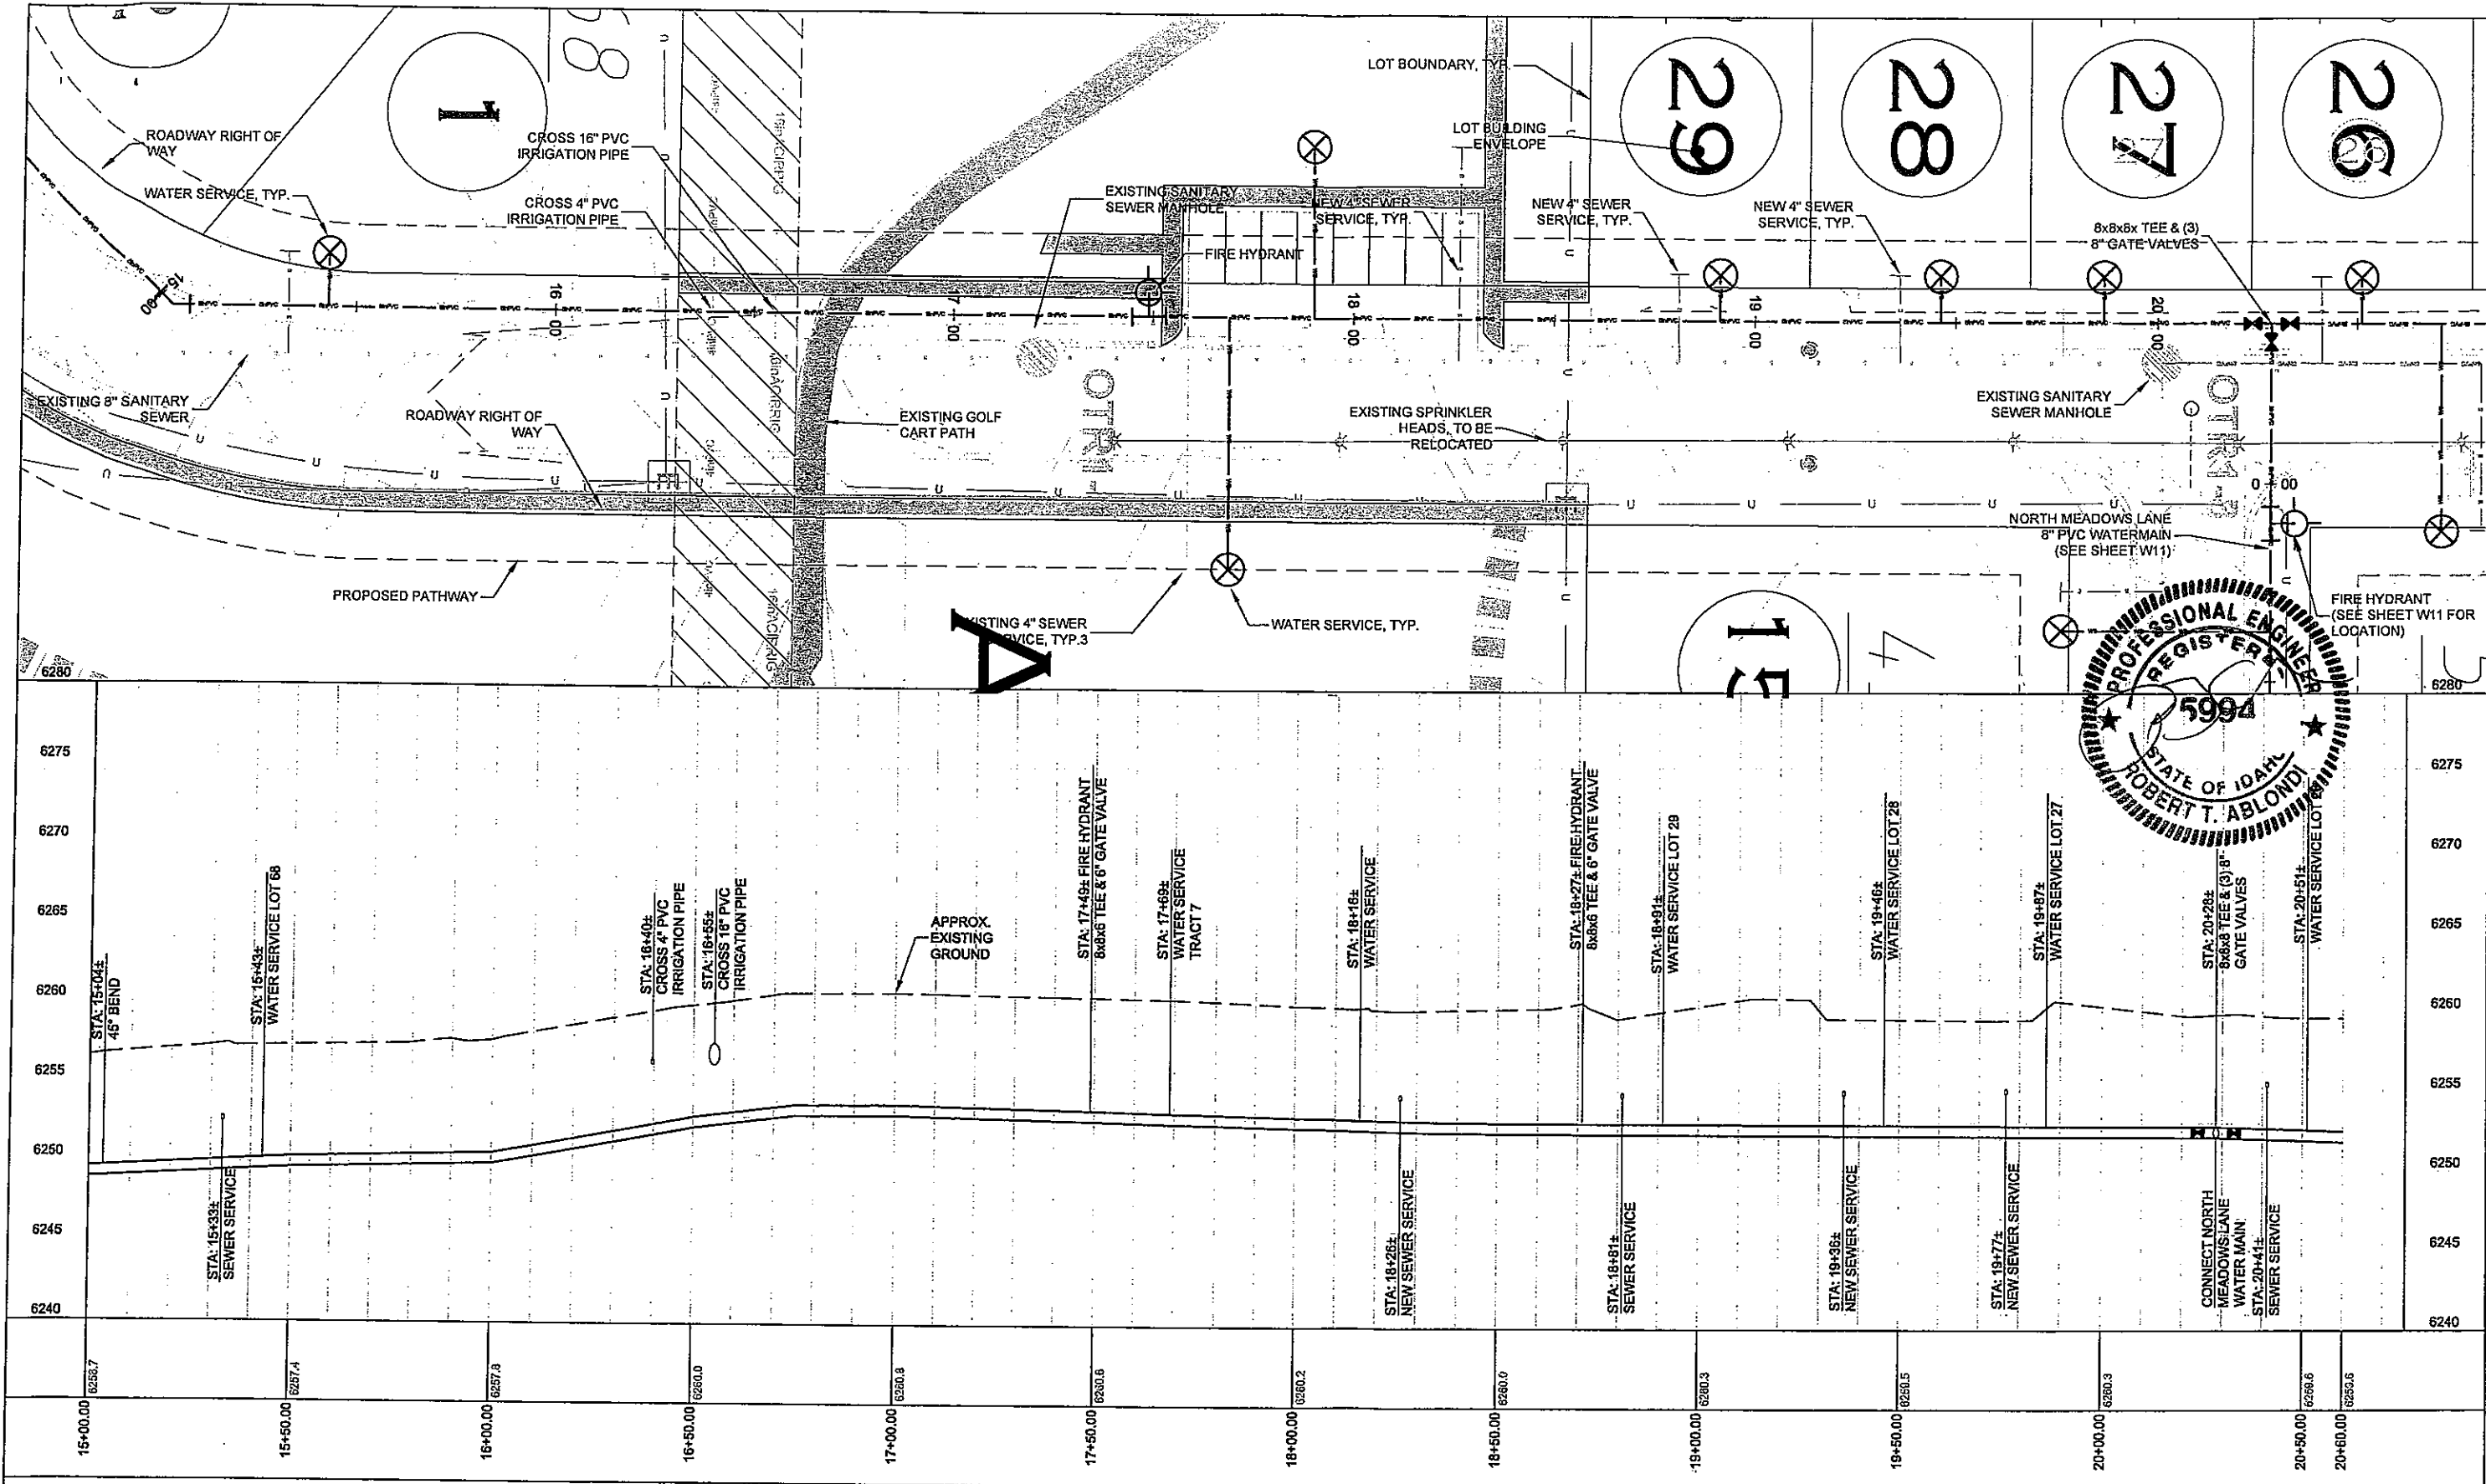

NOTES - THIS SHEET

GENERAL NOTES



SCALE: 1" = 20' HORIZ.
1" = 5' VERT.

PROJECT TITLE:
RECORD DRAWINGS
TETON SPRINGS

PROJECT NUMBER:
04-002
1.40


DRAWING NUMBER:
ASBW-58

DRAWING TITLE:
ASBULT WATERMAIN
WATER MAIN 'W1'
MOUNTAIN MEADOWS LANE

PROFESSIONAL ENGINEER
5994
STATE OF IDAHO
ROBERT T. ABLONDI

PREPARED BY: JWC
DATE: 10/07
REV. DATE:

RENDEZVOUS ENGINEERING, P.C.
P.O. BOX 4858 JACKSON, WYOMING 83001
25 SOUTH GROS VENTRE STREET
PHONE - 307.733.5252 FAX - 307.733.2334

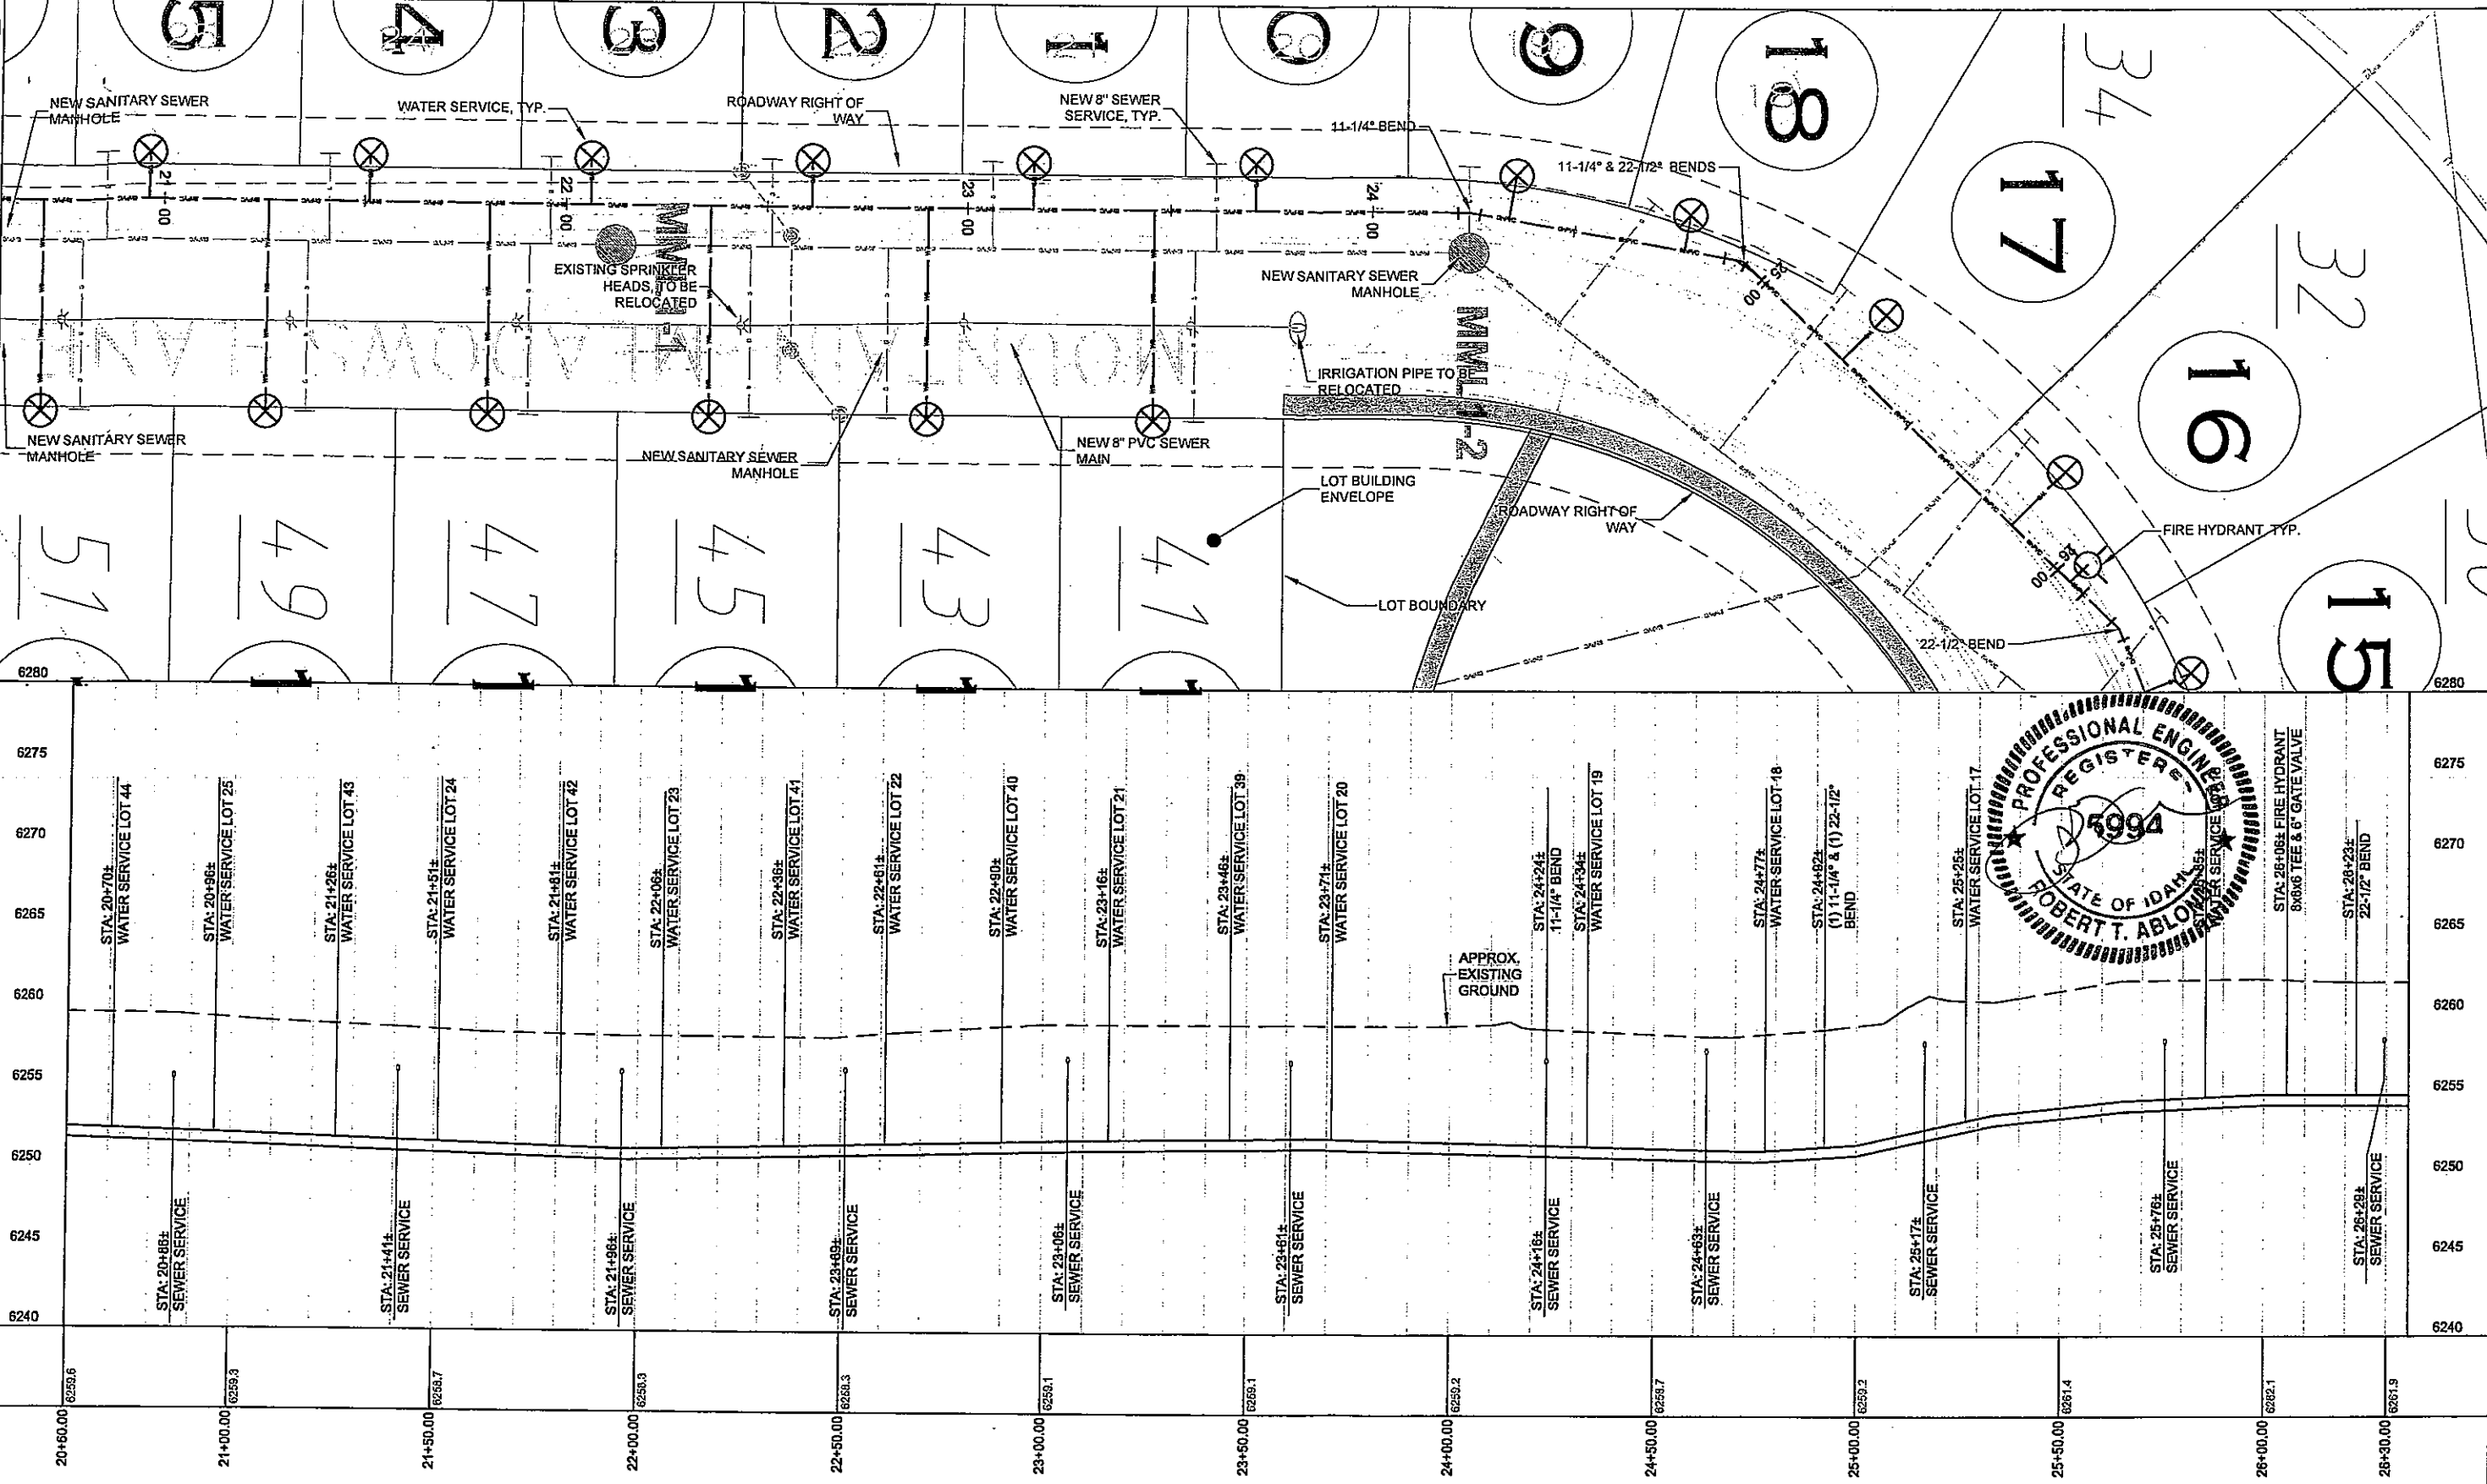

NOTES - THIS SHEET

GENERAL NOTES

SCALE: 1" = 20' HORIZ.
1" = 5' VERT.



Prepared By: JKC
Date: 1/30/07
Rev. Date:

RENDEZVOUS ENGINEERING, P.C.
P.O. BOX 4853 JACKSON, WYOMING 83001
25 SOUTH GROS VENTRE STREET
PHONE - 307.733.5252 FAX - 307.733.2334

DRAWING TITLE:
ASBUILT WATER MAIN
WATER MAIN "W1"
MOUNTAIN MEADOWS LANE


PROJECT TITLE:
RECORD DRAWINGS
TETON SPRINGS

PROJECT NUMBER:
04-002
1.40
DRAWING NUMBER:
ASBW-59

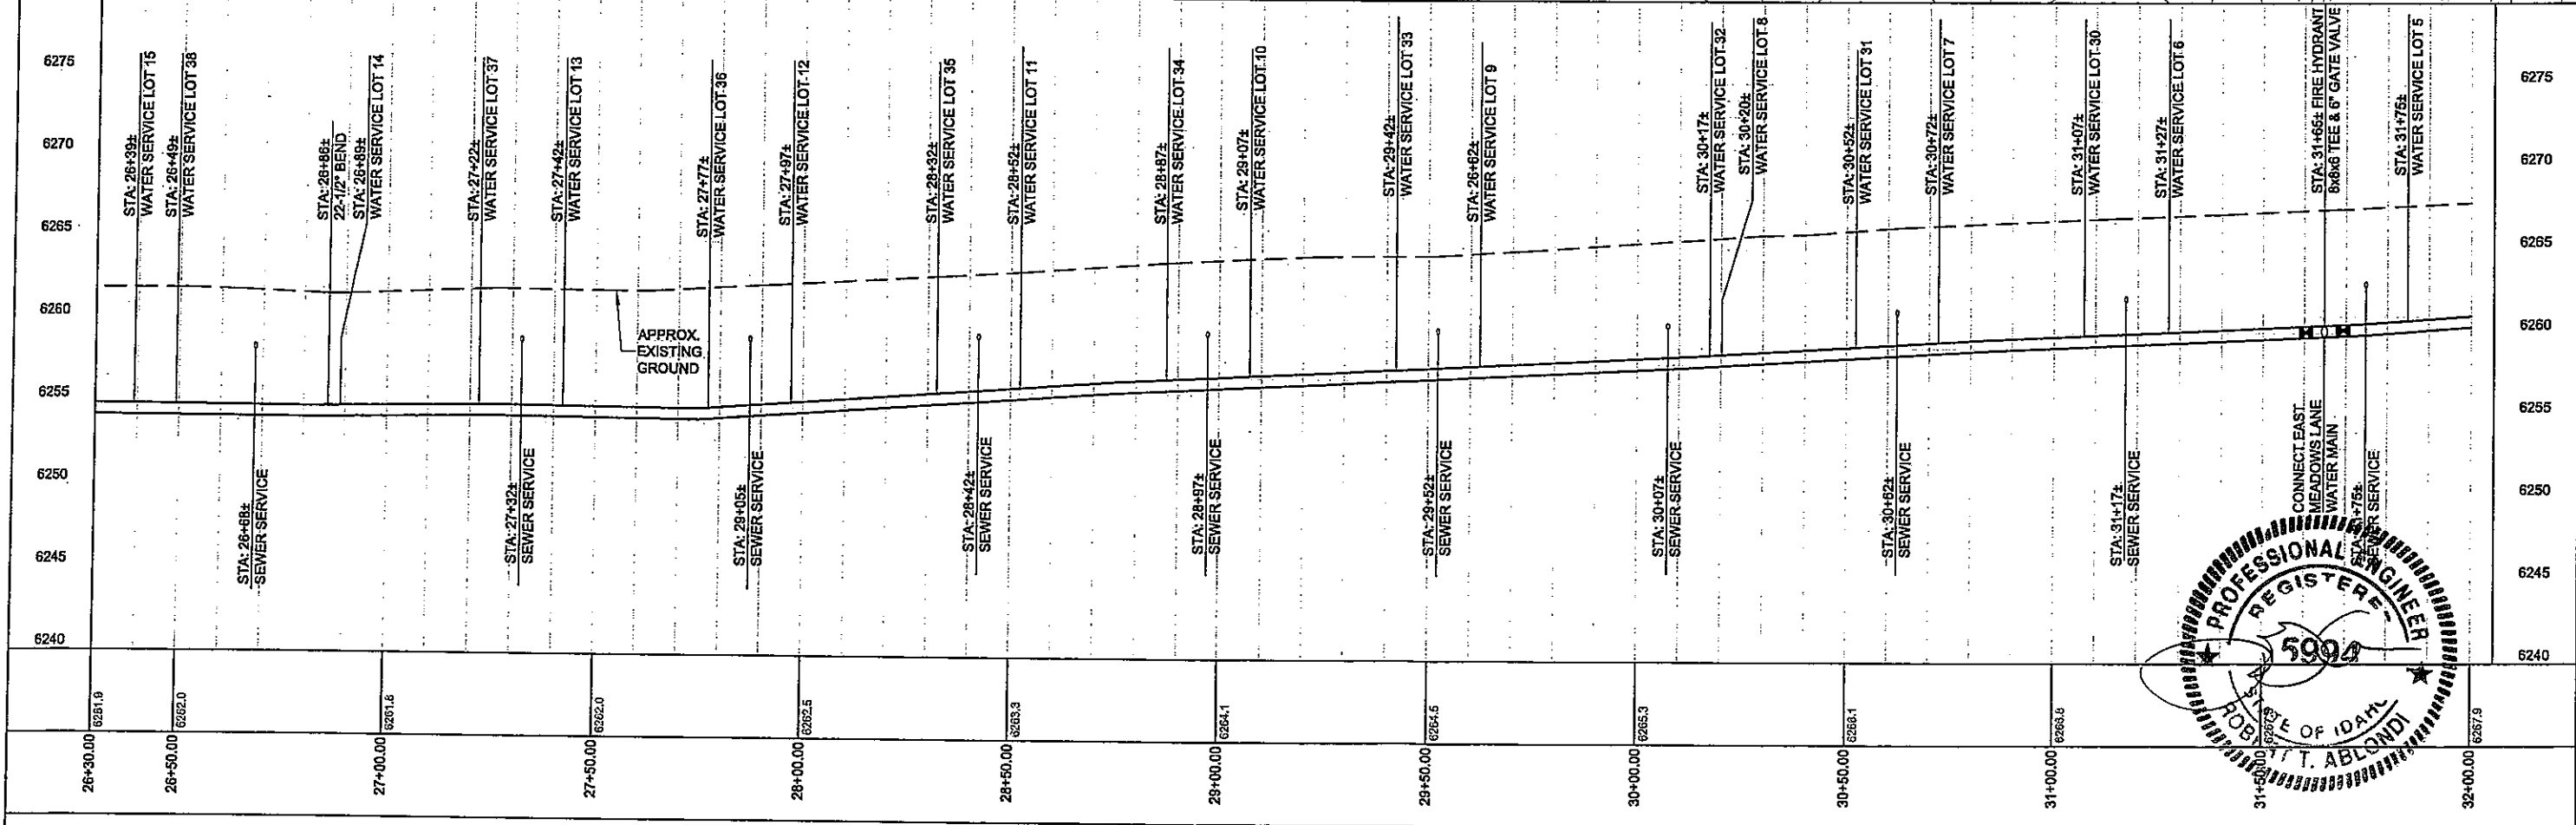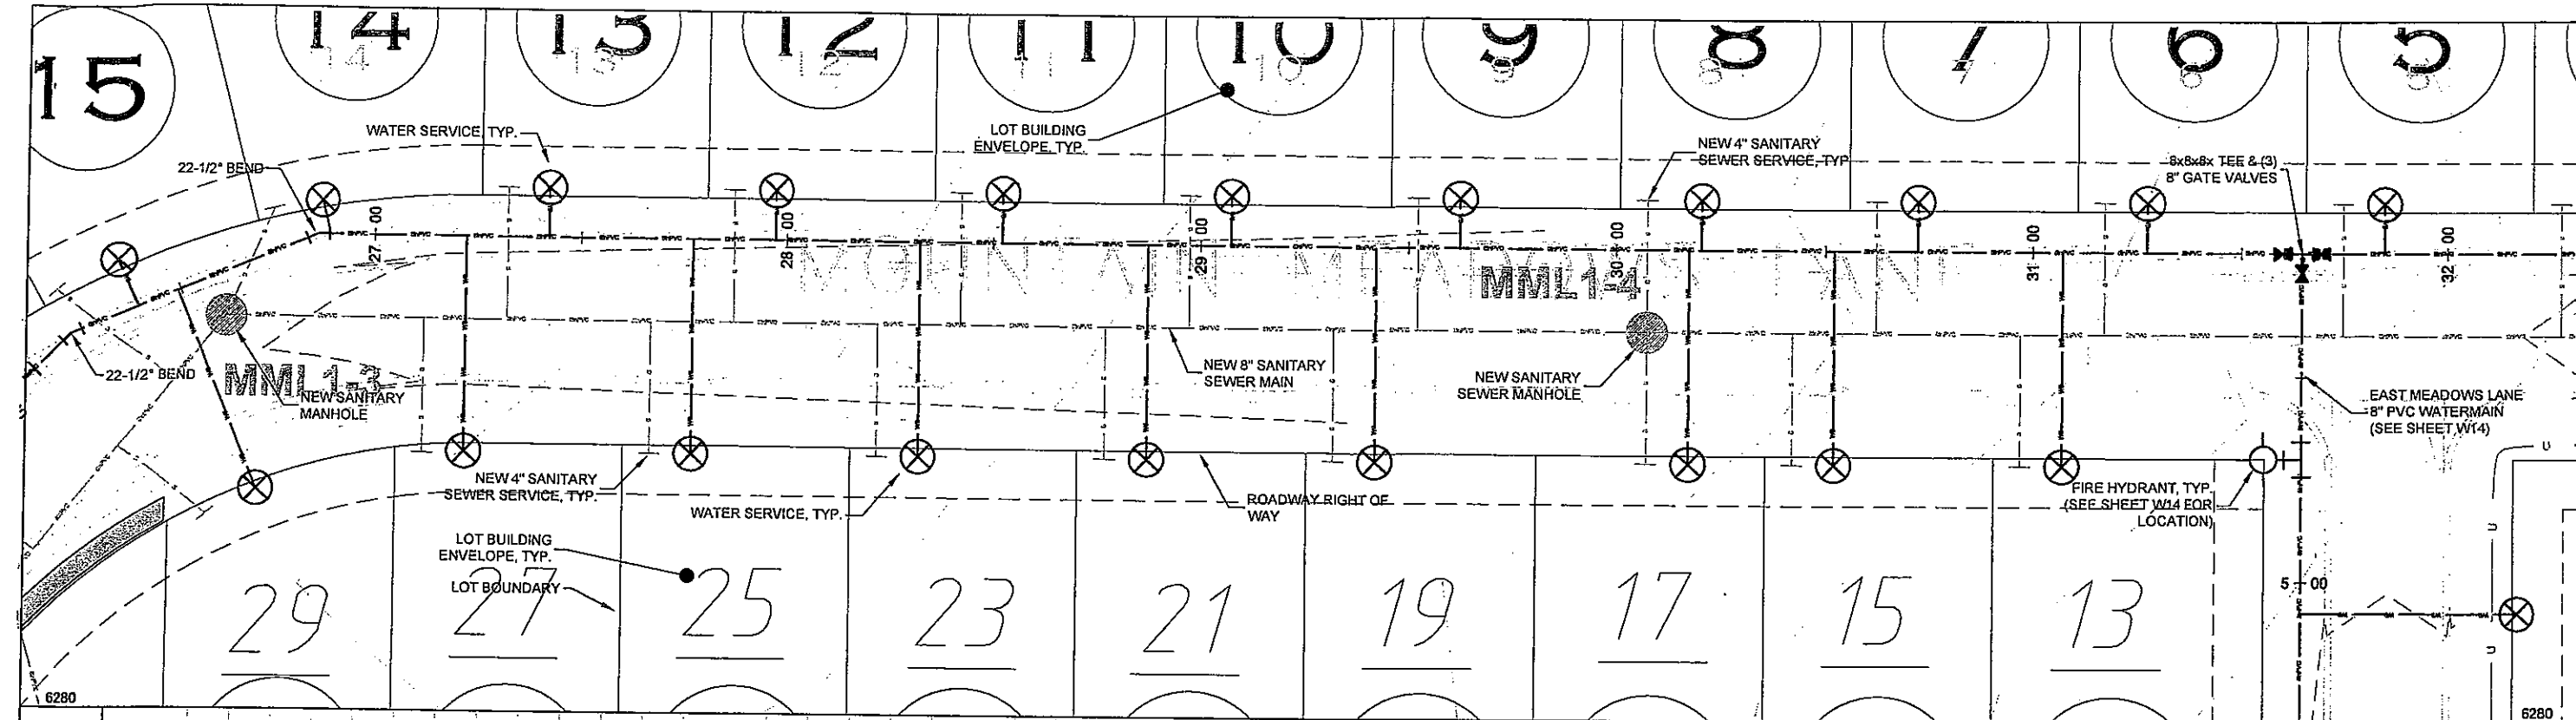


NOTES - THIS SHEET

GENERAL NOTES

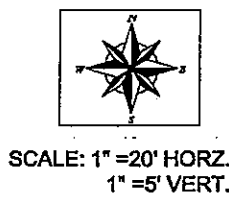

PROJECT TITLE: RECORD DRAWINGS TETON SPRINGS		PROJECT NUMBER: 04-002 1.40	DRAWING NUMBER: ASBW-60
DRAWING TITLE: ASBUILT WATERMAIN WATER MAIN 'W1' MOUNTAIN MEADOWS LANE			
PROFESSIONAL ENGINEER REGISTERED ROBERT T. ABLONDI 5904			
PREPARED BY: JWC Date: 10/07 Rev. Date:			
RENDEZVOUS ENGINEERING, P.C. P.O. BOX 4858 JACKSON, WYOMING 83001 25 SOUTH GROSVENTRE STREET PHONE - 307.733.5252 FAX - 307.733.2334			

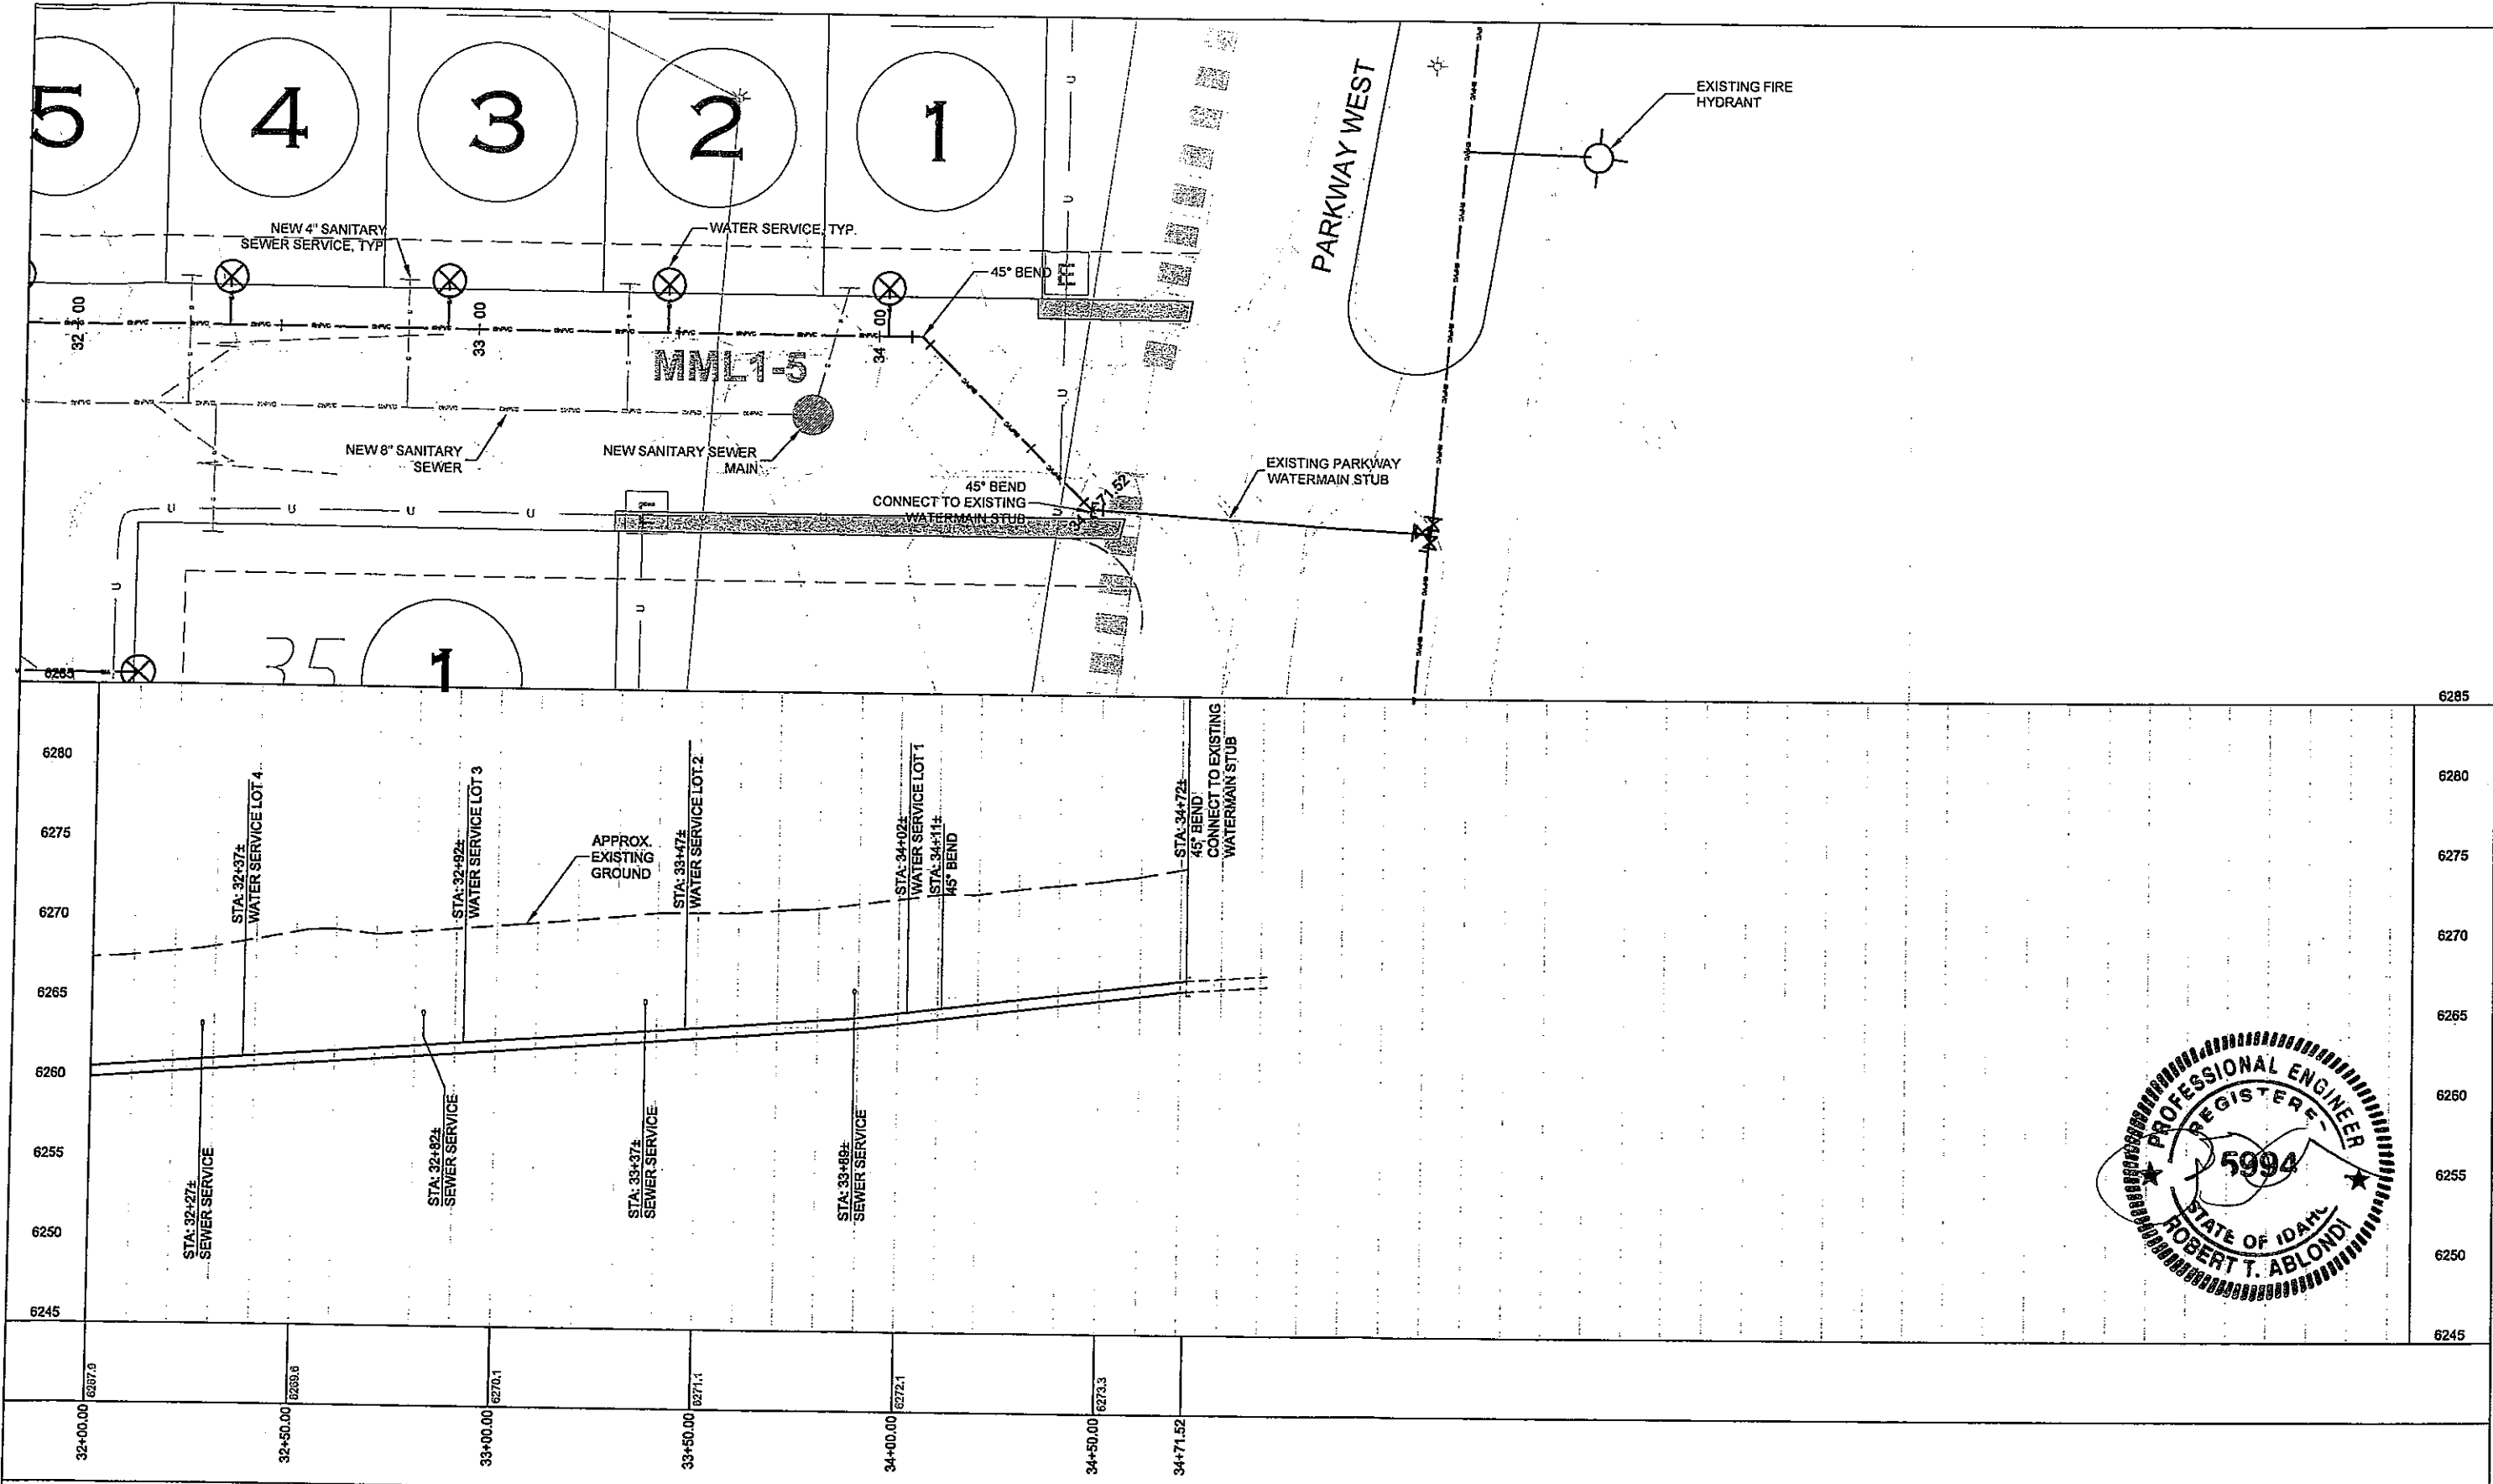



NOTES - THIS SHEET

GENERAL NOTES



SCALE: 1" = 20' HORZ.
1" = 5' VERT.

PROJECT TITLE: RECORD DRAWINGS TETON SPRINGS		DRAWING TITLE: ASBUILT WATERMAIN WATER MAIN "W1" MOUNTAIN MEADOWS LANE			RENDEZVOUS ENGINEERING, P.C. P.O. BOX 4858 JACKSON, WYOMING 83001 25 SOUTH GROS VENTRE STREET PHONE - 307.733.5252 FAX - 307.733.2334	Prepared By: JJC Date: 10/07 Rev. Date:
PROJECT NUMBER: 04-002 1.40		PROJECT TITLE: RECORD DRAWINGS TETON SPRINGS				
DRAWING NUMBER: ASBW-61						

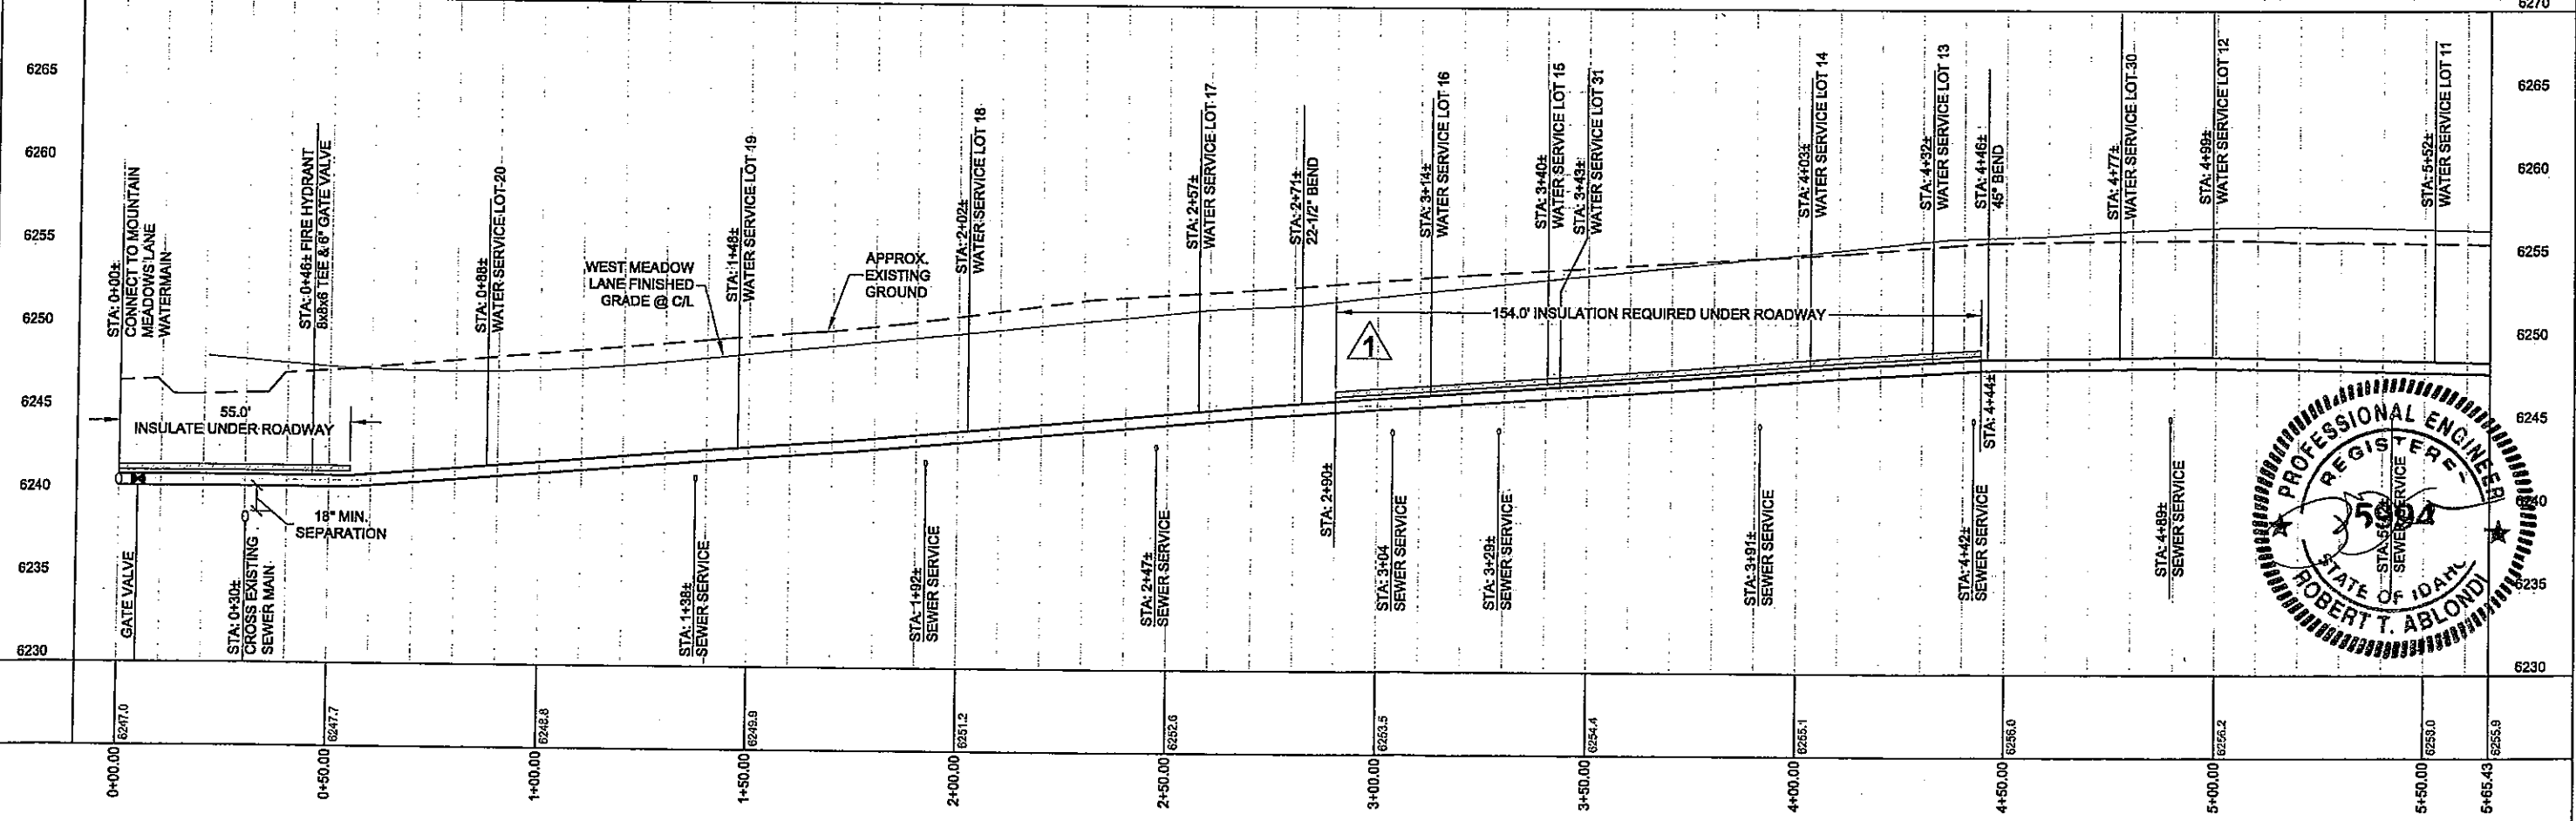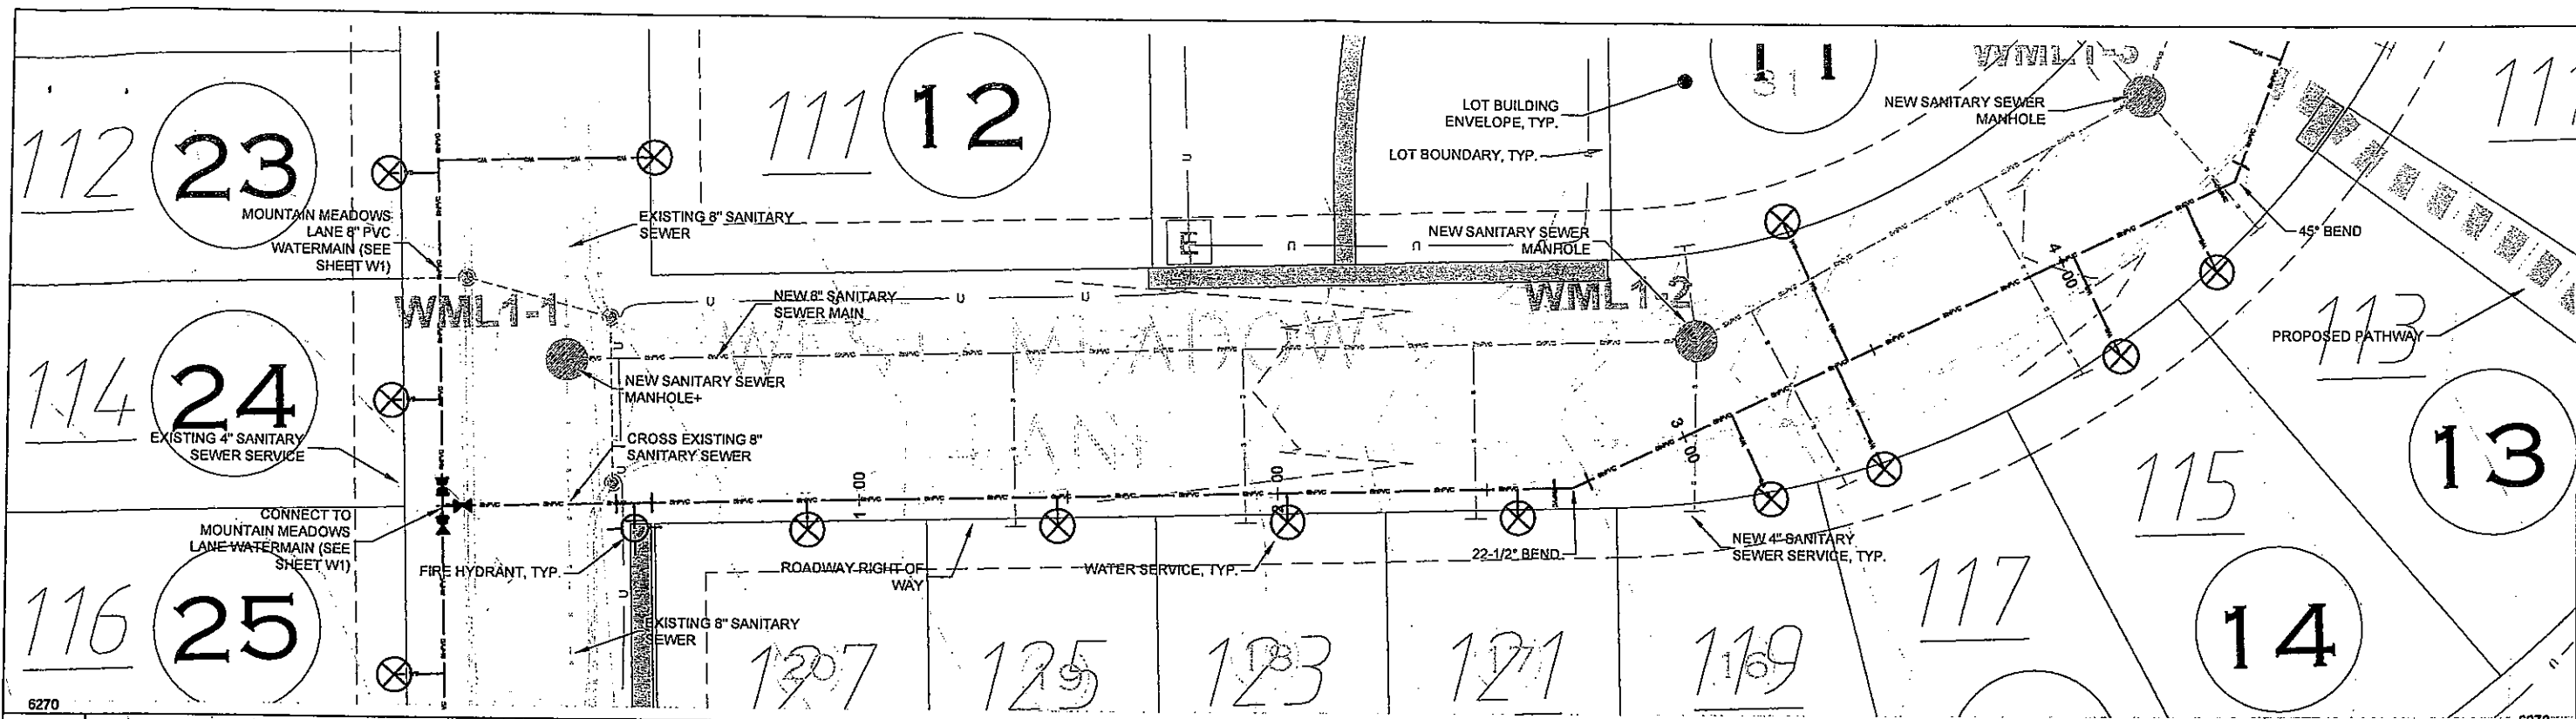


NOTES - THIS SHEET

GENERAL NOTES



SCALE: 1" = 20' HORZ.
1" = 5' VERT.

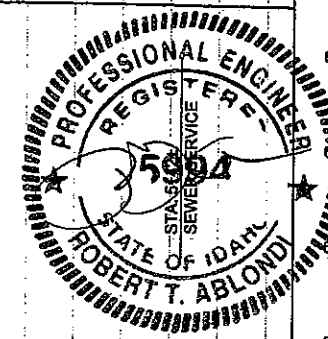

Prepared By: JJC
Date: 10/07
Rev. Date:


RENDEZVOUS ENGINEERING, P.C.
P.O. BOX 4858 JACKSON, WYOMING 83001
28 SOUTH GROS VENTRE STREET
PHONE - 307.733.2582 FAX - 307.733.2334

DRAWING TITLE:
ASBULT WATERMAIN
WATER MAIN 'W2'
WEST MEADOWS LANE

PROJECT TITLE:
RECORD DRAWINGS
TETON SPRINGS

PROJECT NUMBER:
04-002
1.40

DRAWING NUMBER:
ASBW-62

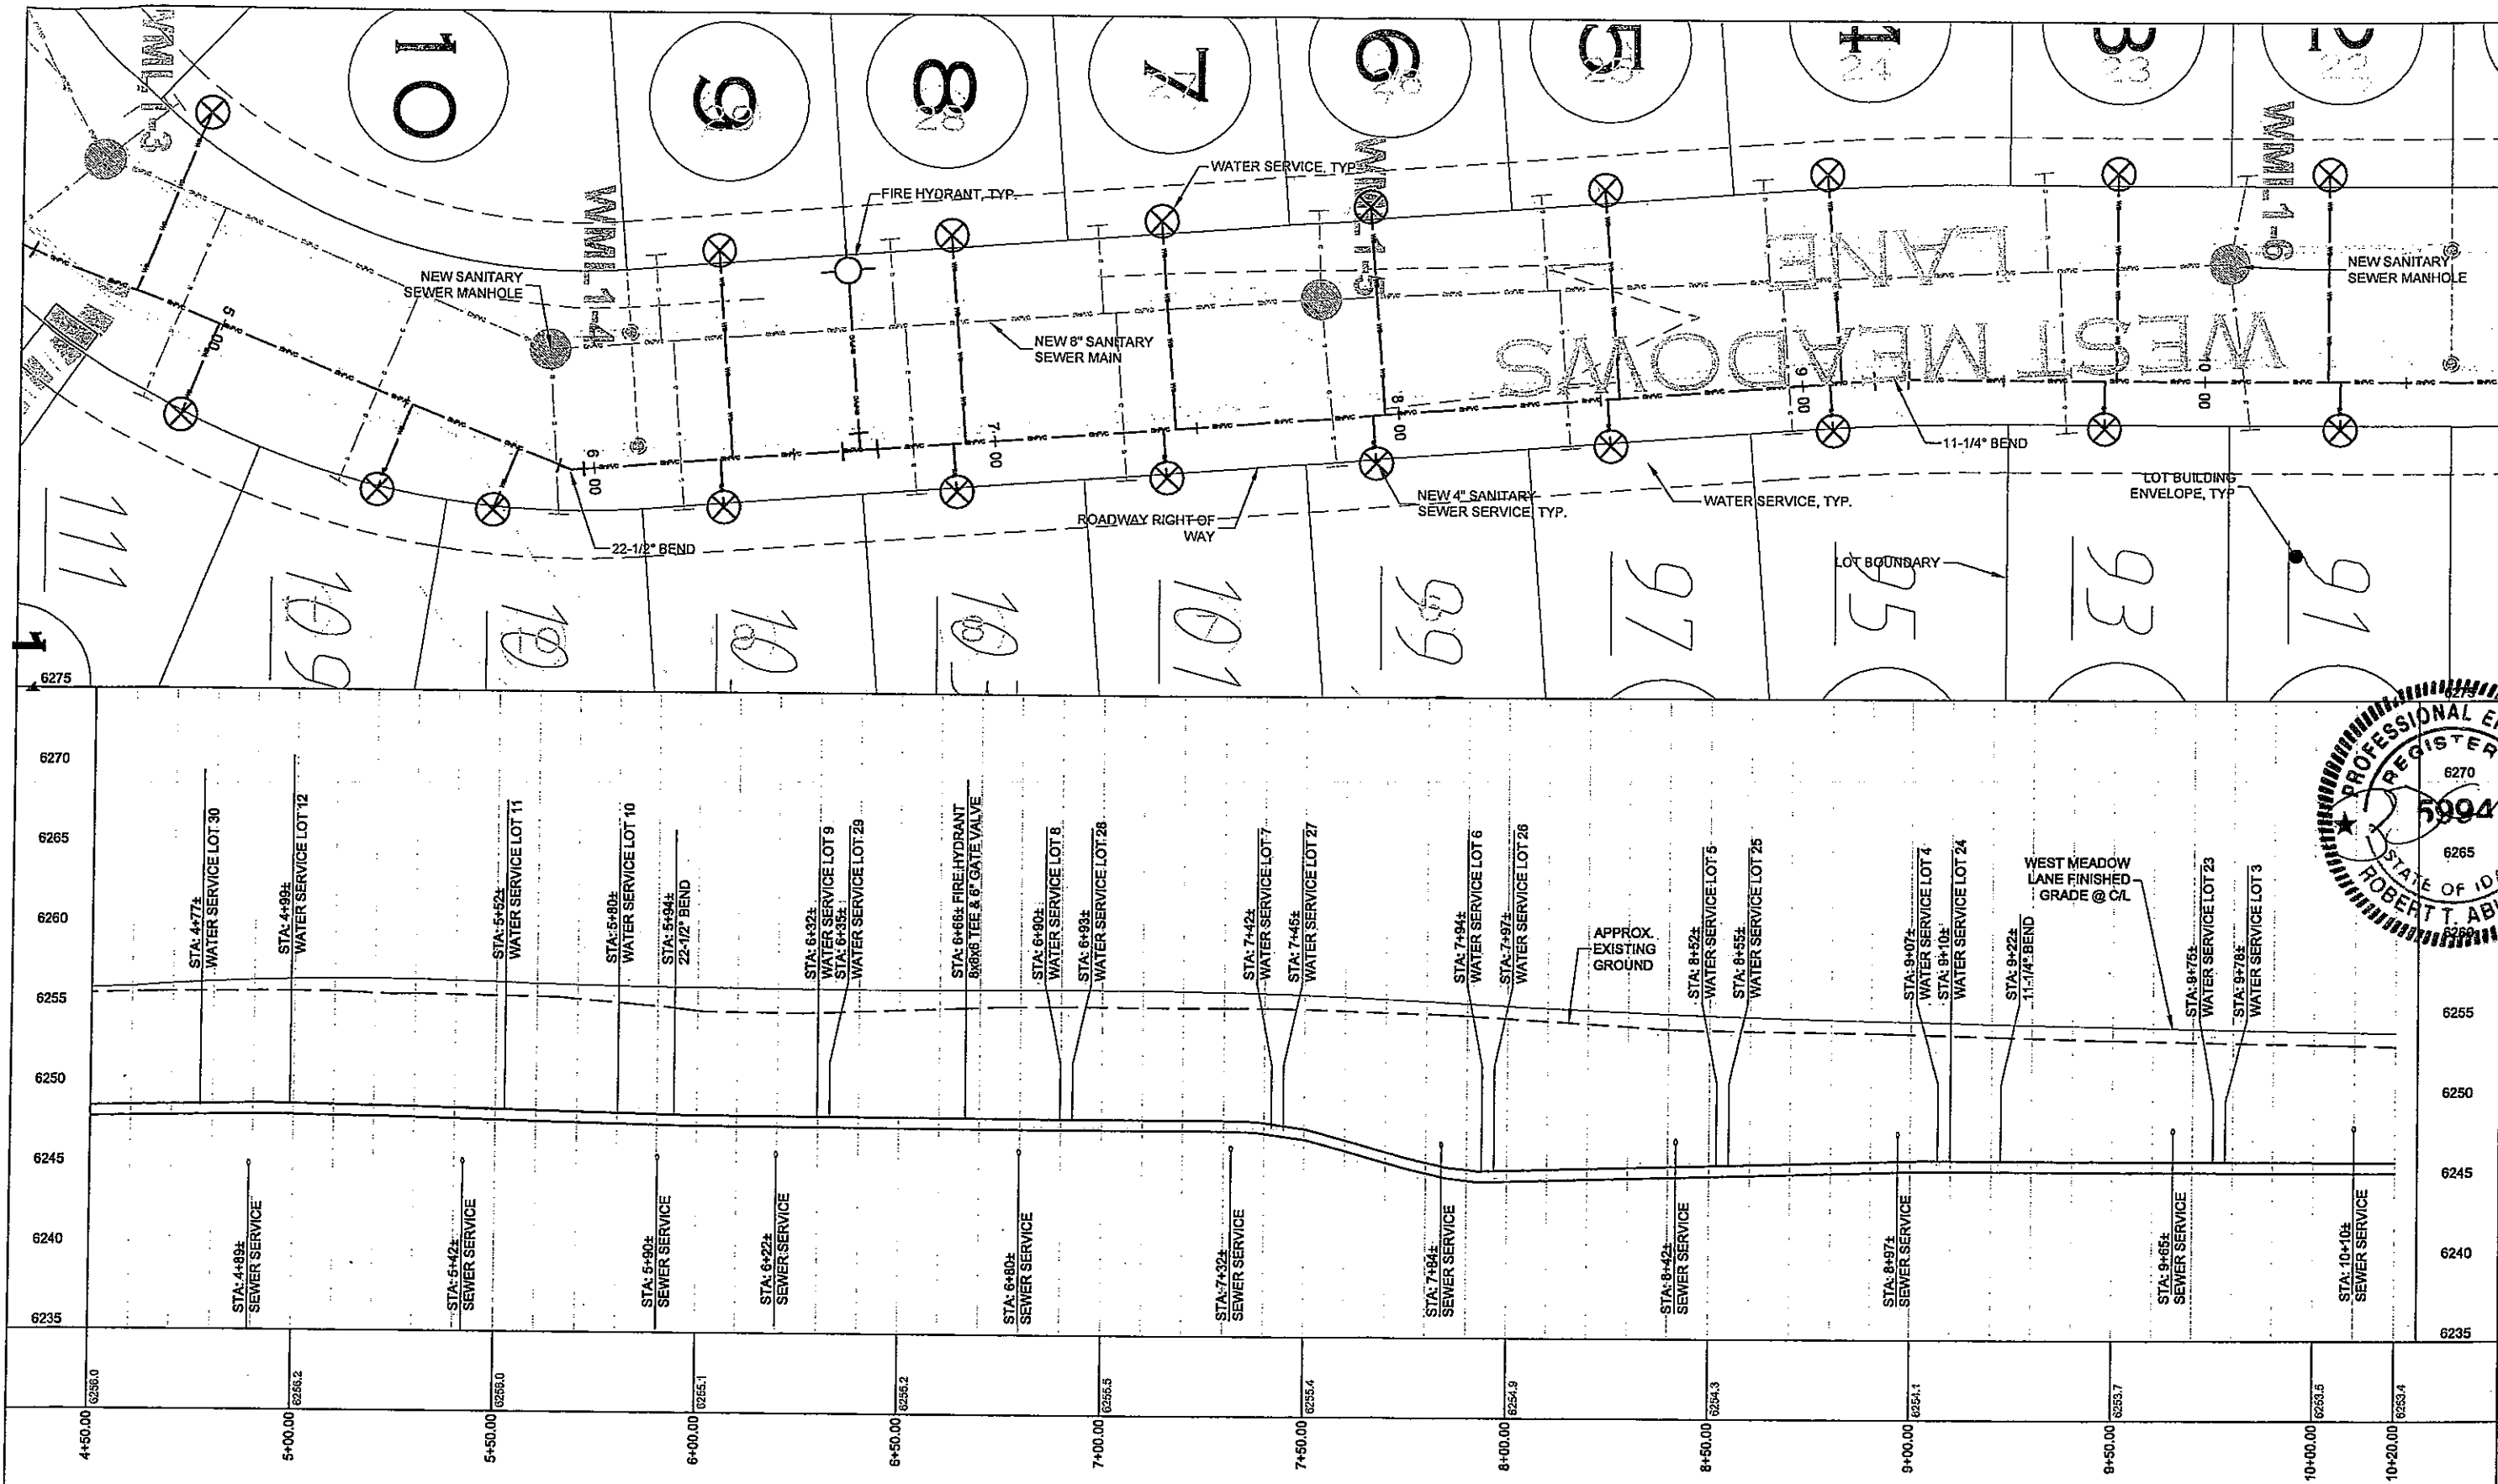


NOTES - THIS SHEET

GENERAL NOTES



SCALE: 1" = 20' HORZ.
1" = 5' VERT.

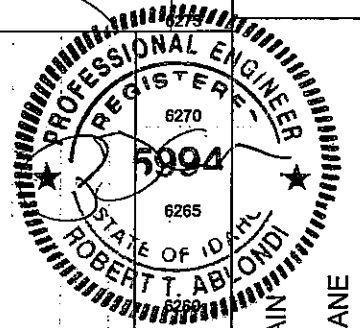


PROJECT TITLE:
RECORD DRAWINGS
TETON SPRINGS

DRAWING TITLE:
ASBUILT WATERMAIN
WATER MAIN "W2"
WEST MEADOWS LANE

PROJECT NUMBER:
04-002
1.40
DRAWING NUMBER:
ASBW-63


RENDEZVOUS ENGINEERING, P.C.
P.O. BOX 4858 JACKSON, WYOMING 83001
25 SOUTH GROES VENTURE STREET
PHONE - 307.733.5252 FAX - 307.733.2334

Prepared By: JWC
Date: 1007
Rev. Date:

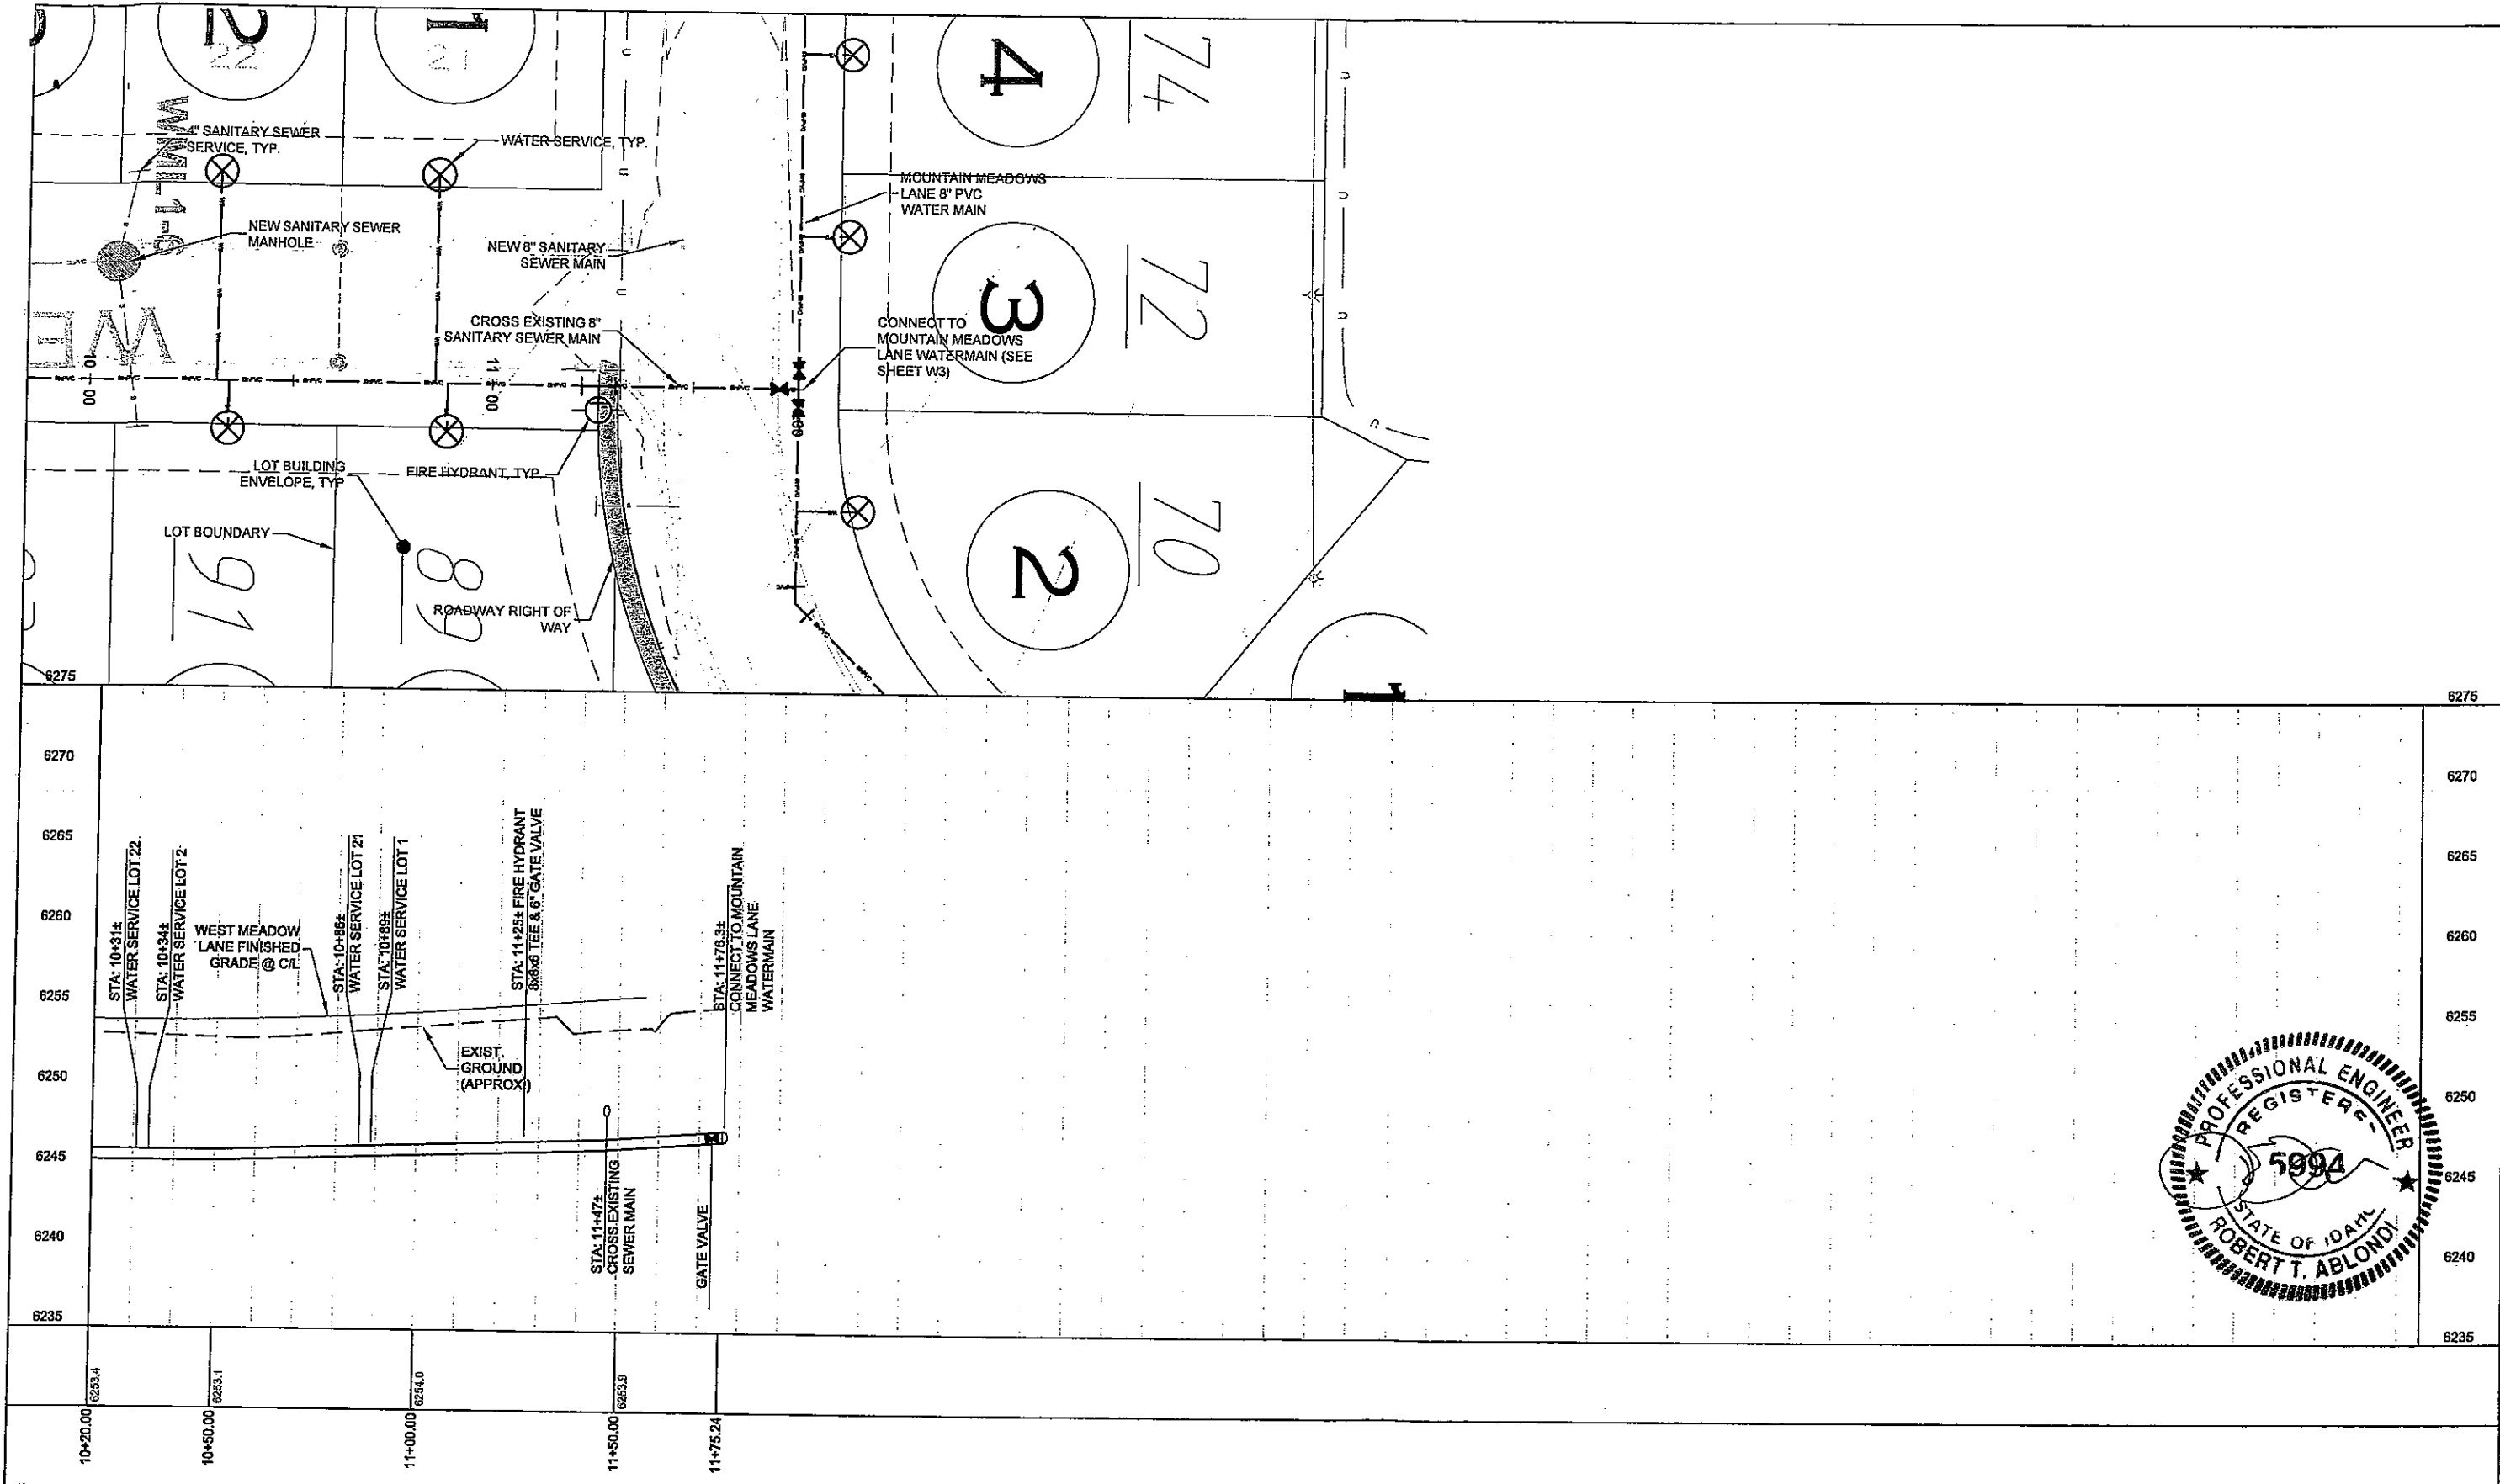

NOTES - THIS SHEET		GENERAL NOTES		 SCALE: 1" = 20' HORZ. 1" = 5' VERT.

RENDZVOUS ENGINEERING, P.C. P.O. BOX 4858 JACKSON, WYOMING 83001 PHONE - 307.733.5252 FAX - 307.733.2334		Prepared By: JKC Date: 10/07 Rev. Date:
DRAWING TITLE: ASBUILT WATERMAIN WATER MAIN 'W2' WEST MEADOWS LANE		PROJECT TITLE: RECORD DRAWINGS TETON SPRINGS
PROJECT NUMBER: 04-002 1.40		
DRAWING NUMBER: ASBW-64		

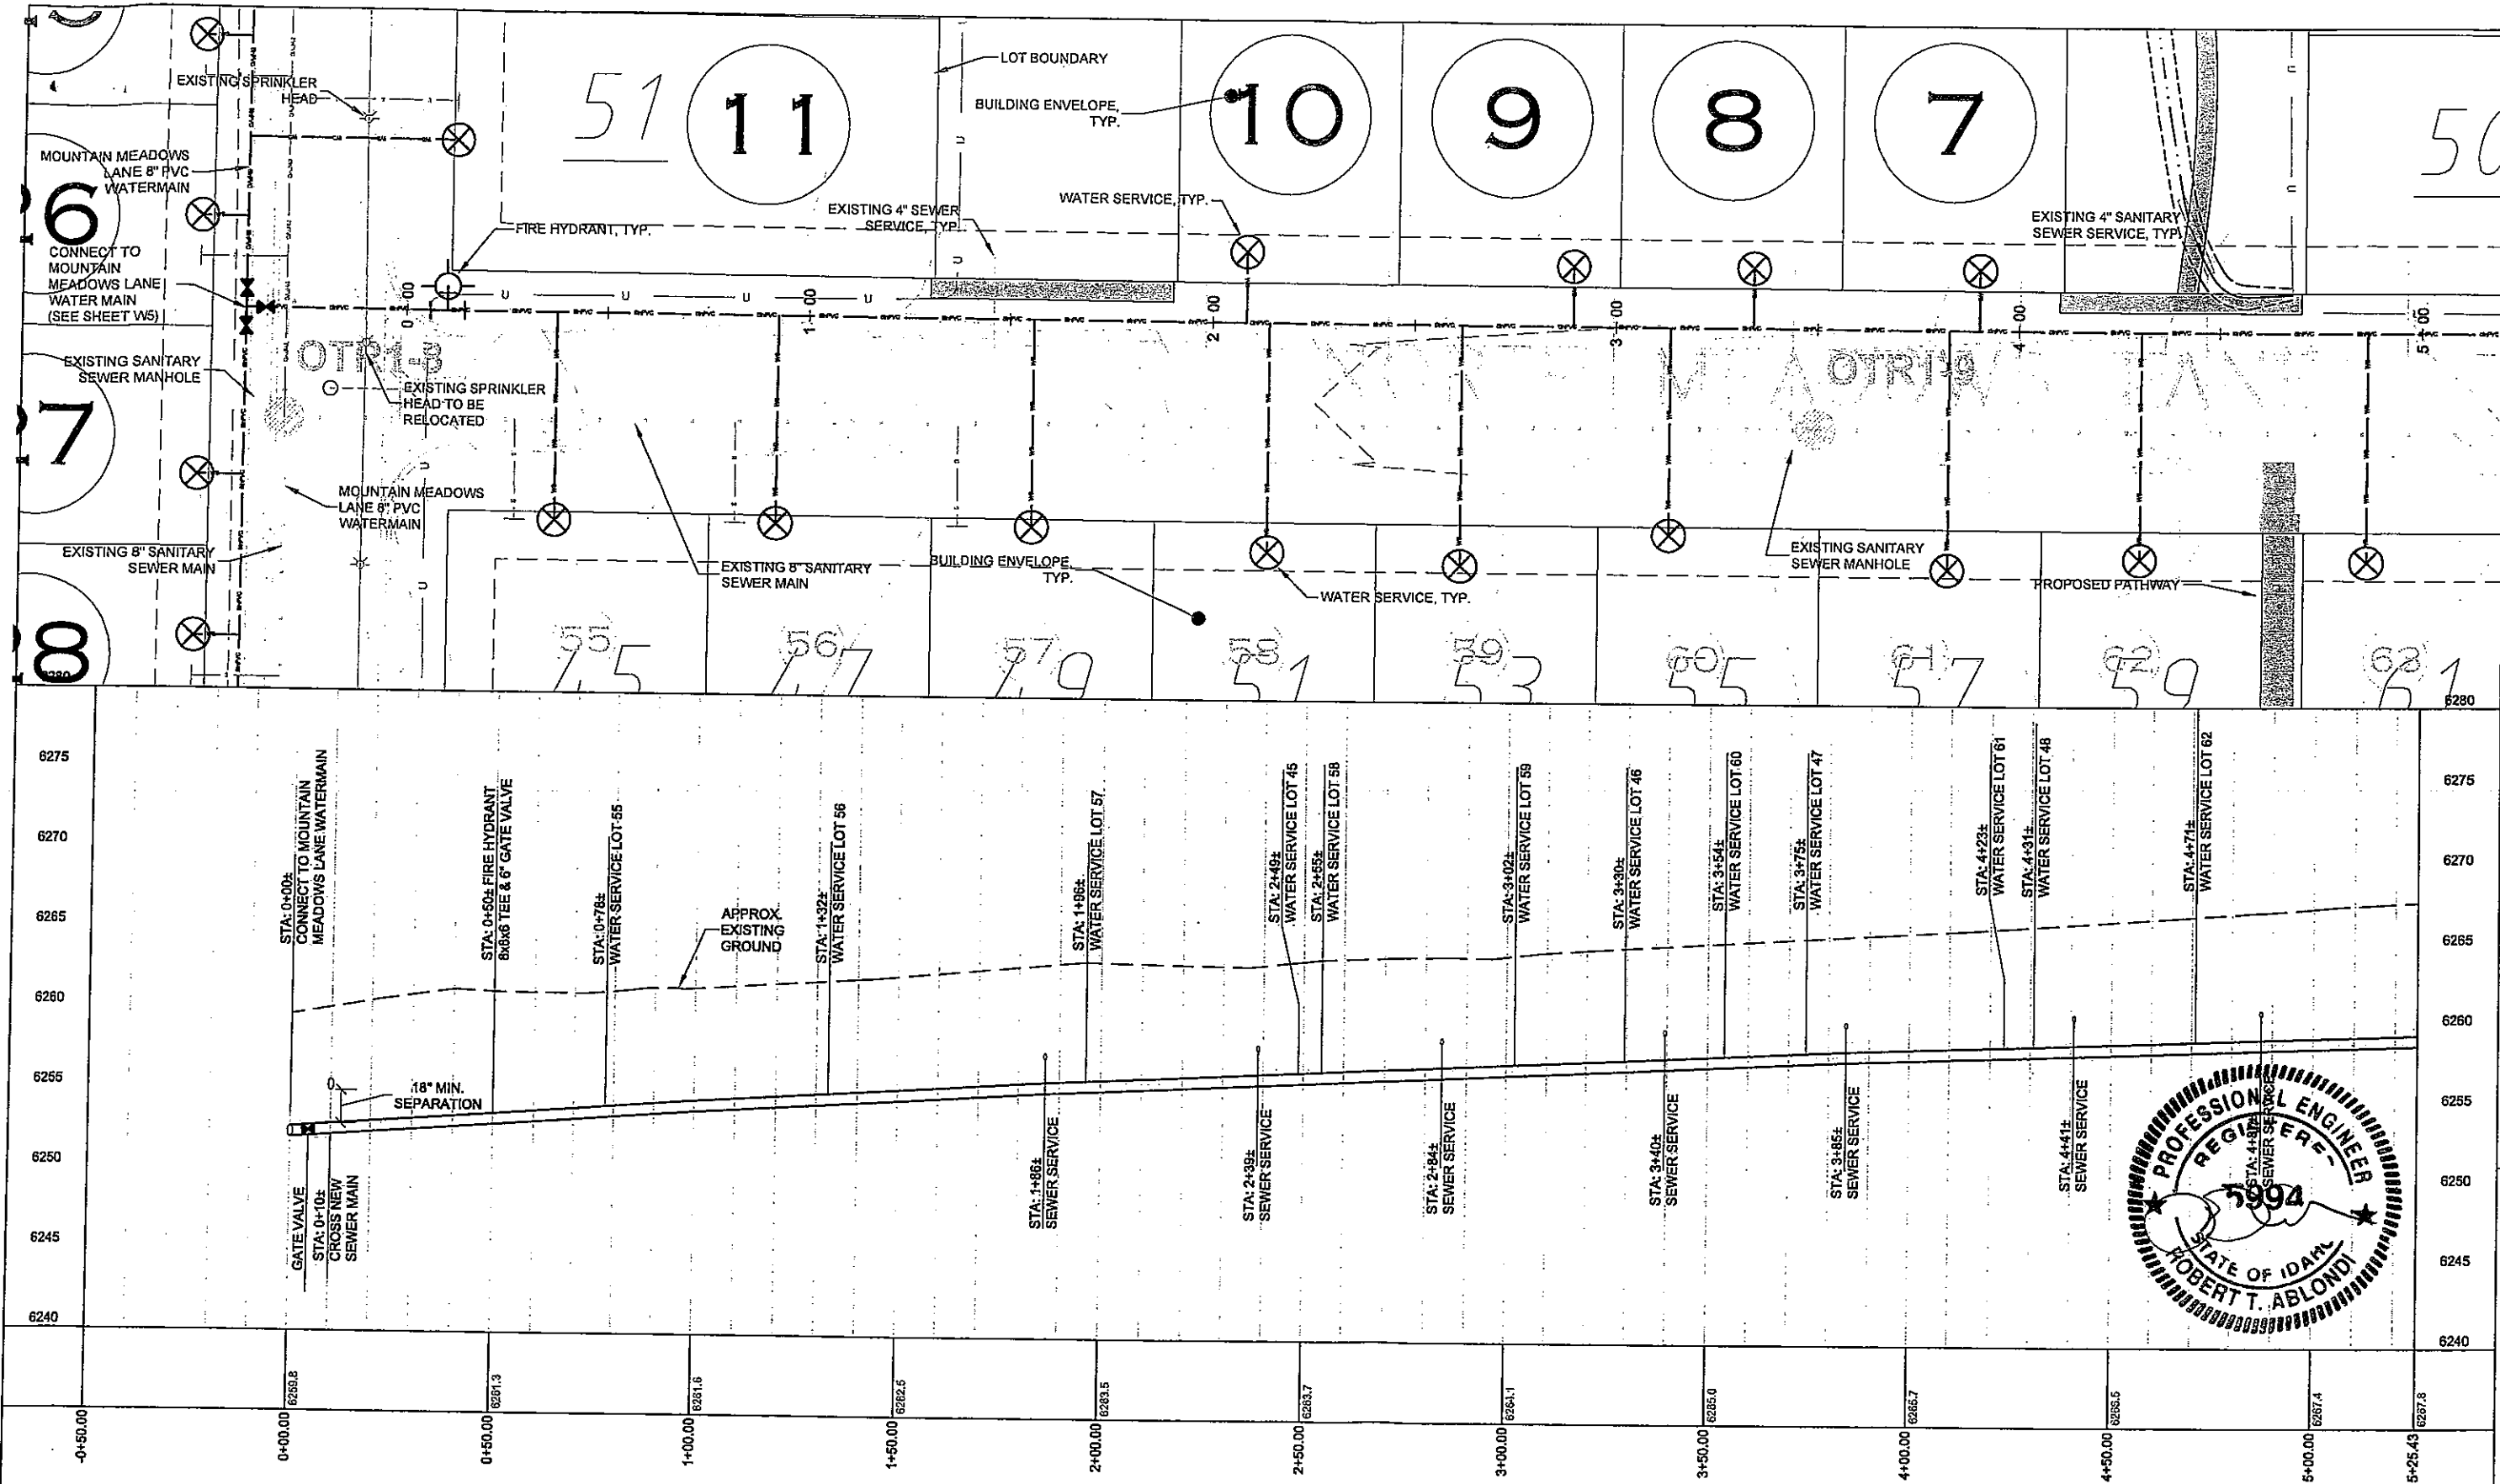

NOTES - THIS SHEET

GENERAL NOTES



SCALE: 1" = 20' HORZ.
1" = 5' VERT.

Prepared By: JKC
Date: 10/07
Rev. Date:


RENDEZVOUS ENGINEERING, P.C.
P.O. BOX 4855 JACKSON, WYOMING 83001
25 SOUTH GROSVENTRE STREET
PHONE - 307.733.5252 FAX - 307.733.2334



DRAWING TITLE:
**ASBUILT WATERMAIN
WATER MAIN 'W3'
NORTH MEADOWS LANE**

PROJECT TITLE:
**RECORD DRAWINGS
TETON SPRINGS**

PROJECT NUMBER:
04-002
1.40


DRAWING NUMBER:
ASBW-65

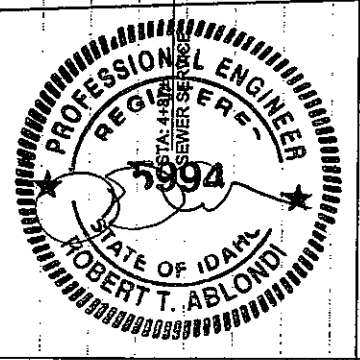

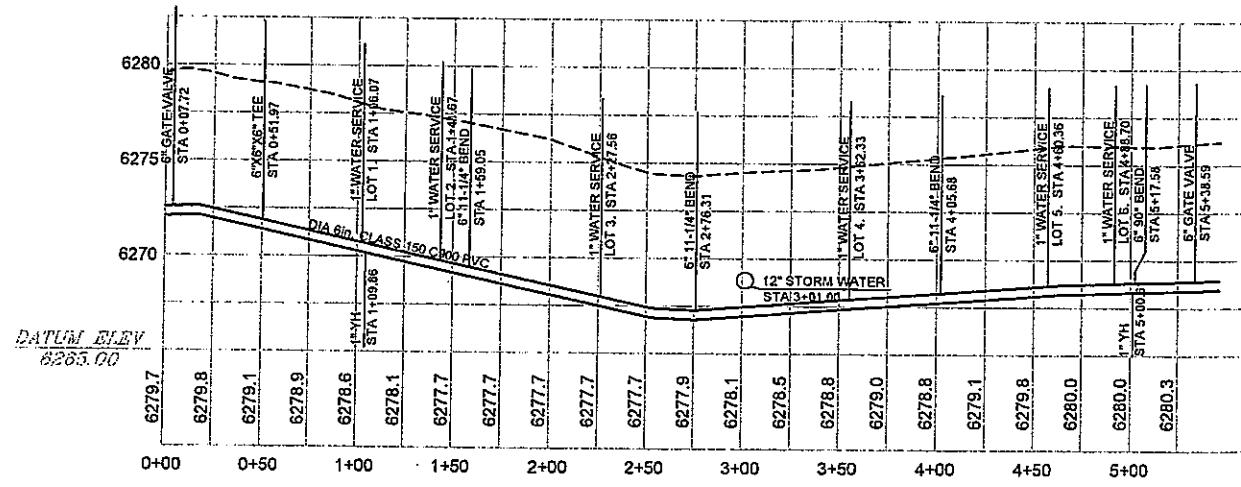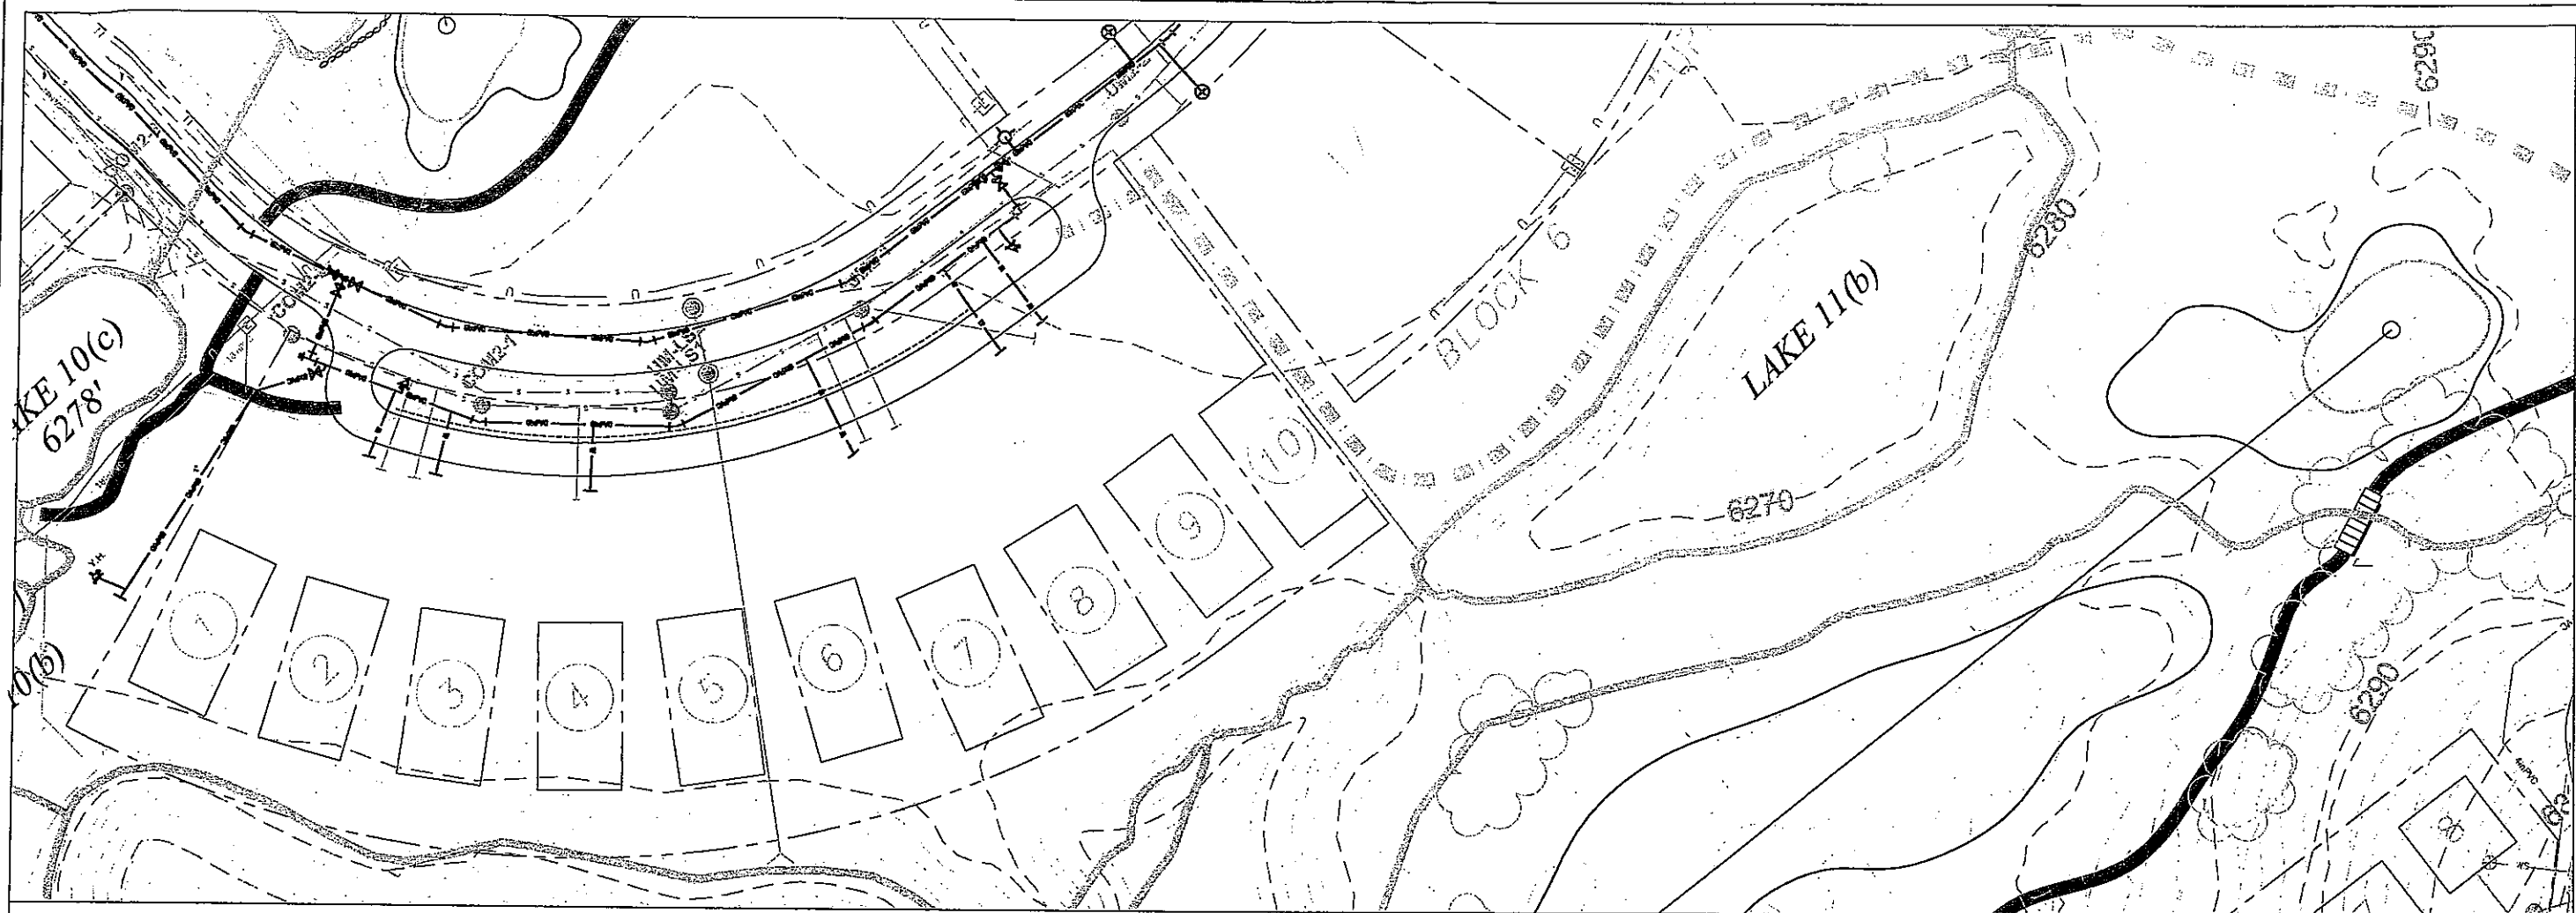

NOTES - THIS SHEET

GENERAL NOTES

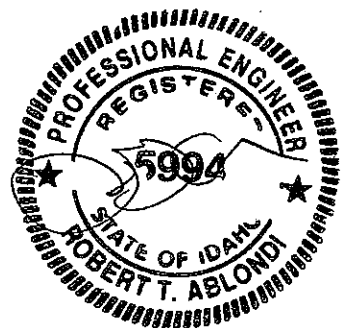

Horizontal Scale: 1" = 50'
Vertical Scale: 1" = 5'

PROJECT TITLE:
RECORD DRAWINGS
TETON SPRINGS



AS BUILT WATER
WATER MAIN 'Z'
ENCLAVE LANE

PREPARED BY: JAC
DATE: 10/27
REV. DATE:
REV. INFO:
DIBL
P&H

RENDEZVOUS ENGINEERING, P.C.
P.O. BOX 4858 JACKSON, WYOMING 83001
25 SOUTH GROS VENTRE STREET
PHONE - 307.733.5252 FAX - 307.733.2334

PROJECT NUMBER:
00-023

DRAWING NUMBER:
ASBW69

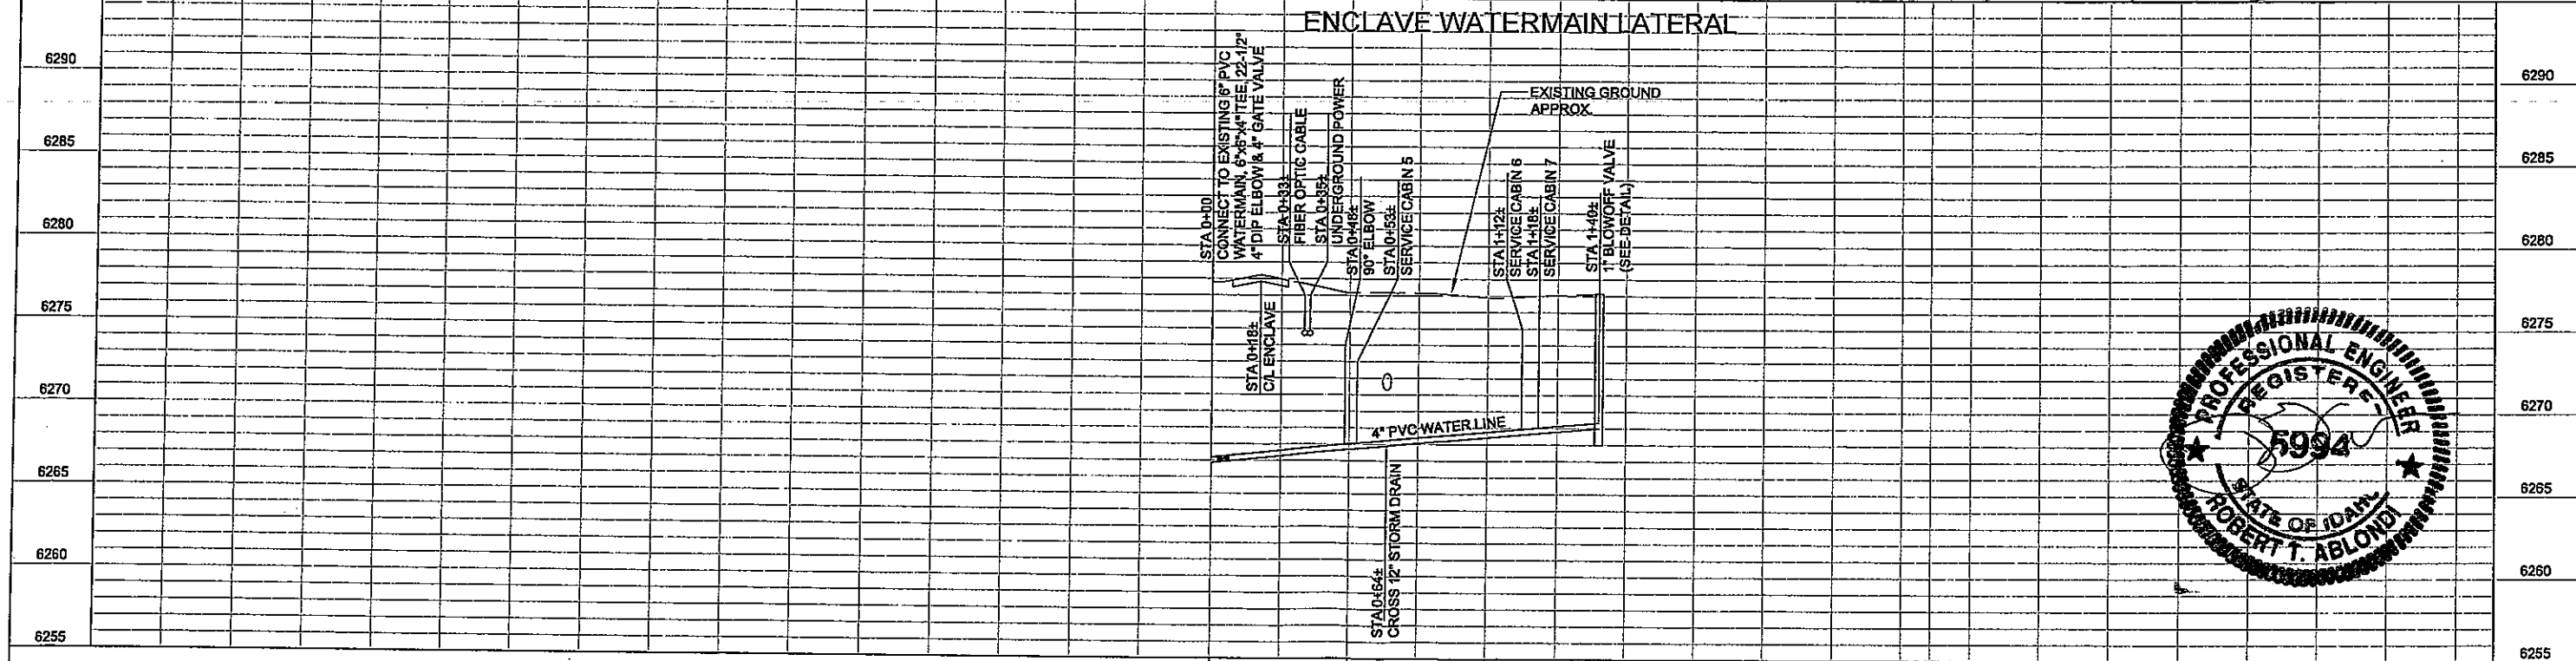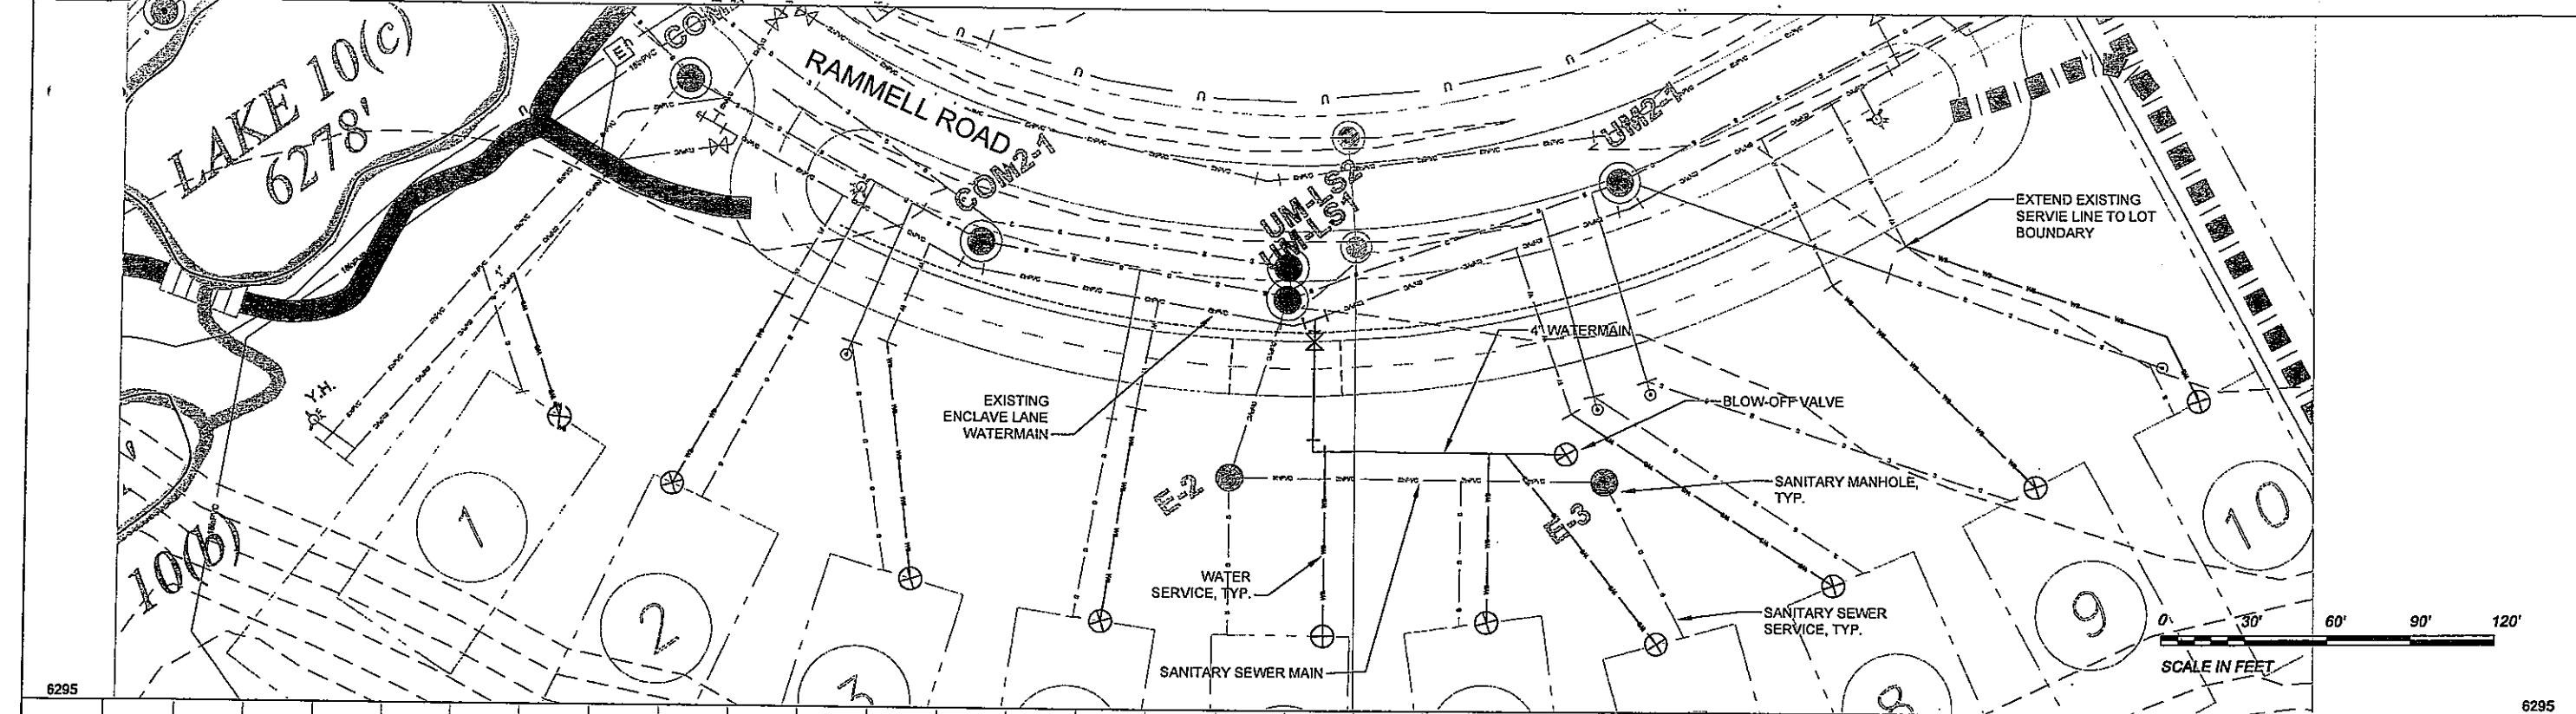

0+00.00	6277.5
0+50.00	6277.4
1+00.00	6277.1
1+47.59	6277.1

NOTE: AS BUILT INFORMATION ONLY FOR SEWER.

NOTES - THIS SHEET

GENERAL NOTES

SCALE: 1" = 30' HORZ.
1" = 5' VERT.

Prepared By: JCC
Date: 1/20/07
Rev. Date:


RENDEZVOUS ENGINEERING, P.C.
P.O. BOX 4658 JACKSON, WYOMING 83001
25 SOUTH GROES VENTURE STREET
PHONE - 307.733.5552 FAX - 307.733.2334


DRAWING TITLE:
ASBUILT WATERMAIN
WATER MAIN 'X'
ENCLAVE LANE

PROJECT TITLE:
RECORD DRAWINGS
TETON SPRINGS

PROJECT NUMBER:
00-023

DRAWING NUMBER:
ASBW70

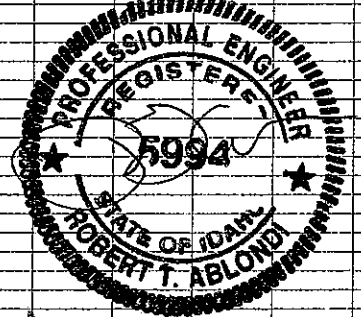

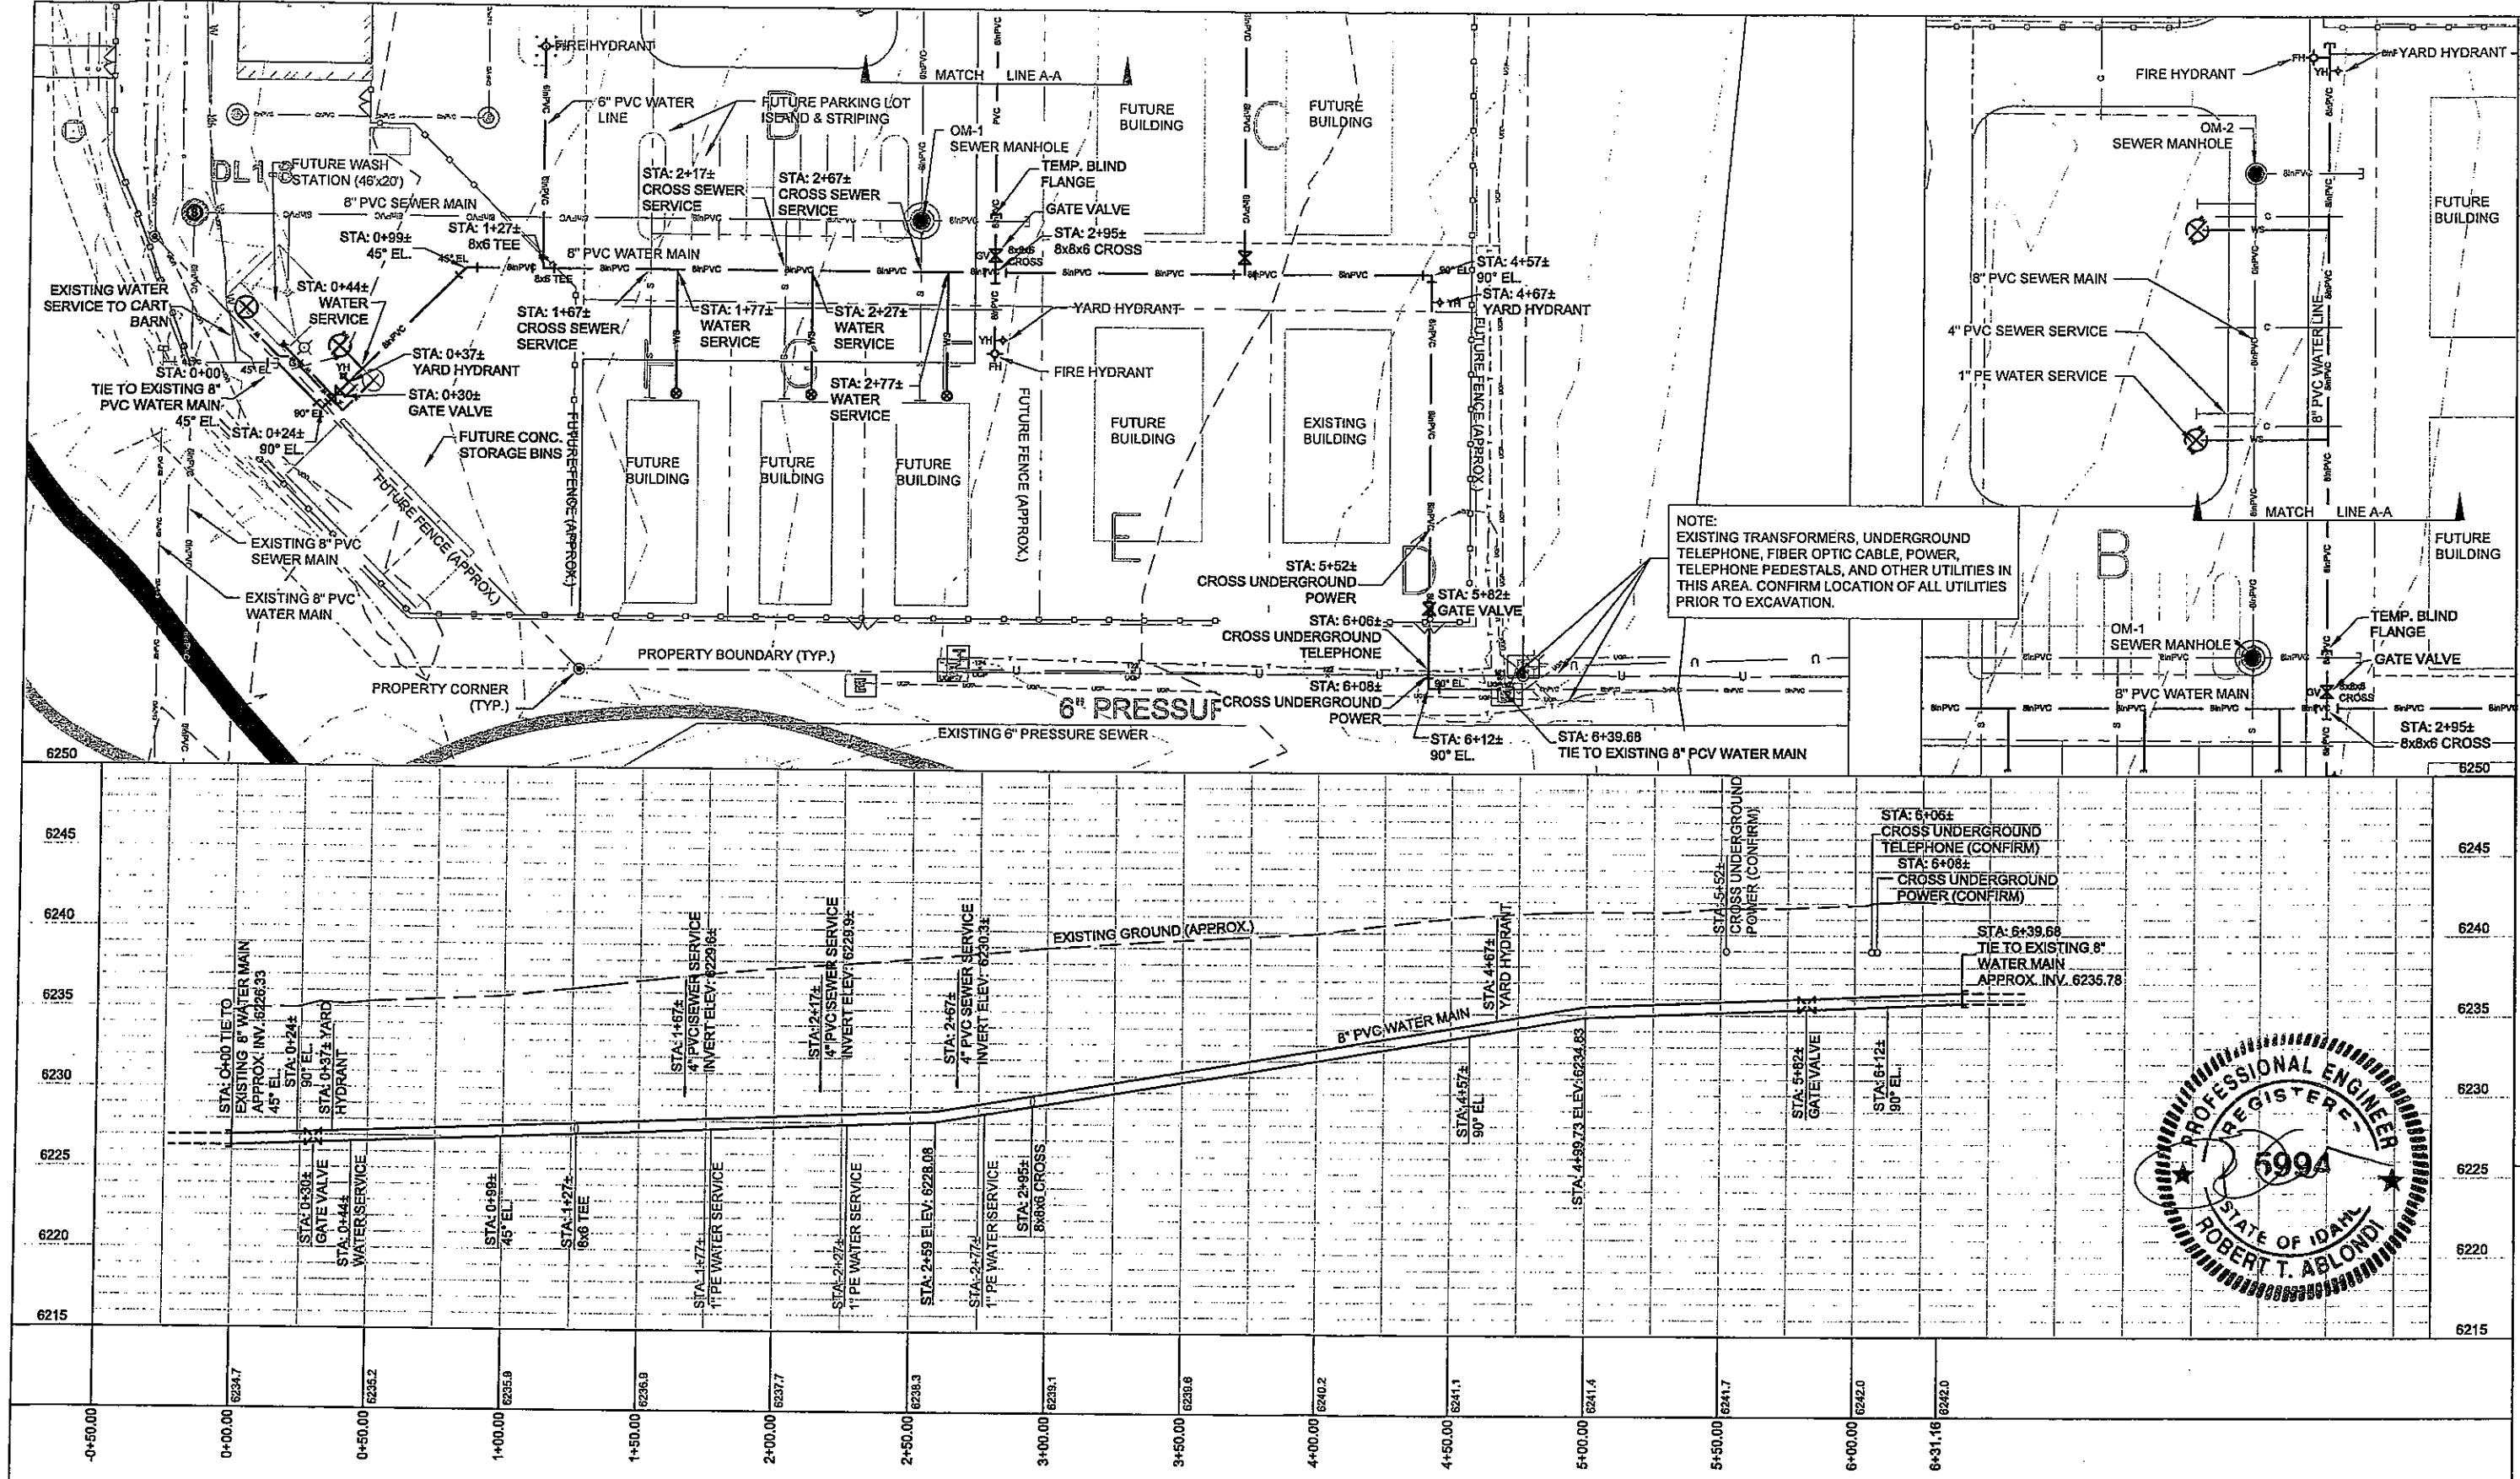


NOTES - THIS SHEET

GENERAL NOTES



SCALE: 1" = 30' HORZ.
1" = 5' VERT.

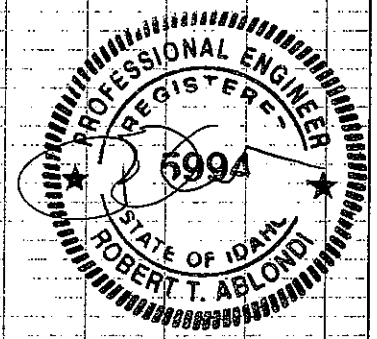

PROJECT TITLE:
**RECORD DRAWINGS
TETON SPRINGS**

PROJECT NUMBER:
**04-002
1.04**

 



DRAWING NUMBER:
ASBW-71

DRAWING TITLE:
**ASBUILT WATERMAIN
WATER MAIN 'Y'
OPERATIONS & MAINTENANCE CENTER**

Prepared By: JKC
Date: 10/07
Rev. Date:
Rev. Info:
Plot Info:
Data:
Pahr:

RENDEZVOUS ENGINEERING, P.C.
P.O. BOX 1458 JACKSON, WYOMING 83001
23 SOUTH GROES VENTURE STREET
PHONE - 307.733.0232 FAX - 307.733.2334

COUNTY ROAD 950 SOUTH (PAVED)

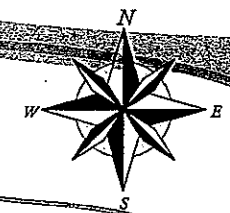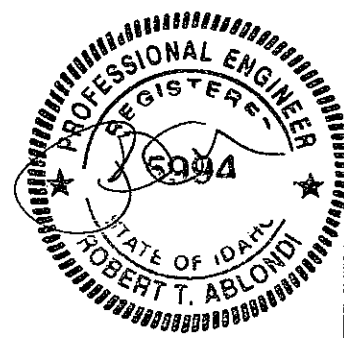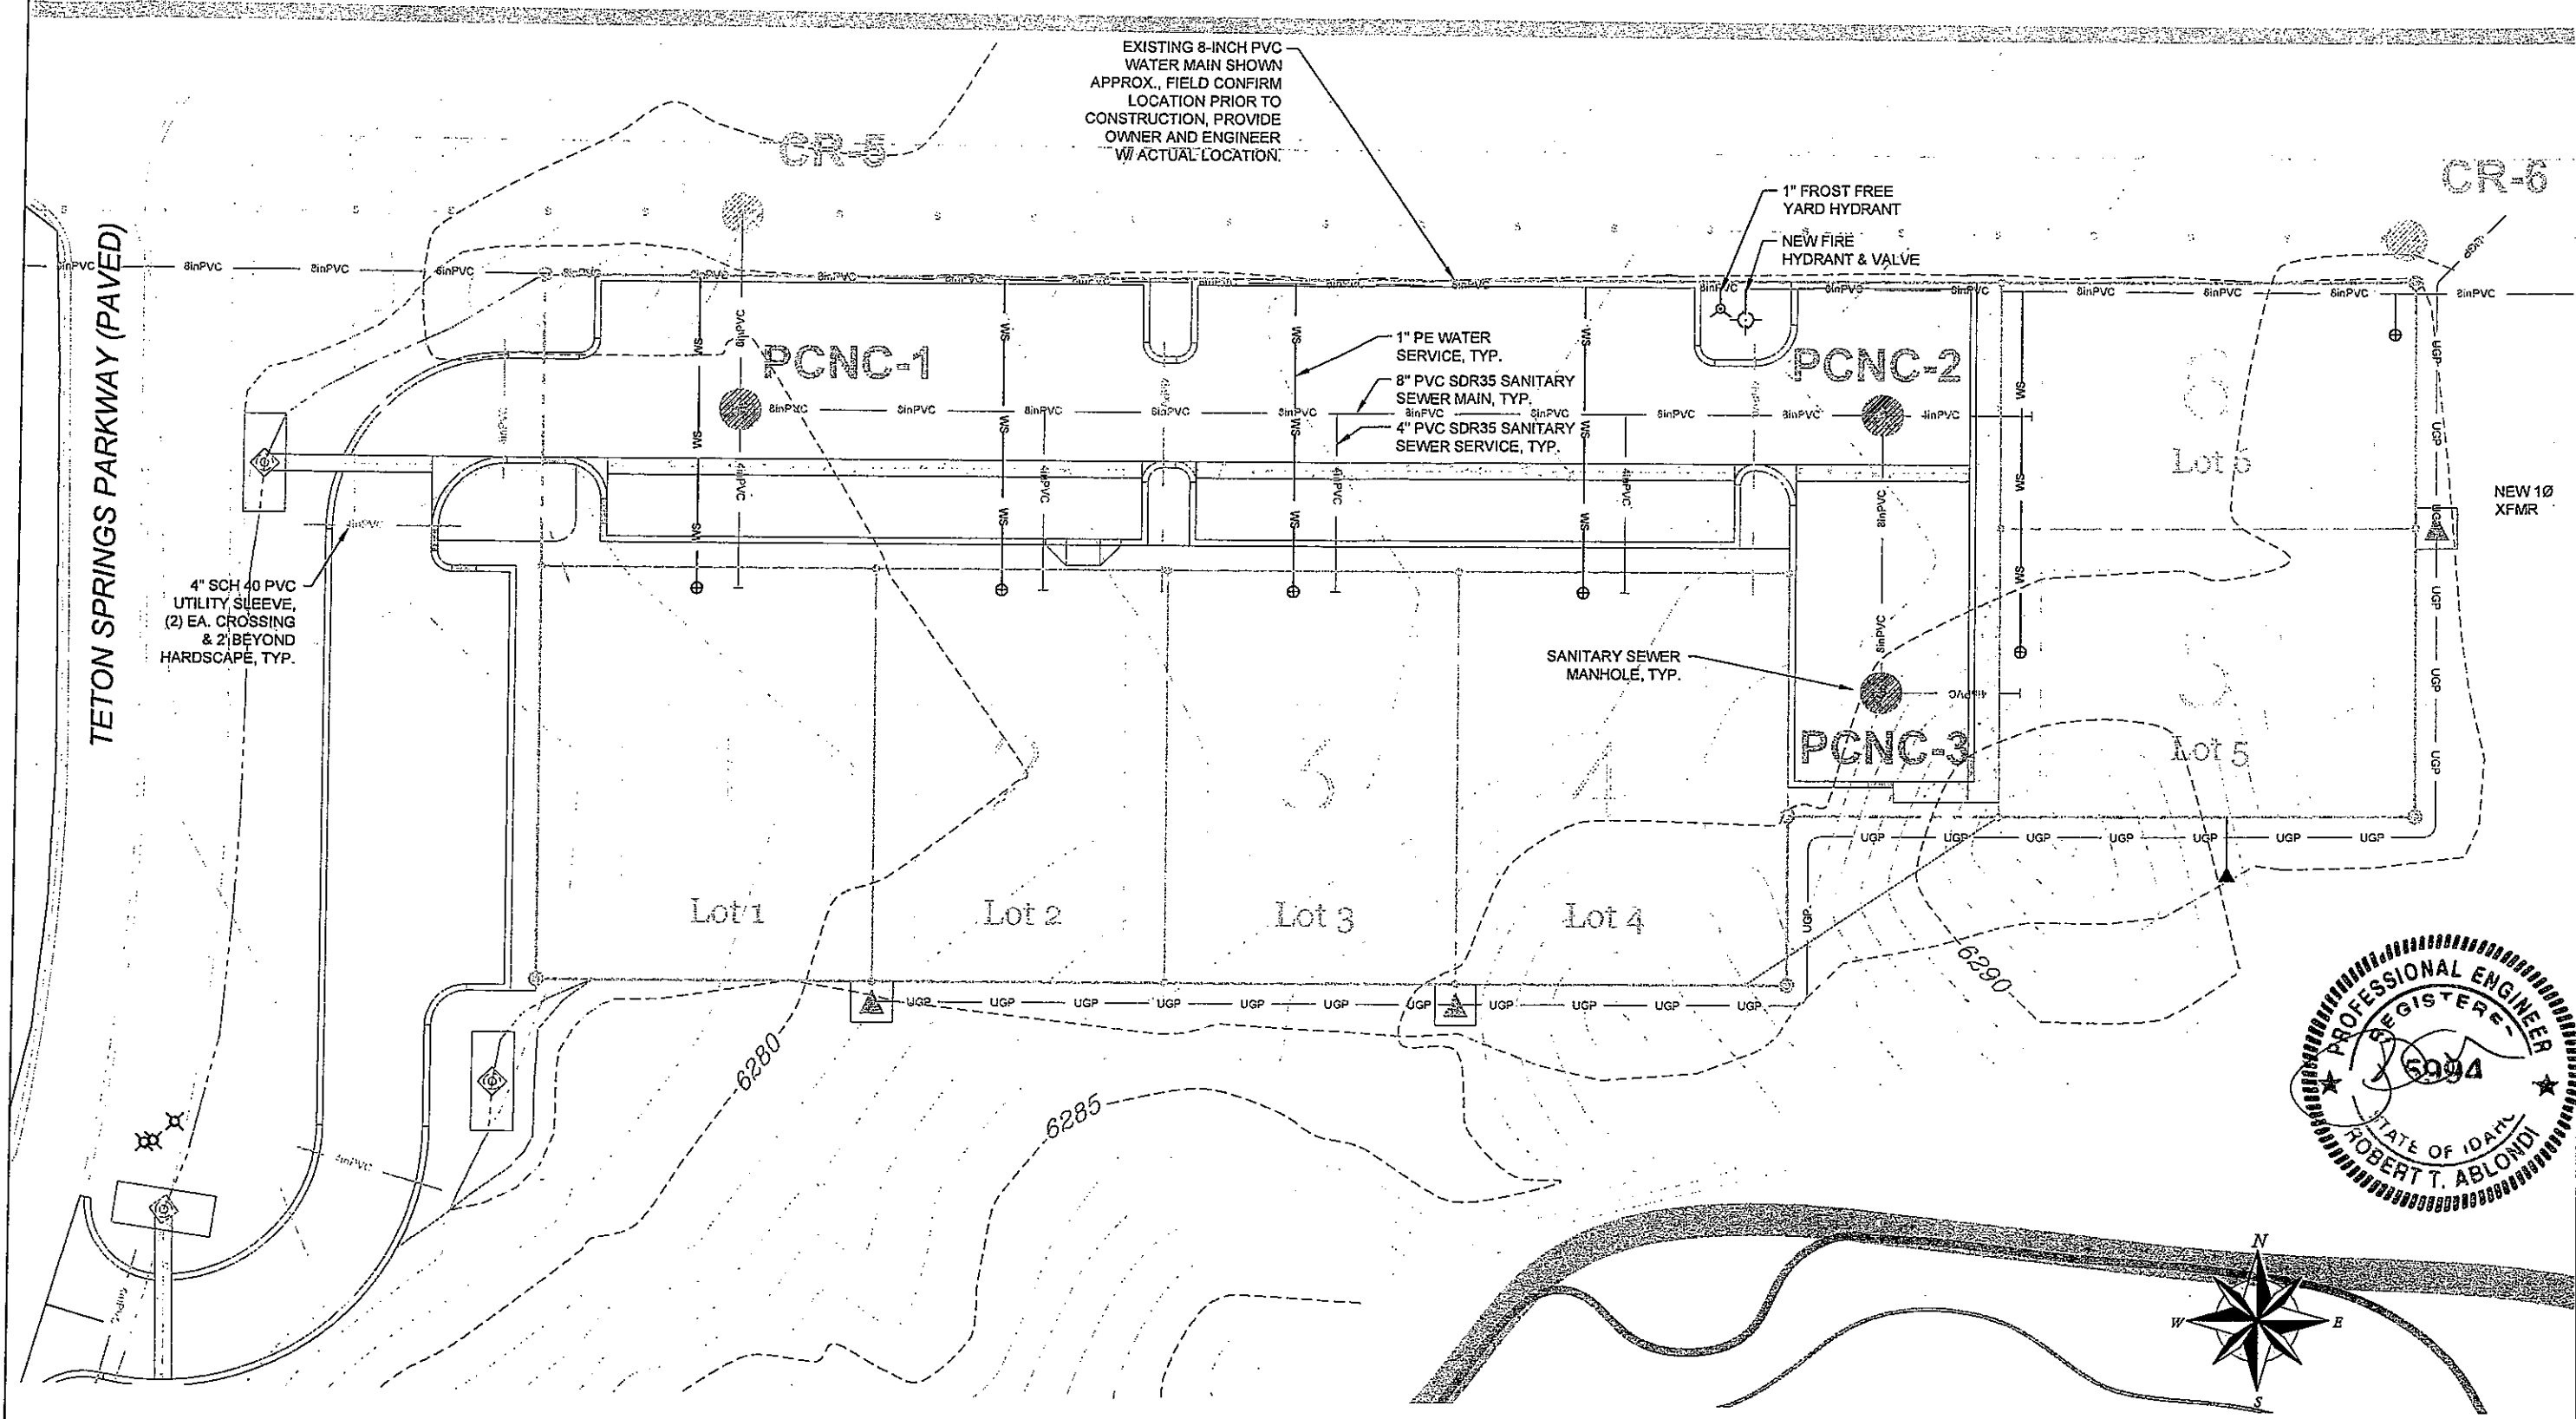

SCALE: 1" = 20' (24x36)


Prepared By: JAC
Date: 10/07
Rev. Date:

RENDEZVOUS ENGINEERING, P.C.
P.O. BOX 4858 JACKSON, WYOMING 83001
25 SOUTH GROS VENTRE STREET
PHONE - 307.733.5252 FAX - 307.733.2334



DRAWING TITLE:
ASBUILT WATER SERVICES
WATER MAIN 'Z'
NORTH COMMERCIAL CENTER

PROJECT TITLE:
RECORD DRAWINGS
TETON SPRINGS


PROJECT NUMBER:
04-002-1.6
DRAWING NUMBER:
ASBW-73

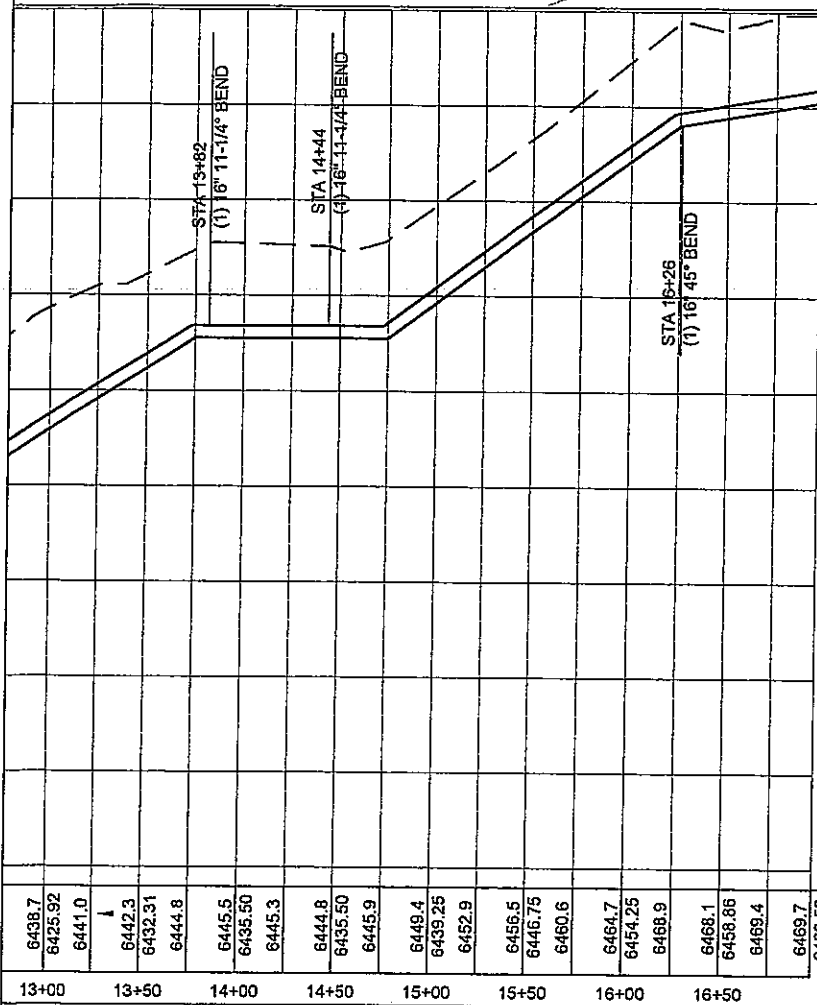


ASBW75

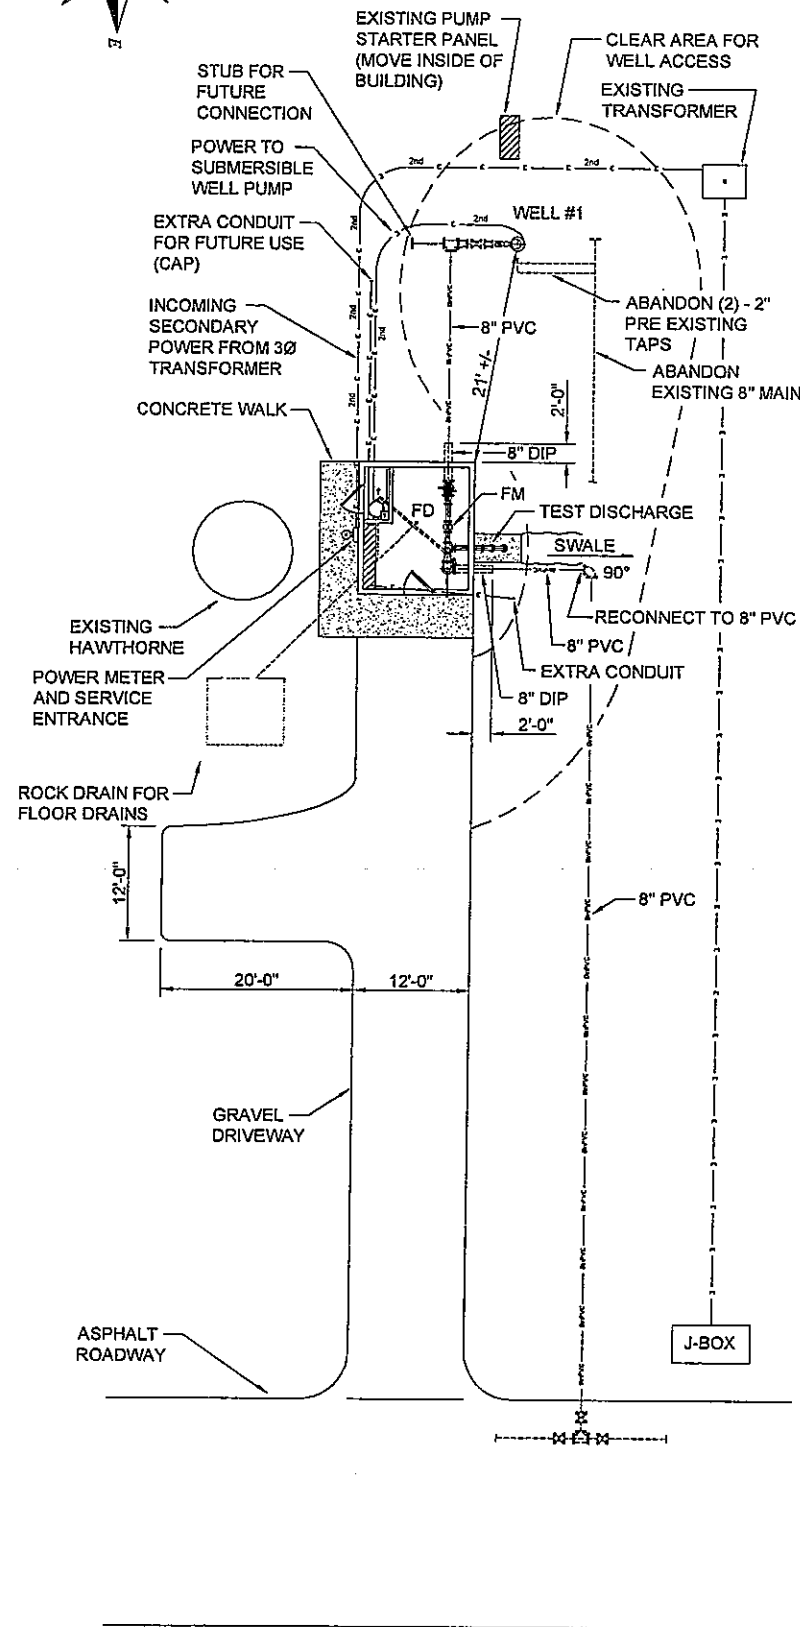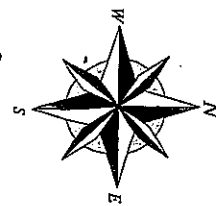


WELL #1 OVERALL SITE PLAN
SCALE: 1" = 10'

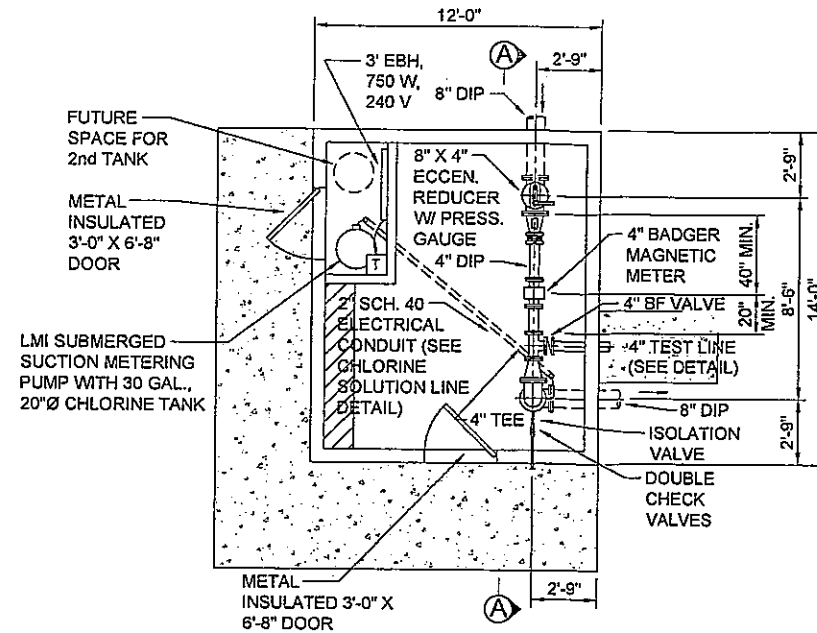


WELL HOUSE FLOOR PLAN
SCALE: 1" = 4'

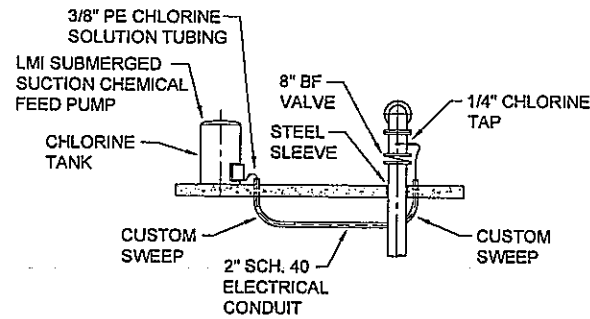


NOTE: USE STAINLESS STEEL OR PLASTIC FOR ALL CHLORINE SOLUTION PIPING AND FITTINGS
CHLORINE SOLUTION LINE DETAIL
SCALE: 1" = 4'

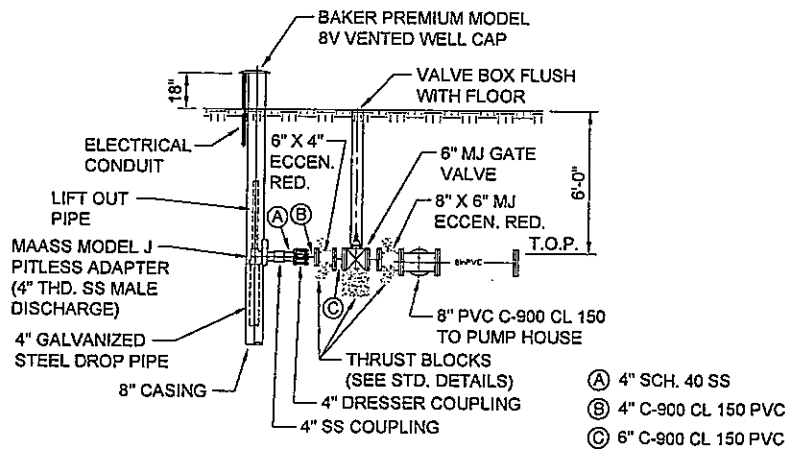


NOTE: DISCHARGE WELL TO THE SOUTH
WELL #1 CONNECTION DETAIL
SCALE: 1" = 4'

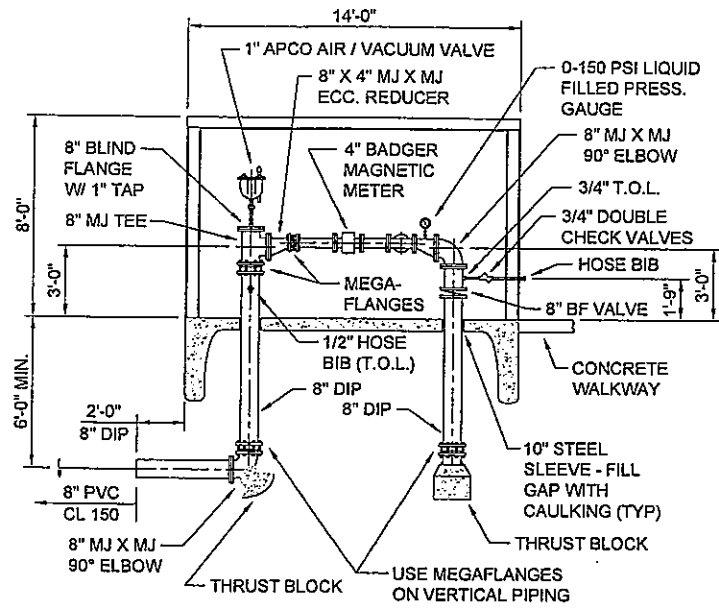


NOTE: ALL PIPING TO BE PAINTED BLUE
SECTION "A-A"
SCALE: 1" = 4'

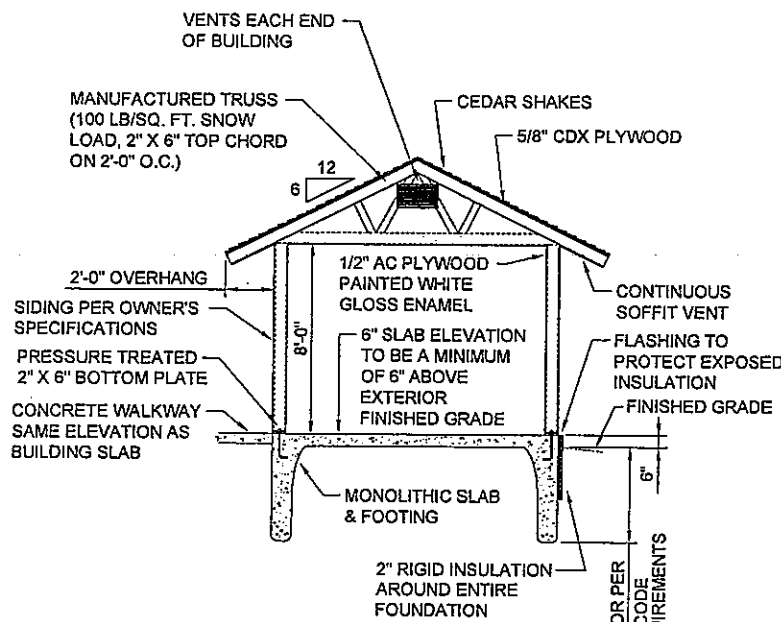


WELL #1 BUILDING SECTION
SCALE: 1" = 4'

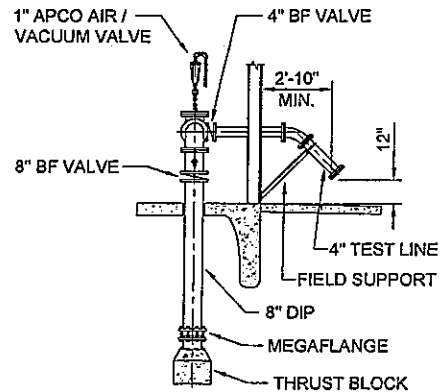


TEST LINE DETAIL
SCALE: 1" = 4'

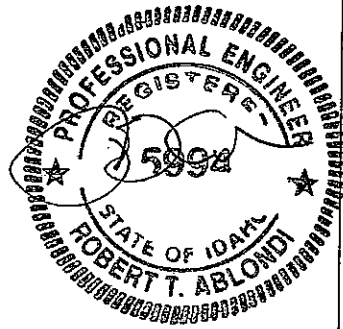


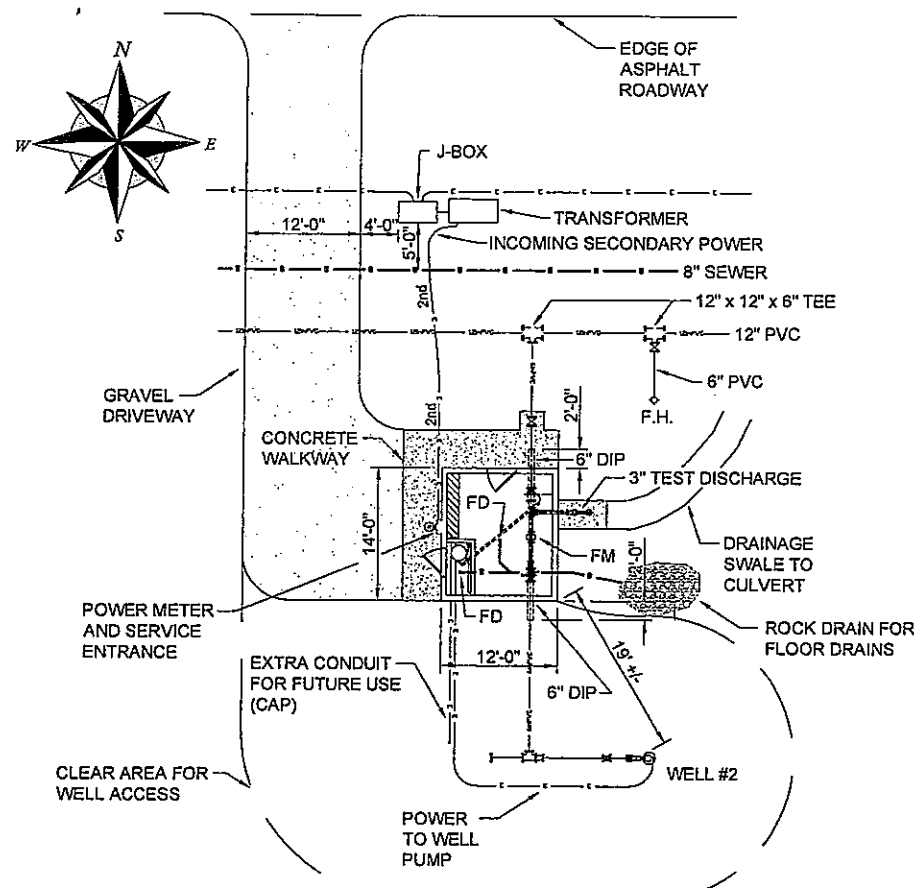


WELL #2 OVERALL SITE PLAN
SCALE: 1" = 10'

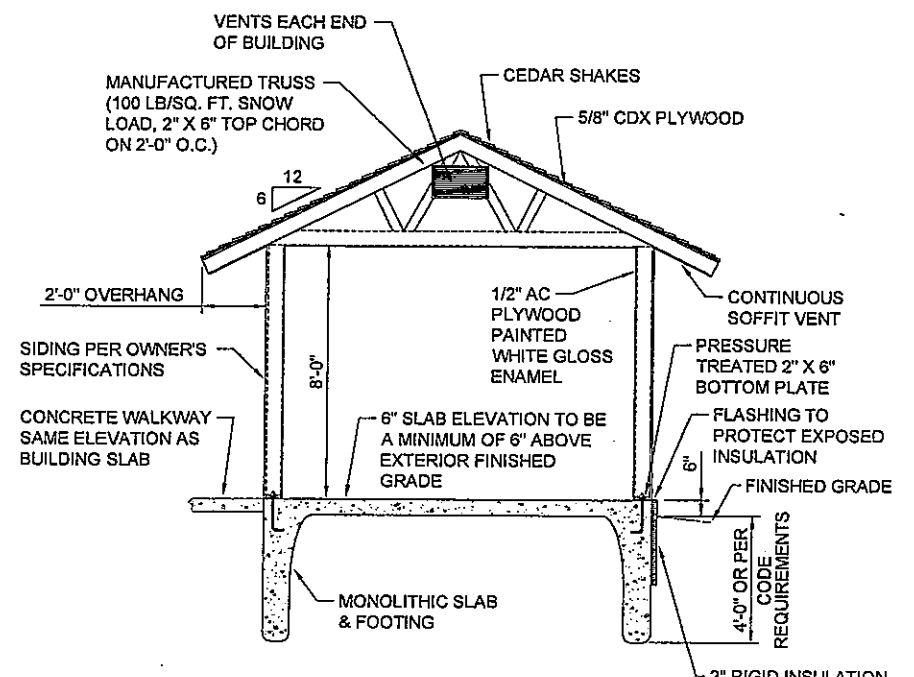

WELL #2 BUILDING SECTION
SCALE: 1" = 3'

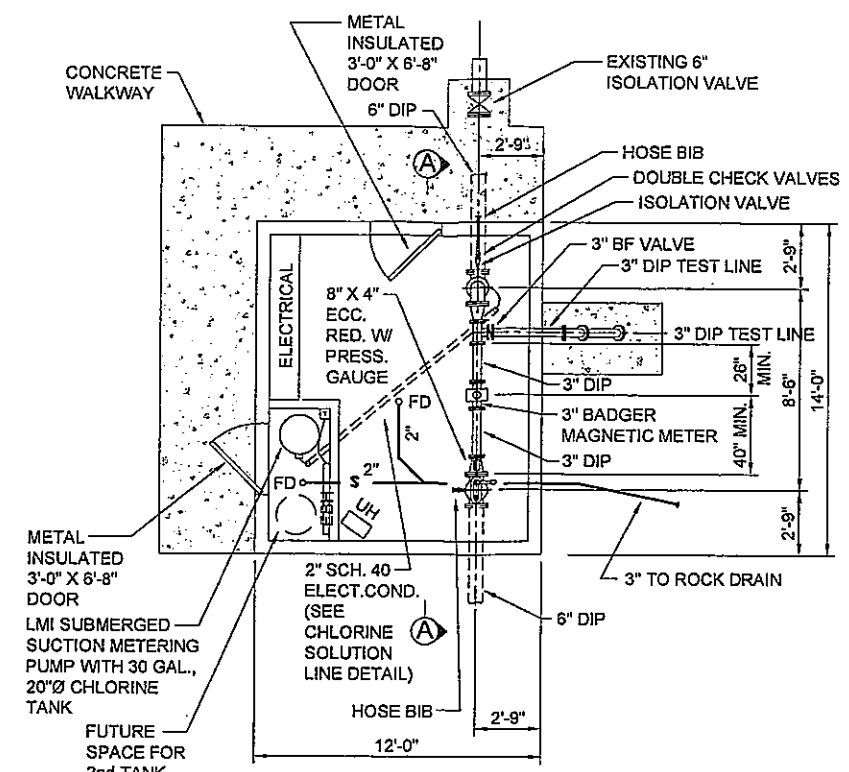


WELL HOUSE FLOOR PLAN
SCALE: 1" = 4'

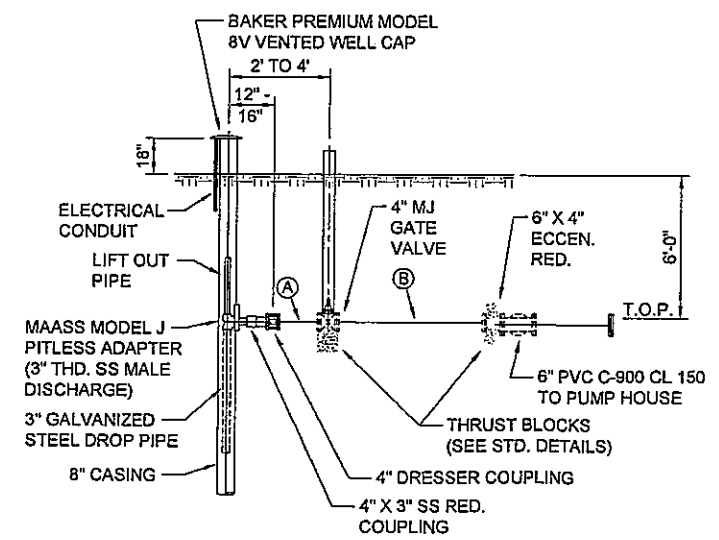

WELL #2 CONNECTION DETAIL
SCALE: 1" = 4'


NOTE: DISCHARGE WELL TO THE WEST

(A) 4" X 12" SS NIPPLE THD. X P.E.
(B) 4" C-900 CL 150 PVC

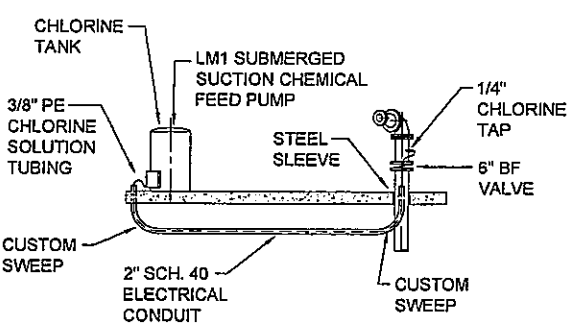


CHLORINE SOLUTION LINE DETAIL
SCALE: 1" = 4'

NOTE: USE STAINLESS STEEL OR PLASTIC FOR ALL CHLORINE SOLUTION PIPING AND FITTINGS

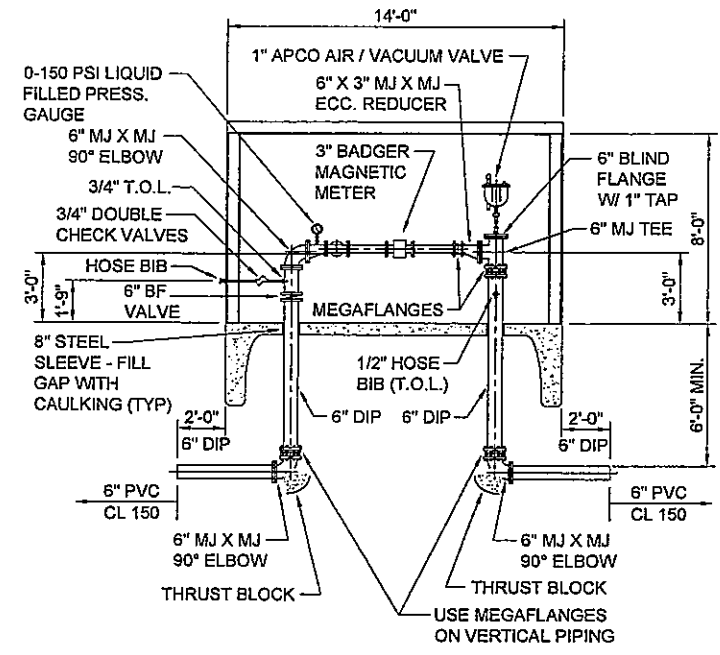


SECTION "A-A"
SCALE: 1" = 4'


NOTE: ALL PIPING TO BE PAINTED BLUE

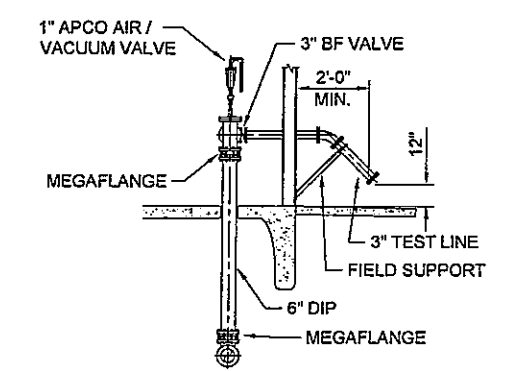

TEST LINE DETAIL
SCALE: 1" = 4'

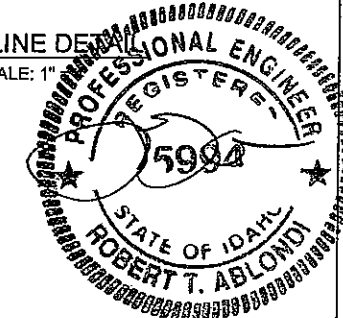

RENDEZVOUS ENGINEERING, P.C. P.O. BOX 4858 JACKSON, WYOMING 83001 25 SOUTH CROSS VENTURE STREET PHONE • 307.733.5252 FAX • 307.733.2334	
PROJECT TITLE: WELL HOUSE #2 PIPING DETAILS	PROJECT NUMBER: 00-023
DRAWING NUMBER: ABSW77	PREPARED BY: TJS DATE: 12/04/03 REV. DATE: REV. DATE: DATA: PLOT:

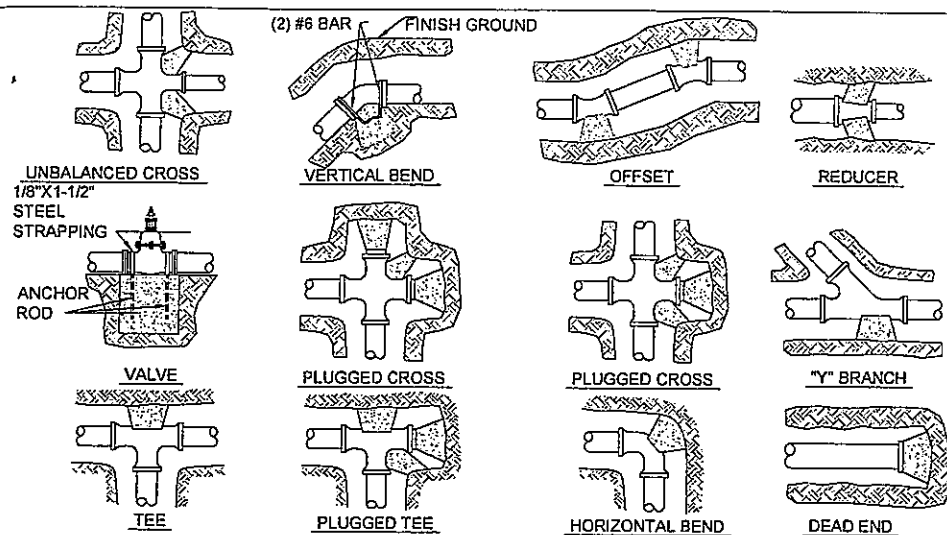


MINIMUM DIMENSION FOR THRUST BLOCKING											
FITTING SIZES	WATER MAIN PRESSURE (PSI)	TEES & PLUGS		90° BEND		45° BEND & WYES		REDUCERS & 22-1/2° BEND		11-1/4° BEND	
		A	B	A	B	A	B	A	B	A	B
4"	150	1'-7"	1'-2"	1'-9"	1'-6"	1'-8"	0'-10"	1'-7"	0'-6"	0'-6"	0'-6"
6"	150	2'-0"	1'-11"	2'-5"	2'-2"	1'-10"	1'-7"	1'-9"	0'-10"	1'-0"	0'-6"
8"	150	2'-8"	2'-6"	3'-2"	3'-0"	2'-5"	2'-1"	1'-9"	1'-6"	1'-0"	1'-0"
10"	150	3'-4"	3'-3"	4'-0"	3'-10"	3'-0"	2'-9"	2'-2"	1'-11"	1'-6"	1'-0"
12"	150	4'-0"	3'-10"	4'-8"	4'-8"	3'-8"	3'-3"	2'-7"	2'-3"	2'-0"	1'-0"

- NOTES:
1. SEPARATE PIPE AND FITTINGS FROM CONCRETE THRUST BLOCK WITH POLYETHYLENE.
 2. THRUST BLOCK SHALL BEAR AGAINST UNDISTURBED SOIL.
 3. DESIGN IS BASED ON 2000 PSF SOIL BEARING CAPACITY.
 4. THRUST BLOCKS SHALL NOT BE LESS THAN 6" THICK.
 5. COAT ALL EXPOSED RODS AND STRAPPING WITH BITUMINOUS EMULSION OR ROOFING CEMENT.

THRUST BLOCKING DETAILS 5
no scale


VERTICAL ANCHOR BLOCK SIZING TABLE CONCRETE VOLUME REQUIRED (CU.FT.) (150 PSI)			
SIZE	45°	22-1/2°	11-1/4°
3"	8.3	4.4	2.1
4"	14.7	7.5	3.9
6"	33.0	17.0	8.4
8"	58.5	29.7	14.9
10"	91.2	46.5	23.3
12"	131.7	67.5	33.3

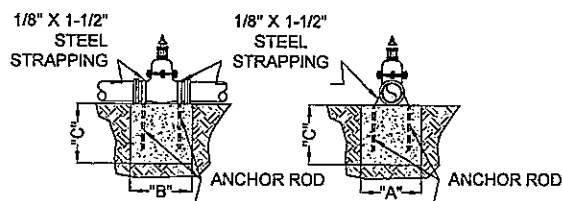


- NOTES:
1. THRUST BLOCKS SHALL BE SIZED FOR THE MAXIMUM WORKING PRESSURE IN THE SYSTEM.
 2. THRUST BLOCK SHALL BE INSTALLED AT ALL BURIED VALVES 4" AND LARGER IN SIZE.
 3. COAT EXPOSED PORTIONS OF ANCHOR RODS AND STRAPPING WITH BITUMINOUS EMULSION OR ROOFING CEMENT.

VALVE THRUST BLOCK DETAIL 6
no scale

MINIMUM DIMENSION FOR THRUST BLOCKING							
ANCHOR ROD SIZE	3/4"	3/4"	3/4"	1"	1 1/8"	1 1/4"	1 3/8"
VALVE SIZE	6" & 8"	10"	12"	14"	16"	18"	24"
150 PSI	"A"	2'-0"	2'-6"	3'-0"	3'-5"	4'-4"	5'-8"
	"B"	2'-0"	2'-6"	3'-0"	3'-0"	3'-0"	4'-0"
	"C"	2'-0"	2'-0"	2'-8"	3'-0"	3'-0"	4'-0"

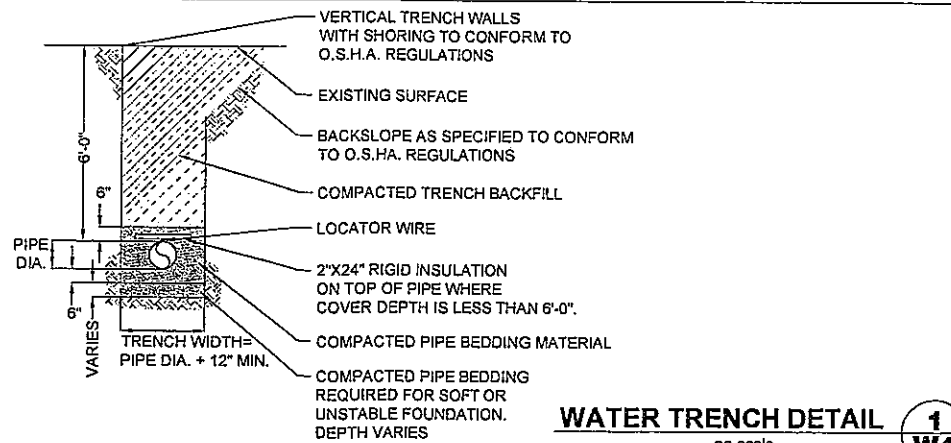


WATER TRENCH DETAIL 1
no scale

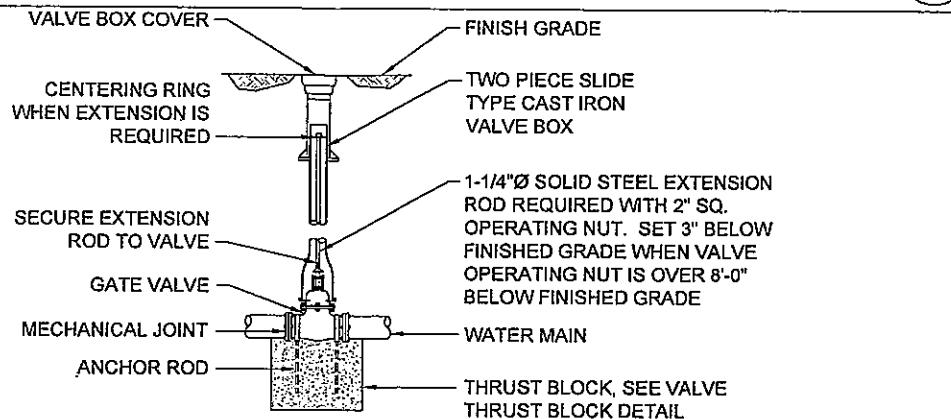


WATER MAIN VALVE DETAIL 2
no scale


NOTE: VALVE BOX SHALL BE CENTERED AND PLUMB

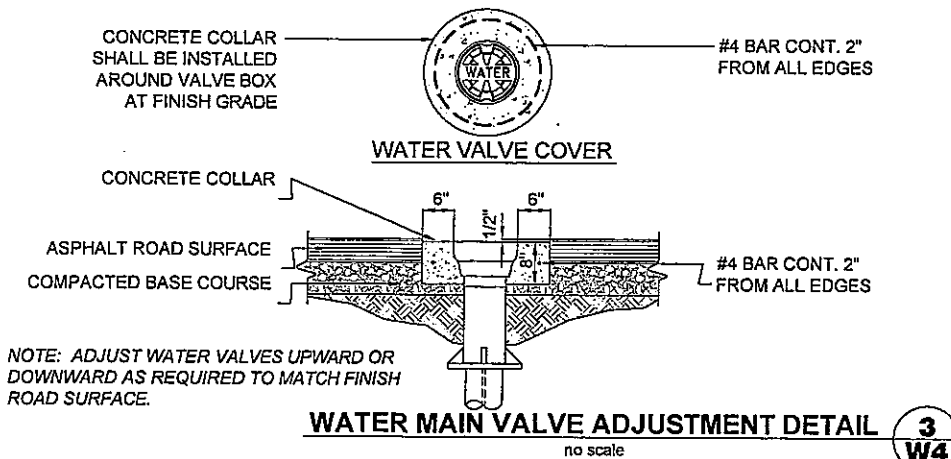


WATER MAIN VALVE ADJUSTMENT DETAIL 3
no scale

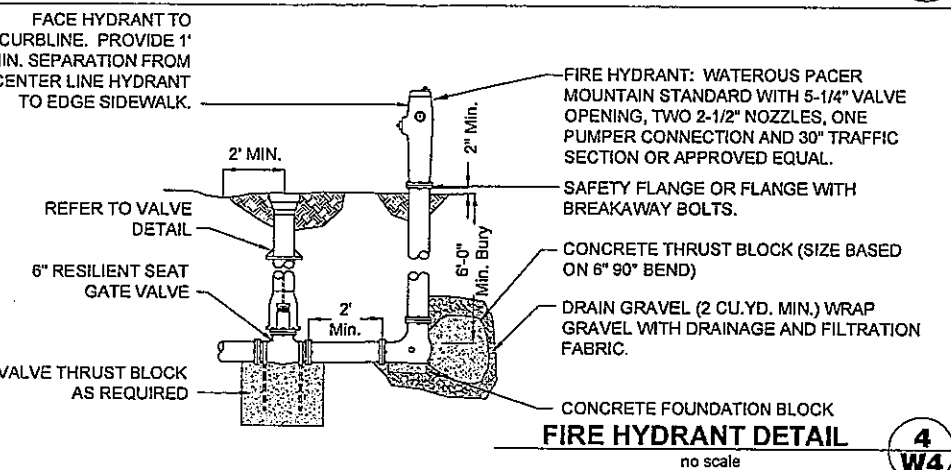


FIRE HYDRANT DETAIL 4
no scale

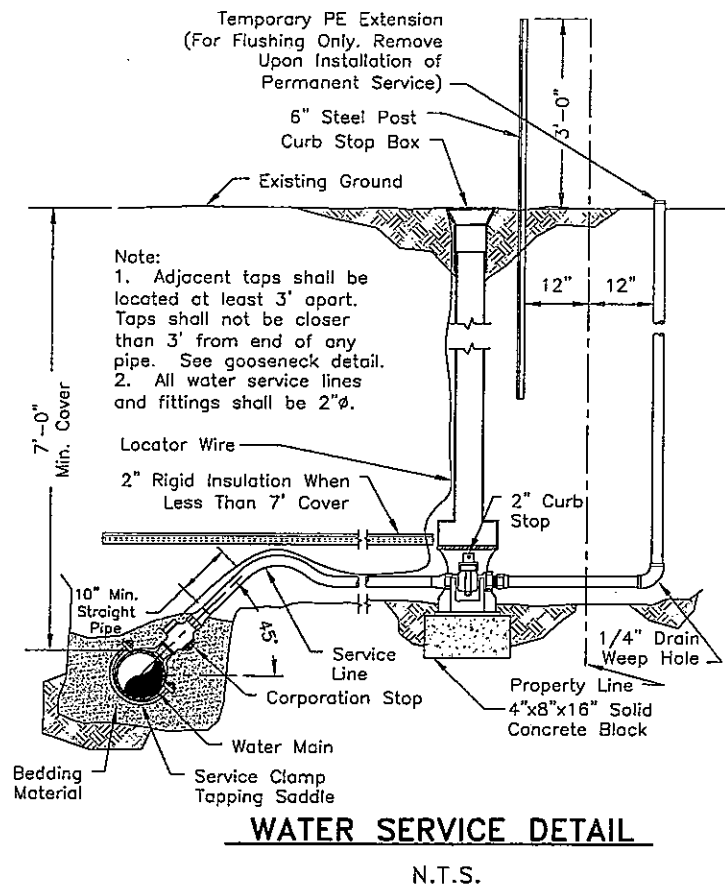


WATER SERVICE DETAIL
N.T.S.

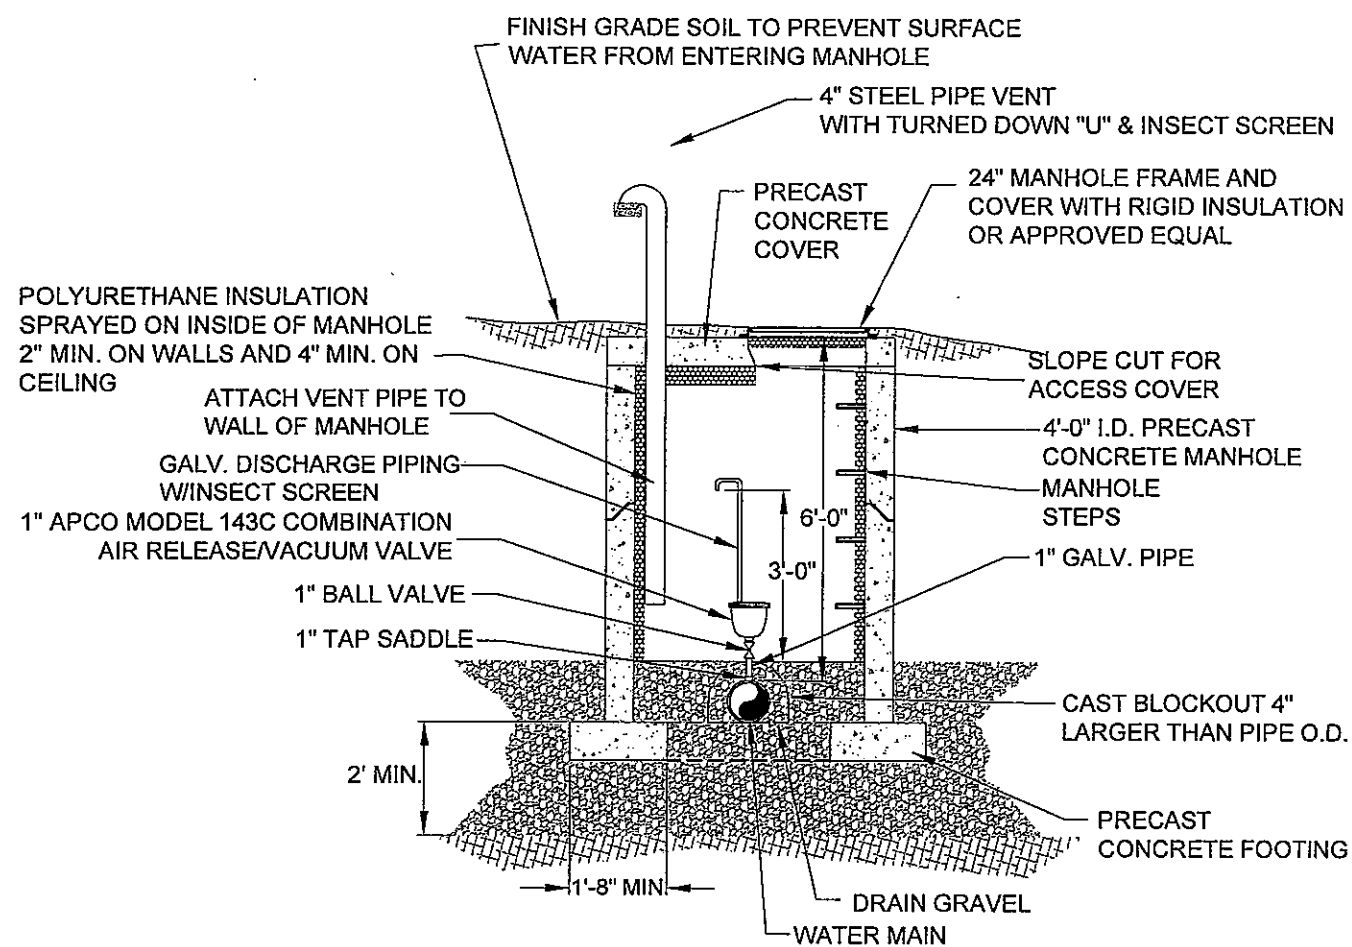



AIR RELEASE VALVE OVER WATER MAIN 2
SCALE: 1" = 20'

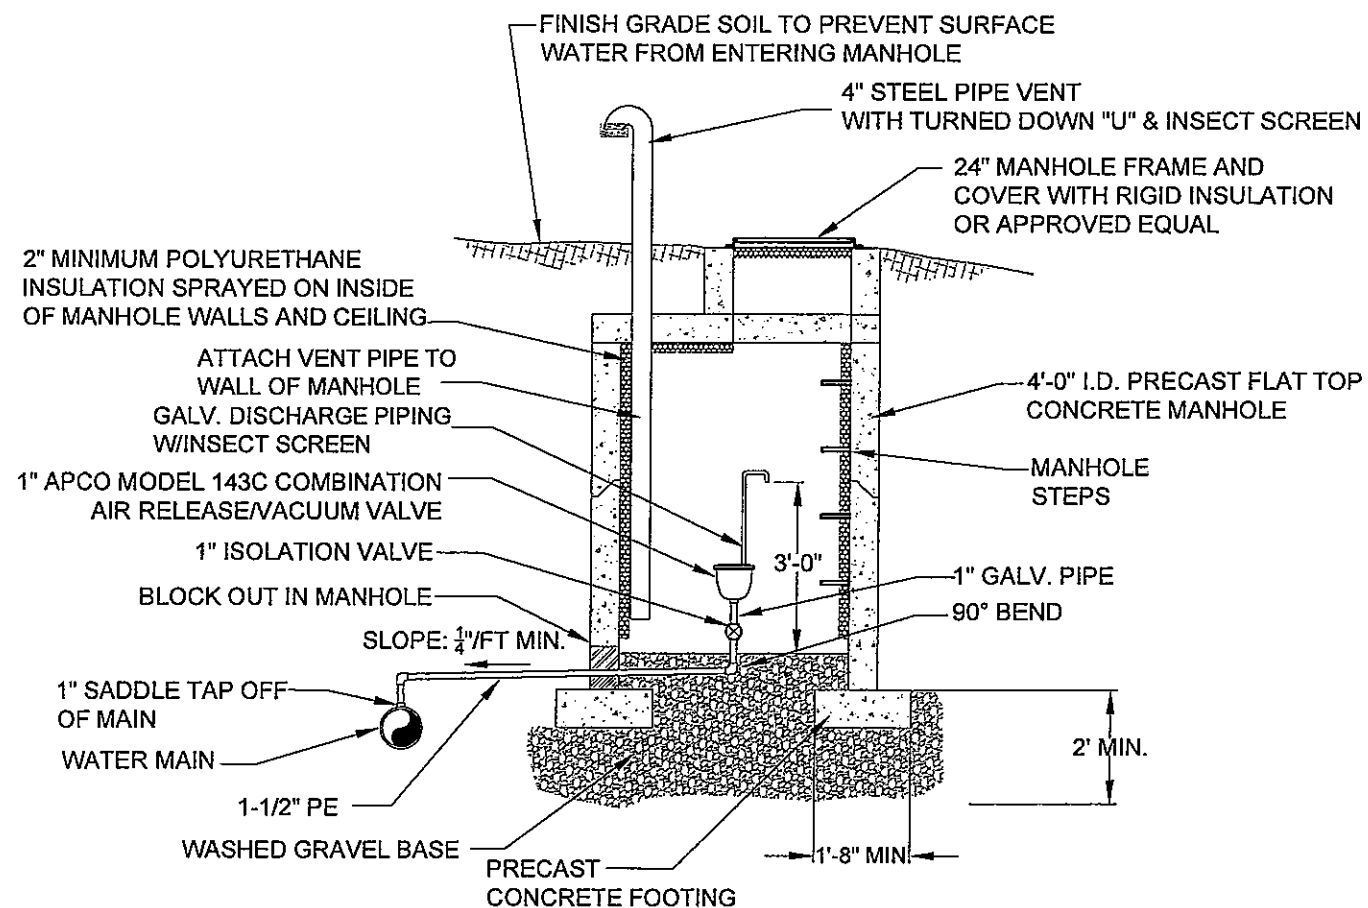


OFF-SET AIR RELEASE VALVE 1
SCALE: 1" = 20'

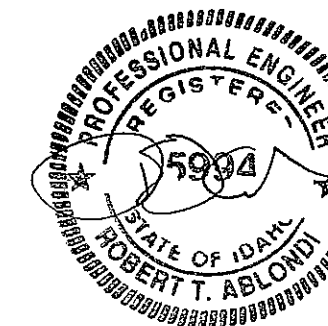

Prepared By: MBB Date: MAY 29, 2002 Rev. Date: APRIL 2003 Plot Info: Date: PLOT:	RENDEZVOUS ENGINEERING, P.C. P.O. BOX 4855 JACKSON, WYOMING 83001 25 SOUTH GROS VENTRE STREET PHONE - 307.733.5252 FAX - 307.733.2334
PROJECT TITLE: WATER SYSTEM DETAILS	PROJECT TITLE: RECORD DRAWINGS TETON SPRINGS
PROJECT NUMBER: 00-023	DRAWING NUMBER: ASBS79

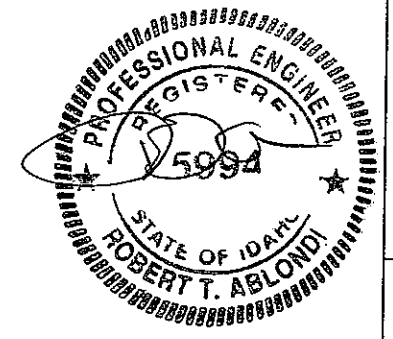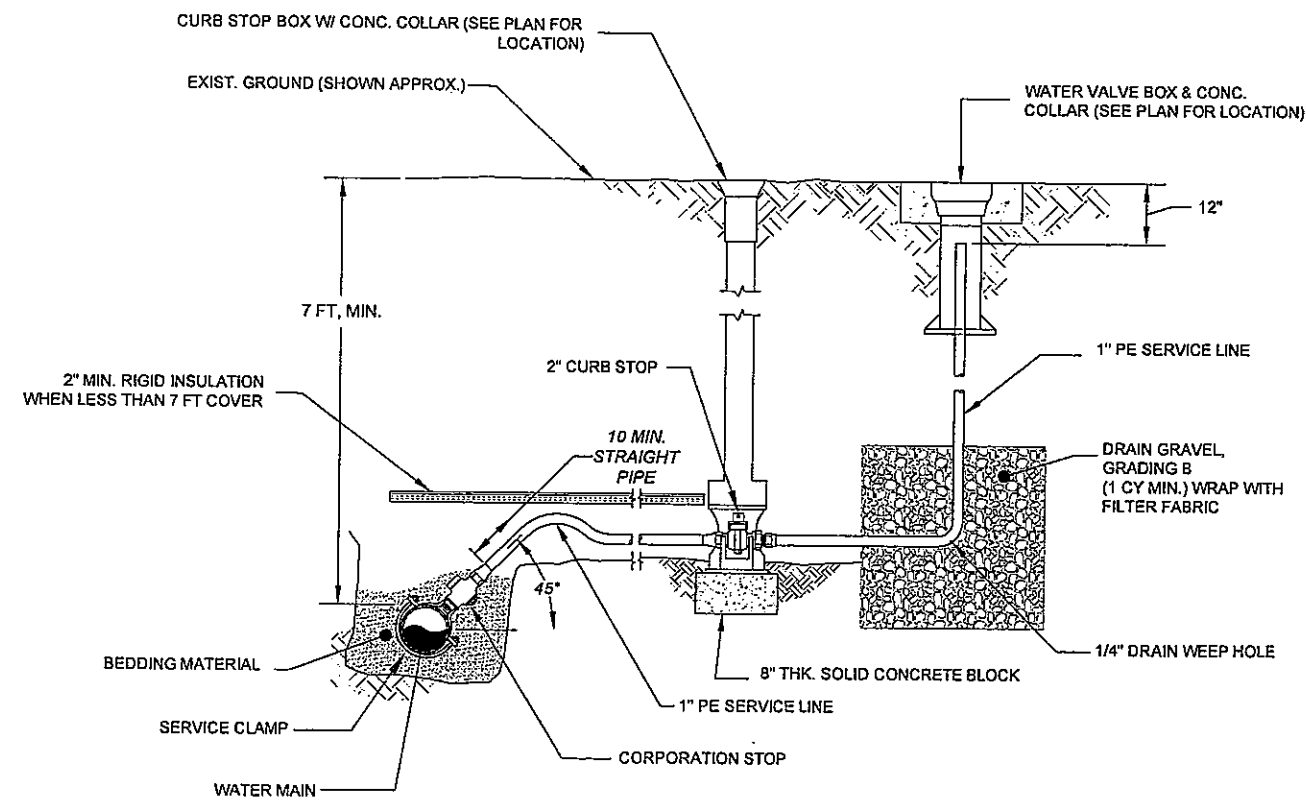

Prepared By: JWC	RENDEZVOUS ENGINEERING, P.C.	ENCLAVE WATER & SEWER BLOWOFF VALVE DETAILS	PROJECT TITLE: RECORD DRAWINGS TETON SPRINGS	PROJECT NUMBER:
Date:	P.O. BOX 4859 JACKSON, WYOMING 83001 25 SOUTH GROS VENTRE STREET PHONE - 307.733.5252 FAX - 307.733.2334			04-002
Rev. Date:				1.032
				DRAWING NUMBER: ASBW80

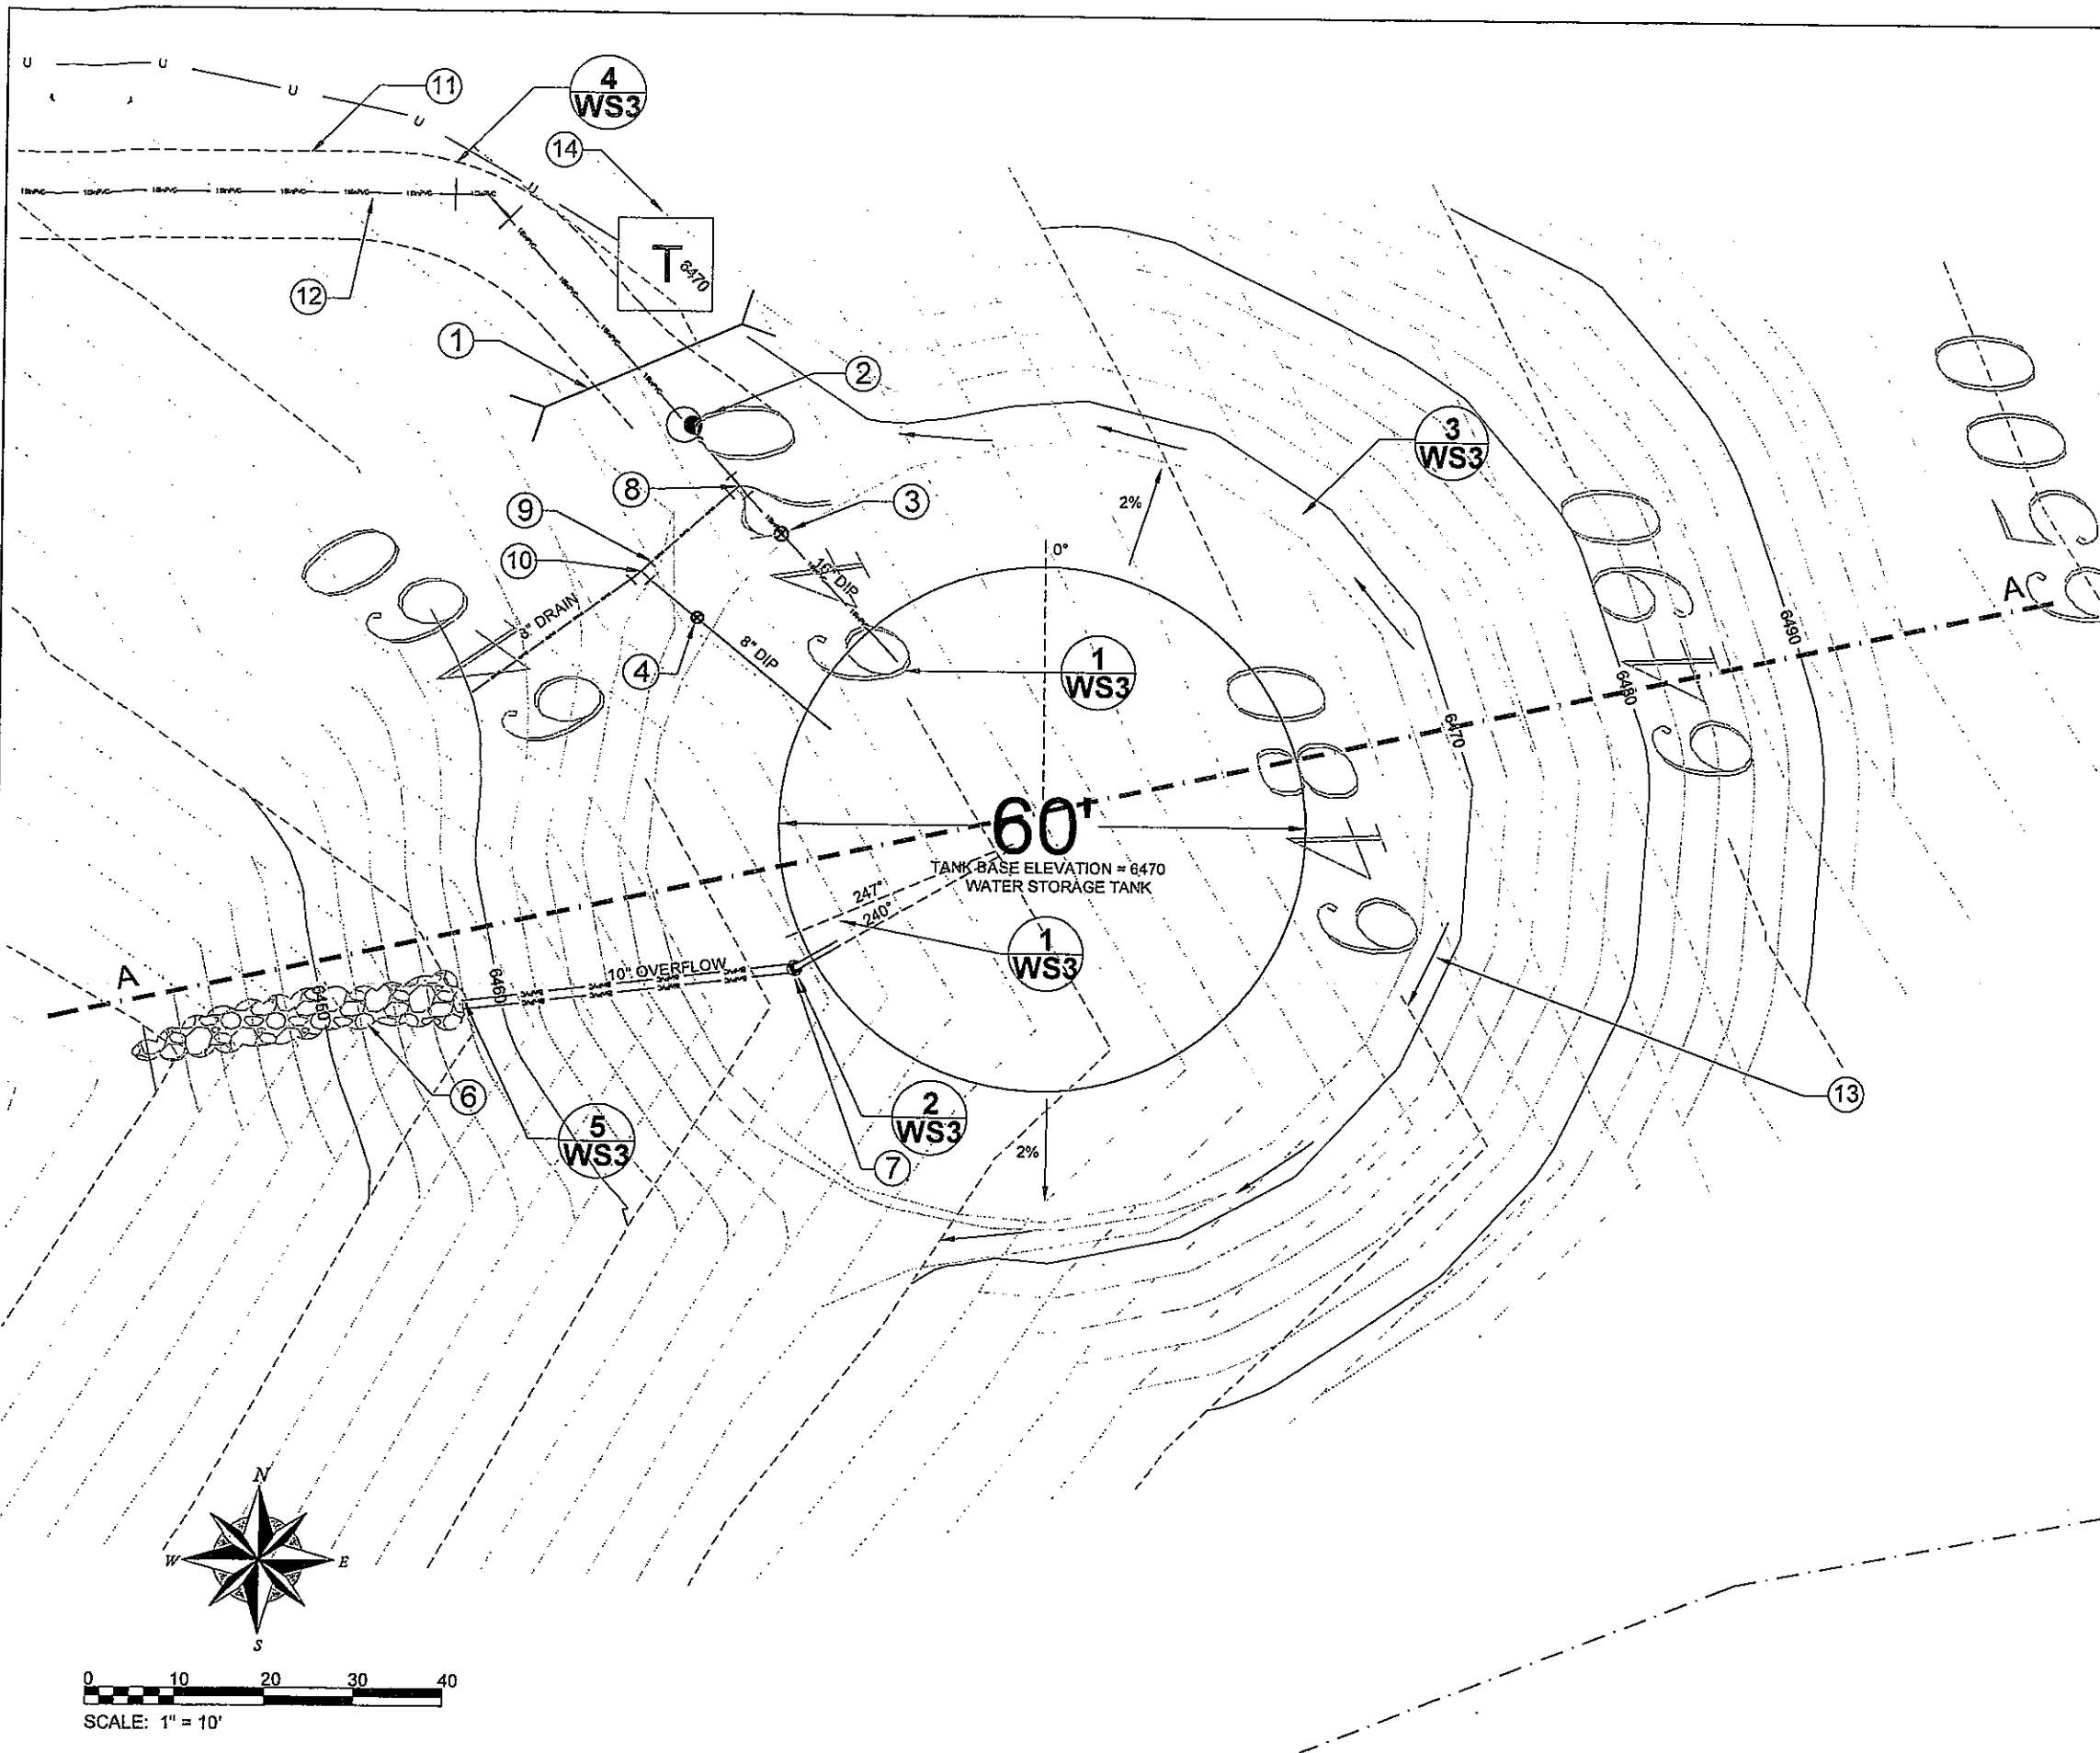

NOTES THIS SHEET

- ① 18" CMP CULVERT, 24 LF, WITH FLARED END SECTIONS.
- ② 4' CONCRETE MANHOLE WITH COVER FOR TRANSDUCER.
- ③ 16" GATE VALVE
- ④ 8" GATE VALVE
- ⑤ N/A
- ⑥ RIP RAP OVERFLOW OUTLET
- ⑦ DISCHARGE OVERFLOW TO DRAINAGE GRATE
- ⑧ (1) 16"x16"x8" TEE
- ⑨ (1) 8" 22-1/2" BEND
- ⑩ (1) 8"x8"x8" TEE
- ⑪ 10' WIDE ACCESS ROAD
- ⑫ EXISTING 16" SUPPLY LINE
- ⑬ ARROW INDICATES DITCH SLOPE DIRECTION
- ⑭ ELECTRICAL PANEL FOR RADIO TELEMTRY/ TRANSDUCER CONTROLS

RENEZVOUS ENGINEERING, P.C.


P.O. BOX 4558 JACKSON, WYOMING 83301
25 SOUTH GROS VENTRE STREET
PHONE - 307.733.5252 FAX - 307.733.2334


DRAWING TITLE:
ASBUILT WATER PLANS
WATER TANK SITE

PROJECT
RECORD DRAWINGS
TETON SPRINGS

PROJECT
NUMBER:
00-023

DRAWING
NUMBER:
ASBW81

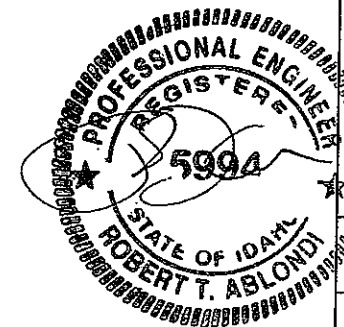

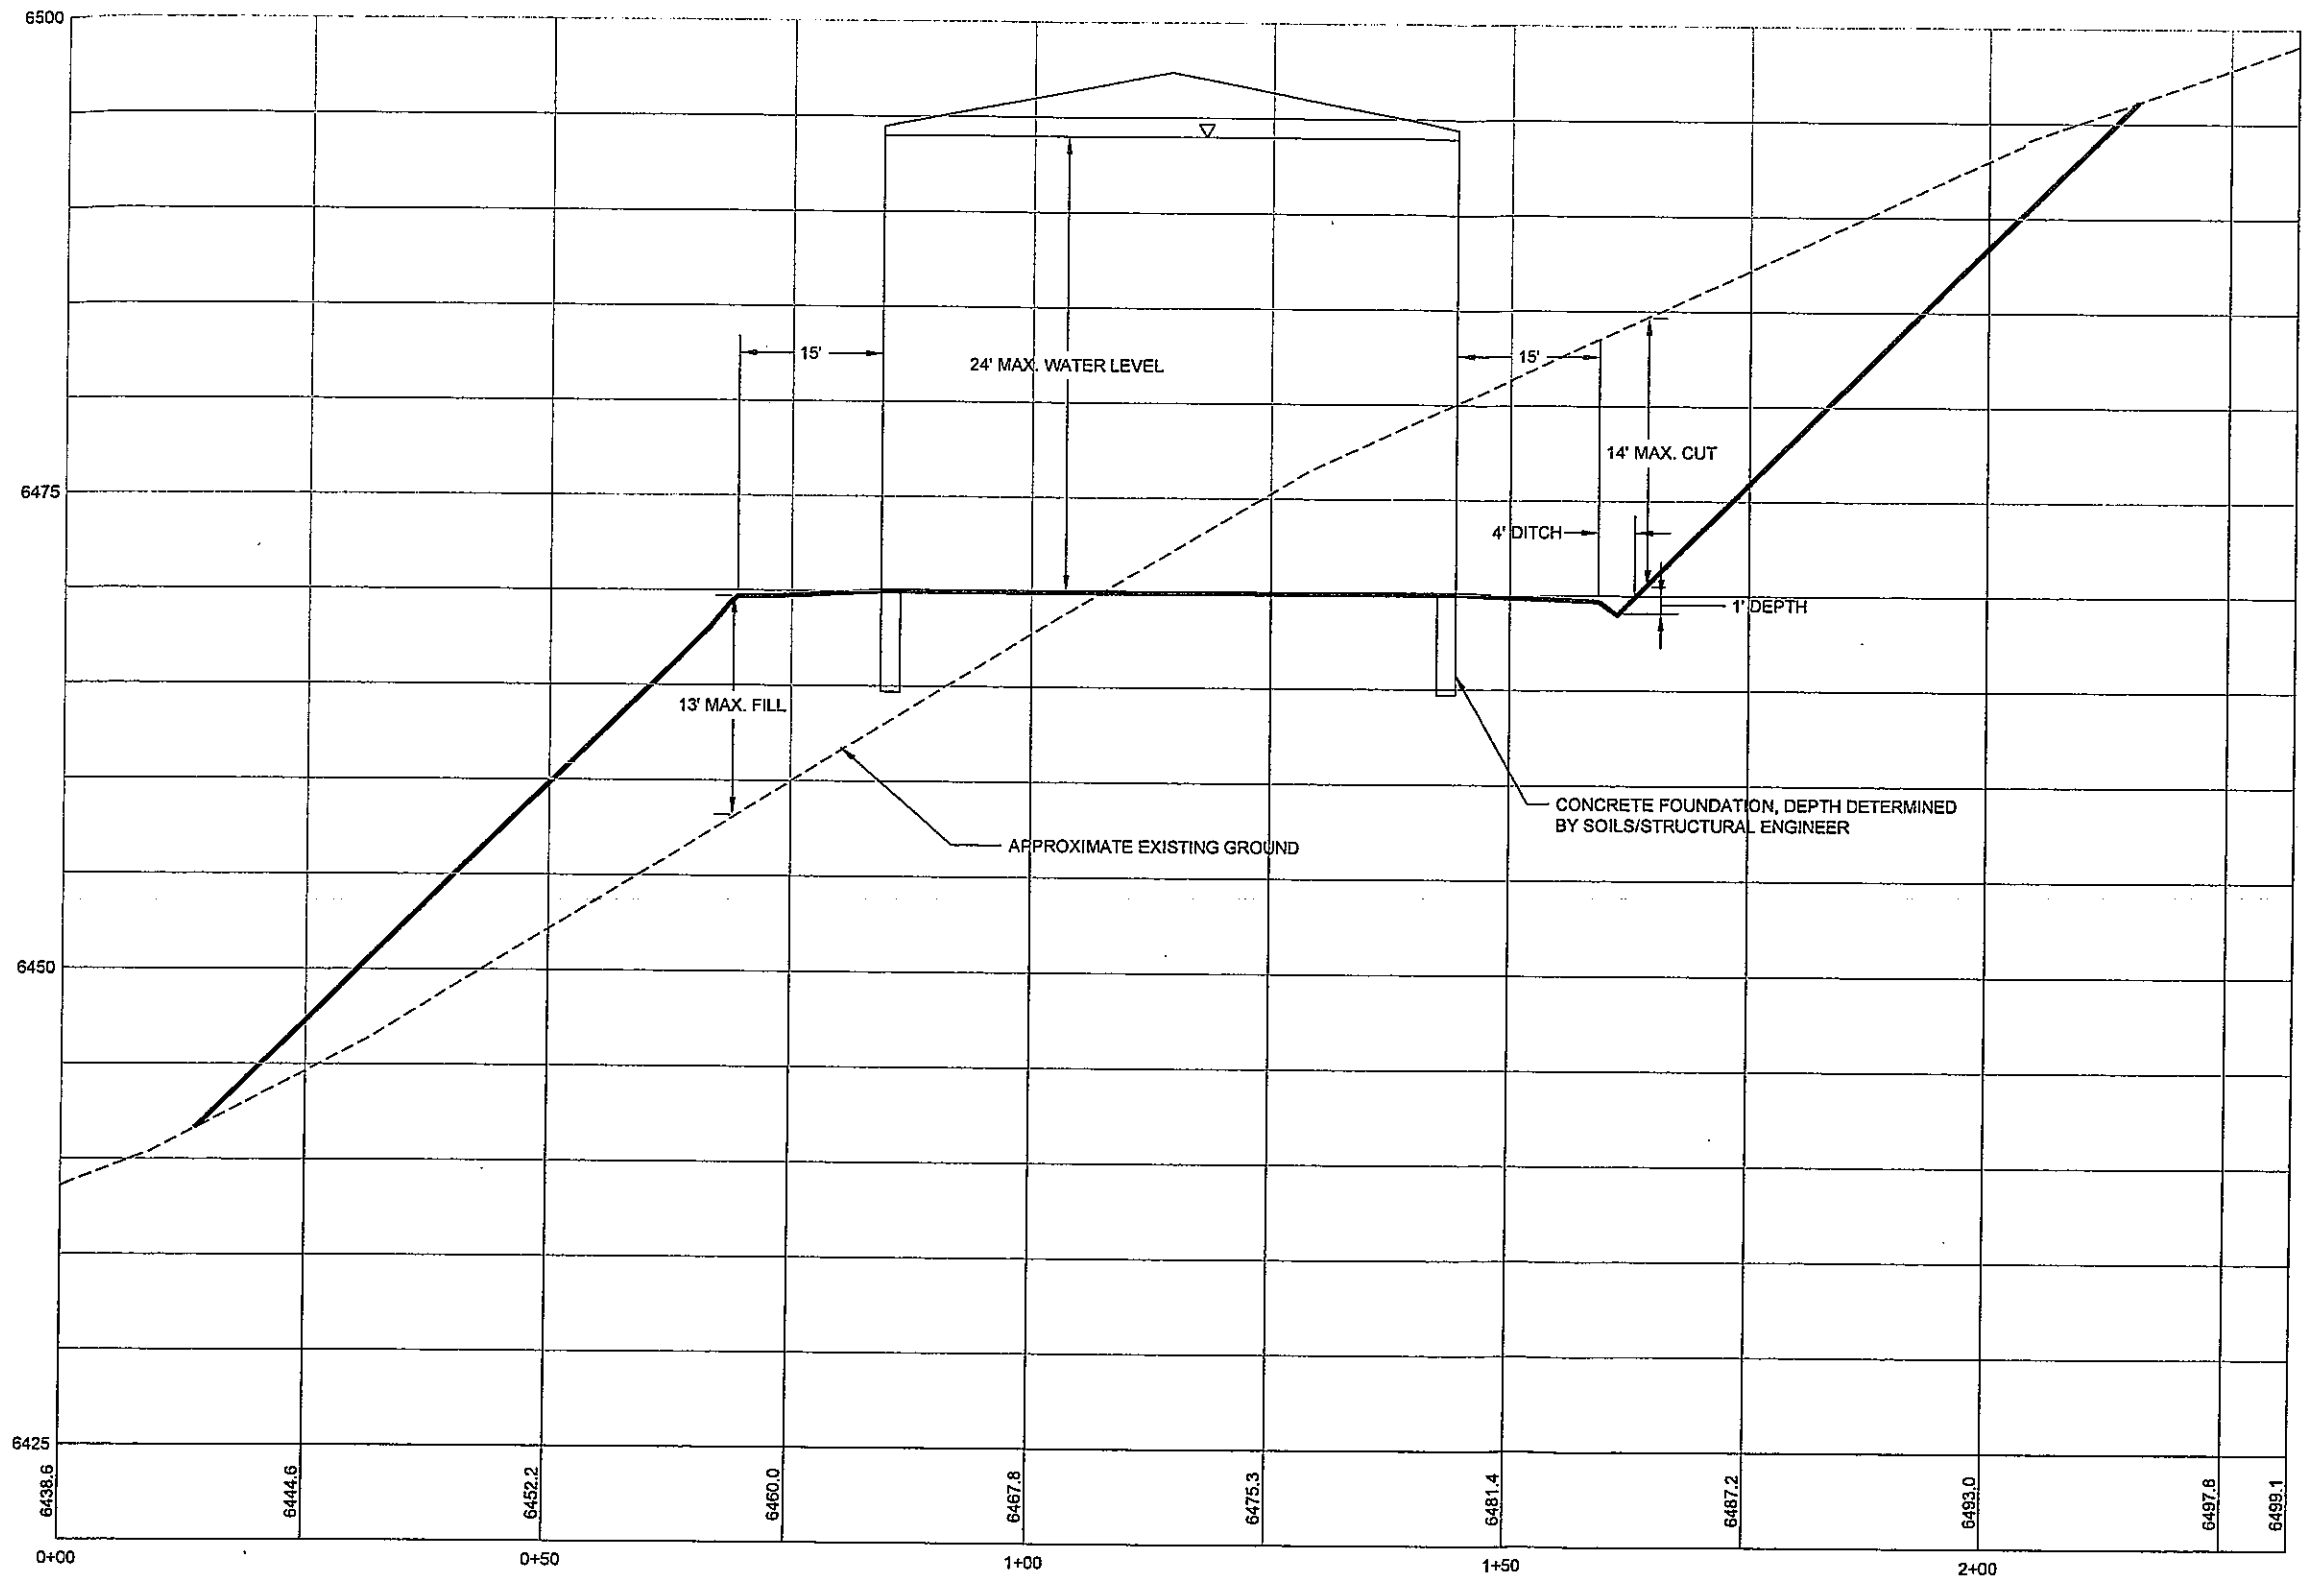


CROSS SECTION A-A

HORIZONTAL SCALE: 1" = 10'
VERTICAL SCALE: 1" = 5'




Prepared By: JTI Date: 04-03-03 Rev. Date: 12-12-07	RENDEZVOUS ENGINEERING, P.C. P.O. BOX 4858 JACKSON, WYOMING 83001 25 SOUTH GROS VENTRE STREET PHONE - 307.733.5252 FAX - 307.733.2334
PROJECT TITLE: RECORD DRAWINGS TETON SPRINGS	DRAWING TITLE: ASBUILT WATER PLANS WATER TANK SITE CROSS SECTION
PROJECT NUMBER: 00-023	DRAWING NUMBER: ASBW82

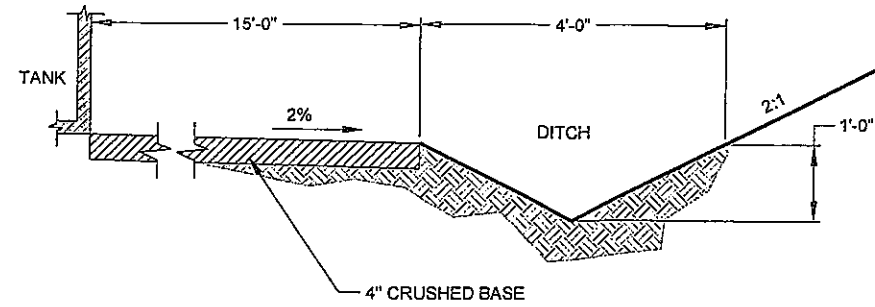

NOTE: SEE GRADING PLAN FOR DITCH ELEVATIONS


DITCH DETAIL
NOT TO SCALE

3
WS3

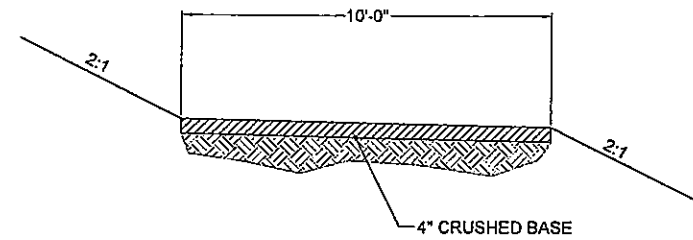

TYPICAL TANK ROAD SECTION
NOT TO SCALE


4
WS3

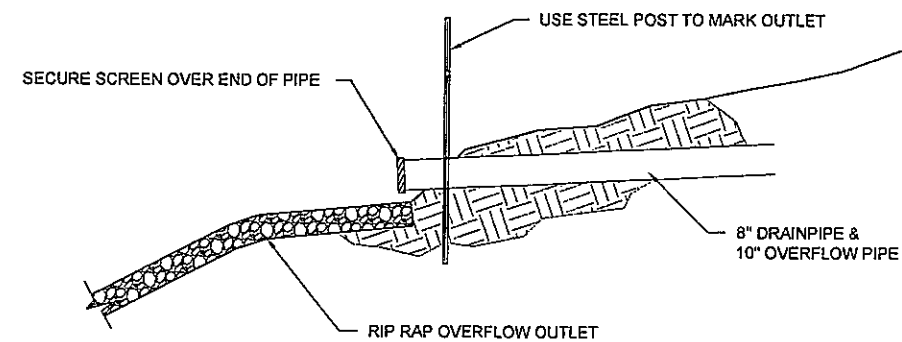

NOTE: USE SAME DETAIL FOR DRAINPIPE & OVERFLOW

PIPE OUTLET DETAIL
NOT TO SCALE


5
WS3

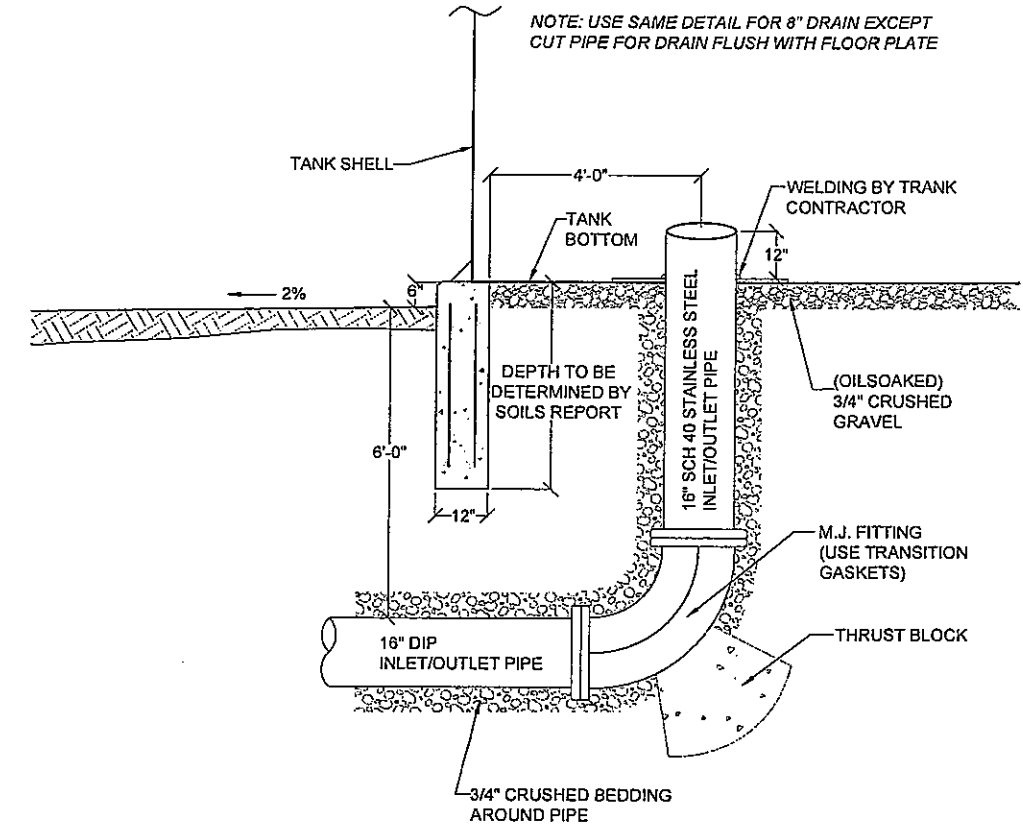

NOTE: USE SAME DETAIL FOR 8" DRAIN EXCEPT CUT PIPE FOR DRAIN FLUSH WITH FLOOR PLATE


TANK INLET/OUTLET DETAIL
NOT TO SCALE

1
WS3

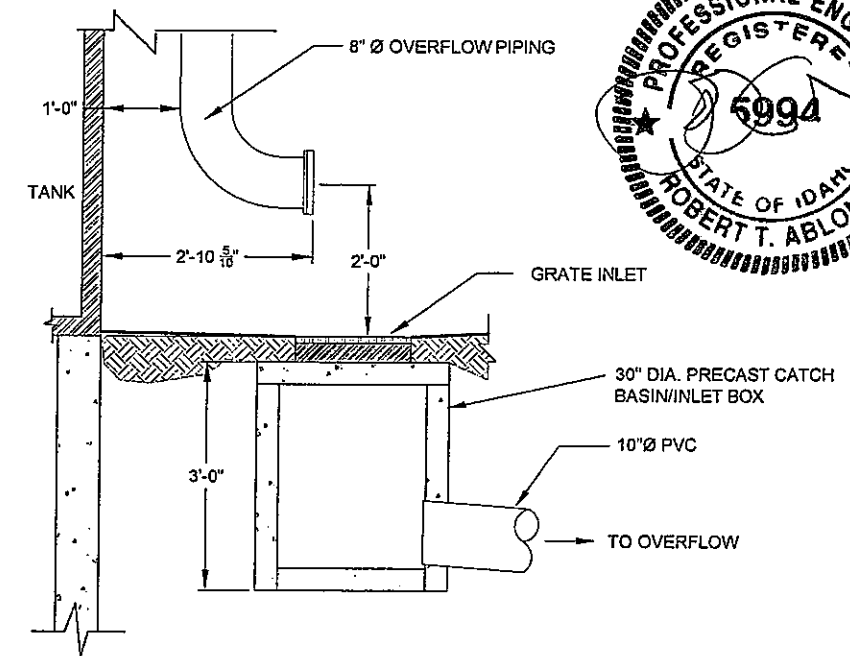

OVERFLOW INLET DETAIL
NOT TO SCALE

2
WS3

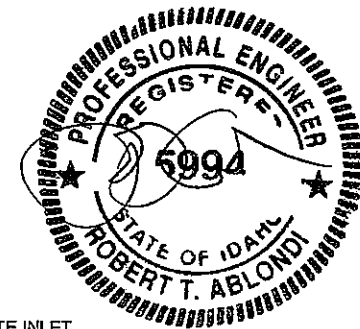

DRAWING TITLE:
ASBUILT WATER PLANS
WATER TANK DETAILS

PROJECT TITLE:
RECORD DRAWINGS
TETON SPRINGS

PROJECT NUMBER:
00-023

DRAWING NUMBER:
ASBW83

Prepared By: JPH
Date: 04/17/03
Rev. Date: 12/12/07


RENDEZVOUS ENGINEERING, P.C.
P.O. BOX 4853 JACKSON, WYOMING 83001
25 SOUTH GROS VENTRE STREET
PHONE - 307.733.5252 FAX - 307.733.2334

 
TETON SPRINGS GOLF & CASTING CLUB
VICTOR, IDAHO

500,000 GALLON WATER STORAGE TANK
60'-0"Ø X 24'-0" HIGH
PER AWWA D-100 CODES
LOCATED IN TETON SPRINGS, IDAHO



INDEX OF DRAWINGS:

- 1. GENERAL ELEVATION
- 2. PLAN VIEW
- 3. SHELL ROLL OUT
- 4. WELD DETAIL
- 5. FLOOR LAYOUT
- 6. ROOF LAYOUT
- 7. (2) 24" SHELL MANWAYS
- 8. RAFTER/CENTER COLUMN DETAIL
- 9. INLET/OUTLET THROUGH FLOOR
- 10. 8" OVERFLOW TO GRADE
- 11. LIQUID LEVEL INDICATOR
- 12. SHELL LADDER WITH SAFETY CLIMB
- 13. SHELL COUPLING FOR LEVEL TRANSDUCER
- 14. 24" SQUARE ROOF HATCH
- 15. 24" ROOF MANWAY
- 16. 12" ROOF VENT
- 17. ANTENNA MOUNTING BRACKET
- 18. 8' X 42" ROOF HANDRAILS
- 19. ANCHOR CHAIR DETAIL
- 20. ANCHOR BOLT LAYOUT
- 21. AWWA NAME PLATE WITH BRACKET
- 22. FOUNDATION DESIGN

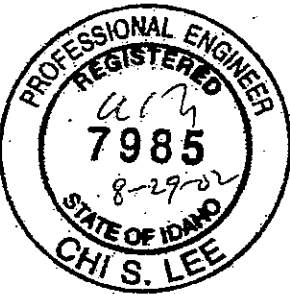

 PITTSBURG TANK & TOWER CO. GROUND TANK DIVISION HENDERSON, KENTUCKY	
SINCE 1919	
DESCRIPTION INDEX OF DRAWINGS	
CUSTOMERTETON SPGS. GOLF & CSTG. CLUB TETON SPRINGS, IDAHO	
DRAWN BY: JOE B.	JOB NO. 4742
CHECKED BY:	PROJ. MGR. JEFF BYRD
APPROVED BY: 	SHEET NO. INDEX
DATE 8/8/02	

NO.	REVISION	DATE	BY
This drawing and its designs are part of the intellectual property of PITTSBURG TANK & TOWER and may not be copied or used without the written permission of PITTSBURG TANK & TOWER. This drawing, its designs and any information hereon may not be disclosed to any third party without the written permission of PITTSBURG TANK & TOWER.			

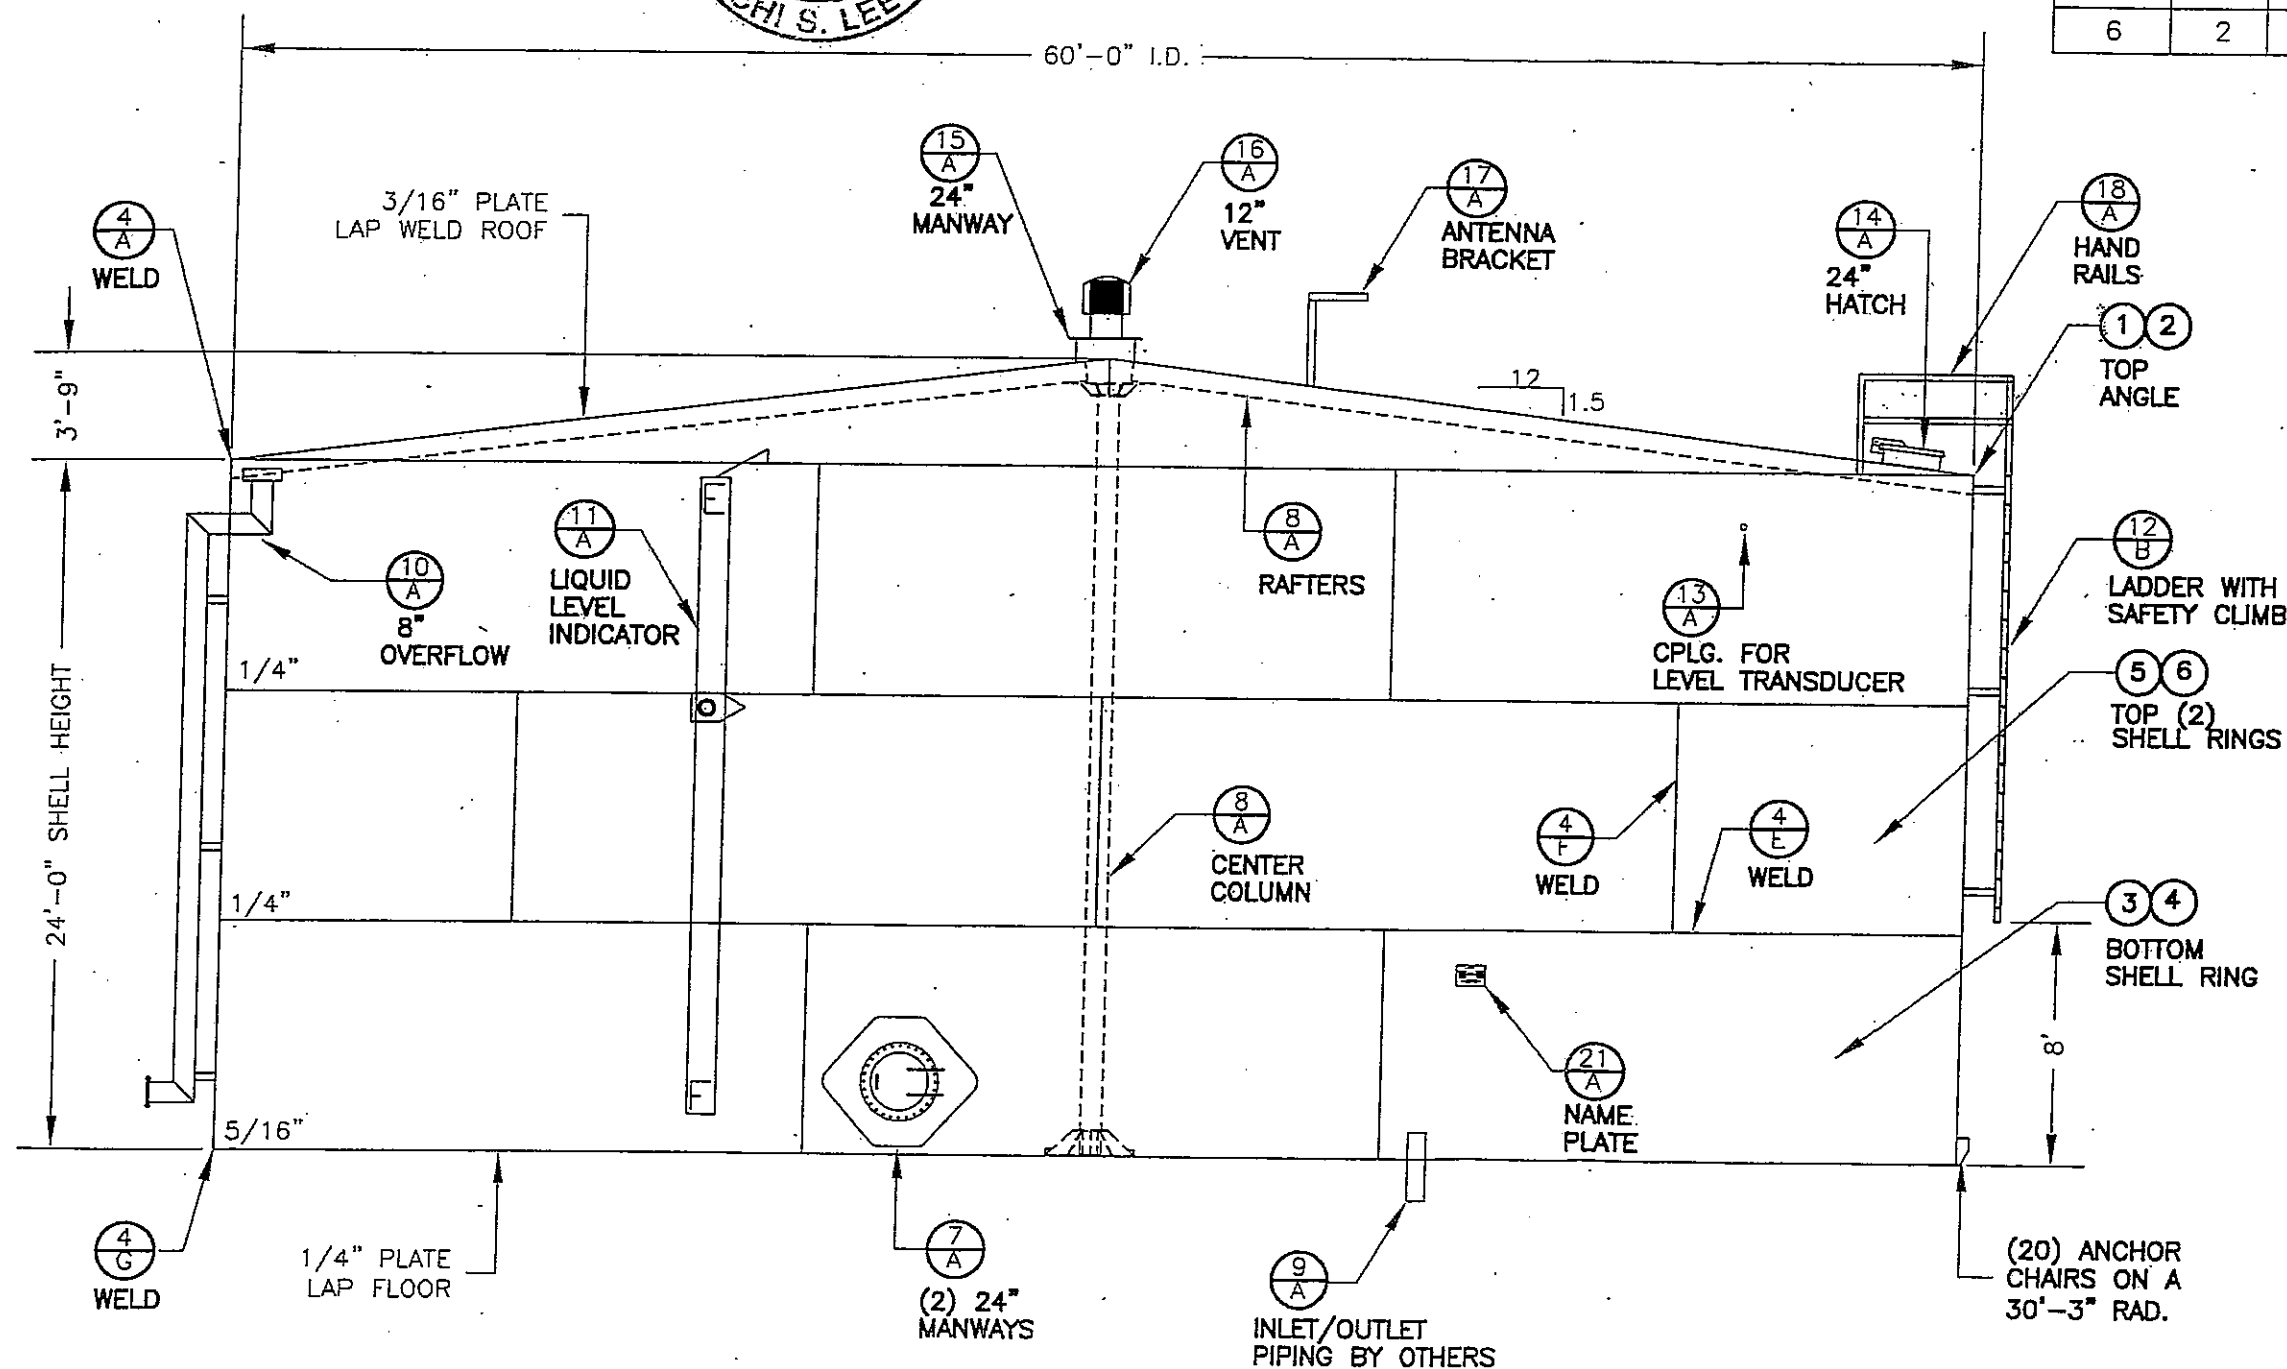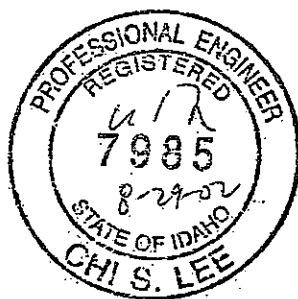

BILL OF MATERIAL

MK. NO.	QTY.	ASSY. PC.	DESCRIPTION
1	10		ANGLE A36 3 X 3 X 1/4" X 18'-0"
2	1		ANGLE A36 3 X 3 X 1/4" X 8'-5 15/16"
3	9		PLATE A36 5/16" X 8' X 19'-11"
4	1		PLATE A36 5/16" X 8' X 9'-2 15/16"
5	18		PLATE A36 1/4" X 8' X 19'-11"
6	2		PLATE A36 1/4" X 8' X 9'-2 15/16"

NOTES:

1. ALL WELDING TO BE IN ACCORDANCE WITH AWWA D100-96 AND AWS D5.2. ALL SHELL WELDS TO BE FULL FUSION WELDS.
2. ALL PLATES TO BE COLD ROLLED TO PROPER RADIUS.
3. ALL WORK TO BE IN ACCORDANCE WITH AWWA D100-96.
4. TANK TO BE COATED IN ACCORDANCE W/ CONTRACT SPECIFICATIONS.
5. ALL ACCESSORIES TO BE FIELD LOCATED AND/OR ORIENTED.
6. ALL PLATE MATERIAL IS TO BE A36. ALL BOLTS ARE A325. ALL PIPE IS A53 GR. B. ALL STRUCTURAL IS A36.
7. EXTERIOR LADDER TO BE EQUIPPED WITH SAFETY DEVICE.
8. FOUNDATION SHALL BE DESIGNED BY PT&T, AND FURNISHED BY OTHERS.
9. TANK SHALL BE FILLED WITH WATER TO MAXIMUM WORKING LEVEL AND CHECKED FOR LEAKS PRIOR TO BEING PUT INTO SERVICE BY OTHERS.

LEGEND:

PAGE NO.
DETAIL LTR.

DESIGN LOADING:

SNOW - 100 PSF
WIND - 100 MPH
SEISMIC - ZONE 3




PITTSBURG TANK & TOWER CO.
GROUND TANK DIVISION
HENDERSON, KENTUCKY

DESCRIPTION GENERAL ELEVATION
500,000 GALLON TANK

CUSTOMER TETON SPGS. GOLF & CSG. CLUB
TETON SPRINGS, IDAHO

DRAWN BY: JOE B.	JOB NO. 4742
CHECKED BY:	PROJ. MGR. JEFF BYRD
APPROVED BY: <i>[Signature]</i>	SHEET NO. 1
DATE 8/9/02	SCALE NONE

NO.	REVISION	DATE	BY
This drawing and its designs are part of the intellectual property of PITTSBURG TANK & TOWER and may not be copied or used without the written permission of PITTSBURG TANK & TOWER. This drawing, its designs and any information hereon may not be disclosed to any third party without the written permission of PITTSBURG TANK & TOWER.			

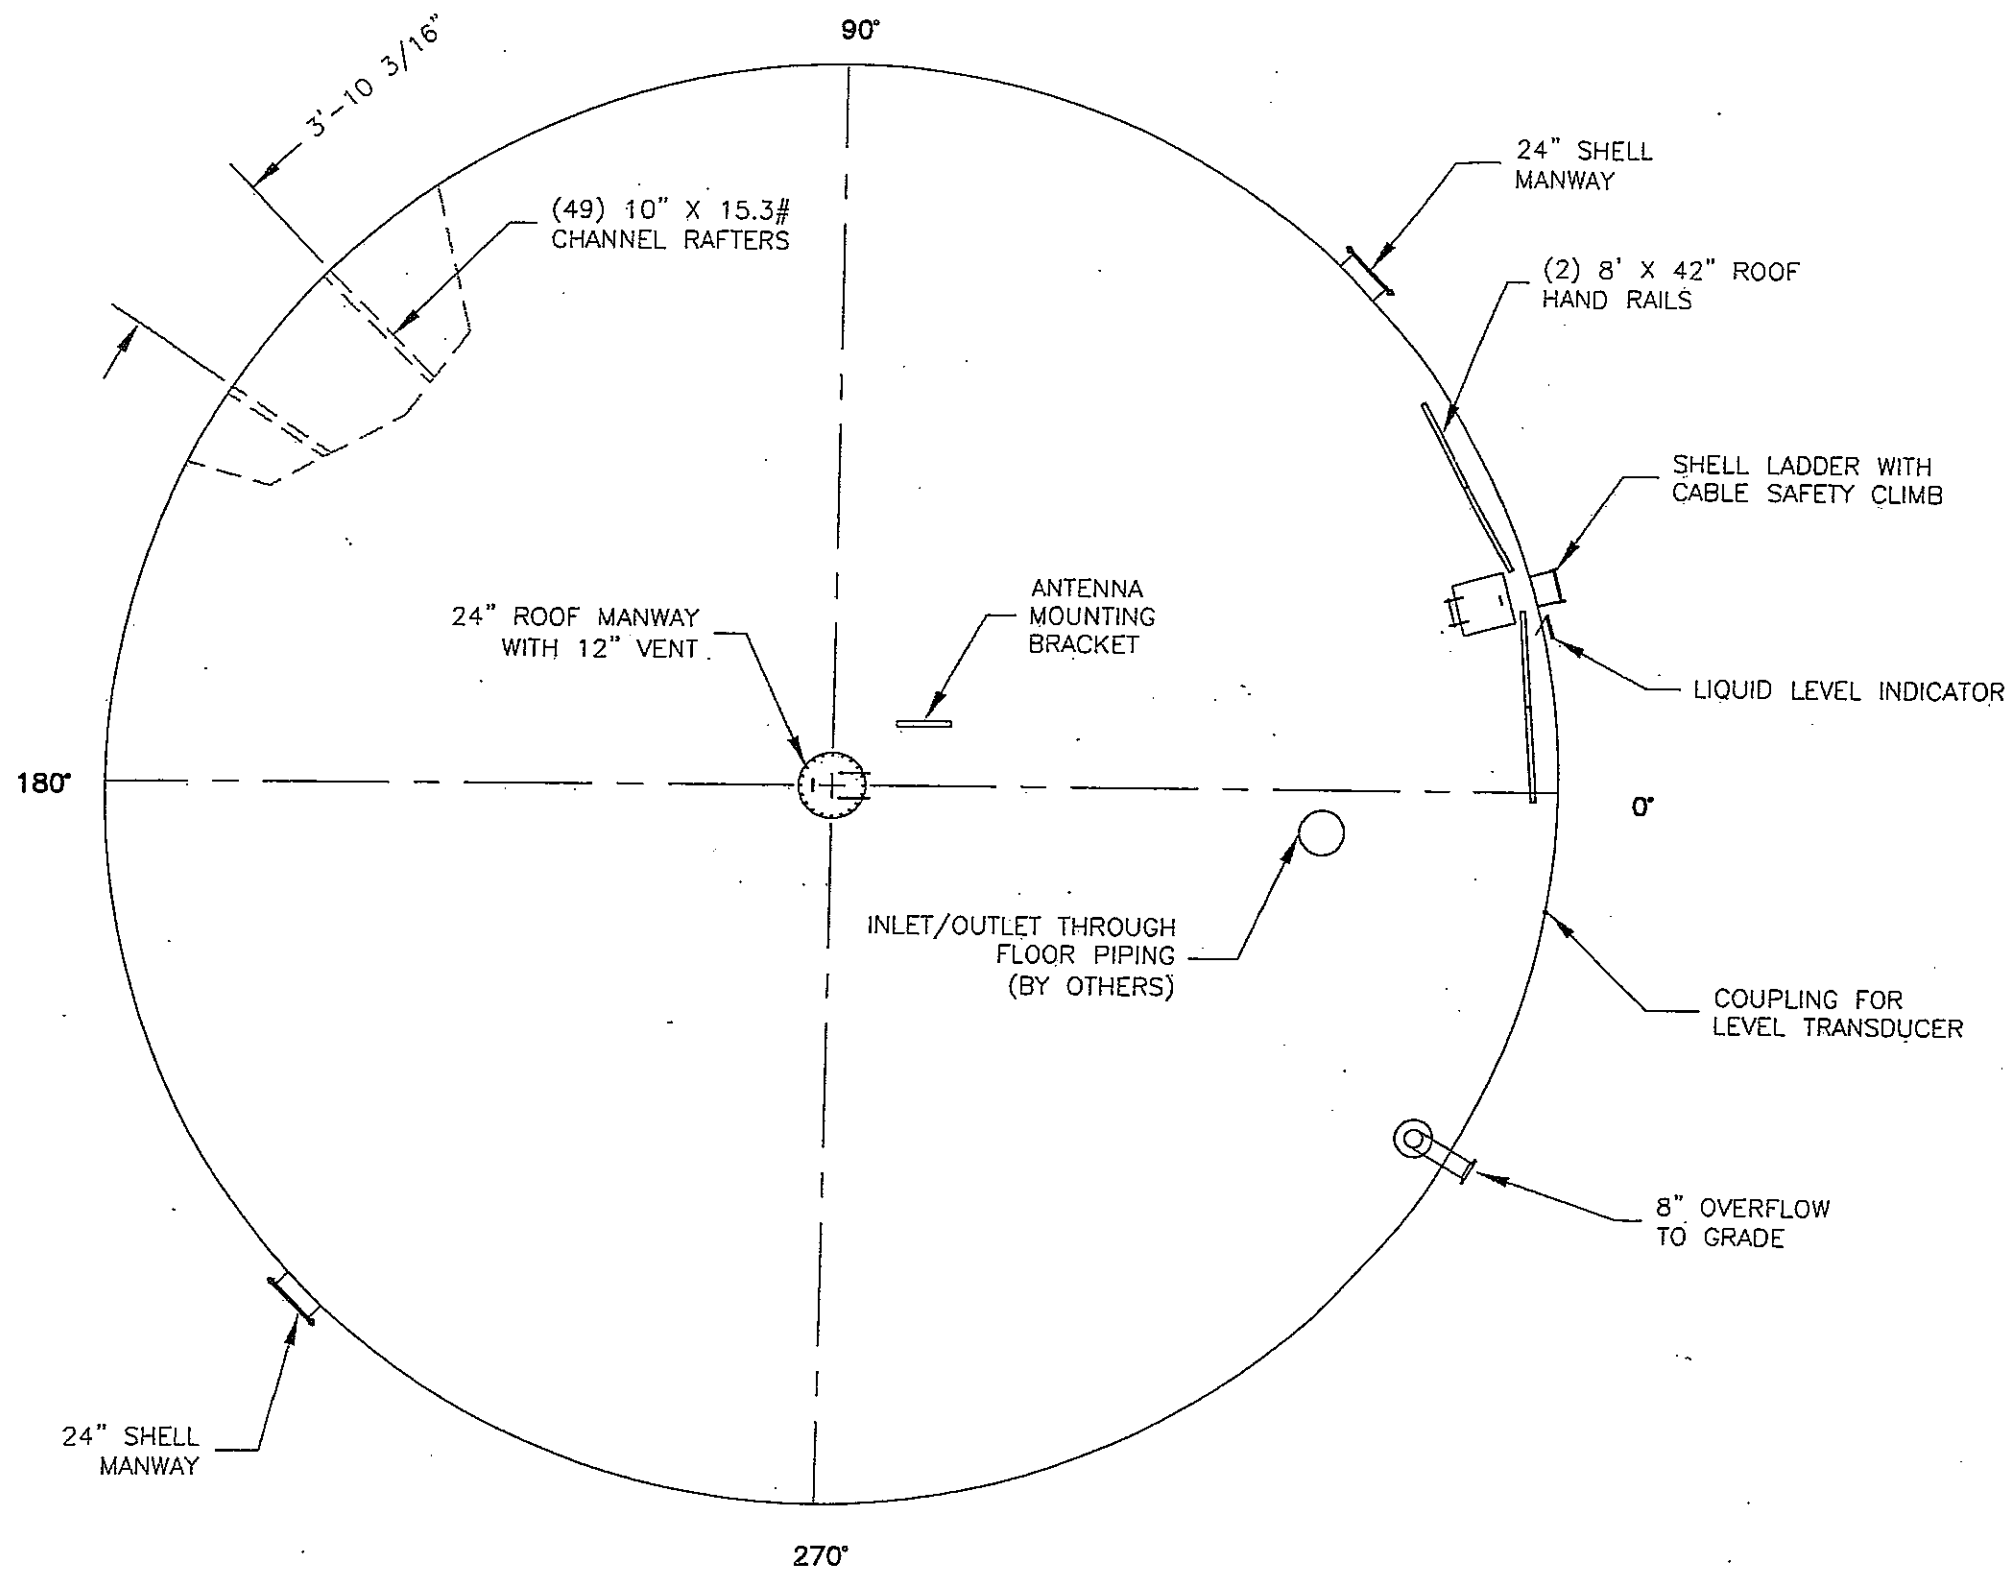


CUSTOMER TO VERIFY LOCATION OF ALL ACCESSORIES IN FIELD.

1" = 6 5/16"

		PITTSBURG TANK & TOWER CO. GROUND TANK DIVISION HENDERSON, KENTUCKY	
SINCE 1919			
DESCRIPTION PLAN VIEW			
CUSTOMER TETON SPGS. GOLF & CSTG. CLUB TETON SPRINGS, IDAHO			
DRAWN BY: JOE B.		JOB NO. 4742	
CHECKED BY:		PROJ. MGR. JEFF BYRD	
APPROVED BY: <i>[Signature]</i>		SHEET NO. 2	
DATE 8/9/02		SCALE NONE	

NO.	REVISION	DATE	BY
This drawing and its designs are part of the intellectual property of PITTSBURG TANK & TOWER and may not be copied or used without the written permission of PITTSBURG TANK & TOWER. This drawing, its designs and any information hereon may not be disclosed to any third party without the written permission of PITTSBURG TANK & TOWER.			

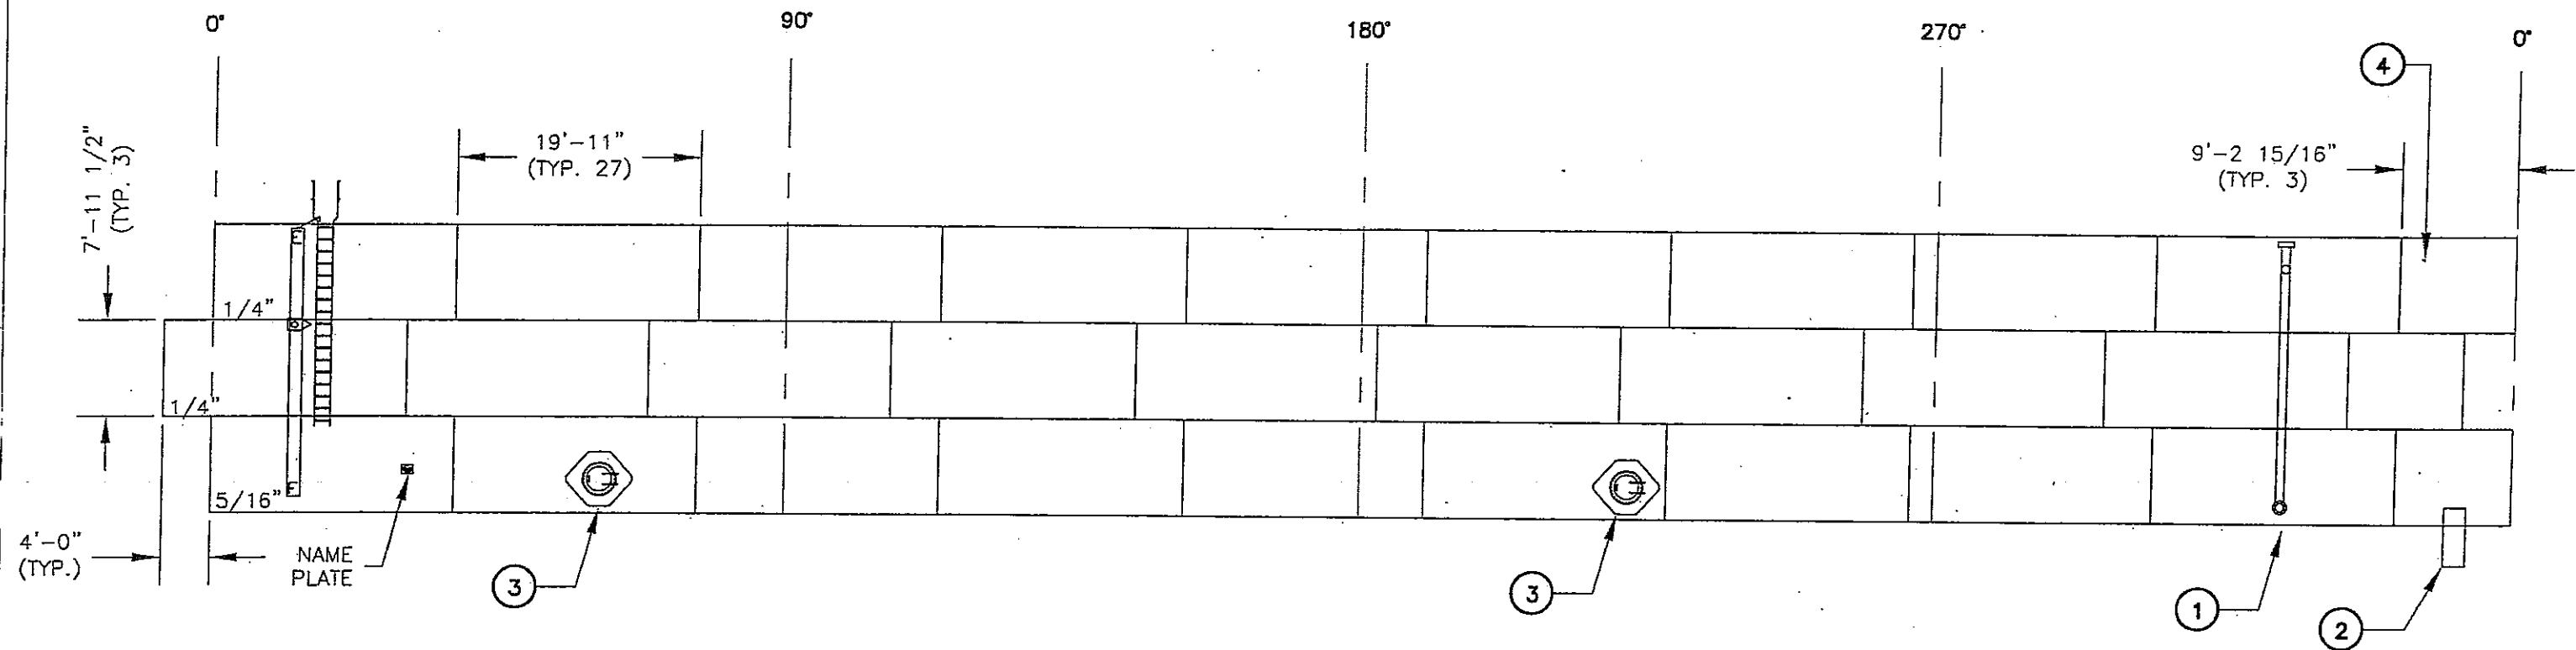


CONNECTION SCHEDULE					
NO.	QUA.	SIZE	ELEV.	LOC.	DESCRIPTION
1	1	8"	2'-0"		OVERFLOW
2	1	*	FLOOR		INLET/OUTLET
3	2	24"	2'-6"		SHELL MANWAY
4	1	2"	22'-5 1/2"		CPLG. FOR LEVEL TRANSDUCER


* SIZE TO BE VERIFIED
BY CUSTOMER

NO.	REVISION	DATE	BY
This drawing and its designs are part of the intellectual property of PITTSBURG TANK & TOWER and may not be copied or used without the written permission of PITTSBURG TANK & TOWER. This drawing, its designs and any information hereon may not be disclosed to any third party without the written permission of PITTSBURG TANK & TOWER.			


 PITTSBURG TANK & TOWER CO. SINCE 1919		GROUND TANK DIVISION HENDERSON, KENTUCKY	
DESCRIPTION SHELL ROLL OUT			
CUSTOMER TETON SPGS. GOLF & CSTG. CLUB TETON SPRINGS, IDAHO			
DRAWN BY: JOE B.		JOB NO. 4742	
CHECKED BY:		PROJ. MGR. JEFF. BYRD	
APPROVED BY: <i>[Signature]</i>		SHEET NO. 3	
DATE 8/9/02		SCALE NONE	

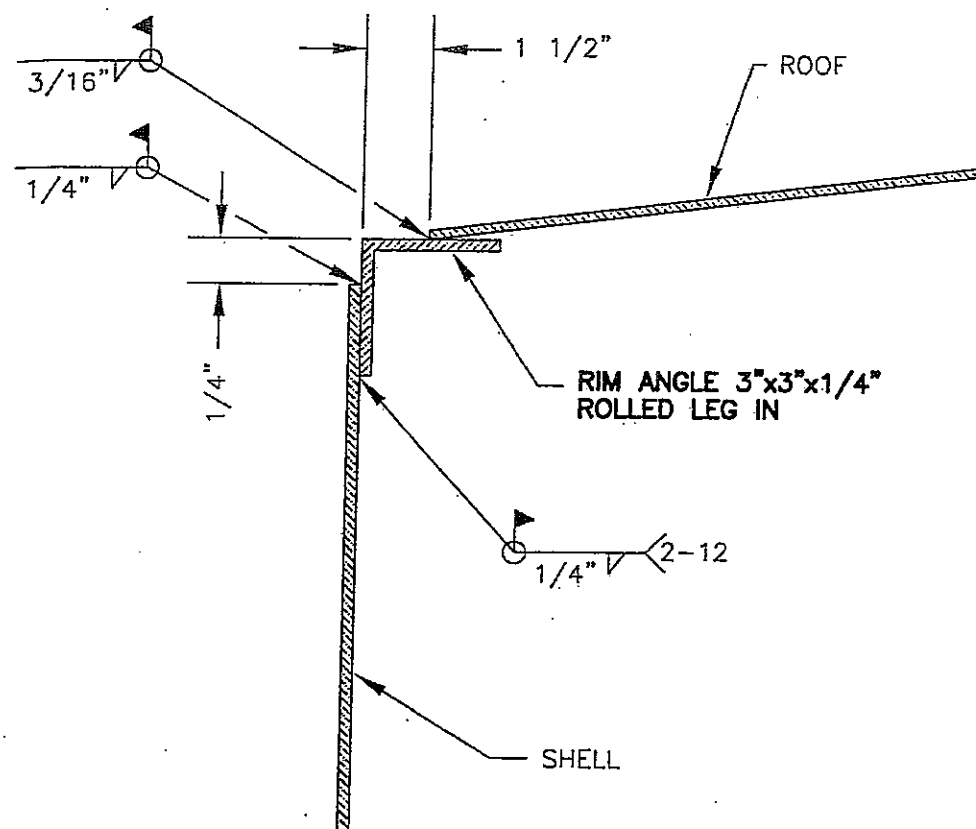


DETAIL "A"
SHELL TO ROOF WELD

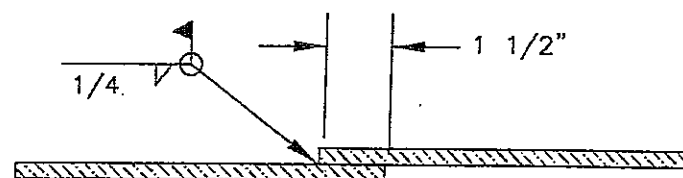


DETAIL "B"
FLOOR PLATES WELD

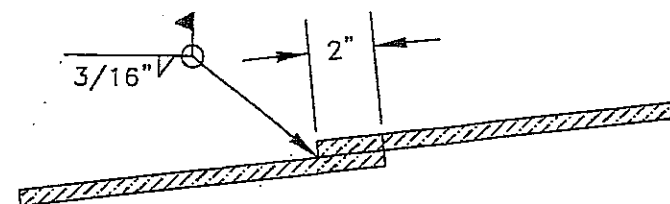


DETAIL "D"
ROOF PLATES WELD

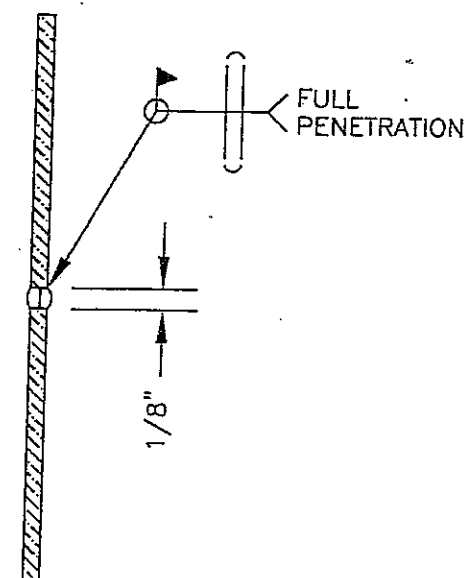

DETAIL "E"
HORIZONTAL WELD
(PLATE 5/16" THICK OR LESS)

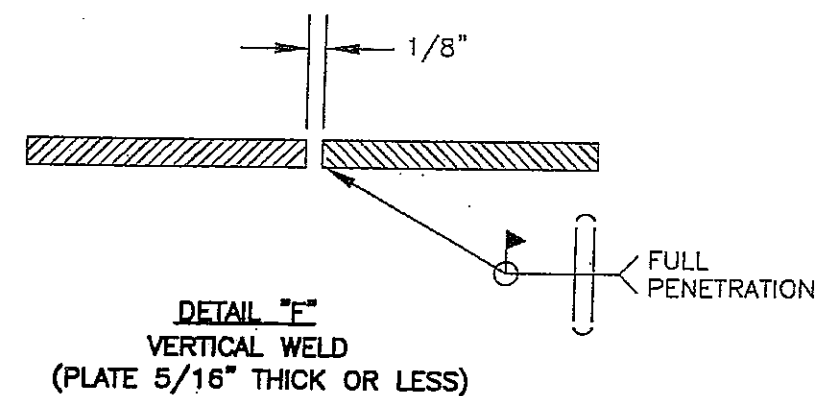

DETAIL "F"
VERTICAL WELD
(PLATE 5/16" THICK OR LESS)

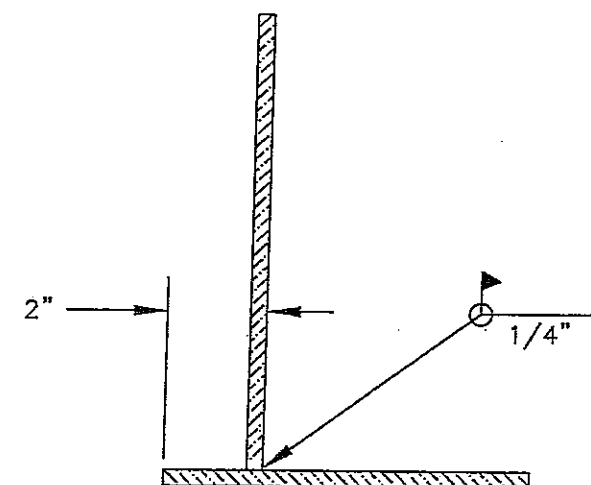

DETAIL "G"
SHELL TO FLOOR WELD




PITTSBURG TANK & TOWER CO.
GROUND TANK DIVISION
HENDERSON, KENTUCKY

DESCRIPTION WELD DETAIL



CUSTOMER TETON SPGS. GOLF & CSTG. CLUB
TETON SPRINGS, IDAHO

DRAWN BY: JOE B.	JOB NO. 4742
CHECKED BY:	PROJ. MGR. JEFF BYRD
APPROVED BY: <i>[Signature]</i>	SHEET NO. 4
DATE 8/9/02	SCALE NONE

NO.	REVISION	DATE	BY
This drawing and its designs are part of the intellectual property of PITTSBURG TANK & TOWER and may not be copied or used without the written permission of PITTSBURG TANK & TOWER. This drawing, its designs and any information hereon may not be disclosed to any third party without the written permission of PITTSBURG TANK & TOWER.			

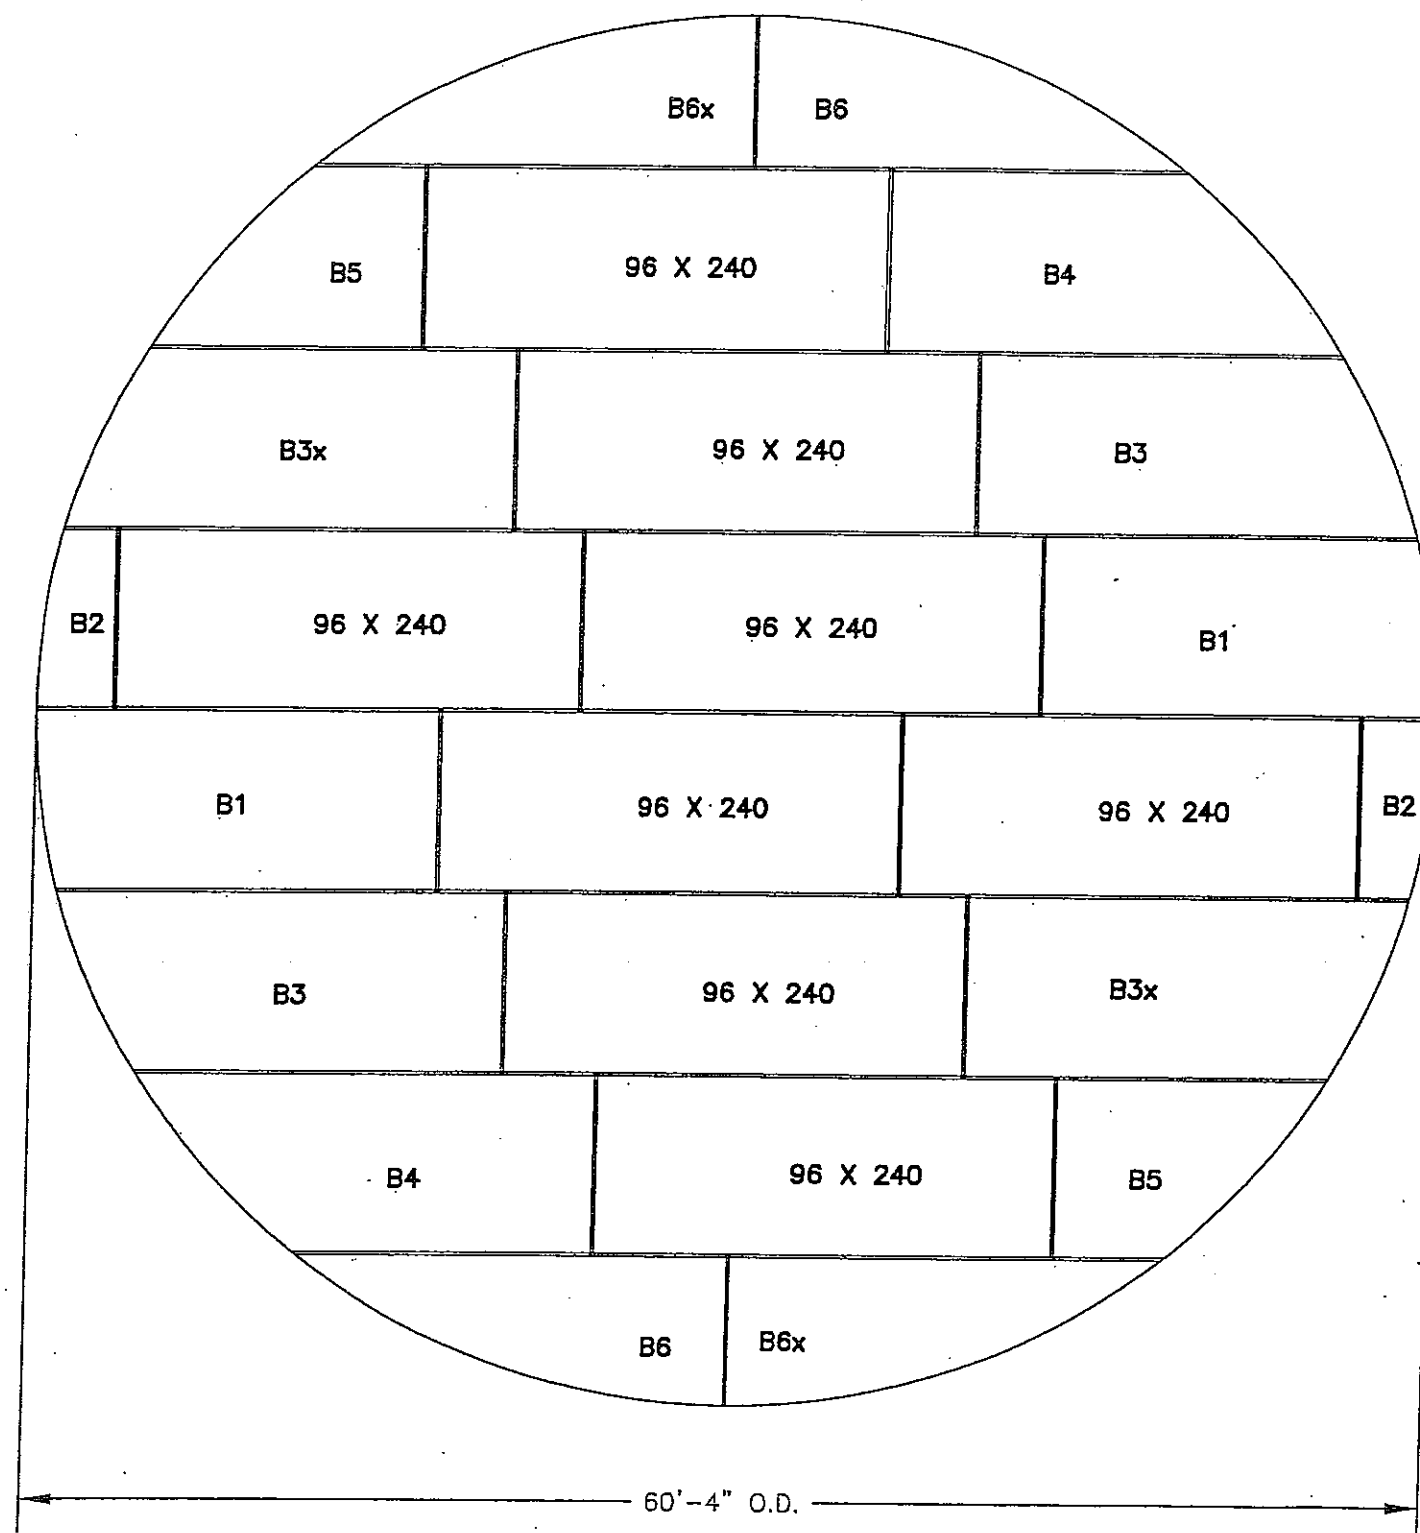





BILL OF MATERIAL			
MK. NO.	QTY.	ASSY. PC.	DESCRIPTION
B1	2		PLATE A36 1/4" X 8' X "SK"
B2	2		PLATE A36 1/4" X 8' X "SK"
B3	4		PLATE A36 1/4" X 8' X "SK"
B4	2		PLATE A36 1/4" X 8' X "SK"
B5	2		PLATE A36 1/4" X 8' X "SK"
B6	4		PLATE A36 1/4" X "SK"
B7	8		PLATE A36 1/4" X 8' X 20'

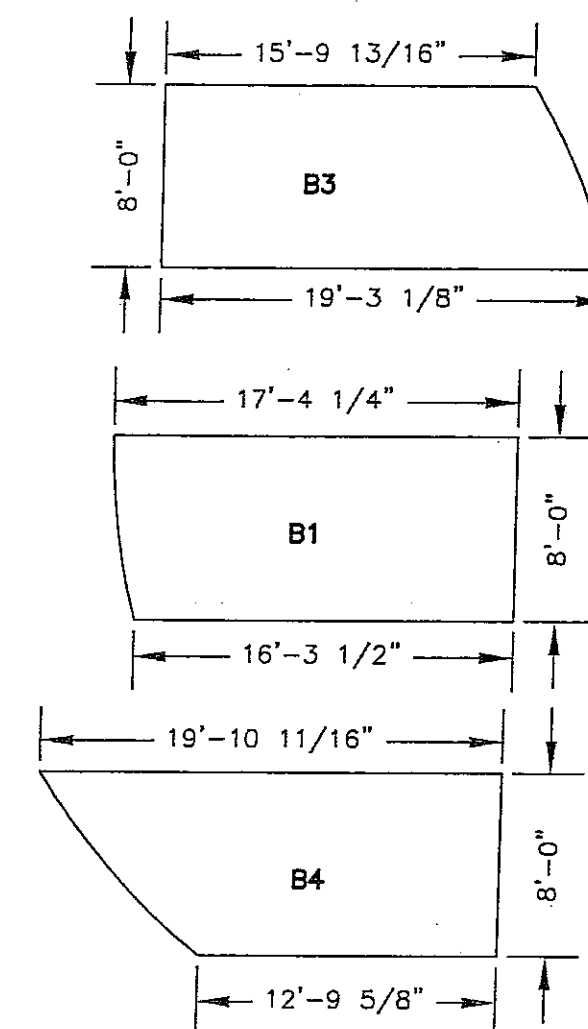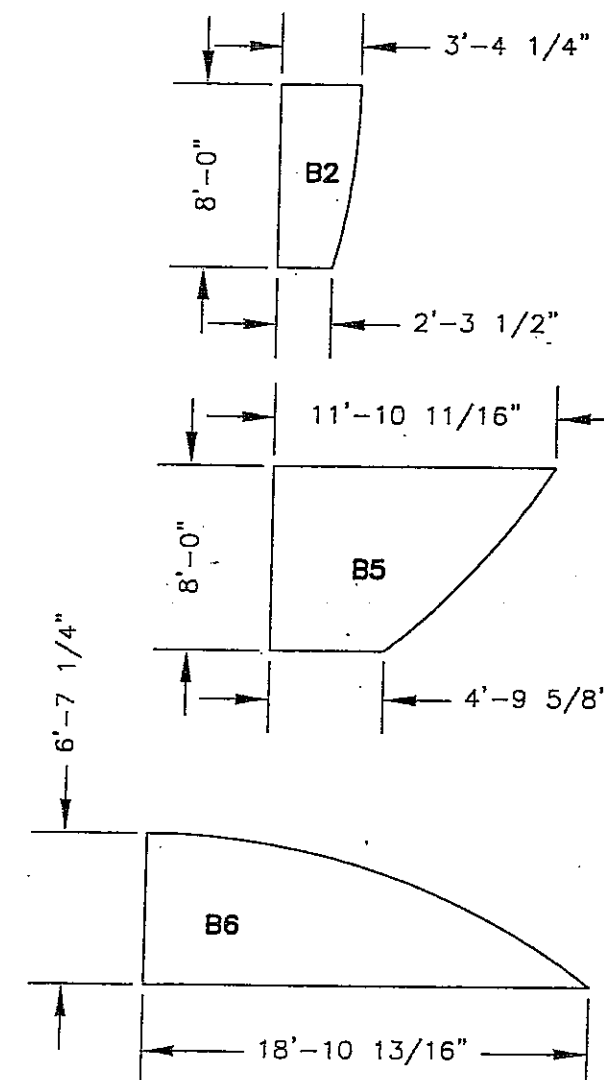

- NOTES:
 1) 30'-2" CUT RADIUS FLOOR
 2) FOR A 60'-0" TANK








NO.	REVISION	DATE	BY
This drawing and its designs are part of the intellectual property of PITTSBURG TANK & TOWER and may not be copied or used without the written permission of PITTSBURG TANK & TOWER. This drawing, its designs and any information hereon may not be disclosed to any third party without the written permission of PITTSBURG TANK & TOWER.			

 		PITTSBURG TANK & TOWER CO.	
SINCE 1919		GROUND TANK DIVISION HENDERSON, KENTUCKY	
DESCRIPTION FLOOR LAYOUT			
CUSTOMER TETON SPGS. GOLF & CSTG. CLUB TETON SPRINGS, IDAHO			
DRAWN BY: JOE B.		JOB NO. 4742	
CHECKED BY:		PROJ. MGR. JEFF BYRD	
APPROVED BY: 		SHEET NO. 5	
DATE 8/9/02		SCALE NONE	

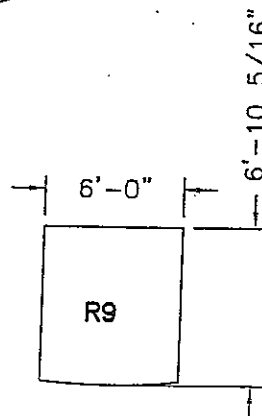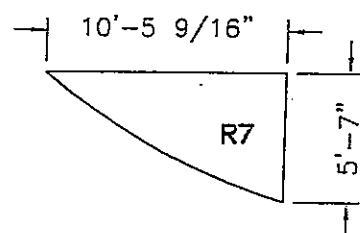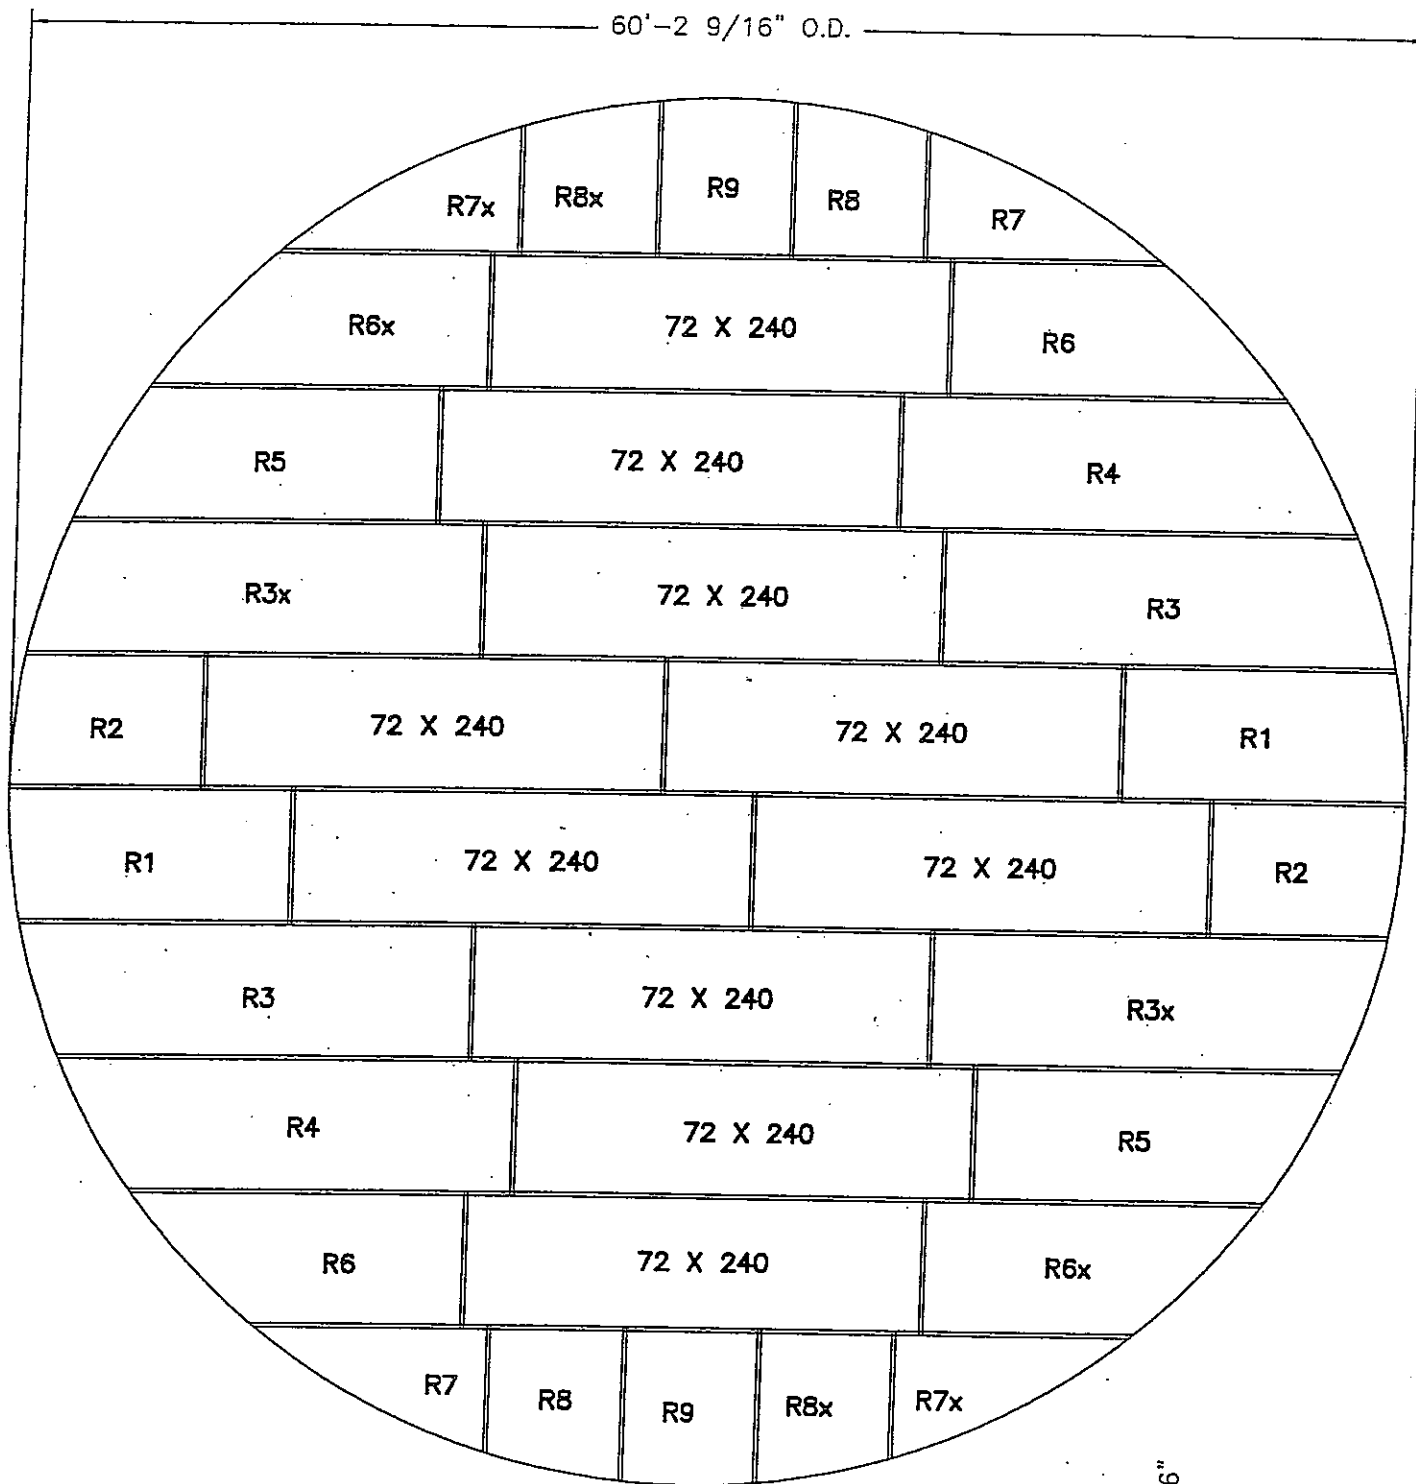

BILL OF MATERIAL

MK. NO.	QTY.	ASSY. PC.	DESCRIPTION
R1	2		PLATE A36 3/16" X 6' X "SK"
R2	2		PLATE A36 3/16" X 6' X "SK"
R3	4		PLATE A36 3/16" X 6' X "SK"
R4	2		PLATE A36 3/16" X 6' X "SK"
R5	2		PLATE A36 3/16" X 6' X "SK"
R6	4		PLATE A36 3/16" X 6' X "SK"
R7	4		PLATE A36 3/16" X "SK"
R8	4		PLATE A36 3/16" X 6' X "SK"
R9	2		PLATE A36 3/16" X 6' X "SK"
R10	10		PLATE A36 3/16" X 6' X 20'

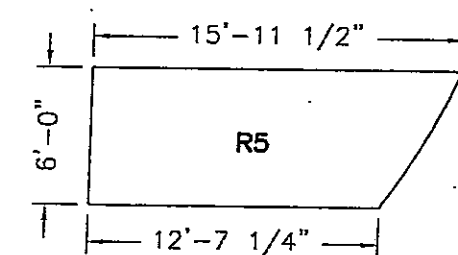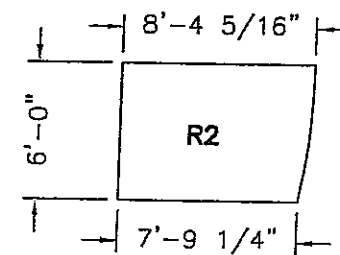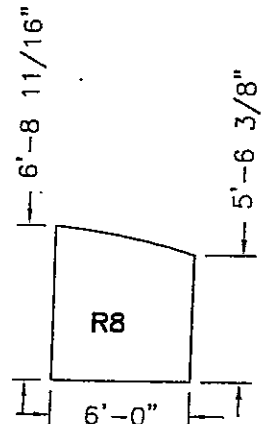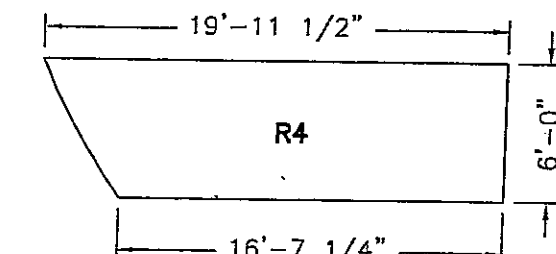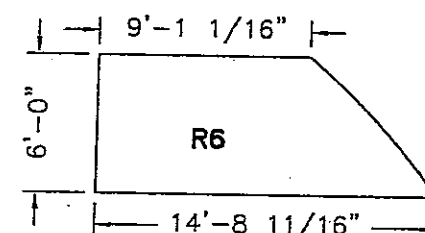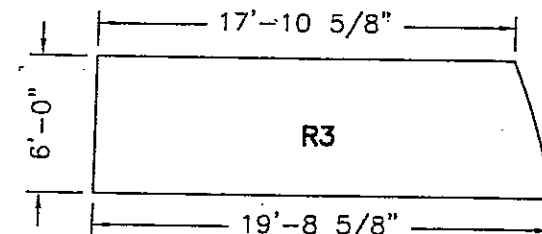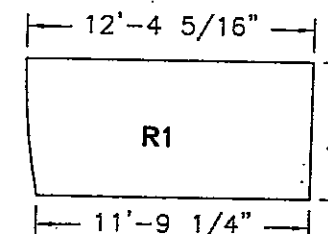

NOTES:

- 30'-1 9/32" CUT RADIUS ROOF
- FOR A 60'-0" TANK

NO.	REVISION	DATE	BY

This drawing and its designs are part of the intellectual property of PITTSBURGH TANK & TOWER and may not be copied or used without the written permission of PITTSBURGH TANK & TOWER. This drawing, its designs and any information hereon may not be disclosed to any third party without the written permission of PITTSBURGH TANK & TOWER.




PITTSBURGH TANK & TOWER CO.
GROUND TANK DIVISION
HENDERSON, KENTUCKY

DESCRIPTION ROOF LAYOUT


CUSTOMER TETON SPGS. GOLF & CSTG. CLUB
TETON SPRINGS, IDAHO

DRAWN BY: JOE B.	JOB NO. 4742
CHECKED BY:	PROJ. MGR. JEFF BYRD
APPROVED BY: <i>[Signature]</i>	SHEET NO. 6
DATE 8/9/02	SCALE NONE

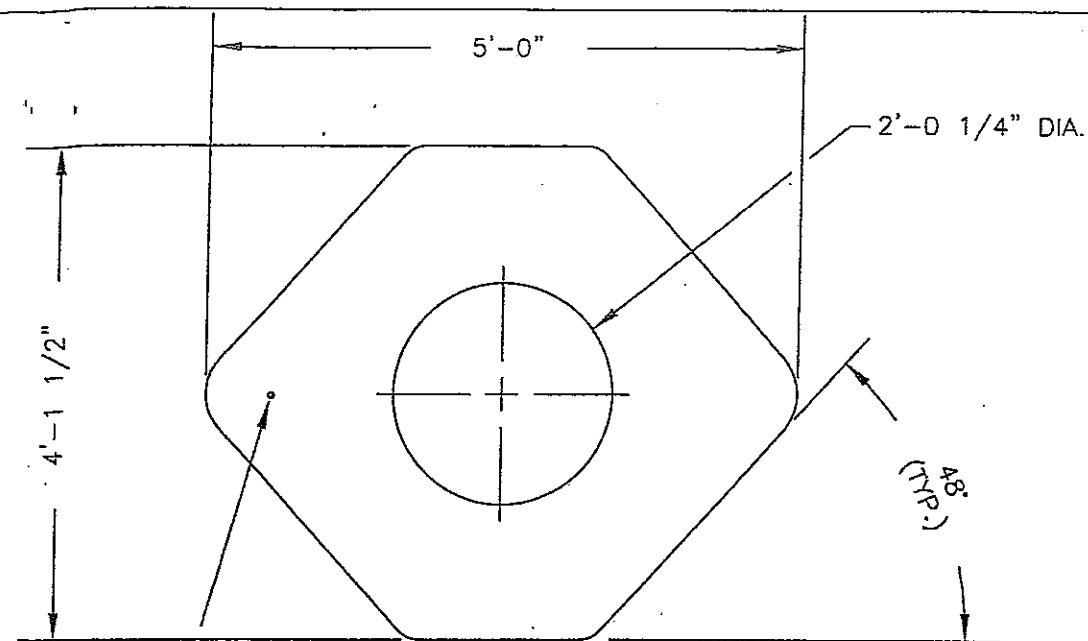


DRILL AND TAP A 1/4" HOLE IN REINFORCING PLATE, ON HORIZONTAL CENTERLINE.


⑪ REINF. PLATE DETAIL

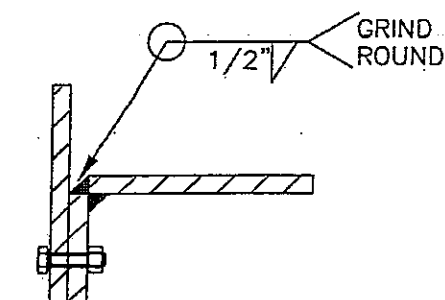


DETAIL "B"

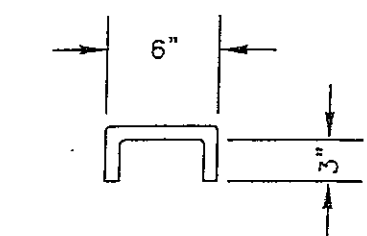


④ HANDLE DETAIL

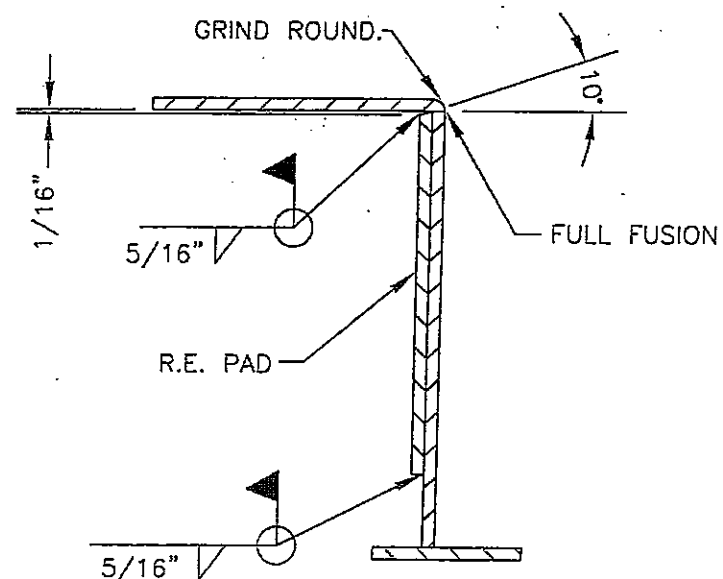


DETAIL "A"

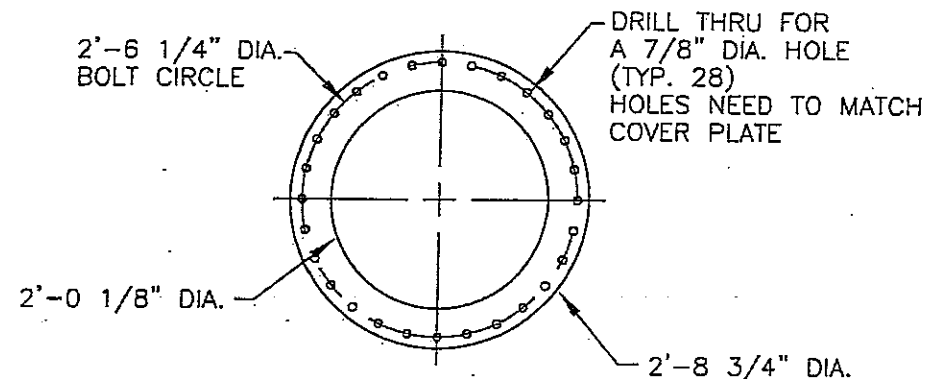


② ③ FLANGE & GASKET DETAIL

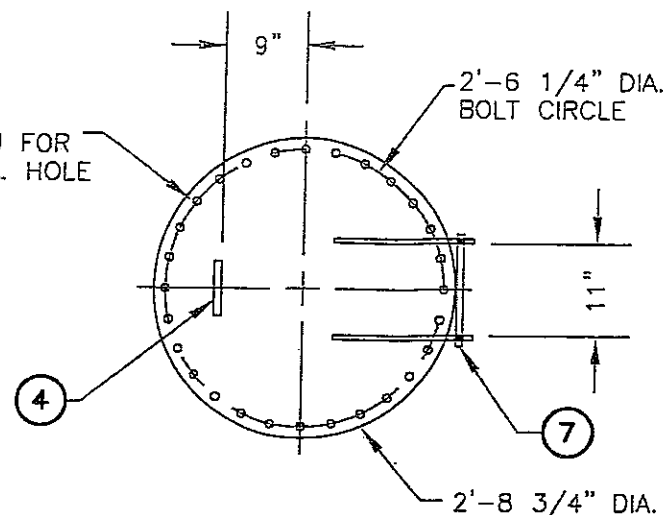

① COVER PLATE DETAIL

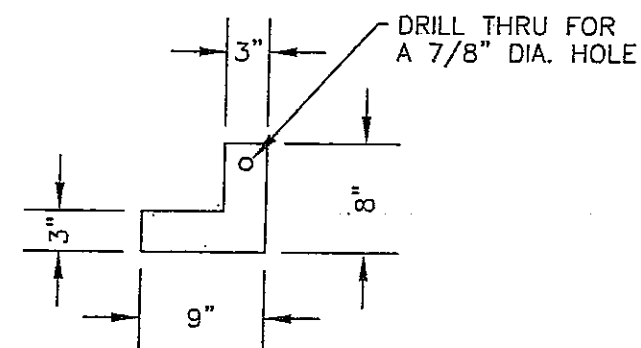

⑤ HINGE DETAIL (TYP. 2)

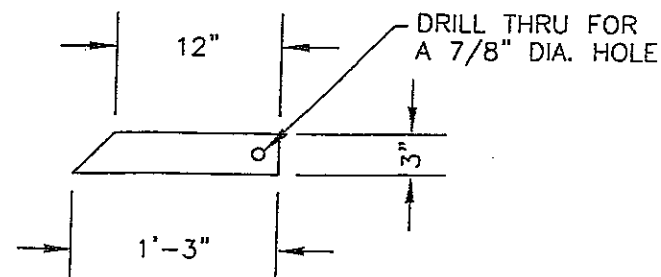


⑥ HINGE DETAIL (TYP. 2)

NOTE: ROLL REPAD TO 30'-0" RADIUS

BILL OF MATERIAL

MK. NO.	QTY.	ASSY. PC.	DESCRIPTION
A	2		24" DIA. MANWAY
1		1	PLATE, A-36 2'-8 3/4" DIA. x 1/2" THICK
2		1	PLATE, A-36 2'-8 3/4" O.D. x 1/2"
			2'-0 1/8" I.D.
3		1	GASKET, RED RUBBER 2'-8 3/4" O.D. x
			2'-0 1/8" I.D.
4		1	BAR A-36 3/4" DIA. x 1'-0" LNG
5		2	PLATE, A-36 9" x 1/2" x 8"
6		2	PLATE, A-36 1'-3" x 1/2" x 3"
7		1	BAR, A-36 3/4" DIA. x 1'0" LNG
8		1	PIPE, A-36 2'-0" DIA. x 1/2" x 9 3/4"
9		28	BOLTS, A325 3/4" DIA. x 2 1/2" LNG
10		28	NUTS, A325 HEX 3/4" DIA.
11	2		PLATE, A-36 4'-1 1/2" x 5/16" x 5'-0"

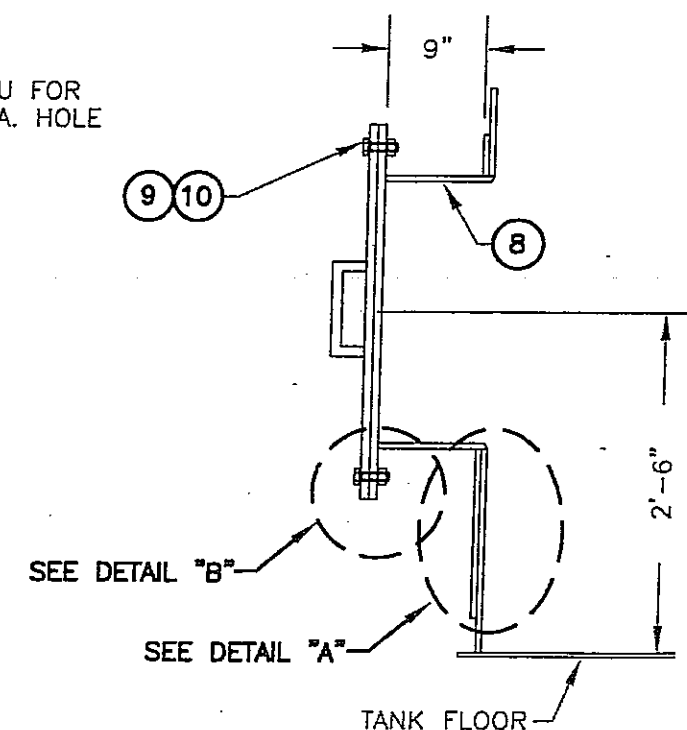

PITTSBURG TANK & TOWER CO.
GROUND TANK DIVISION
HENDERSON, KENTUCKY
SINCE 1919







DESCRIPTION 24" SHELL MANWAY

CUSTOMER TETON SPGS. GOLF & CSTG. CLUB
TETON SPRINGS, IDAHO


DRAWN BY: JOE B. JOB NO. 4742
CHECKED BY: PROJ. MGR. JEFF BYRD
APPROVED BY: SHEET NO. 7
DATE 8/9/02 SCALE NONE

NO.	REVISION	DATE	BY

This drawing and its designs are part of the intellectual property of PITTSBURG TANK & TOWER and may not be copied or used without the written permission of PITTSBURG TANK & TOWER. This drawing, its designs and any information hereon may not be disclosed to any third party without the written permission of PITTSBURG TANK & TOWER.

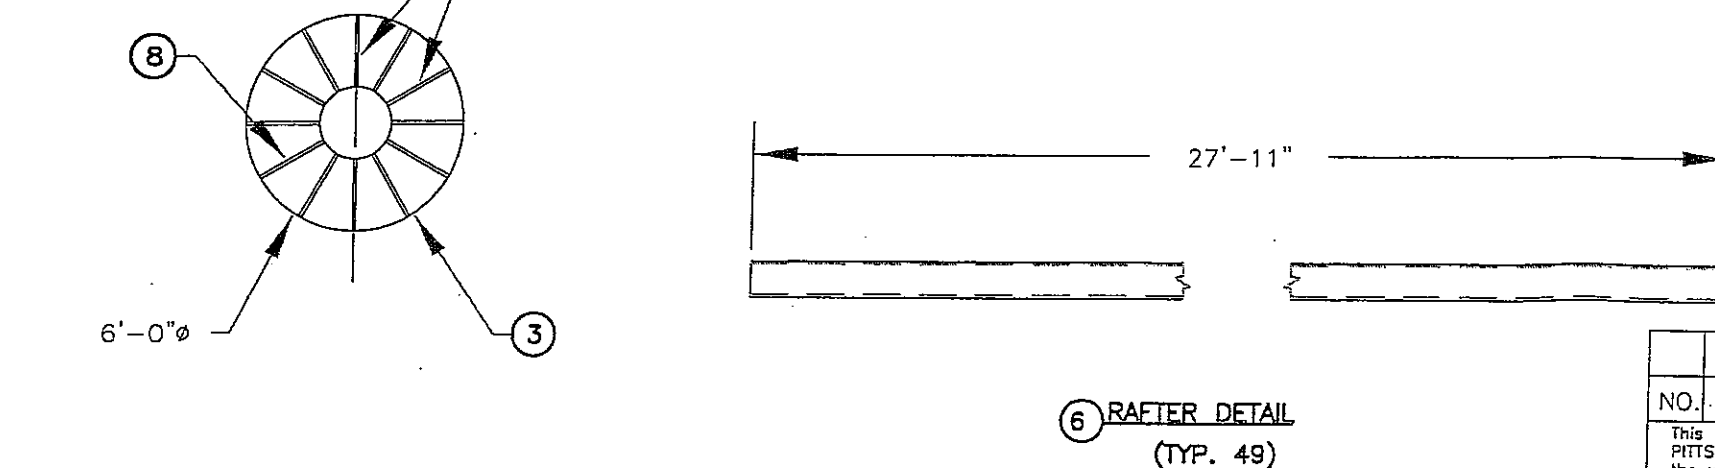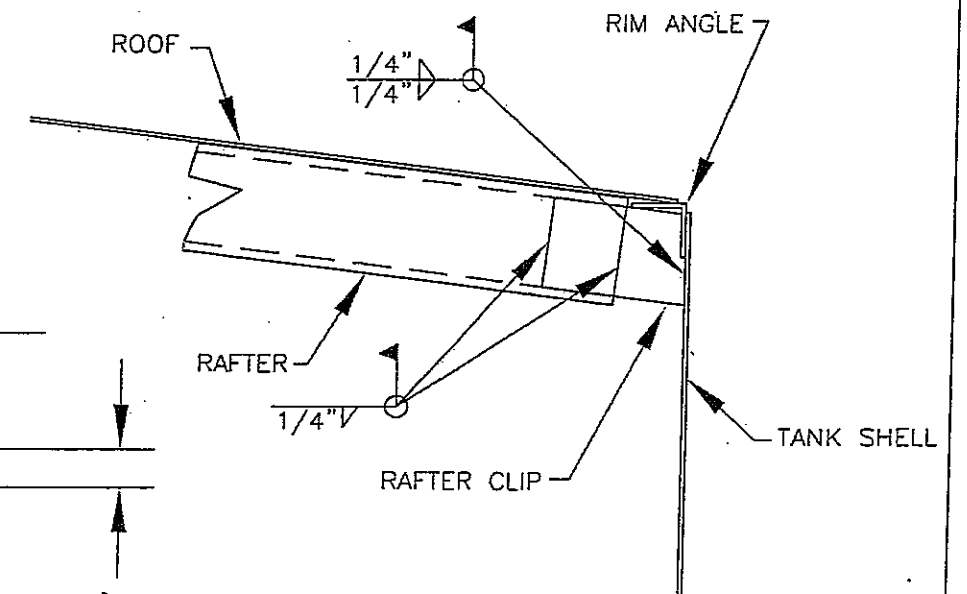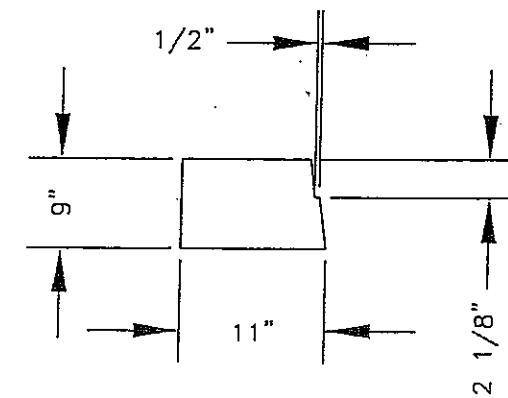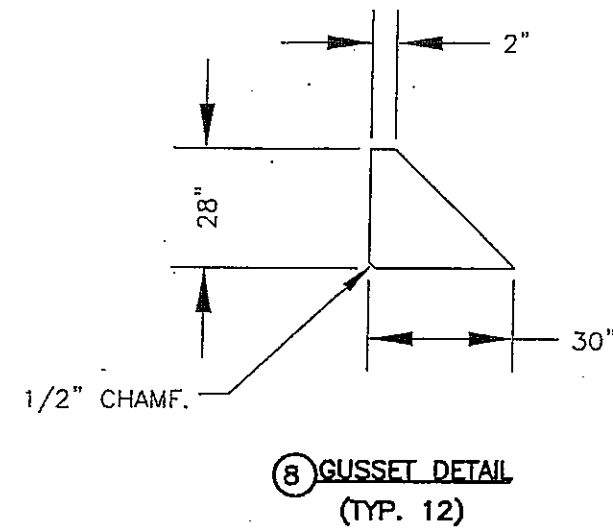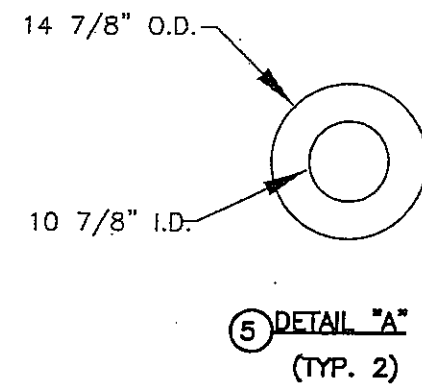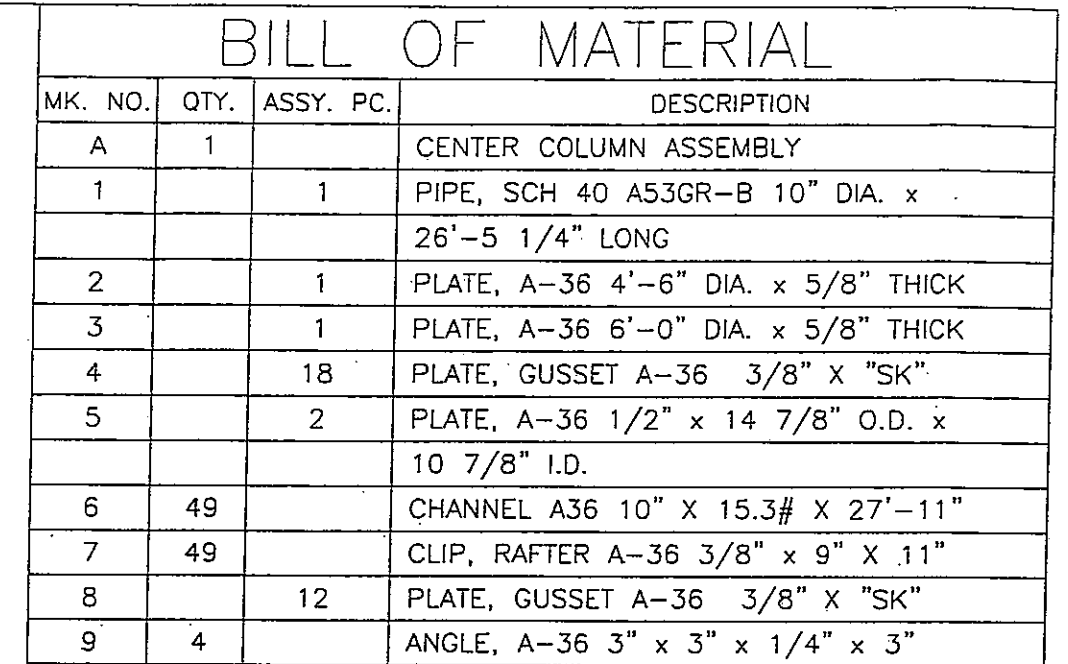


NO.	REVISION	DATE	BY
This drawing and its designs are part of the intellectual property of PITTSBURGH TANK & TOWER and may not be copied or used without the written permission of PITTSBURGH TANK & TOWER. This drawing, its designs and any information hereon may not be disclosed to any third party without the written permission of PITTSBURGH TANK & TOWER.			

 		PITTSBURGH TANK & TOWER CO. GROUND TANK DIVISION HENDERSON, KENTUCKY	
SINCE 1919			
DESCRIPTION RAFTER/CENTER COLUMN DETAIL			
CUSTOMER TETON SPGS. GOLF & CSTG. CLUB TETON, IDAHO			
DRAWN BY: JOE B.		JOB NO. 4742	
CHECKED BY:		PROJ. MGR. JEFF BYRD	
APPROVED BY: 		SHEET NO. 8	
DATE 8/9/02		SCALE NONE	


BILL OF MATERIAL


MK. NO.	QTY.	ASSY. PC.	DESCRIPTION
1	1		PLATE A36 1/4" X **

** SIZED TO MATCH PIPE THROUGH FLOOR



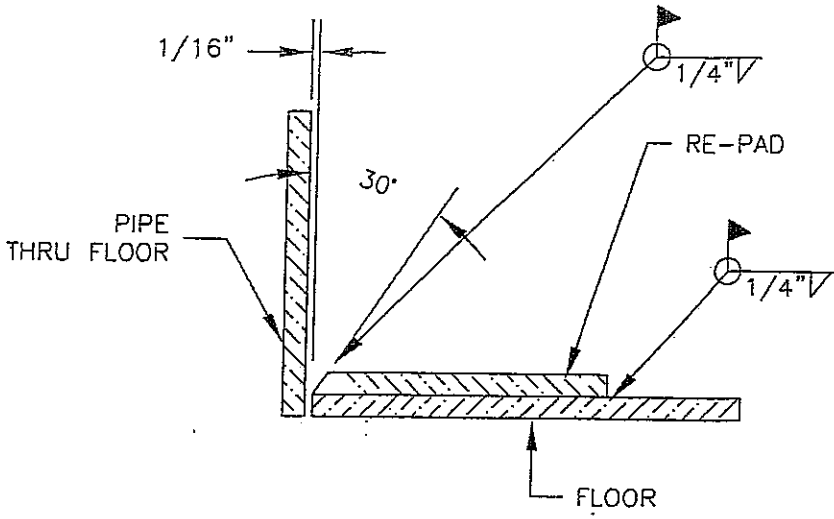


 NOTE:
CUSTOMER TO FURNISH PT&T WITH
SIZE OF INLET/OUTLET PIPE BEFORE
FABRICATED STEEL IS SHIPPED, SO
THAT PROPER SIZE RE-PLATE IS
INCLUDED IN SHIPMENT.

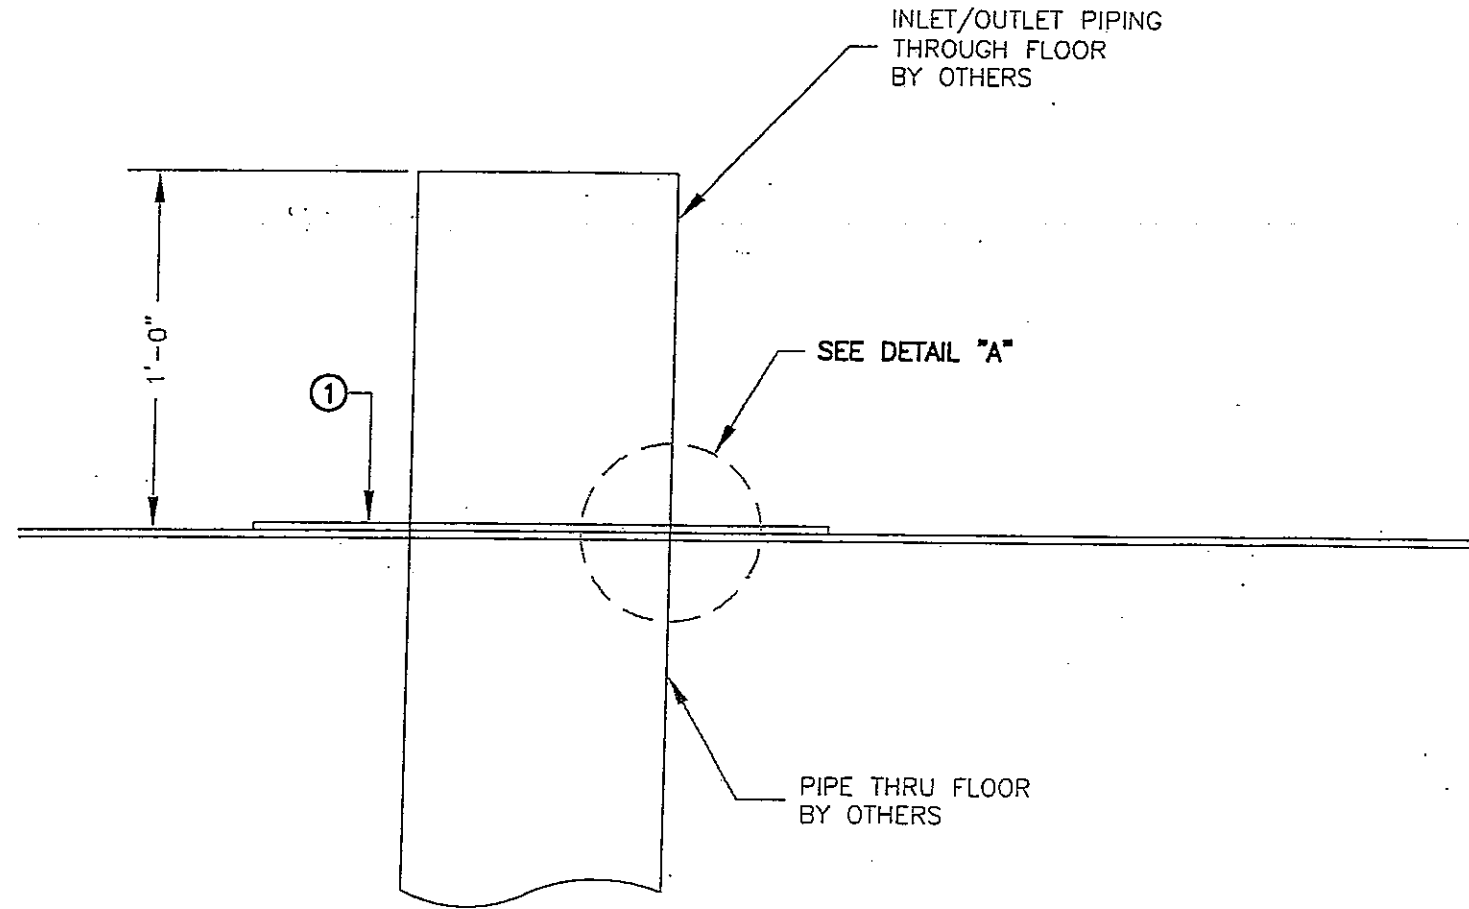

		PITTSBURG TANK & TOWER CO. GROUND TANK DIVISION HENDERSON, KENTUCKY	
DESCRIPTION THROUGH FLOOR INLET/OUTLET			
CUSTOMER TETON SPGS. GOLF & CSTG. CLUB TETON SPRINGS, IDAHO			
DRAWN BY: JOE B.		JOB NO. 4742	
CHECKED BY:		PROJ. MGR. JEFF BYRD	
APPROVED BY: 		SHEET NO. 9	
DATE 8/9/02		SCALE NONE	

NO.	REVISION	DATE	BY
This drawing and its designs are part of the intellectual property of PITTSBURG TANK & TOWER and may not be copied or used without the written permission of PITTSBURG TANK & TOWER. This drawing, its designs and any information hereon may not be disclosed to any third party without the written permission of PITTSBURG TANK & TOWER.			

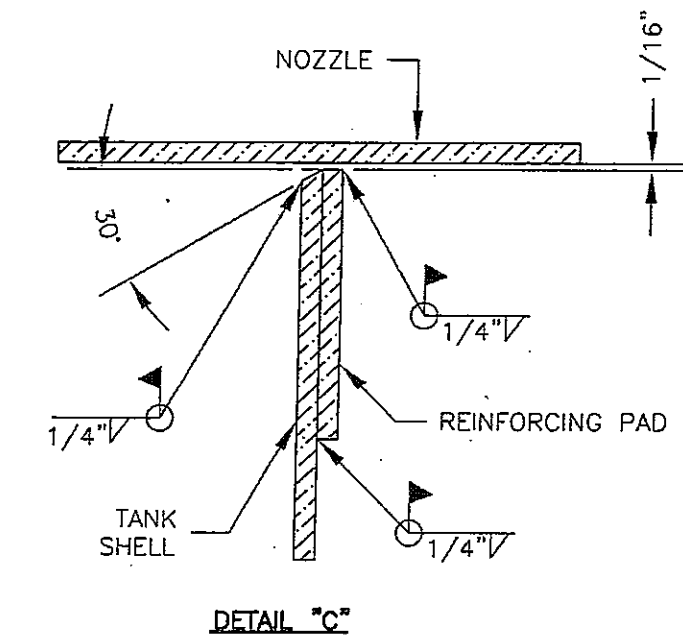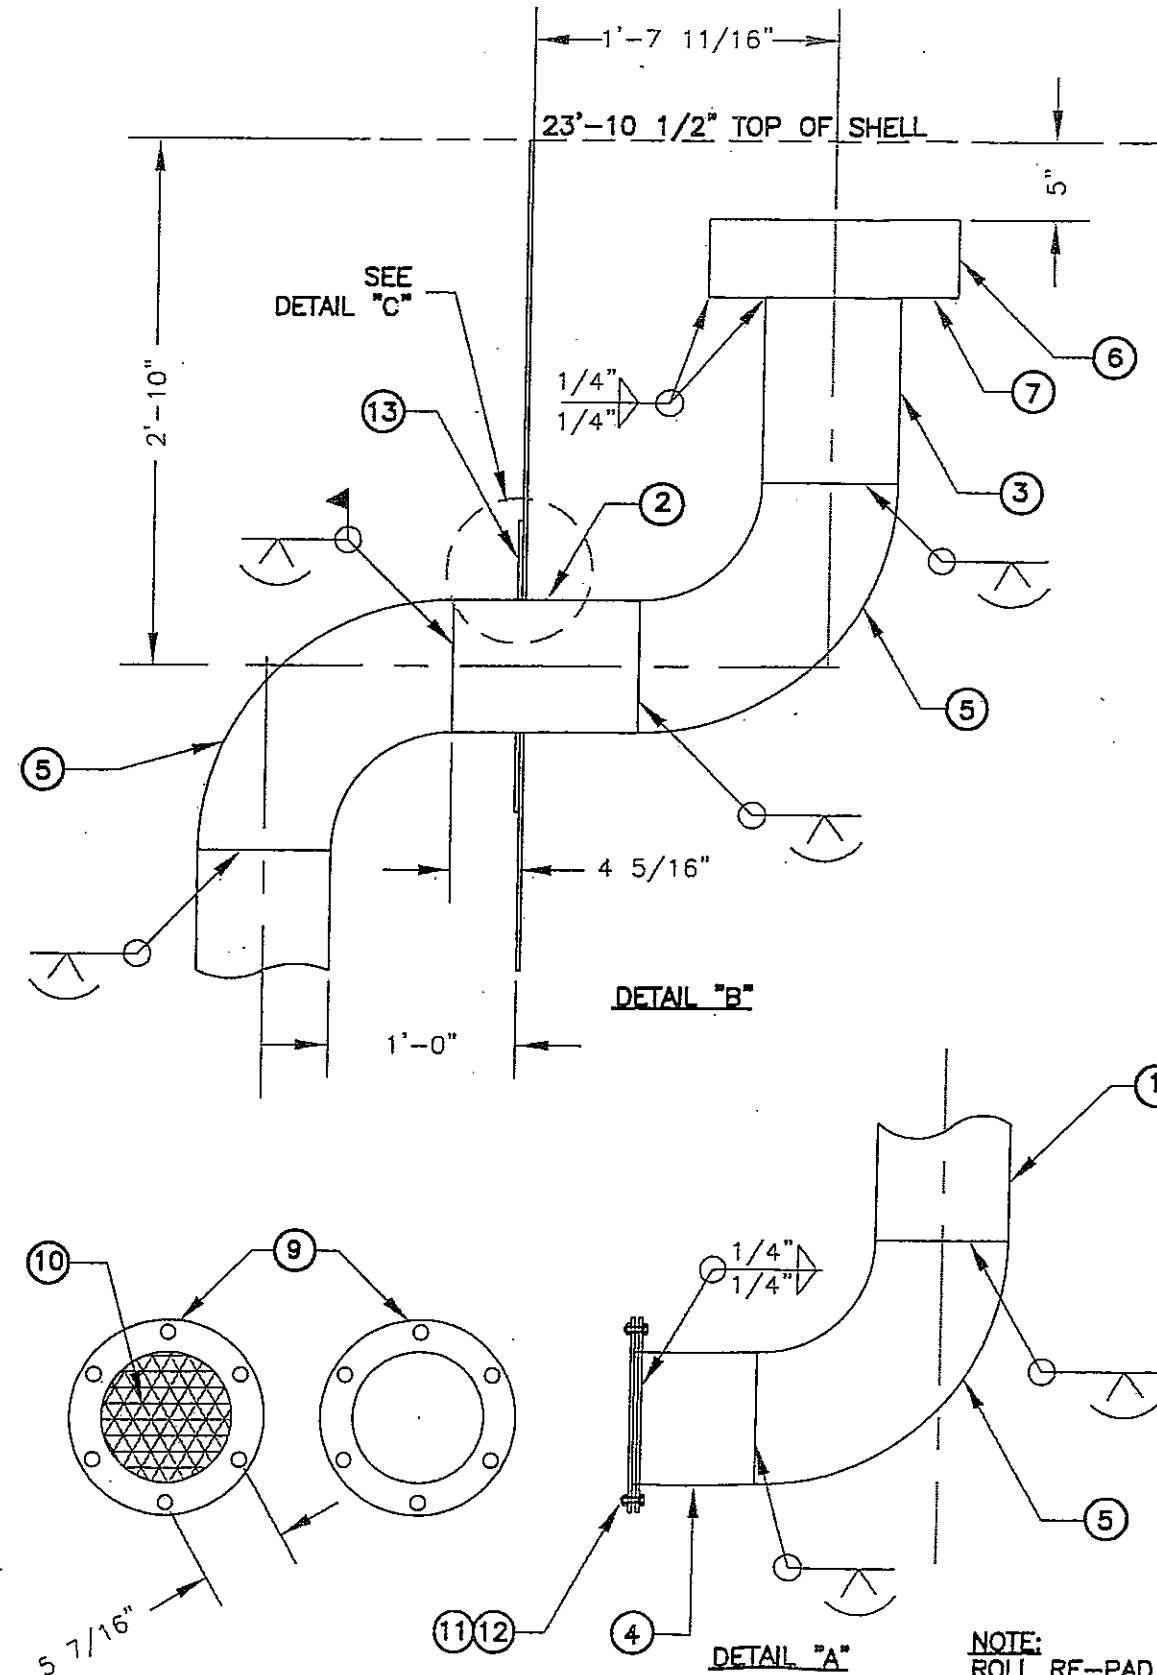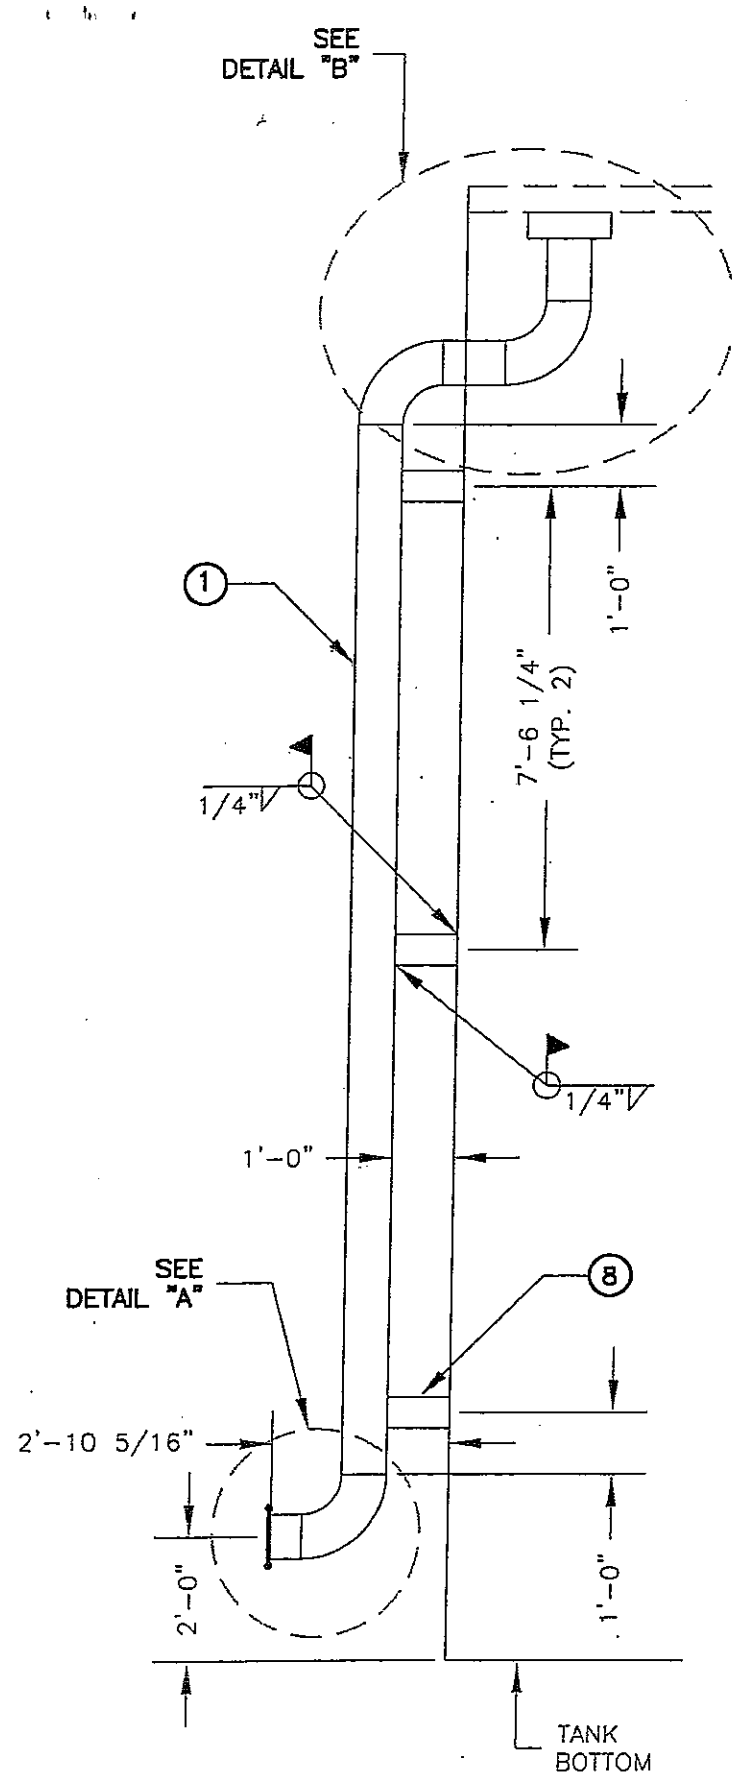

NOTE:
ROLL RE-PAD TO 30'-0" RAD.

BILL OF MATERIAL

MK. NO.	QTY.	ASSY. PC.	DESCRIPTION
1		1	PIPE A53 GR.B 8" SCH. 40 X 17'-0 1/2"
2		1	PIPE A53 GR.B 8" SCH. 40 X 1'-0"
3		1	PIPE A53 GR.B 8" SCH. 40 X 1'-0"
4		1	PIPE A53 GR.B 8" SCH. 40 X 6"
5		3	WELD 90 A53 GR.B SCH. 40 8"Ø
6		1	PIPE A53 GR.B 16" SCH. 40 X 5"
7		1	PLATE A36 1/4" X 8 3/4" ID X 16" OD
8	3		PLATE A36 3/8" X 6" X 1'-0"
9		2	PLATE A36 1/4" X 8 3/4" ID X 13" OD
10		1	SCREEN 3/8" MESH S.S. X 13"Ø
11		6	BOLTS A325 3/8" X 1"
12		6	HEX NUT A325 3/8"Ø
13	1		PLATE A36 1/4" X 8 3/4" ID X 19" OD

PITTSBURG TANK & TOWER CO.
GROUND TANK DIVISION
HENDERSON, KENTUCKY

DESCRIPTION 8" OVERFLOW TO GRADE

CUSTOMER TETON SPGS. GOLF & CSTG. CLUB
TETON SPRINGS, IDAHO

DRAWN BY: JOE B.

JOB NO. 4742

CHECKED BY:

PROJ. MGR. JEFF BYRD

APPROVED BY: *[Signature]*

SHEET NO. 10

DATE

8/9/02

SCALE

NONE


NO.

REVISION


DATE

BY


This drawing and its designs are part of the intellectual property of PITTSBURG TANK & TOWER and may not be copied or used without the written permission of PITTSBURG TANK & TOWER. This drawing, its designs and any information hereon may not be disclosed to any third party without the written permission of PITTSBURG TANK & TOWER.

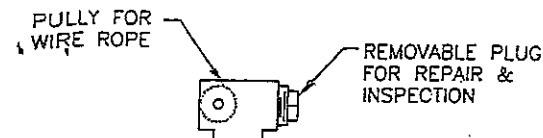


⑥ PULLY BOX DETAIL
(TYP. 2)

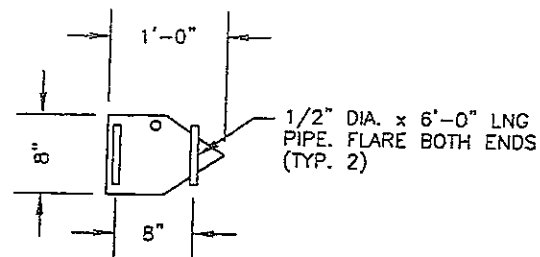


① TARGET DETAIL

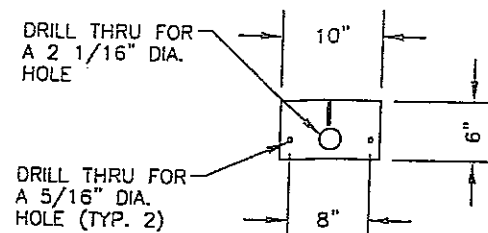


④ TOP PLATE DETAIL

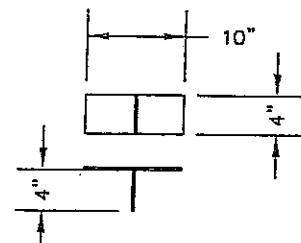


③ HALF MARKER DETAIL

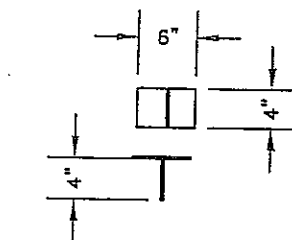

② QUARTER MARKER DETAIL
(TYP. 2)

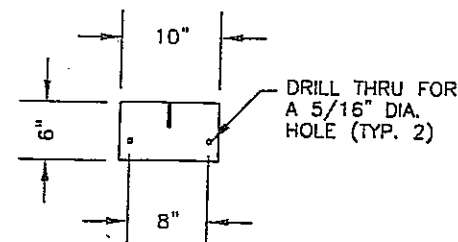


① BOTTOM PLATE DETAIL

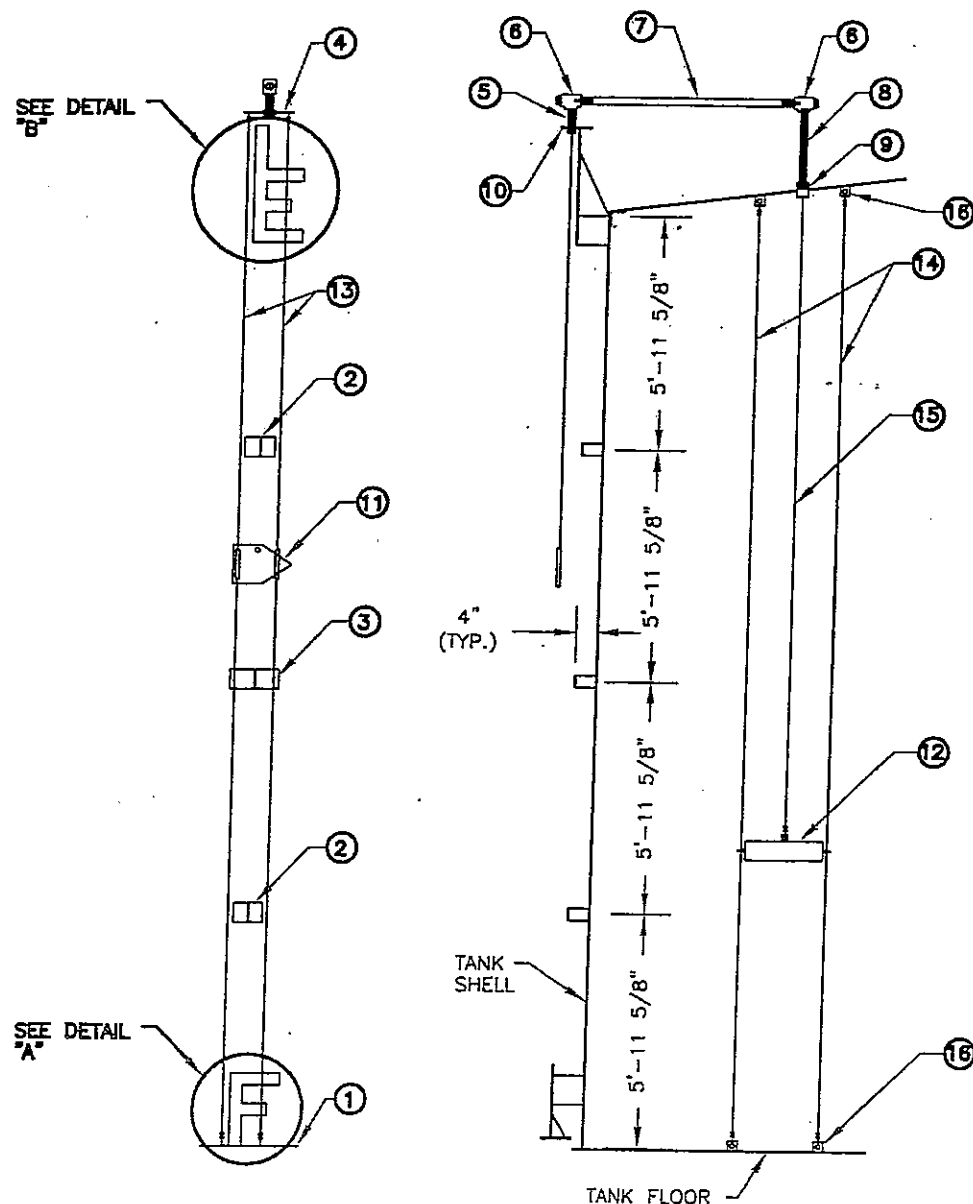


FRONT VIEW


SIDE VIEW

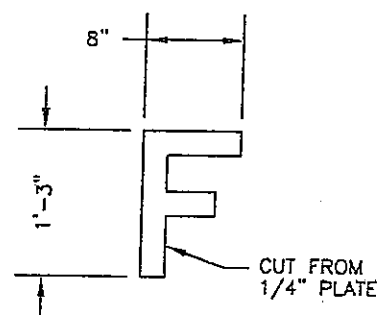


DETAIL "A"

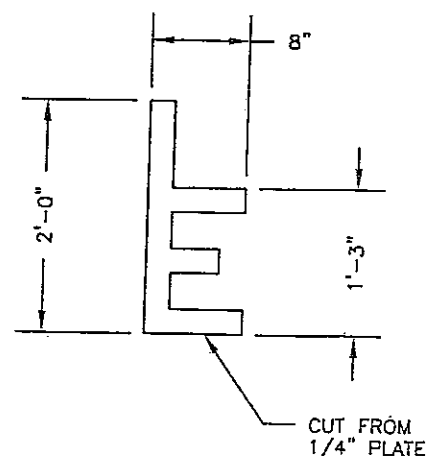

DETAIL "B"

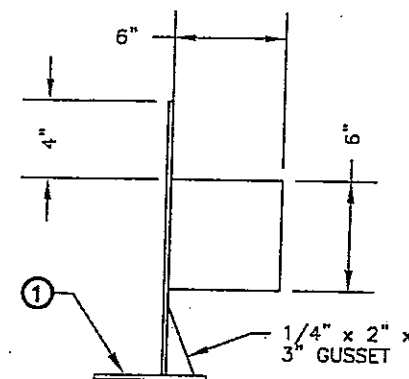

SIDE VIEW FULL MARKER

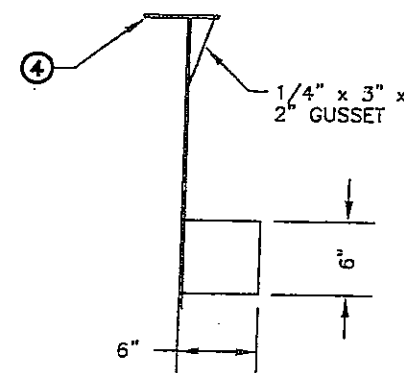

SIDE VIEW EMPTY MARKER

BILL OF MATERIAL

MK. NO.	QTY.	ASSY. PC.	DESCRIPTION
1	1		BOTTOM PLATE, 1/4" THICK
2	2		QUARTER MARKER, 1/4" PLATE WITH 1/4" x 4" x 4" STAND OFF
3	1		HALF MARKER, 1/4" PLATE WITH 1/4" x 4" x 4" STAND OFF
4	1		TOP PLATE, 1/4" PLATE
5	1		1 1/2" DIA. GALV. PIPE NIPPLE x 5" LNG.
6	2		FABRICATED PULLY BOX
7	1		1 1/2" DIA. GALV. PIPE NIPPLE x 40 1/2"
8	1		1 1/2" DIA. GALV. PIPE NIPPLE x 18"
9	1		1 1/2" DIA. FORGED COUPLING
10	2		PIPE LOCK NUTS
11	1		TARGET, 1/2" PLATE
12	1		16" SQ. x 4" FLOAT, 3/16" PLATE
13	2		1/4" GALV. WIRE ROPE TARGET GUIDES 27' W/ CABLE CLAMPS
14	2		1/4" GALV. WIRE ROPE TARGET GUIDES 27' W/ CABLE CLAMPS
15	1		1/8" GALV. WIRE ROPE FOR FLOAT TARGET 32' LONG W/CABLE CLAMPS
16	4		1/4" x 2" SQ. CLIPS W/1" HOLE IN CENTER WELD TO FLOOR & ROOF



PITTSBURG TANK & TOWER CO.
GROUND TANK DIVISION
HENDERSON, KENTUCKY

DESCRIPTION LIQUID LEVEL INDICATOR

CUSTOMER TETON SPGS. GOLF & CSTG. CLUB
TETON SPRINGS, IDAHO

DRAWN BY: JOE B. JOB NO. 4742
CHECKED BY: PROJ. MGR. JEFF BYRD
APPROVED BY: *[Signature]* SHEET NO. 11
DATE 8/9/02 SCALE NONE



NO.	REVISION	DATE	BY

This drawing and its designs are part of the intellectual property of PITTSBURG TANK & TOWER and may not be copied or used without the written permission of PITTSBURG TANK & TOWER. This drawing, its designs and any information hereon may not be disclosed to any third party without the written permission of PITTSBURG TANK & TOWER.


13/16" SQ. HOLE
ON 45° ANGLE FOR
A 3/4" SQ.
BAR RUNG


3/8" x 2 1/2"
SIDE RAIL

DETAIL "A"

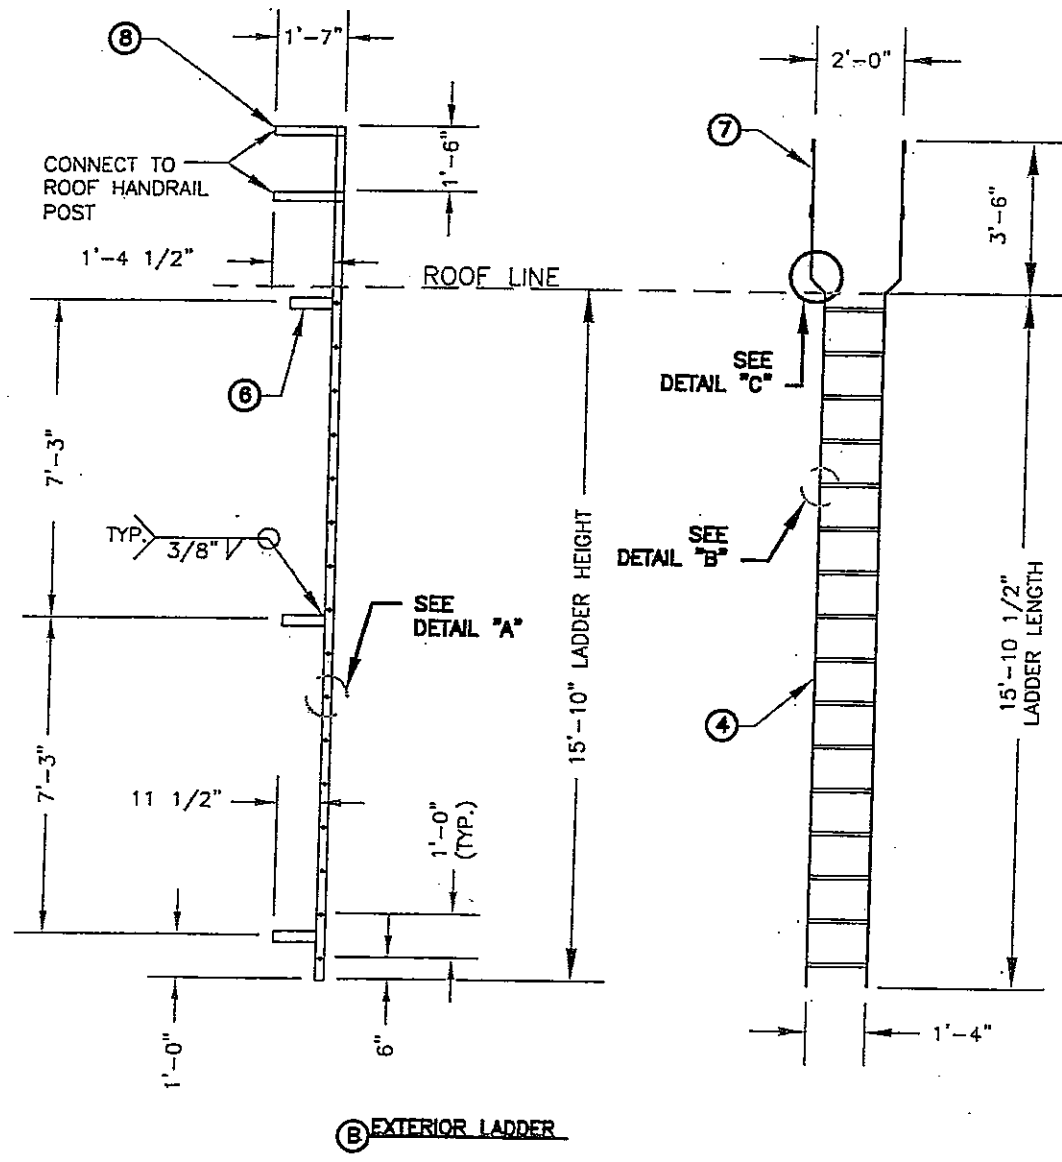
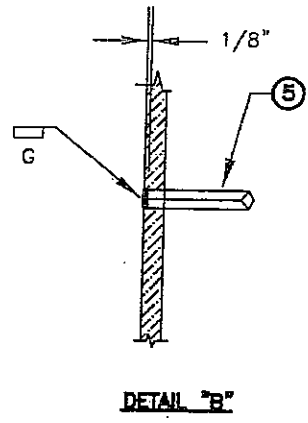


BILL OF MATERIAL			
MK. NO.	QTY.	ASSY. PC.	DESCRIPTION
B	1		EXTERIOR LADDER
4		2	BAR, A-36 3/8" x 2 1/2" x 16'-4 1/8"
5		16	BAR, SQUARE A-36 3/8" x 1'-4 1/2"
6		6	BAR, A-36 3/8" x 3" x 1'-2"
7		2	BAR, A-36 3/8" x 2 1/2" x 3'-2"
8		4	BAR, A-36 1/4" x 2 1/2" x 1'-9"

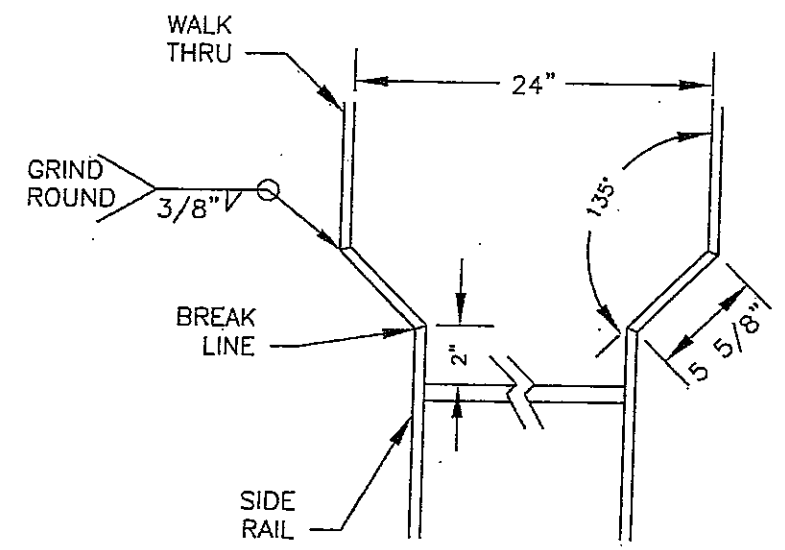

 		PITTSBURG TANK & TOWER CO. GROUND TANK DIVISION HENDERSON, KENTUCKY	
DESCRIPTION LADDER DETAIL			
CUSTOMER TETON SPGS. GOLF & CSTG. CLUB TETON SPRINGS, IDAHO			
DRAWN BY: JOE B.		JOB NO. 4742	
CHECKED BY:		PROJ. MGR. JEFF BYRD	
APPROVED BY: 		SHEET NO. 12	
DATE 8/9/02		SCALE NONE	

NO.	REVISION	DATE	BY
This drawing and its designs are part of the intellectual property of PITTSBURG TANK & TOWER and may not be copied or used without the written permission of PITTSBURG TANK & TOWER. This drawing, its designs and any information hereon may not be disclosed to any third party without the written permission of PITTSBURG TANK & TOWER.			

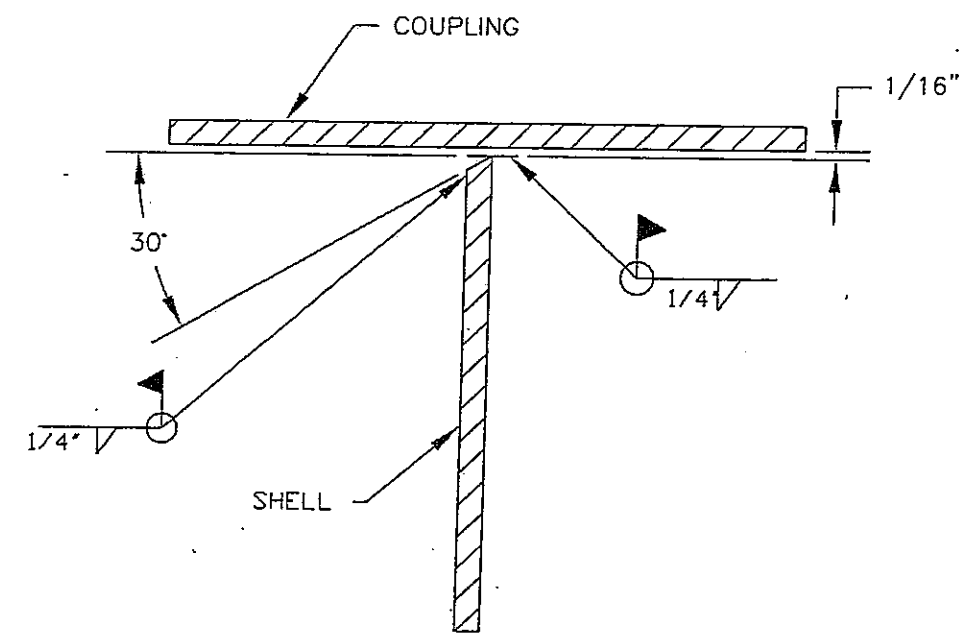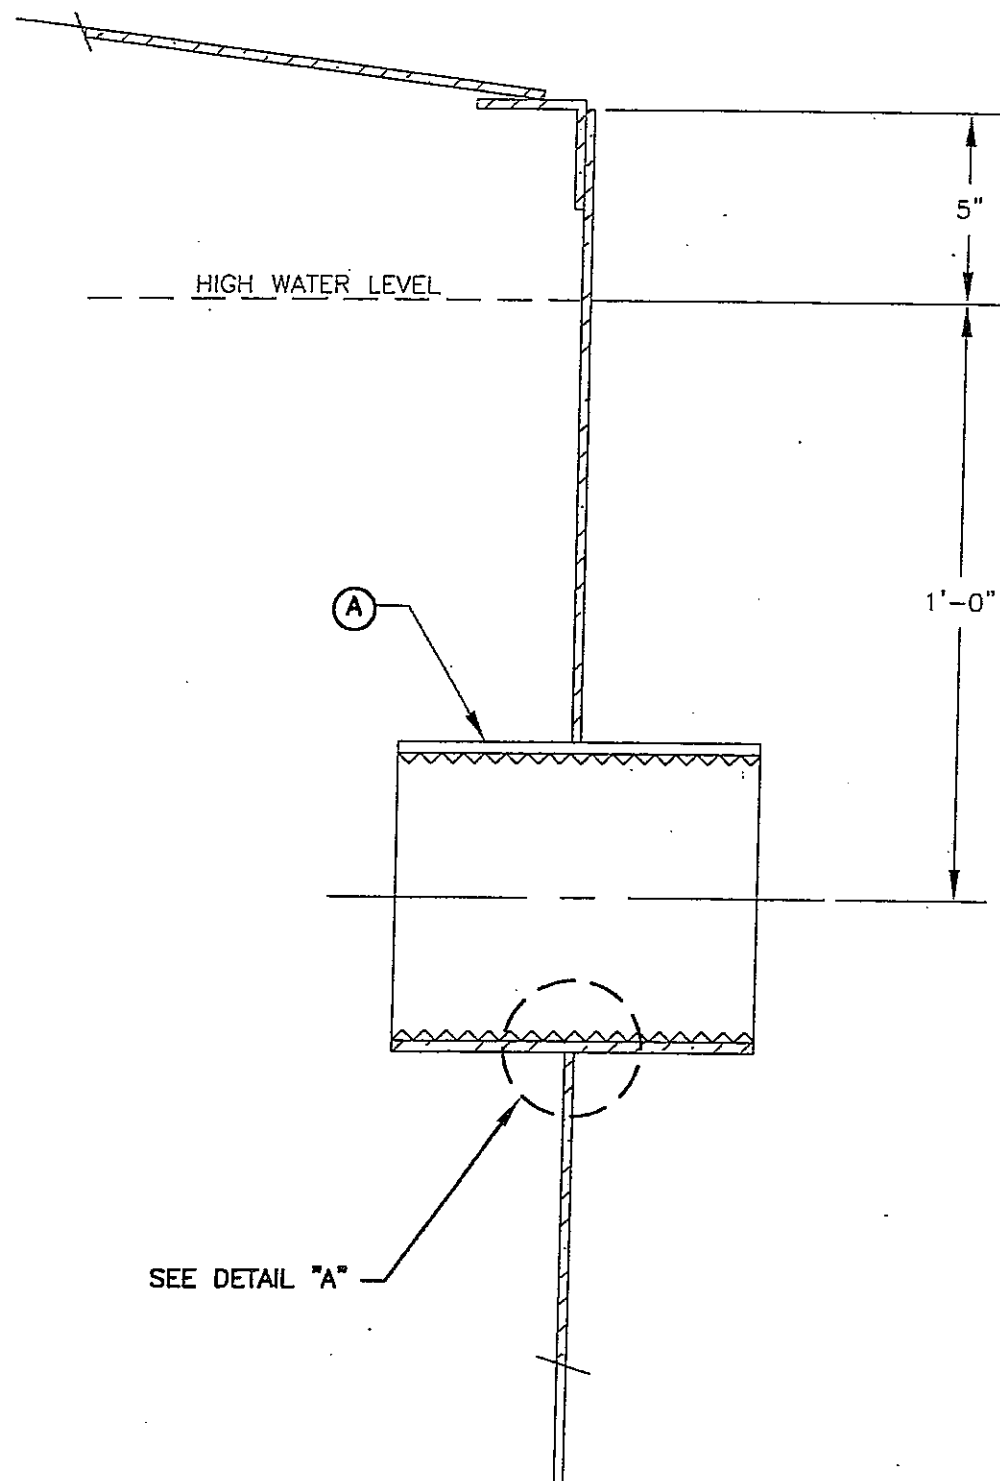

DETAIL "A"

BILL OF MATERIAL

MK. NO.	QTY.	ASSY. PC.	DESCRIPTION
A	1		COUPLING, A53 GR.B 3000# 2"Ø

SEE DETAIL "A"




PITTSBURG TANK & TOWER CO.
GROUND TANK DIVISION
HENDERSON, KENTUCKY

DESCRIPTION SHELL COUPLING FOR
ALTITUDE SENSING SWITCH


CUSTOMER TETON SPGS. GOLF & CSTG. CLUB
TETON SPRINGS, IDAHO

DRAWN BY: JOE B.	JOB NO. 4742
CHECKED BY:	PROJ. MGR. JEFF BYRD
APPROVED BY: <i>[Signature]</i>	SHEET NO. 13
DATE 8/9/02	SCALE NONE


NO.	REVISION	DATE	BY
This drawing and its designs are part of the intellectual property of PITTSBURG TANK & TOWER and may not be copied or used without the written permission of PITTSBURG TANK & TOWER. This drawing, its designs and any information hereon may not be disclosed to any third party without the written permission of PITTSBURG TANK & TOWER.			

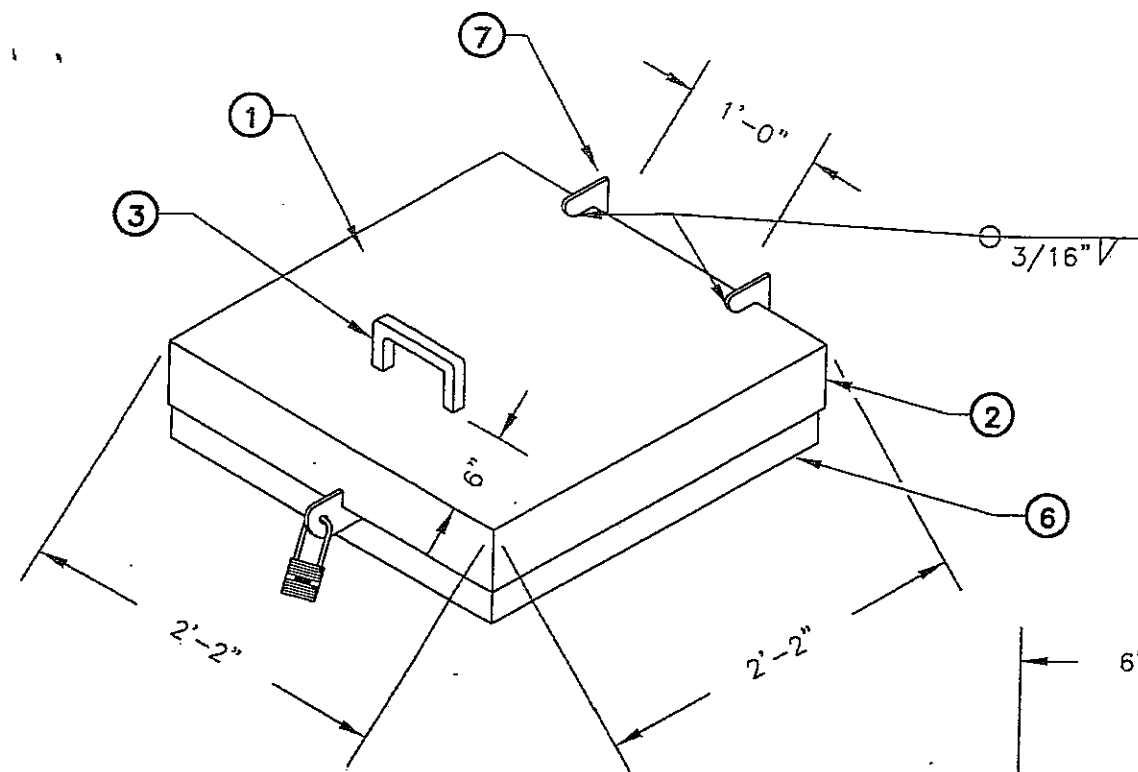


TOP VIEW ASSEMBLY

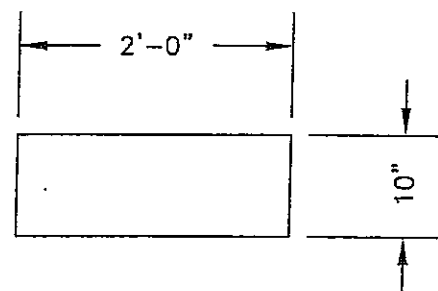


6 SIDE PLATE DETAIL

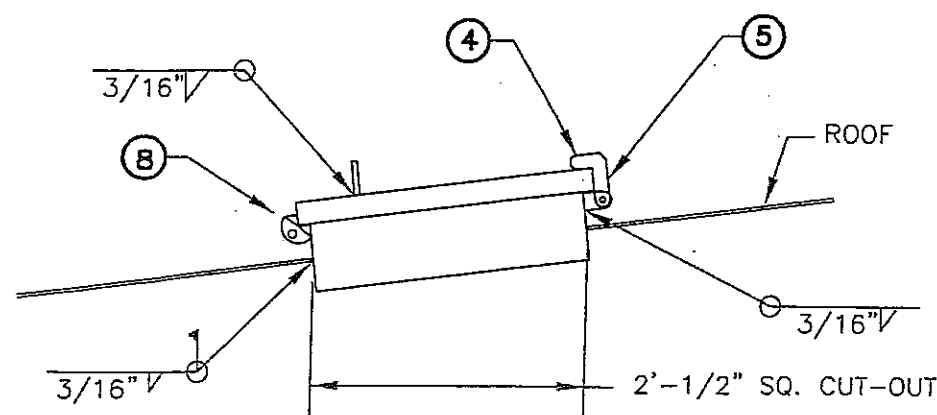


ELEVATION VIEW ASSEMBLY

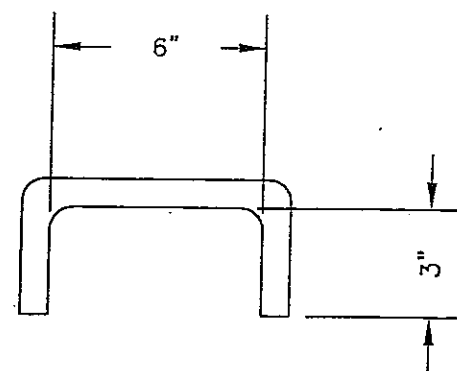


3 HANDLE DETAIL

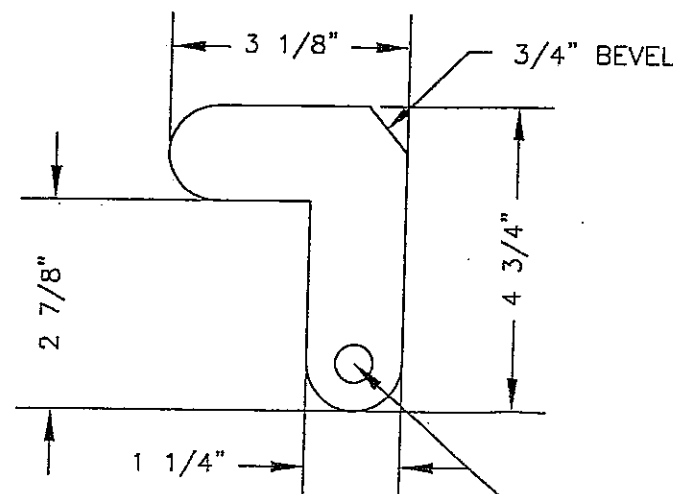


5 HINGE DETAIL

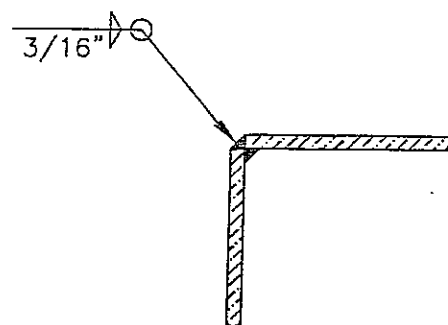


TYP. CORNER WELD
(BODY AND COVER)

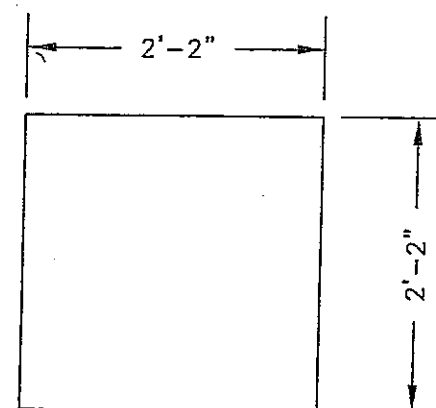


1 HATCH LID DETAIL

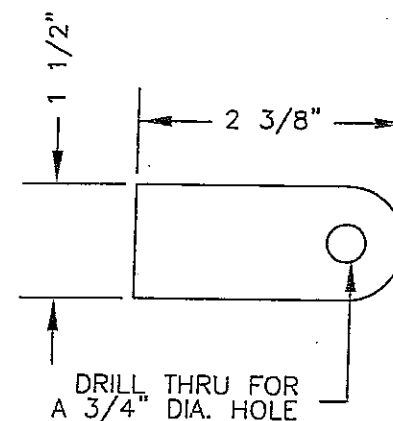

4 HINGE DETAIL

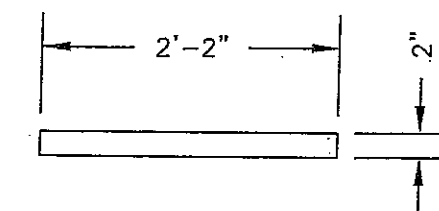

2 SIDE PLATE DETAIL

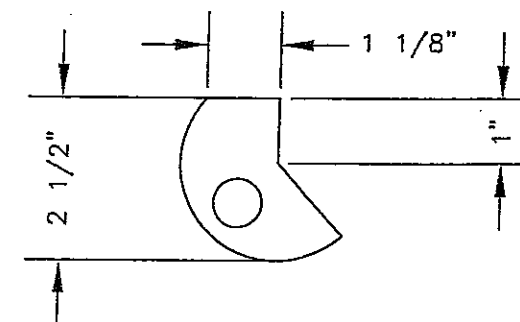

8 LATCH DETAIL

BILL OF MATERIAL

MK. NO.	QTY.	ASSY. PC.	DESCRIPTION
A	1		24" SQUARE ROOF HATCH
1		1	PLATE, A-36 3/16" x 2'-2" x 2'-2"
2		4	PLATE, A-36 3/16" x 2" x 2'-2"
3		1	BAR, A-36 5/8" x 1'-0"
4		2	PLATE, A-36 1/4" x "SK"
5		2	PLATE, A-36 1/4" x "SK"
6		4	PLATE, A-36 3/16" x 10" x 2'-0"
7		1	BAR, A-36 5/8" x 1'-3"
8		2	PLATE, A-36 3/16" x "SK"



PITTSBURG TANK & TOWER CO.
GROUND TANK DIVISION
HENDERSON, KENTUCKY

DESCRIPTION 24" SQUARE ROOF HATCH

CUSTOMER TETON SPGS. GOLF & CSTG. CLUB
TETON SPRINGS, IDAHO

DRAWN BY: JOE B.

JOB NO. 4742

CHECKED BY:

PROJ. MGR. JEFF BYRD

APPROVED BY: *[Signature]*


SHEET NO. 14

DATE



8/9/02

SCALE NONE


NO.	REVISION	DATE	BY
This drawing and its designs are part of the intellectual property of PITTSBURG TANK & TOWER and may not be copied or used without the written permission of PITTSBURG TANK & TOWER. This drawing, its designs and any information hereon may not be disclosed to any third party without the written permission of PITTSBURG TANK & TOWER.			

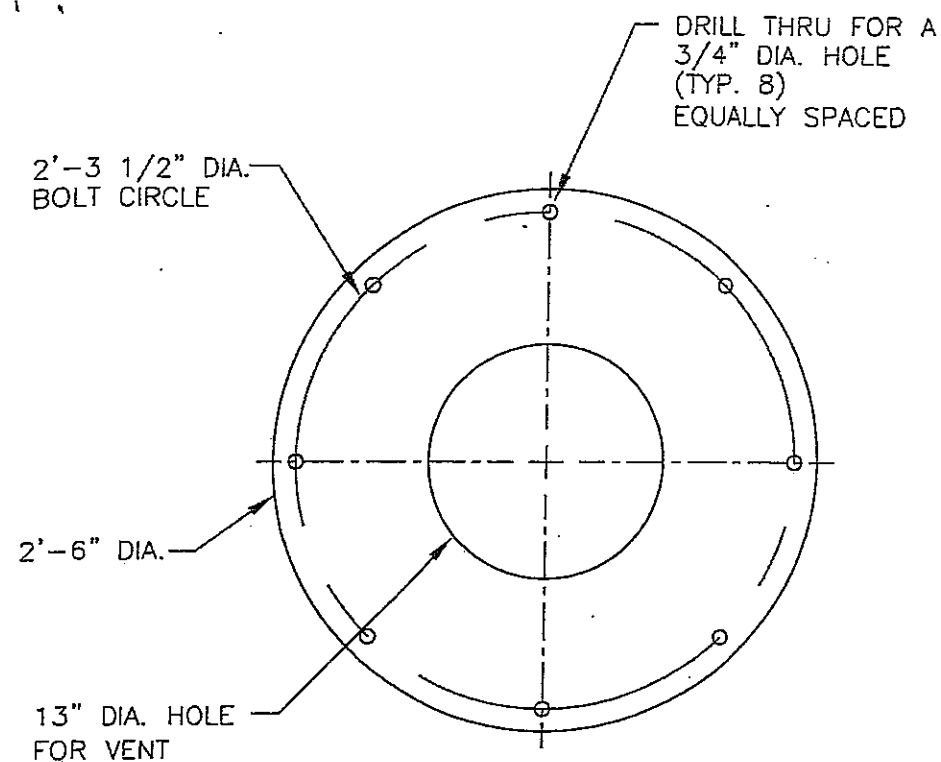

② COVER PLATE DETAIL

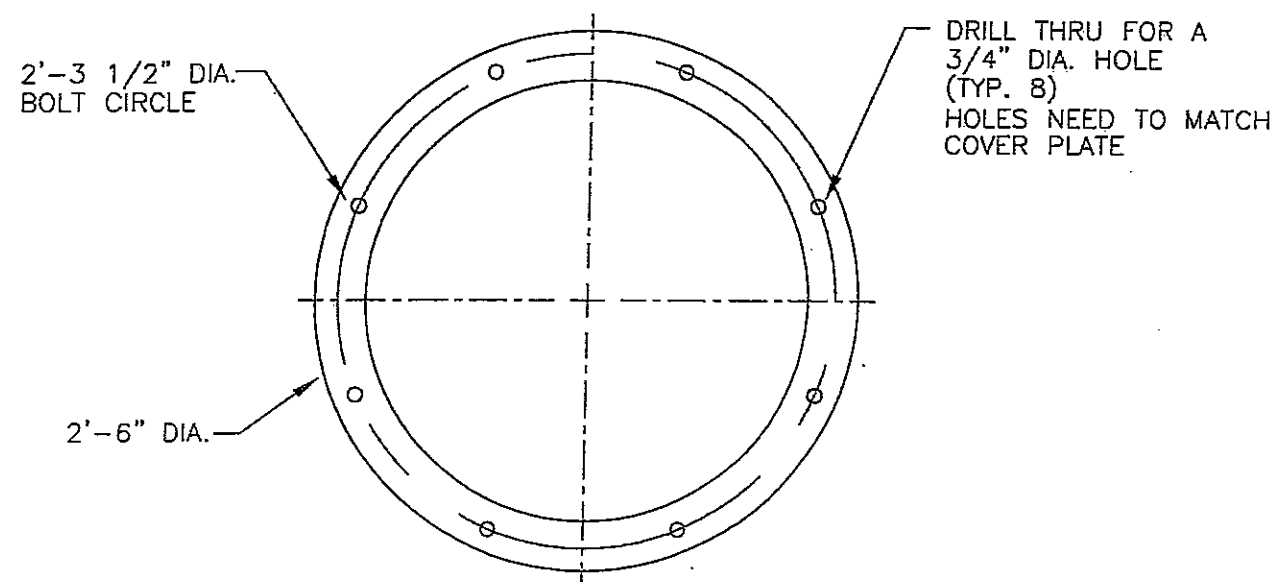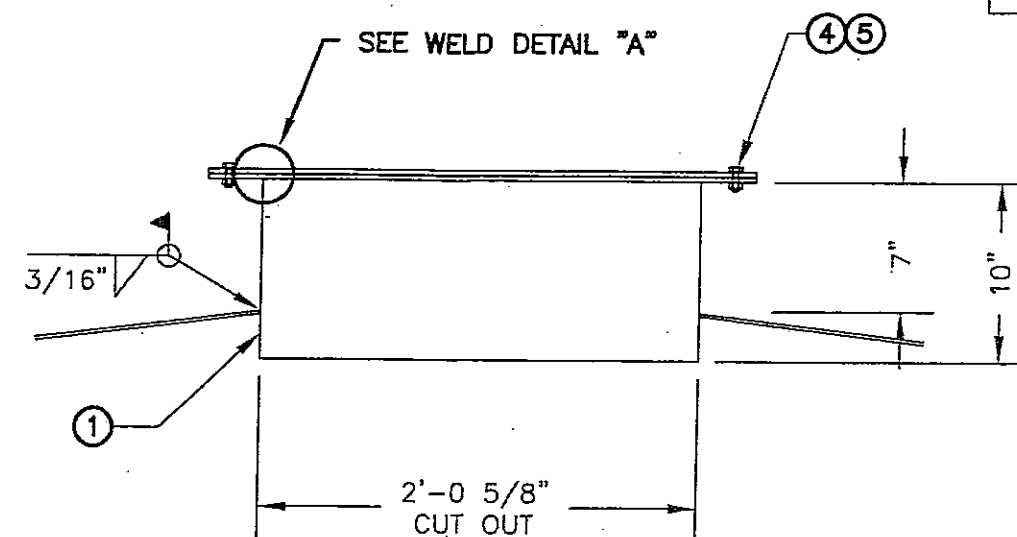

③ ⑥ FLANGE & GASKET DETAIL

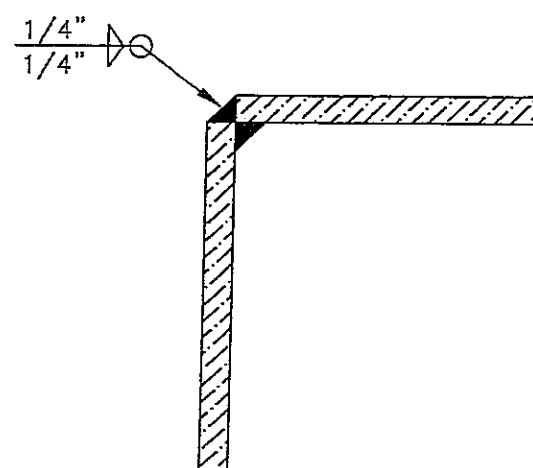

WELD DETAIL "A"

BILL OF MATERIAL

MK. NO.	QTY.	ASSY. PC.	DESCRIPTION
A	1		24" DIA. ROOF MANWAY FOR VENT
1		1	PLATE, A-36 10" x 1/4" x 6'-3 3/8"
			ROLLED TO 2'-0" DIA.
2		1	PLATE, A-36 2'-6" OD x 1/4" x 13" ID
3		1	PLATE, A-36 2'-6" OD x 1/4" x 24 1/2" ID
4		8	BOLTS, A325 5/8" DIA. x 1 1/4" LNG
5		8	NUTS, HEX A325 5/8" DIA.
6		1	GASKET, RED RUBBER 2'-6" OD x 1/8"
			x 2'-0 1/2" I.D.




PITTSBURG TANK & TOWER CO.
GROUND TANK DIVISION
HENDERSON, KENTUCKY

DESCRIPTION 24"Ø ROOF MANWAY


CUSTOMER TETON SPGS. GOLF & CSTG. CLUB
TETON SPRINGS, IDAHO

DRAWN BY: JOE B.	JOB NO. 4742
CHECKED BY:	PROJ. MGR. JEFF BYRD
APPROVED BY: <i>[Signature]</i>	SHEET NO. 15
DATE 8/9/02	SCALE NONE

NO.	REVISION.	DATE	BY
This drawing and its designs are part of the intellectual property of PITTSBURG TANK & TOWER and may not be copied or used without the written permission of PITTSBURG TANK & TOWER. This drawing, its designs and any information hereon may not be disclosed to any third party without the written permission of PITTSBURG TANK & TOWER.			

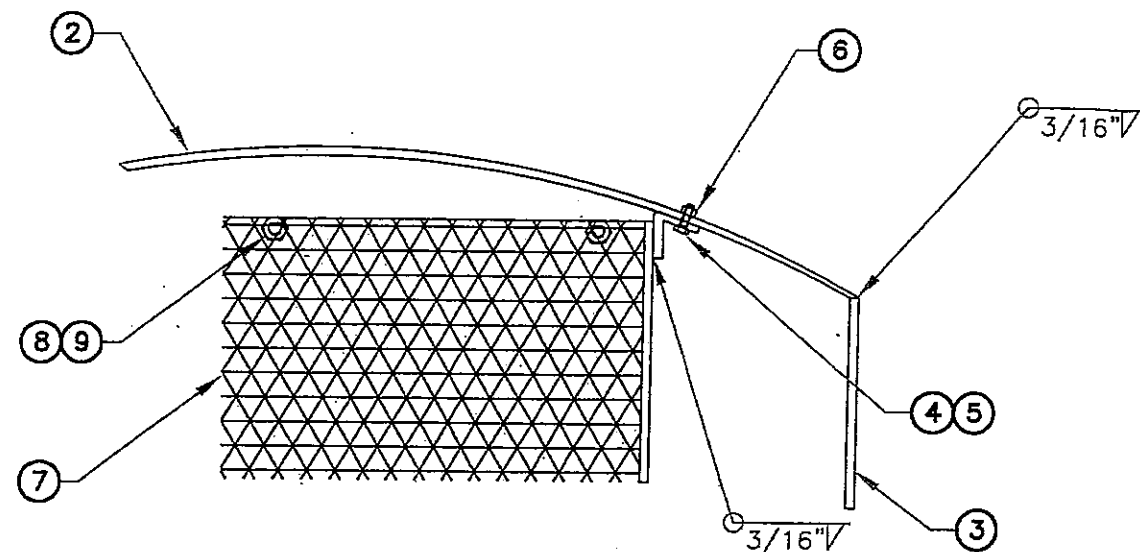

DETAIL "A"

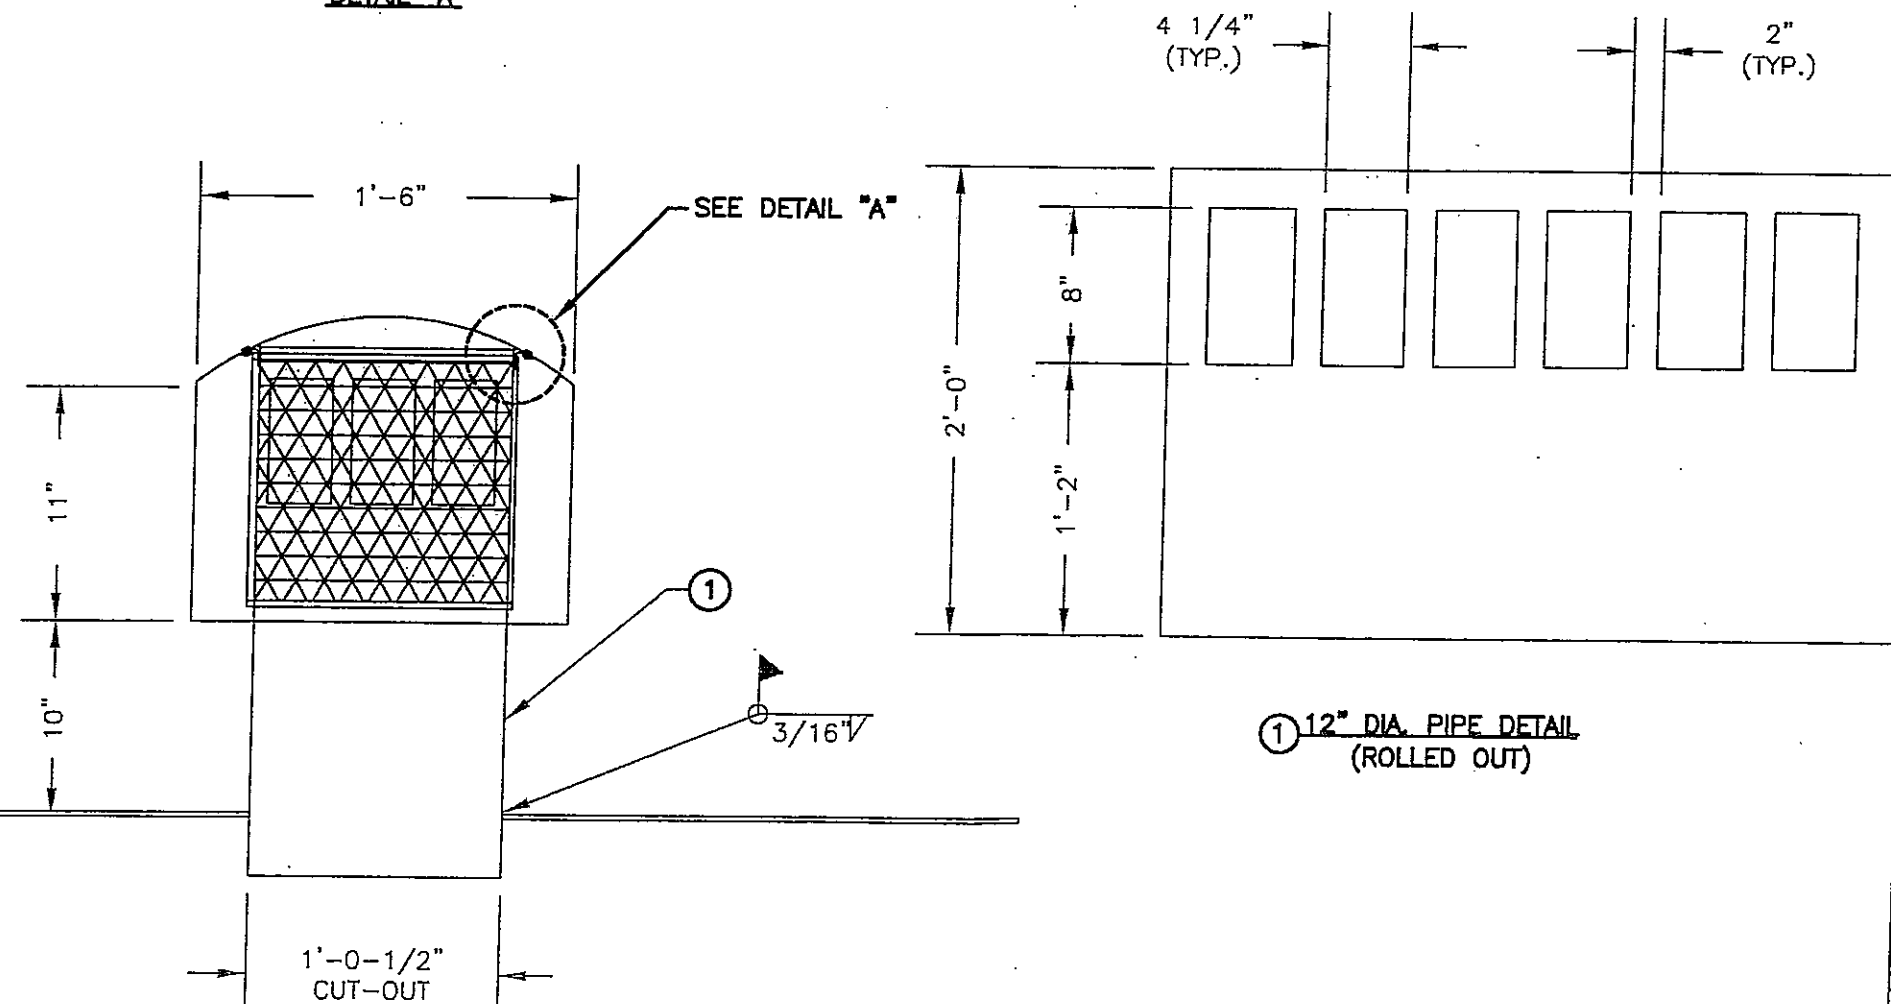

VENT ASSEMBLY VIEW

BILL OF MATERIAL

MK. NO.	QTY.	ASSY. PC.	DESCRIPTION
A	1		STANDARD 12" DIA. PIPE VENT
1		1	PLATE, A-36 12" DIA. x 1/4" x 2'-0"
2		1	PLATE, A-36 1'-6" DIA. x 3/16"
3		1	PLATE, A-36 3/16" x 11" x 4'-8 1/2"
			ROLLED TO 1'-6" DIA.
4		4	BAR, A-36 1/4" x 2" x 5"
5		4	BOLT, A325 1/2" DIA. x 3/4" LNG.
6		4	NUT, HEX A325 1/2" DIA.
7		1	SCREEN, S.S. MESH 1/4" x 10" x 3'-4"
8		4	BOLT, A325 3/8" DIA. x 3/4" LNG
9		4	NUT, HEX A325 3/8" DIA.

① 12" DIA. PIPE DETAIL
(ROLLED OUT)

 PITTSBURG TANK & TOWER CO. GROUND TANK DIVISION HENDERSON, KENTUCKY	
SINCE 1919	
DESCRIPTION 12" ROOF VENT	
CUSTOMER TETON SPGS. GOLF & CSTG. CLUB TETON SPRINGS, IDAHO	
DRAWN BY: JOE B.	JOB NO. 4742
CHECKED BY:	PROJ. MGR. JEFF BYRD
APPROVED BY: <i>[Signature]</i>	SHEET NO. 16
DATE 8/9/02	SCALE NONE

NO.	REVISION	DATE	BY
This drawing and its designs are part of the intellectual property of PITTSBURG TANK & TOWER and may not be copied or used without the written permission of PITTSBURG TANK & TOWER. This drawing, its designs and any information hereon may not be disclosed to any third party without the written permission of PITTSBURG TANK & TOWER.			

4 1 4

BILL OF MATERIAL

MK. NO.	QTY.	ASSY. PC.	DESCRIPTION

INFORMATION FROM CUSTOMER
REQ'D PRIOR TO FABRICATION






PITTSBURG TANK & TOWER CO.
GROUND TANK DIVISION
HENDERSON, KENTUCKY.


DESCRIPTION ANTENNA BRACKET

CUSTOMER TETON SPGS. GOLF & CSTG. CLUB
TETON SPRINGS, IDAHO

NO.	REVISION	DATE	BY	DRAWN BY: JOE B.	JOB NO. 4742
This drawing and its designs are part of the intellectual property of PITTSBURG TANK & TOWER and may not be copied or used without the written permission of PITTSBURG TANK & TOWER. This drawing, its designs and any information hereon may not be disclosed to any third party without the written permission of PITTSBURG TANK & TOWER.				CHECKED BY:	PROJ. MGR. JEFF BYRD
				APPROVED BY: <i>[Signature]</i>	SHEET NO. 17
				DATE 8/9/02	SCALE NONE

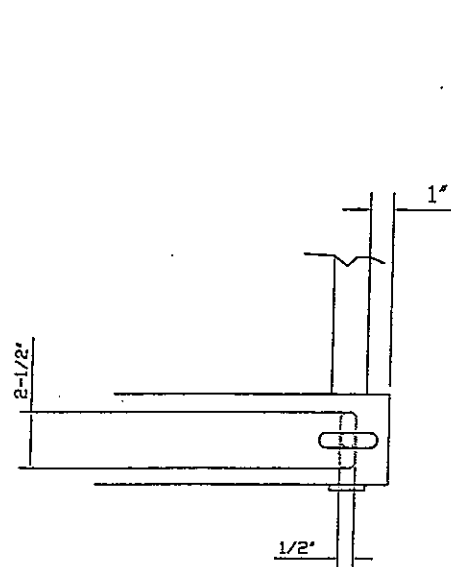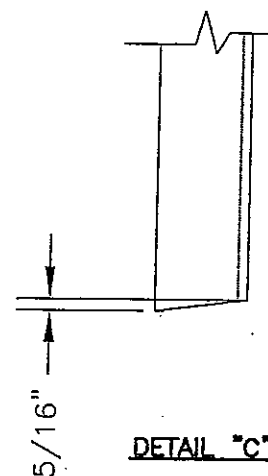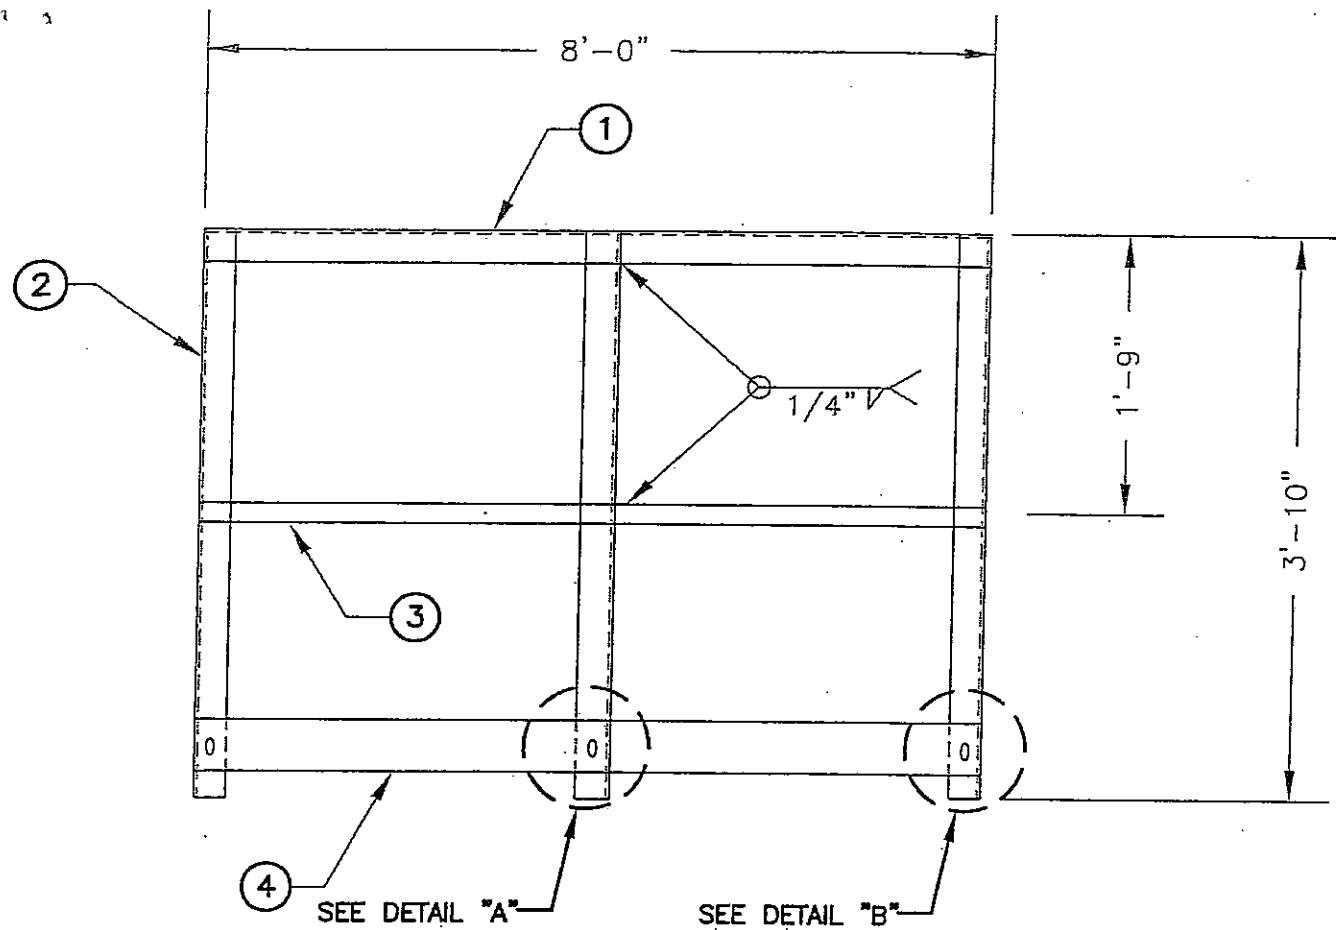


DETAIL "B"
END POST TO TOE
RAIL CONNECTION
AND SLOT DIMENSIONS

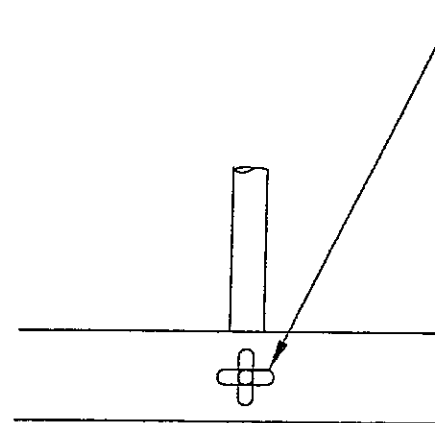

DETAIL "A"
POST TO TOE
RAIL CONNECTION


CUT SLOT IN LEG
AND 4" TOE BAR
3" x 5/8" WIDE

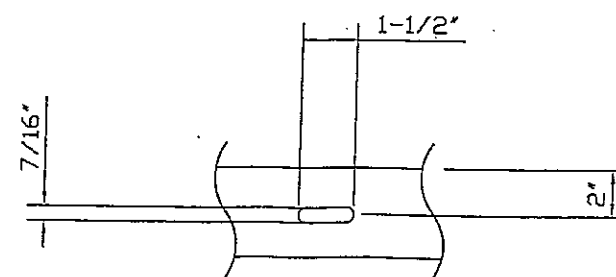

TOE RAIL PUNCH DETAIL

BILL OF MATERIAL

MK. NO.	QTY.	ASSY. PC.	DESCRIPTION
A	2		STANDARD 3'-6" x 8'-0" ROOF HANDRAIL
1		1	ANGLE, A-36 1/4" x 2 1/2" x 2 1/2" x 8'-0"
2		3	ANGLE, A-36 1/4" x 2 1/2" x 2 1/2" x 3'-10"
3		1	BAR, A-36 3/16" x 1 1/2" x 7'-11 1/2"
4		1	BAR, A-36 1/4" x 4" x 8'-0"
5		3	BOLT, A307 GALV. 1/2" x 1 1/2" LNG
6		3	NUT, HEX A307 GALV. 1/2"

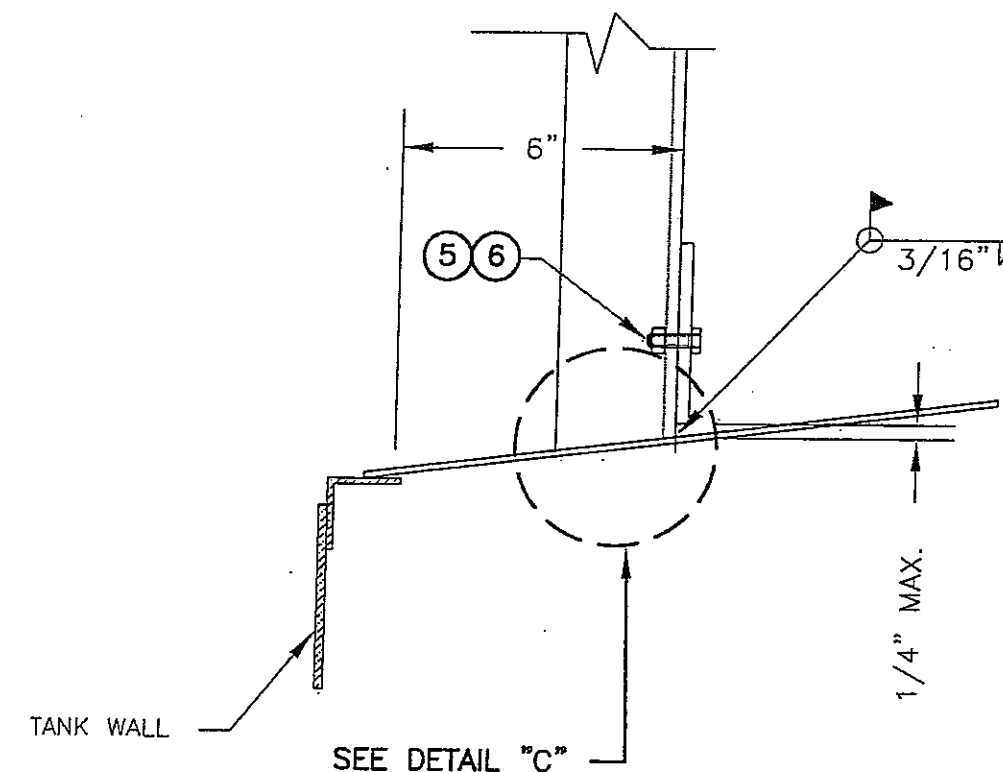

PITTSBURG TANK & TOWER CO.
GROUND TANK DIVISION
HENDERSON, KENTUCKY

DESCRIPTION 8' X 42" ROOF HAND RAIL



CUSTOMER TETON SPGS. GOLF & CSTG. CLUB
TETON SPRINGS, IDAHO

DRAWN BY: JOE B. JOB NO. 4742
CHECKED BY: PROJ. MGR. JEFF BYRD
APPROVED BY: *[Signature]* SHEET NO. 18
DATE 8/9/02 SCALE NONE

NO.	REVISION	DATE	BY
This drawing and its designs are part of the intellectual property of PITTSBURG TANK & TOWER and may not be copied or used without the written permission of PITTSBURG TANK & TOWER. This drawing, its designs and any information hereon may not be disclosed to any third party without the written permission of PITTSBURG TANK & TOWER.			

BILL OF MATERIAL

MK. NO.	QTY.	ASSY. PC.	DESCRIPTION
A	20		ANCHOR CHAIR
1		20	PLATE, A-36 1" x 5" x 6"
2		40	PLATE, A-36 1/2" x 5" x 11"

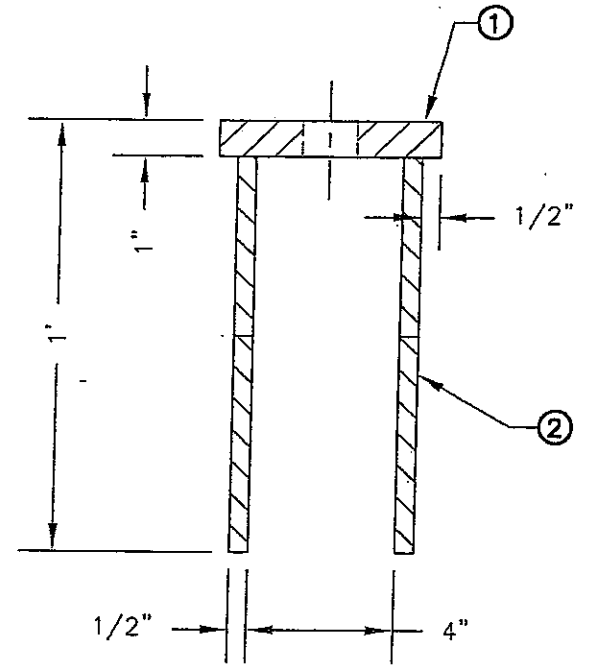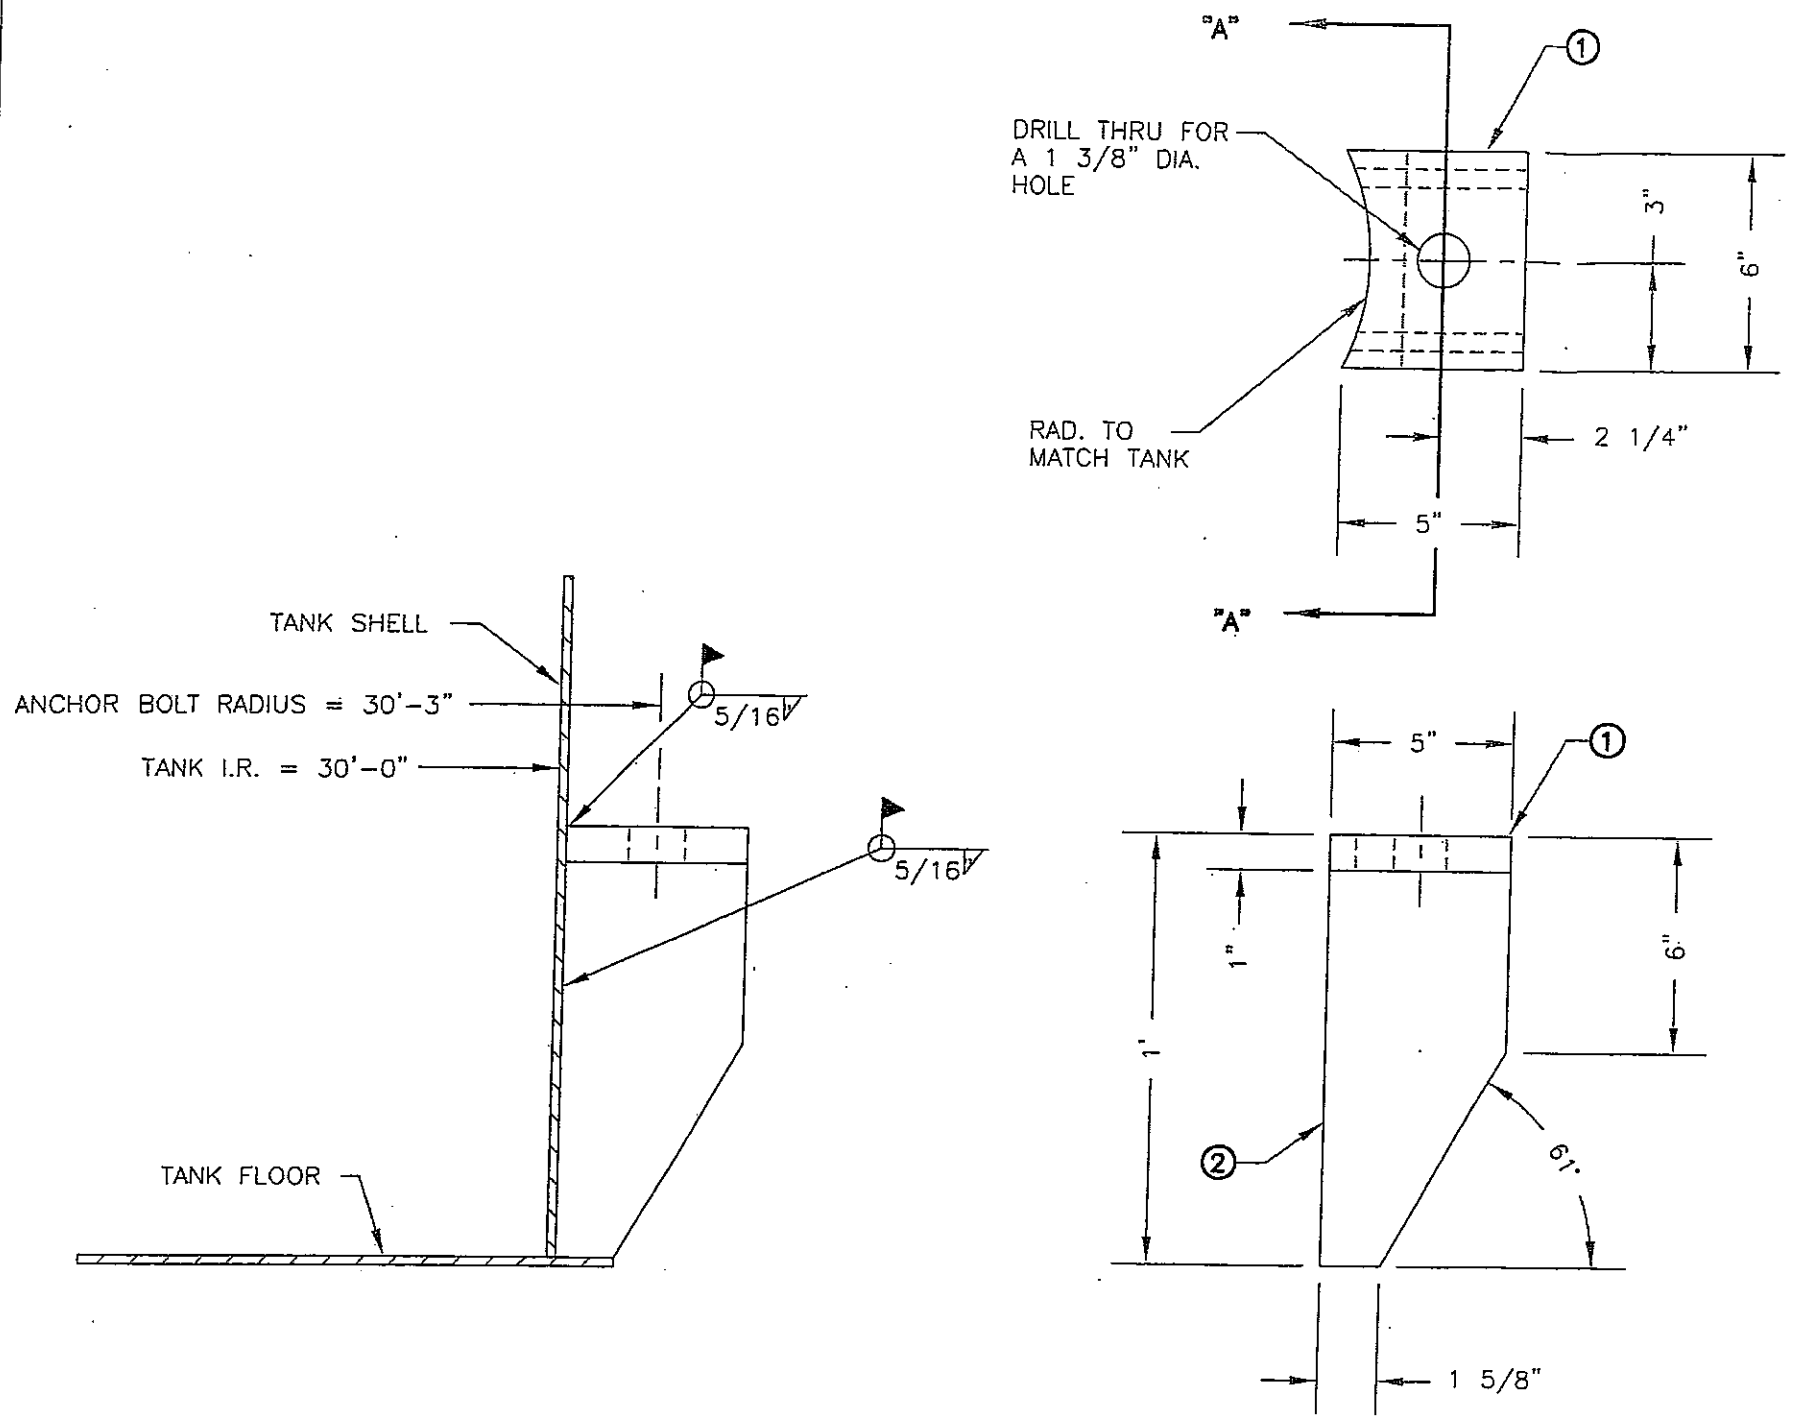

PITTSBURG TANK & TOWER CO.
GROUND TANK DIVISION
HENDERSON, KENTUCKY

DESCRIPTION ANCHOR CHAIR DETAIL

CUSTOMER TETON SPGS. GOLF & CSTG. CLUB
TETON SPRINGS, IDAHO


DRAWN BY: JOE B. JOB NO. 4742

CHECKED BY: PROJ. MGR. JEFF BYRD

APPROVED BY: *[Signature]* SHEET NO. 19


DATE 8/9/02 SCALE NONE

NO.	REVISION	DATE	BY
This drawing and its designs are part of the intellectual property of PITTSBURG TANK & TOWER and may not be copied or used without the written permission of PITTSBURG TANK & TOWER. This drawing, its designs and any information hereon may not be disclosed to any third party without the written permission of PITTSBURG TANK & TOWER.			

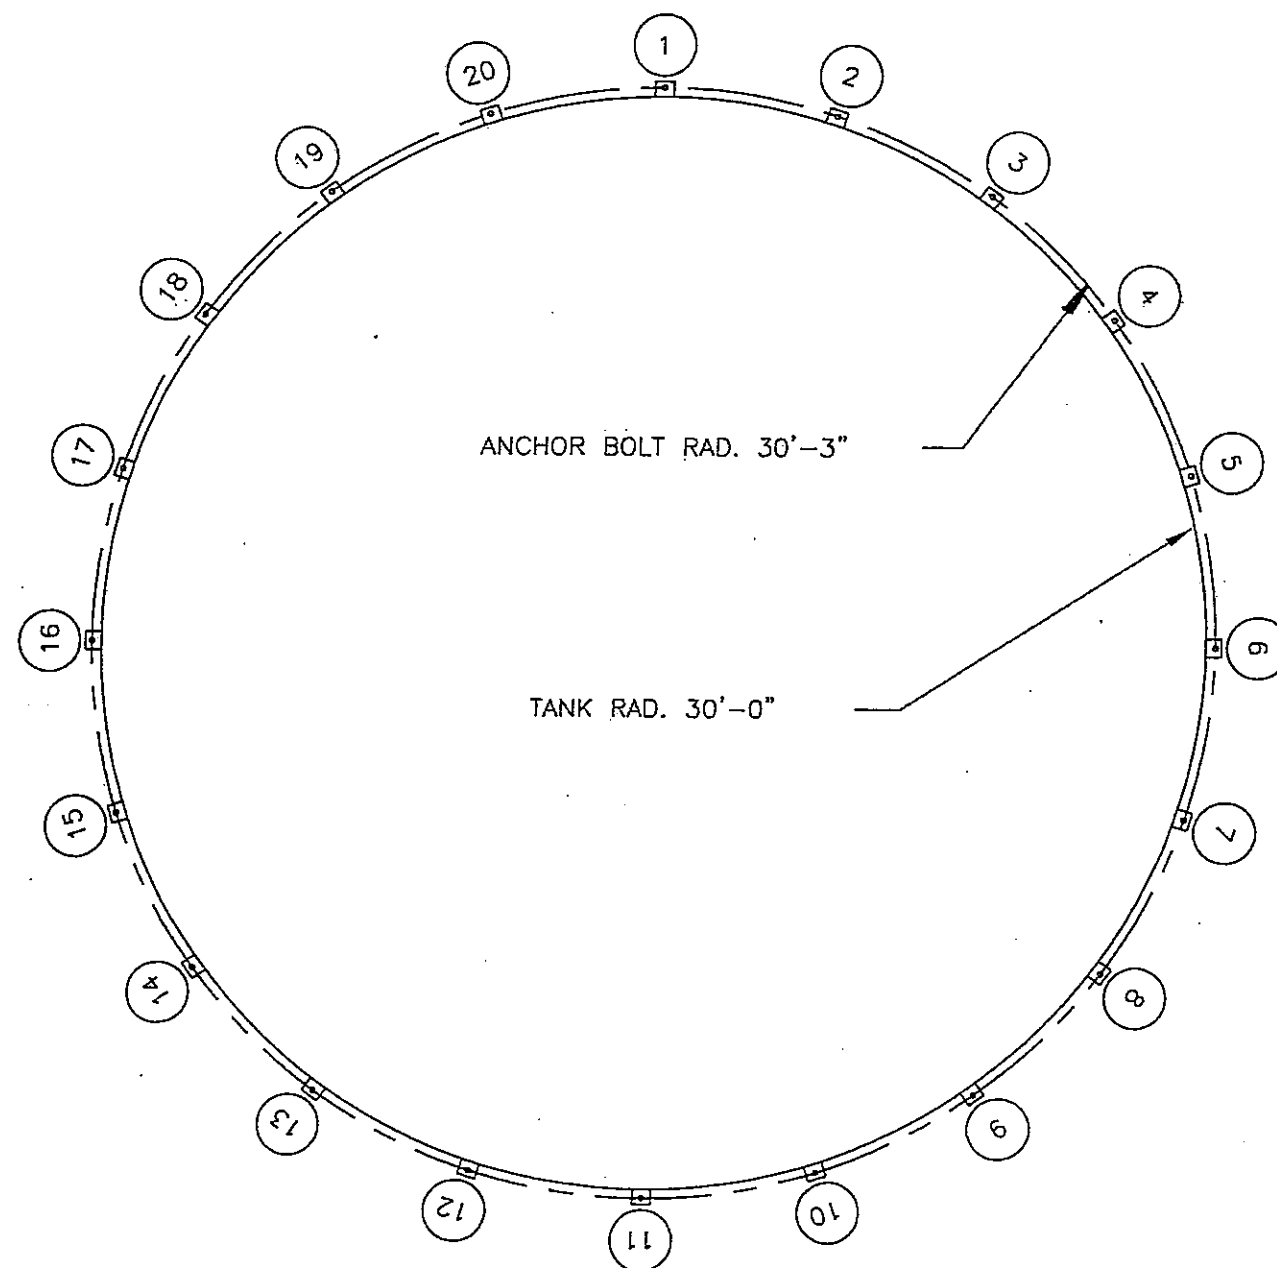


ANCHOR BOLT CHORDS:


1 TO 2	9'-5 9/16"
1 TO 3	18'-8 3/8"
1 TO 4	27'-5 5/8"
1 TO 5	35'-6 3/4"
1 TO 6	42'-9 3/8"
1 TO 7	48'-11 3/8"
1 TO 8	53'-10 7/8"
1 TO 9	57'-6 7/16"
1 TO 10	59'-9 1/16"
1 TO 11	60'-6"
1 TO 12	59'-9 1/16"
1 TO 13	57'-6 7/16"
1 TO 14	53'-10 7/8"
1 TO 15	48'-11 3/8"
1 TO 16	42'-9 3/8"
1 TO 17	35'-6 3/4"
1 TO 18	27'-5 5/8"
1 TO 19	18'-8 3/8"
1 TO 20	9'-5 9/16"

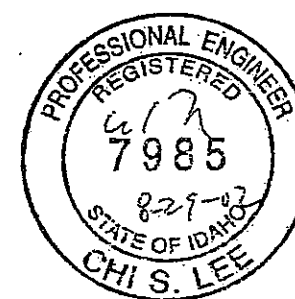

BILL OF MATERIAL

MK. NO.	QTY.	ASSY. PC.	DESCRIPTION
1	20		ANCHOR BOLT, A-36 1 1/4"Ø X 3'-6"
2	20		HEX NUT, A325 1 1/4"Ø
3	20		PLATE, A-36 1/2" X 5" SQUARE

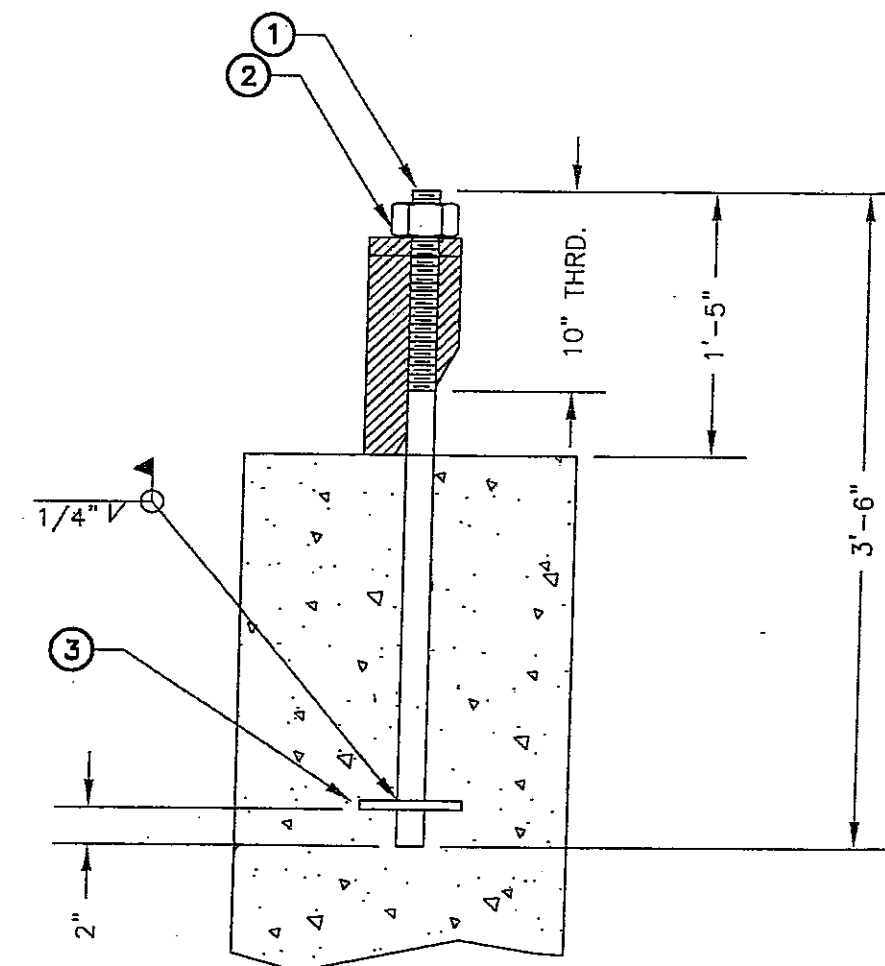

 
PITTSBURG TANK & TOWER CO.
 SINCE 1919
 GROUND TANK DIVISION
 HENDERSON, KENTUCKY

DESCRIPTION ANCHOR BOLT LAYOUT

CUSTOMER TETON SPGS. GOLF & CSTG. CLUB
 TETON SPRINGS, IDAHO

DRAWN BY: JOE B.	JOB NO. 4742
CHECKED BY:	PROJ. MGR. JEFF BYRD
APPROVED BY: <i>[Signature]</i>	SHEET NO. 20
DATE 8/9/02	SCALE NONE

NO.	REVISION	DATE	BY
This drawing and its designs are part of the intellectual property of PITTSBURG TANK & TOWER and may not be copied or used without the written permission of PITTSBURG TANK & TOWER. This drawing, its designs and any information hereon may not be disclosed to any third party without the written permission of PITTSBURG TANK & TOWER.			



BILL OF MATERIAL

MK. NO.	QTY.	ASSY. PC.	DESCRIPTION
A	1		NAME PLATE BRACKET
1		1	PLATE, A-36 10" x 1/4" x 7"
2		1	PLATE, A-36 4" x 1/4" x 7"
3		4	SCREWS, S.S. 1/8"
4		1	AWWA NAME PLATE

AWWA D100-96

4742		2002
CONTRACT NO.		YEAR
60'-0"	24'-0"	500,000
NOM. DIAMETER, FT	NOM. HEIGHT, FT	NOM CAPACITY, GAL
A-36		N.A.
MATERIAL		HEAT TREATMENT

FABRICATED AND ERECTED BY
PITTSBURG TANK & TOWER CO.
HENDERSON, KENTUCKY

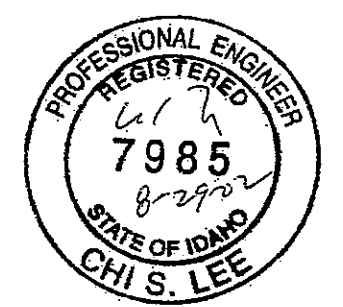
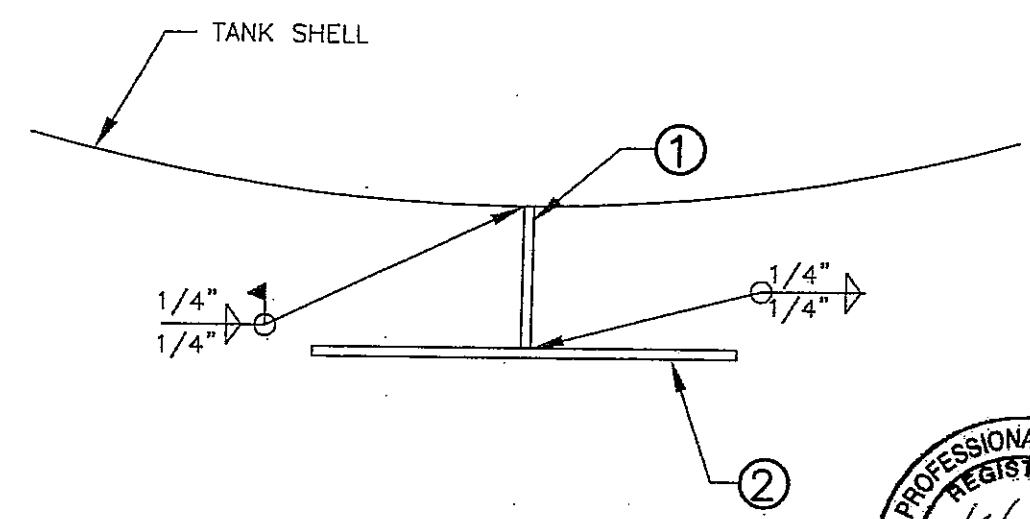


NAME PLATE DETAIL

MOUNTING BRACKET DETAIL


 PITTSBURG TANK & TOWER CO. SINCE 1919 GROUND TANK DIVISION HENDERSON, KENTUCKY	
DESCRIPTION AWWA D-100 NAME PLATE	
CUSTOMER TETON SPGS. GOLF & CSTG. CLUB TETON SPRINGS, IDAHO	
DRAWN BY: JOE B.	JOB NO. 4742
CHECKED BY:	PROJ. MGR. JEF BYRD
APPROVED BY: <i>[Signature]</i>	SHEET NO. 21
DATE 8/9/02	SCALE NONE

NO.	REVISION	DATE	BY
This drawing and its designs are part of the intellectual property of PITTSBURG TANK & TOWER and may not be copied or used without the written permission of PITTSBURG TANK & TOWER. This drawing, its designs and any information hereon may not be disclosed to any third party without the written permission of PITTSBURG TANK & TOWER.			

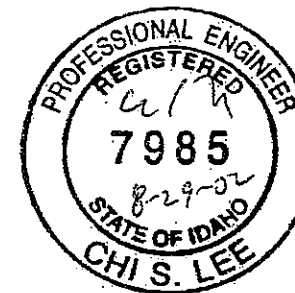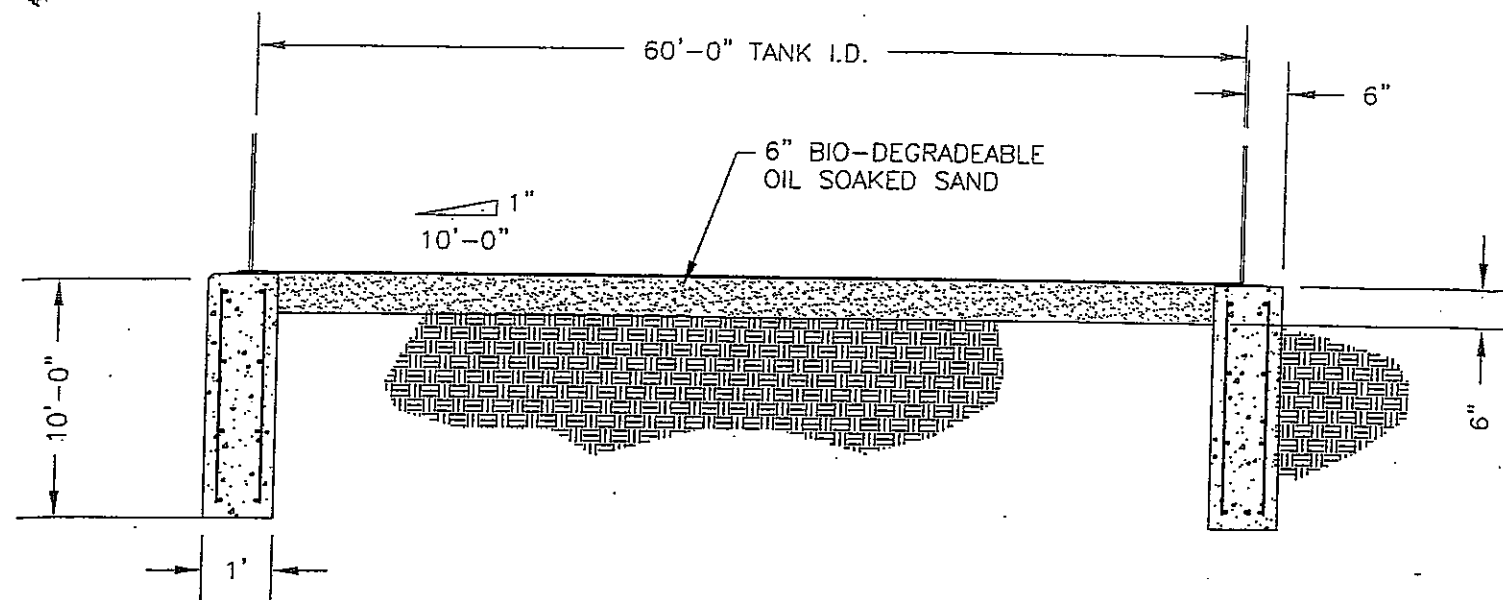


NOTES:

1. BOTTOM OF RINGWALL SHALL BE POURED ON UNDISTURBED SOIL.
2. ALL CONCRETE SHALL DEVELOP A MINIMUM COMPRESSIVE STRENGTH OF 4000 P.S.I. AT 28 DAYS.
3. CYLINDERS SHALL BE CAST AND BE MARKED AS TO DATE AND LOCATION AS DIRECTED BY THE RESIDENT ENGINEER. (A MINIMUM OF ONE PER EACH 10 CUBIC YARDS.)
4. ALL REINFORCEMENT STEEL SHALL CONFORM TO A.S.T.M. SPECIFICATIONS FOR A-615 GRADE 60.
5. TOP OF RING WALL TO BE FINISHED LEVEL WITHIN 1/8 INCH.
6. FOUNDATION DESIGNED ON AN ALLOWABLE SOIL BEARING PRESSURE OF 2000 P.S.F.
7. ALL BACKFILL SHALL BE COMPACTED TO 95% OF THE SOIL BEARING PRESSURE FOR WHICH THE FOUNDATION IS DESIGNED.
8. BACKFILL VOLUME SHALL BE KEPT TO A MINIMUM.
9. FOUNDATION TO BE CONSTRUCTED IN ACCORDANCE WITH A.C.I. STANDARDS.
10. VALVE PIT, IF REQUIRED, TO BE BY OTHERS.
11. AREA AROUND TANK TO BE GRADED FOR POSITIVE DRAINAGE AWAY FROM TANK FOUNDATION.

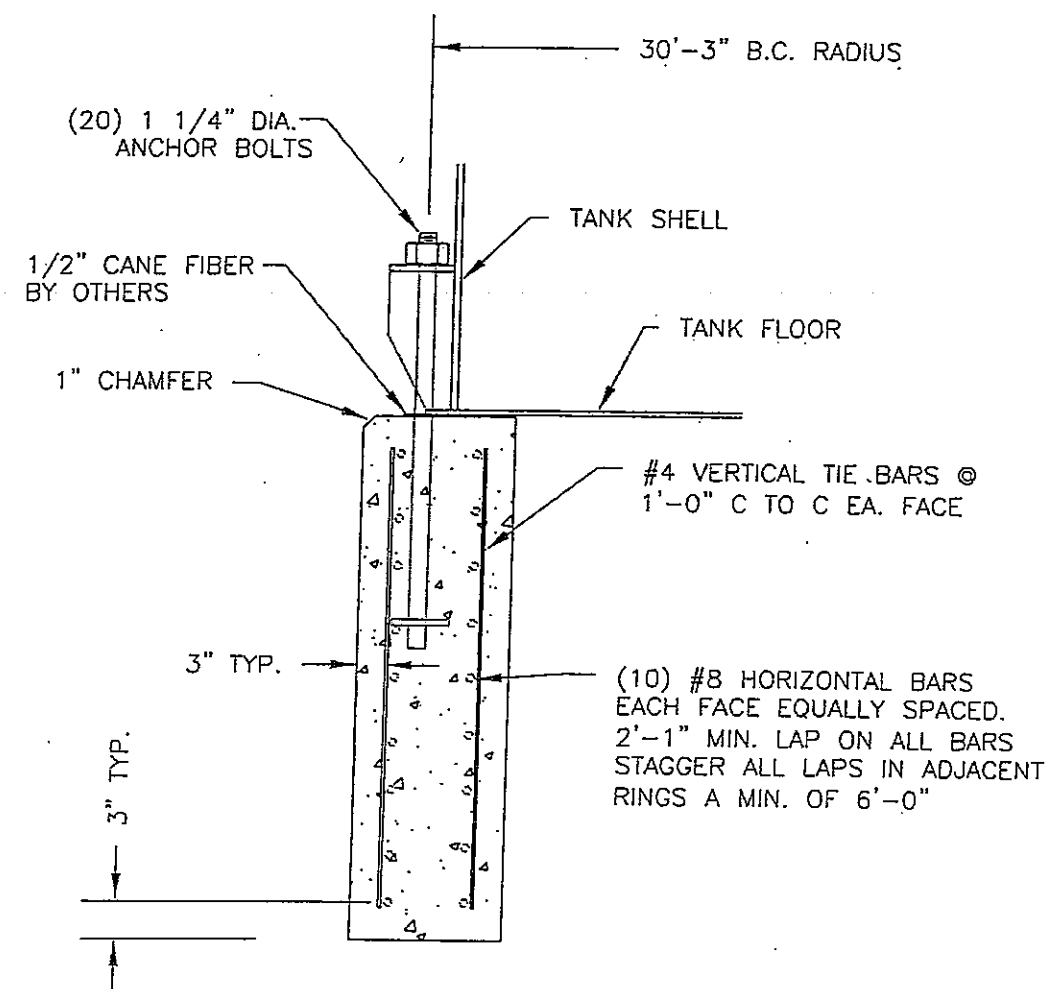

REINFORCING STEEL DETAIL

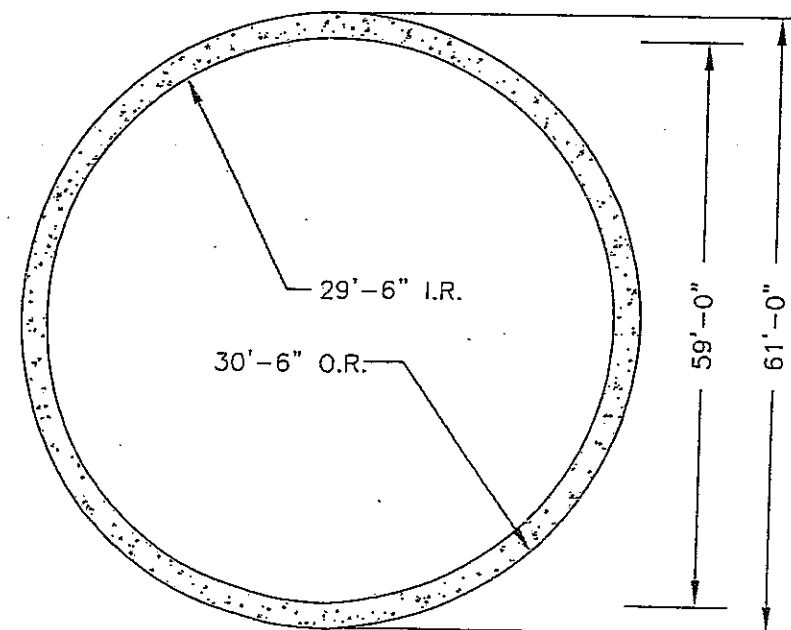

PLAN VIEW

DESIGN LOADS:
WIND - 100 M.P.H.
SNOW - 100 P.S.F.
SEISMIC - ZONE 3

NOTE:
FOUNDATION DESIGN BASED UPON 2000 PSF ALLOWABLE SOIL BEARING CAPACITY. PRIOR TO BEGINNING CONSTRUCTION A QUALIFIED SOILS ENGINEER SHOULD VERIFY SOIL BEARING CAPACITY.



PITTSBURG TANK & TOWER CO.
GROUND TANK DIVISION
HENDERSON, KENTUCKY

DESCRIPTION RINGWALL FOUNDATION
FOR A 60'-0" X 24'-0" G.S.T.

CUSTOMER TETON SPGS. GOLF & CSTG. CLUB
TETON SPRINGS, IDAHO

DRAWN BY: JOE B.	JOB NO. 4742
CHECKED BY:	PROJ. MGR. JEFF BYRD
APPROVED BY: <i>[Signature]</i>	SHEET NO. 22
DATE 8/9/02	SCALE NONE

NO.	REVISION	DATE	BY
This drawing and its designs are part of the intellectual property of PITTSBURG TANK & TOWER and may not be copied or used without the written permission of PITTSBURG TANK & TOWER. This drawing, its designs and any information hereon may not be disclosed to any third party without the written permission of PITTSBURG TANK & TOWER.			