


CABINET MOUNTAINS WATER DISTRICT WATER SYSTEM IMPROVEMENTS WELL, BOOSTER STATION, & RESERVOIR 1995

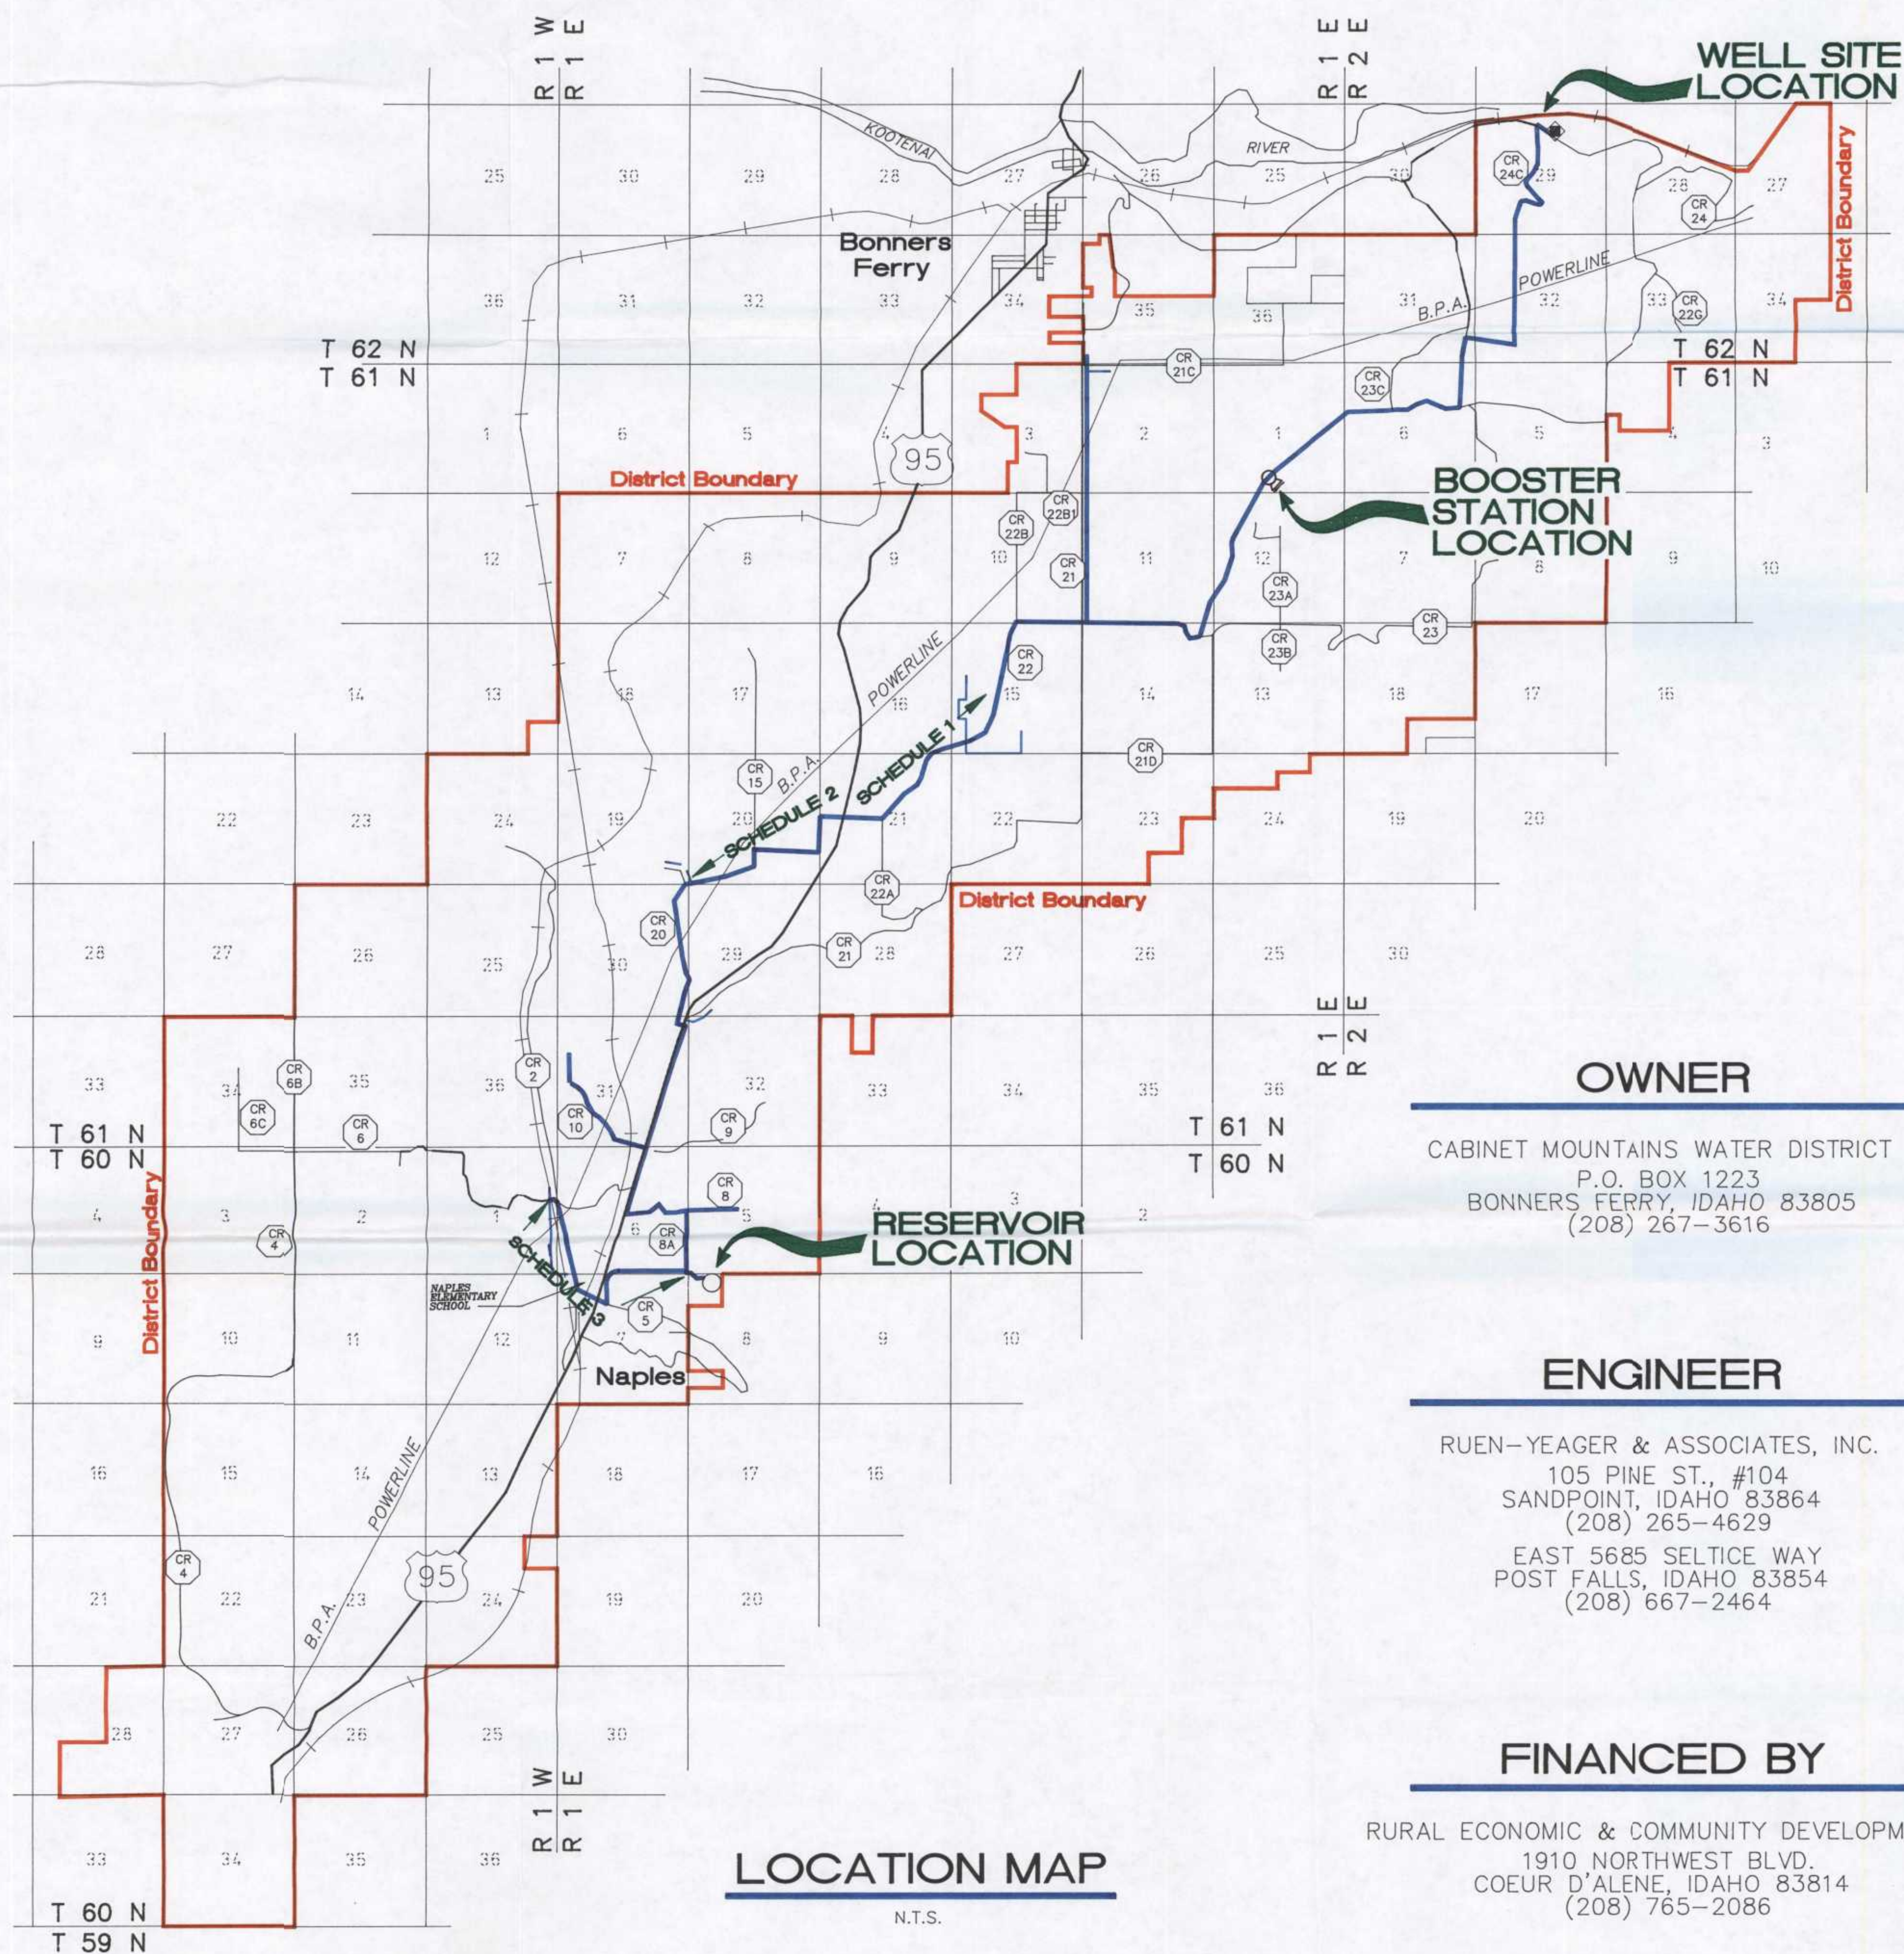


INDEX OF SHEETS

1	TITLE SHEET
2	WELL SITE TOPO
3	WELL SITE LOCATION PLAN
4	WELL HOUSE PIPING DETAIL
5	WELL HOUSE BUILDING DETAILS
6	BOOSTER STATION SITE PLAN
7	BOOSTER STATION PLAN
8	BOOSTER STATION DETAILS
9	RESERVOIR SITE PLAN
10	RESERVOIR PLAN
11	RESERVOIR DETAILS
E1-E12	ELECTRICAL

LEGEND		
ITEM	EXISTING	NEW
RIGHT OF WAY	R/W	
EDGE OF GRAVEL	---	
EDGE OF PAVEMENT	---	
CENTERLINE	---	
DRY WELL		⊙
SANITARY SEWER FORCE MAIN		6"FM
WATER LINE	W	
FIRE HYDRANT	⊕	⊕
VALVES	⊗	⊗
WATER METER	⊗	⊗
POWER POLE	⊕	
GUY WIRE	---	
COMMUNICATION CABLE (UNDERGROUND)	---	
TELEPHONE SPLICE BOX	Δ	
LIGHT POLE	☆	
MAIL BOXES	○	
GRADE CONTOUR	---2200---	---2200---
SIGN	---	

PROJECT:	438A
PLOT DATE:	5/26/95
FILE NAME:	R438A_1.DWG
SHEET NUMBER:	1 OF 11

CABINET MOUNTAINS WATER DISTRICT

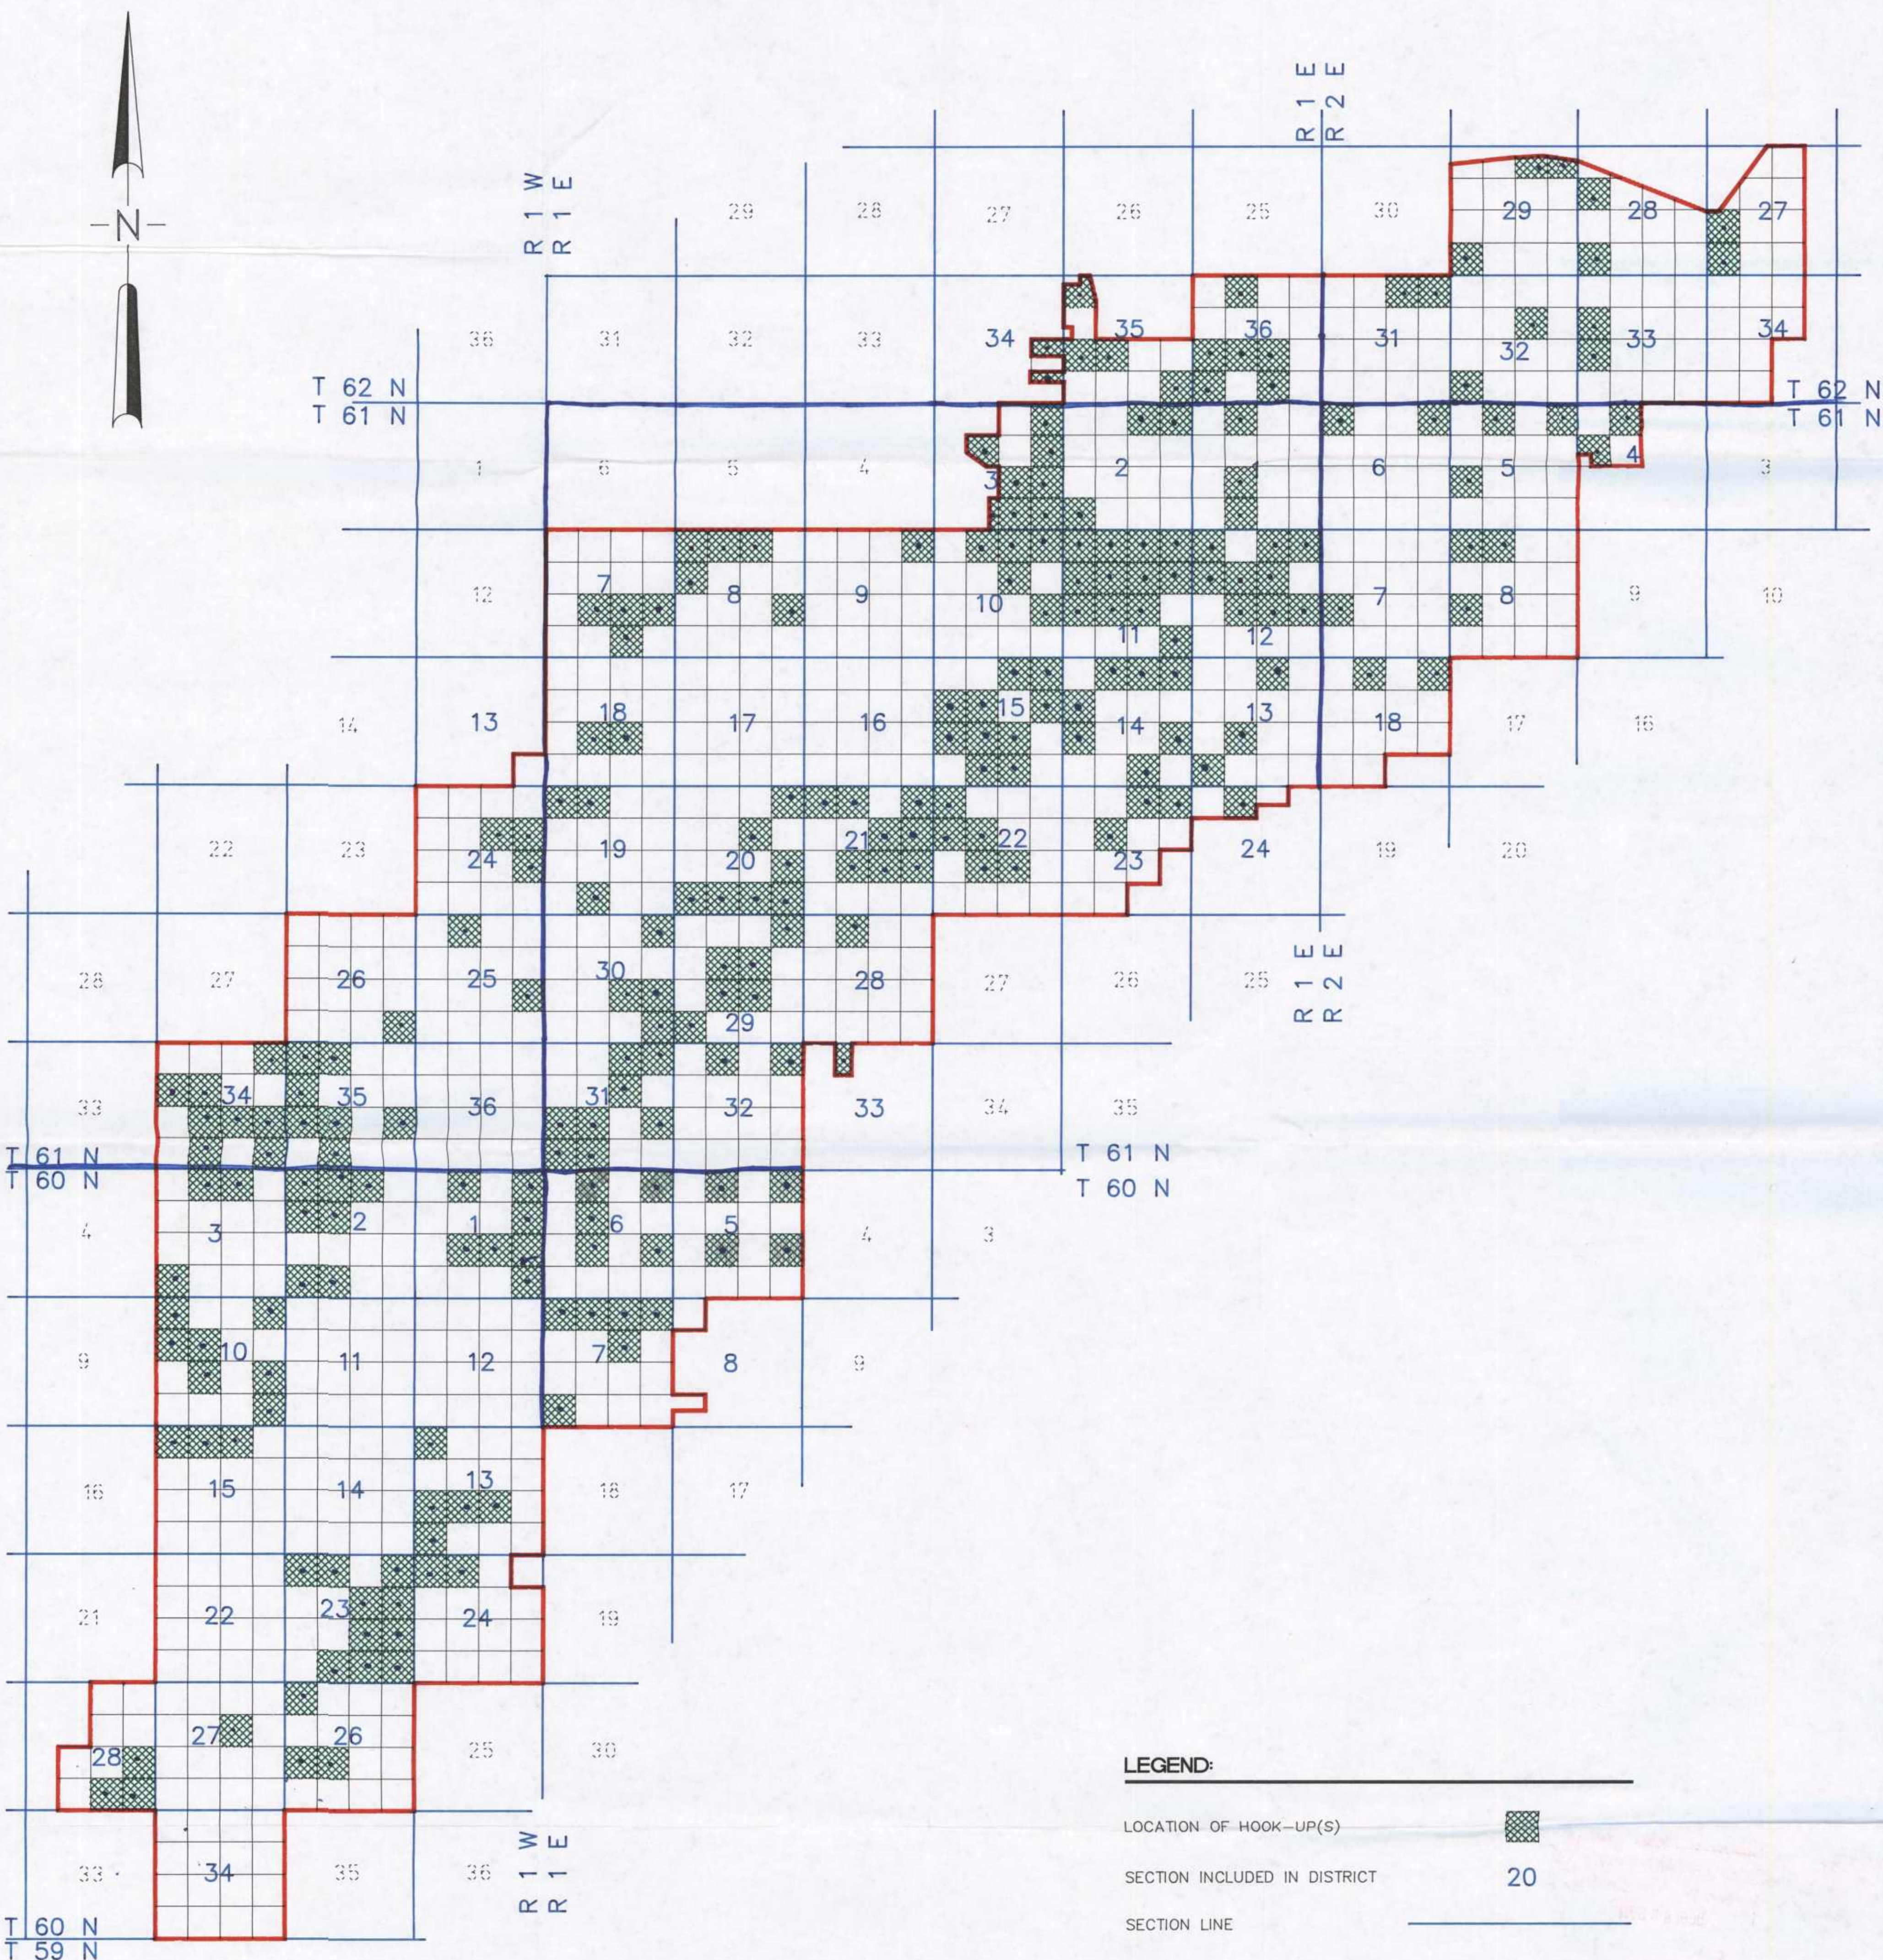

LEGEND:

- LOCATION OF HOOK-UP(S)
- SECTION INCLUDED IN DISTRICT 20
- SECTION LINE
- 1/16TH LINE
- DISTRICT BOUNDARY LINE

