


HARBOR VIEW ESTATES



WATER AND SEWER SYSTEMS

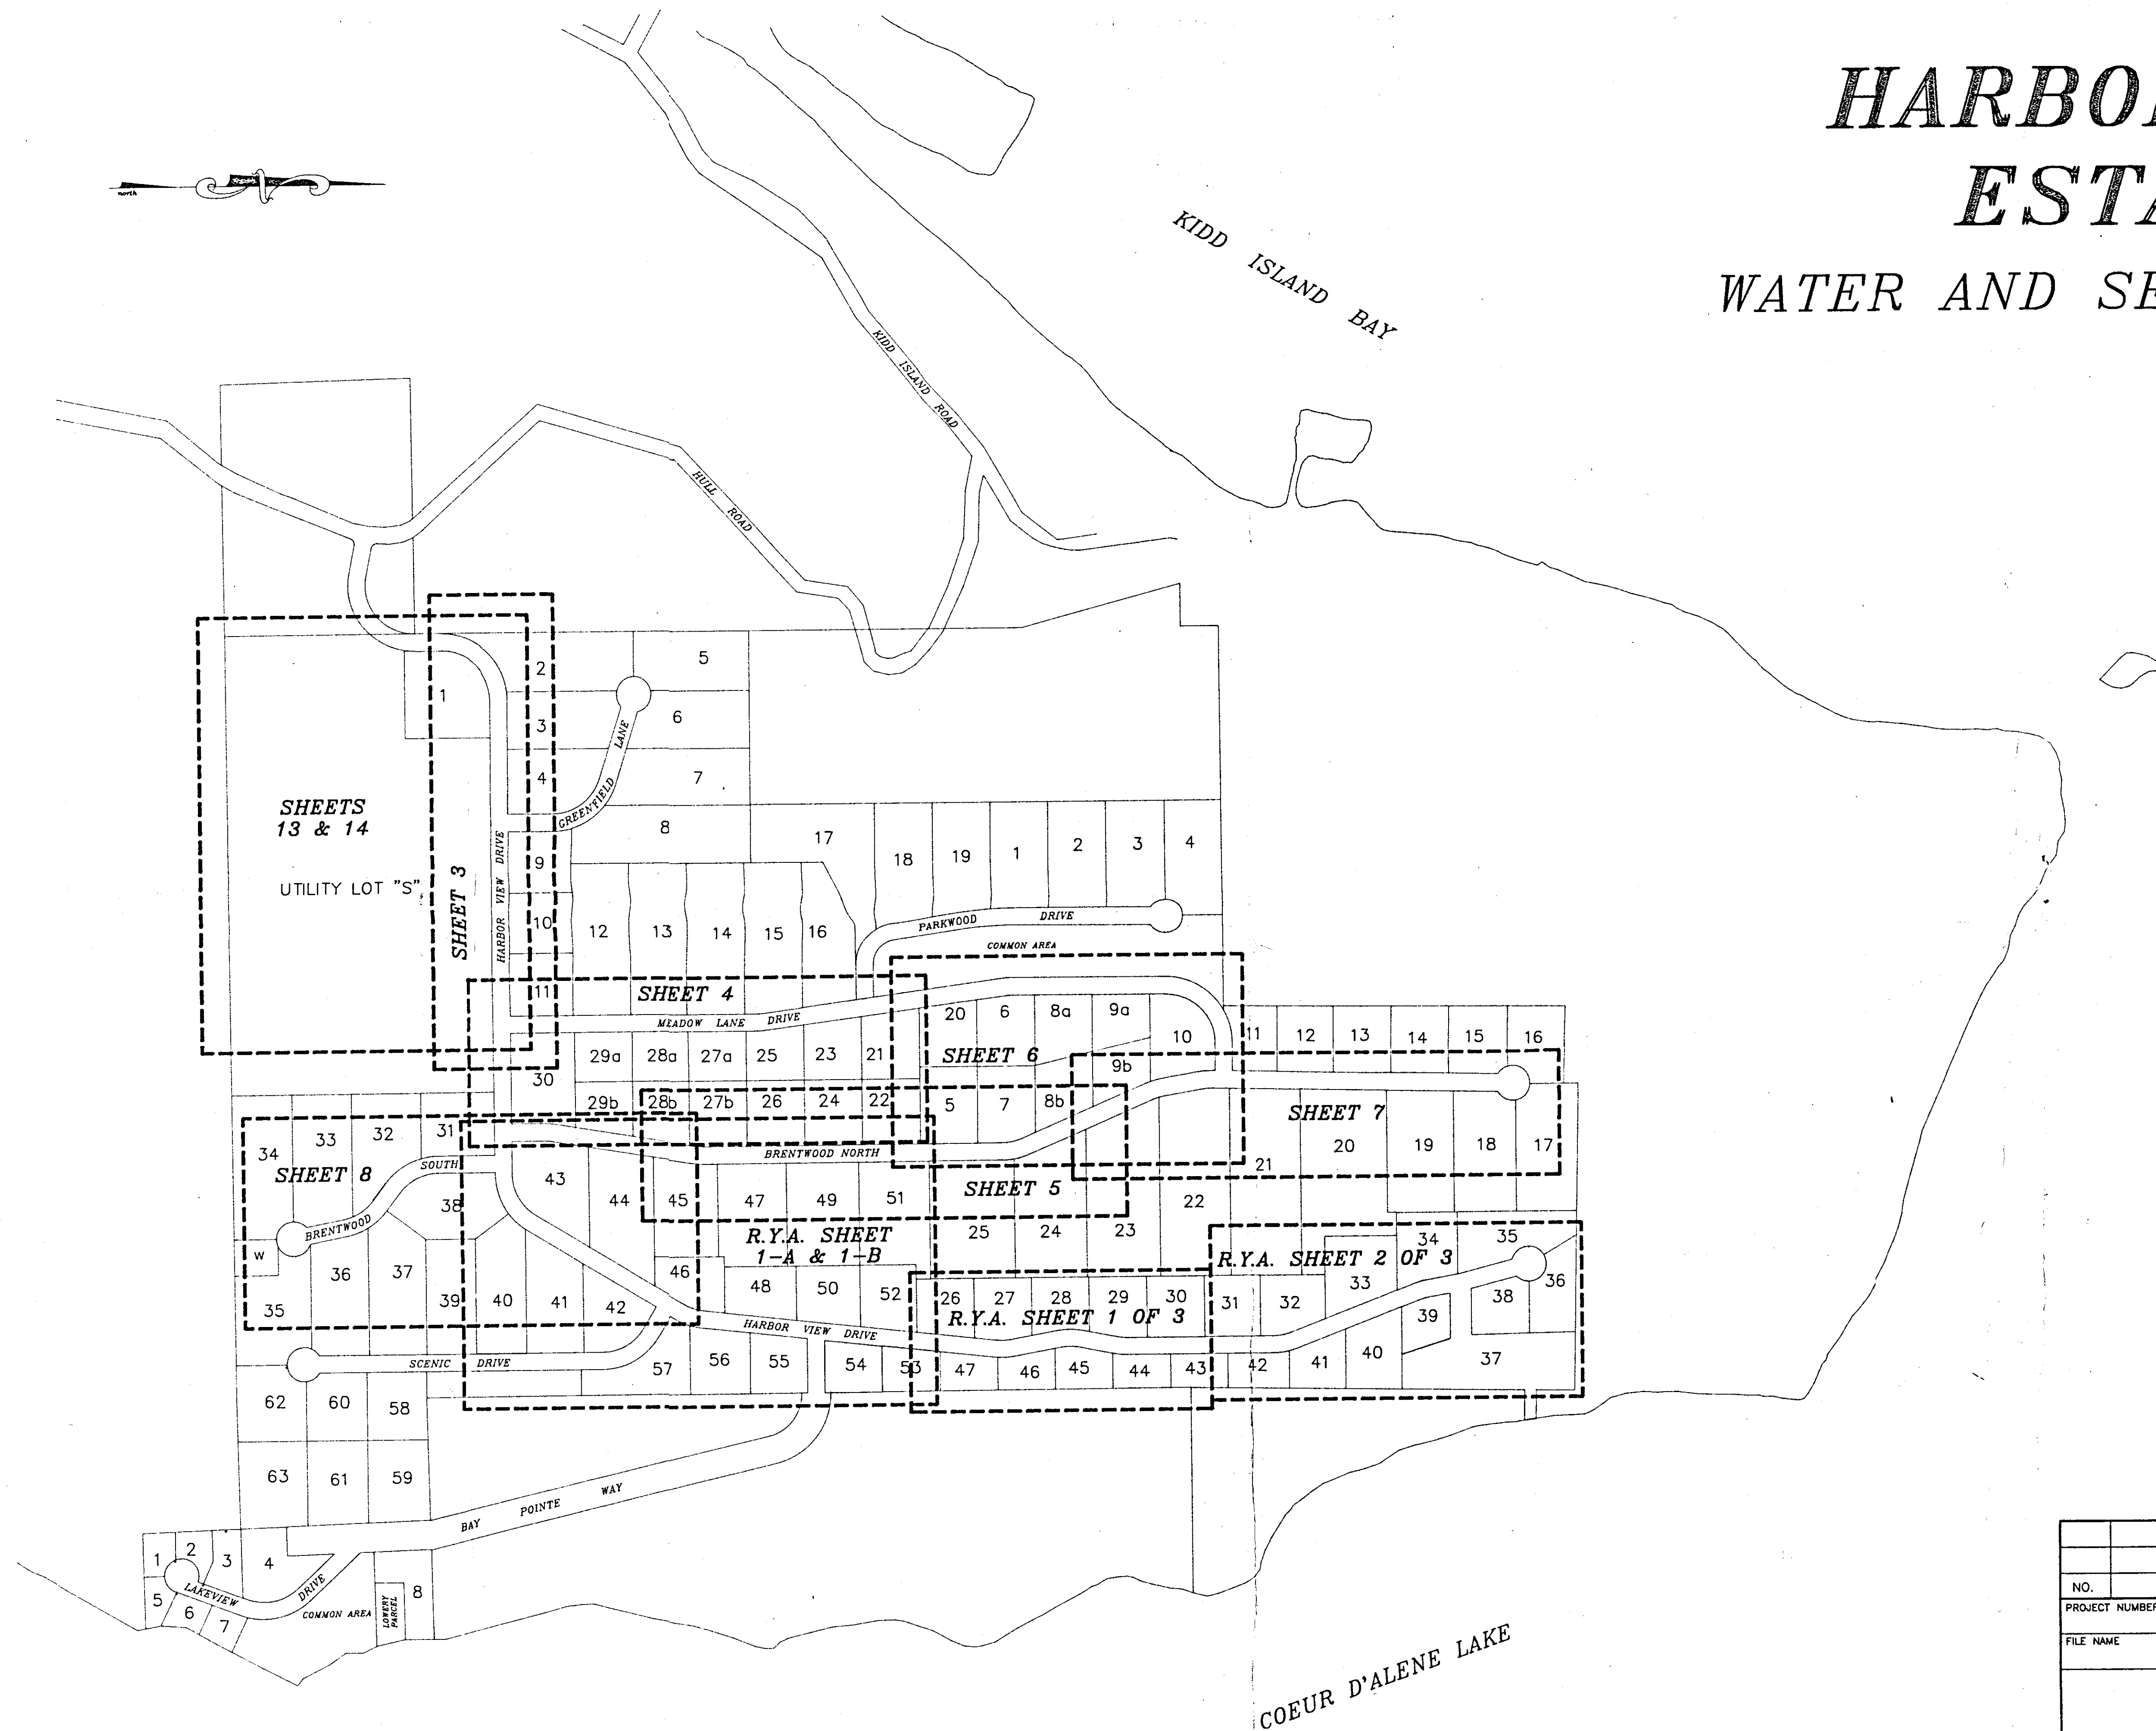

95-0847

NO.	REVISION	BY	DATE
PROJECT NUMBER 241C	HARBOR VIEW ESTATES WATER & SEWER INDEX MAP		
FILE NAME D241C_0			
RUEN-YEAGER & ASSOCIATES, INC. Consulting Engineers 1119 Ironwood Parkway, Suite 200 Coeur d'Alene, Idaho 83814		SCALE 1" = 300'	
PLOT DATE 11-7-91	DESIGN BY	DRAWN BY J.L.G.	SHEET 1 OF 22
	DATE 8-15-91		

PROFILE	BY DATE	
SURVEYED:		
PLOTTED:		
GRAPHS CHECKED:		
B. M.'S. NOTED:		

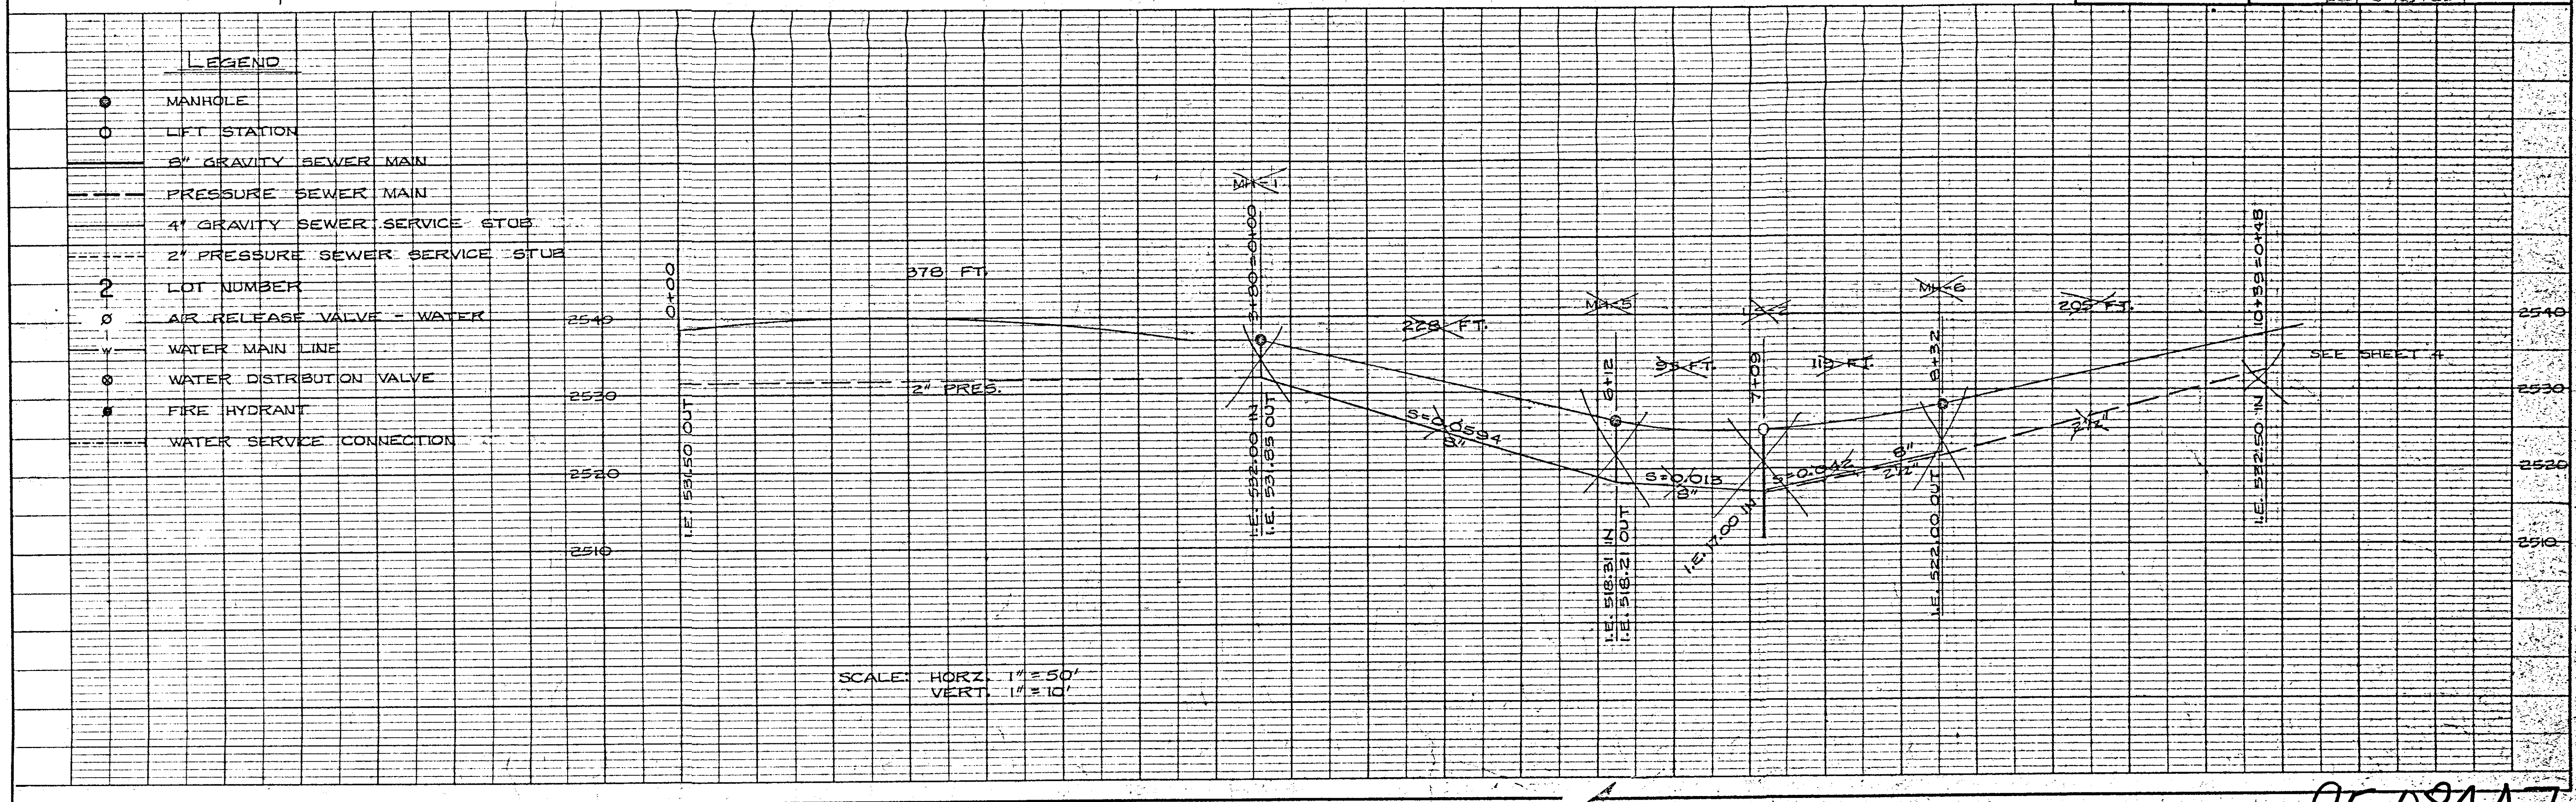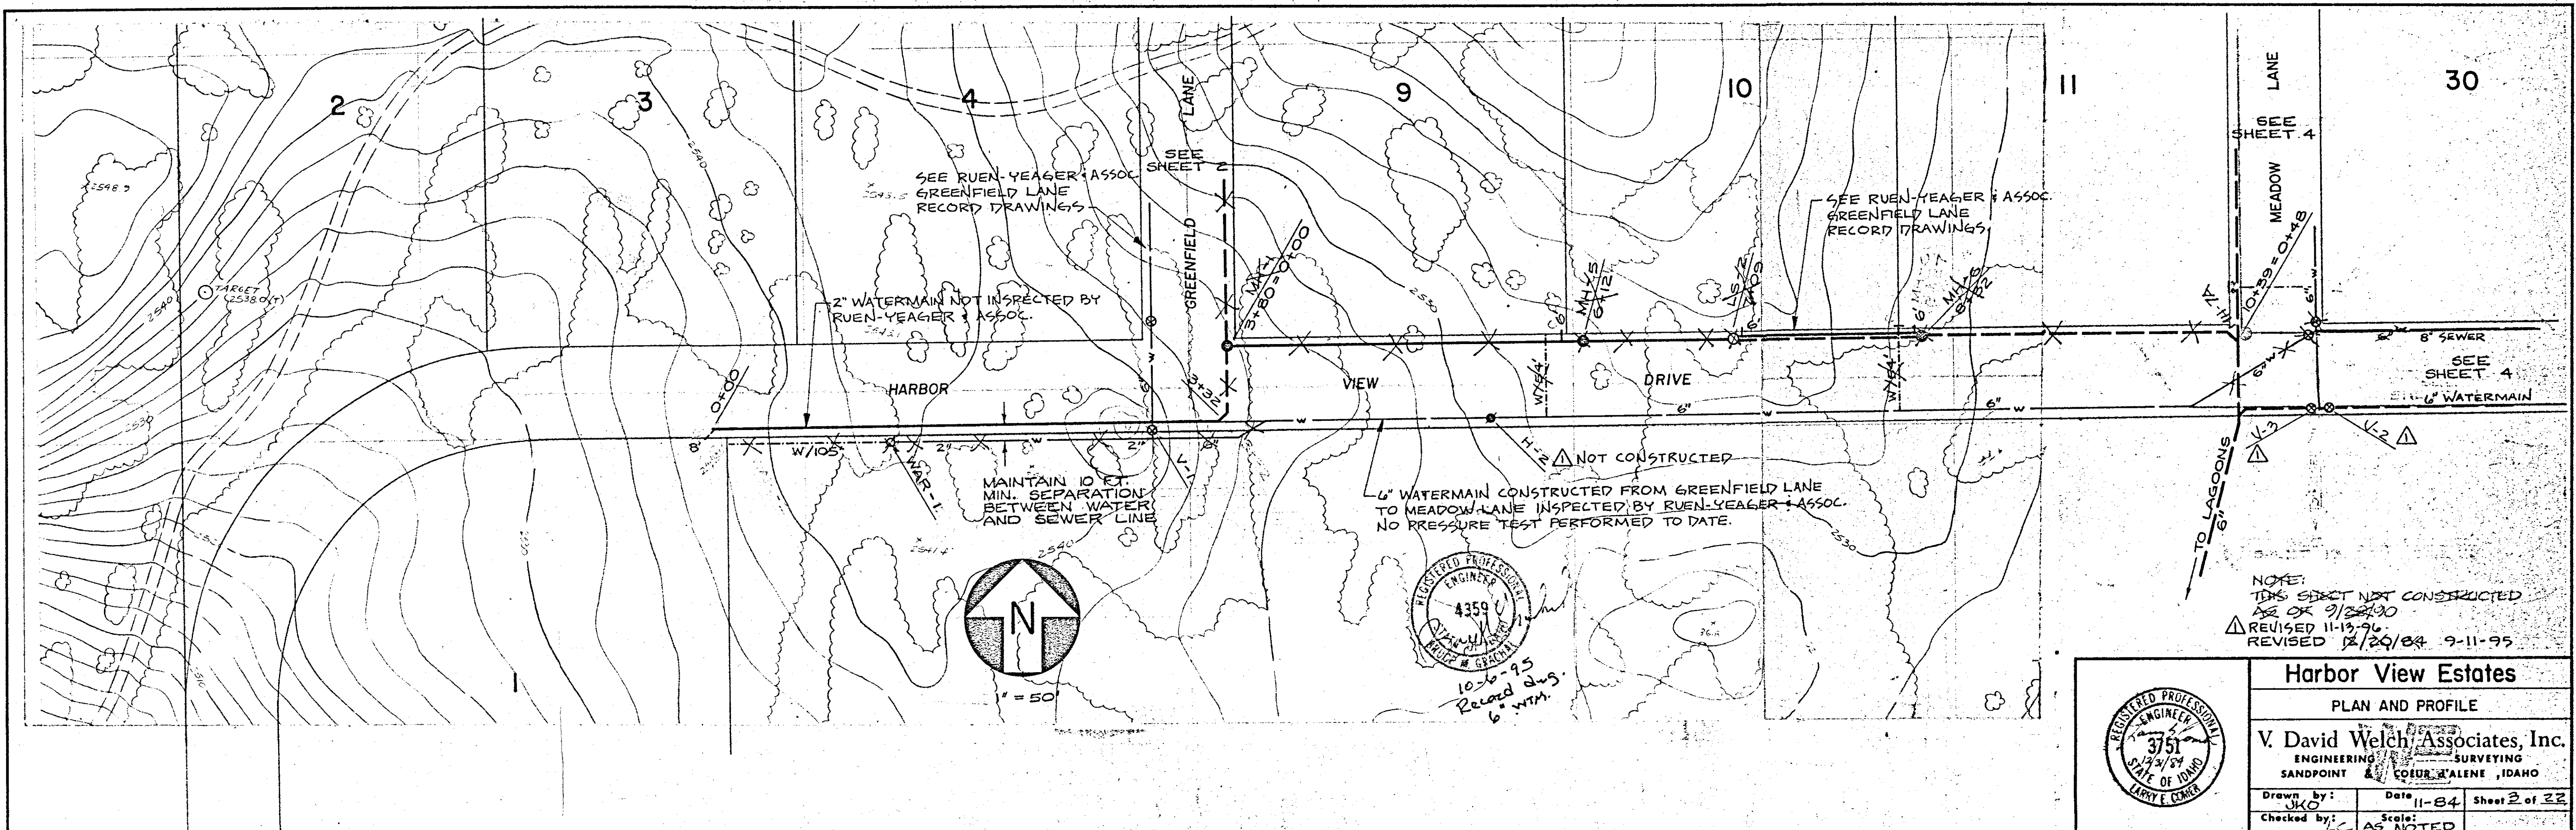

95-08447

PLAN	DATE	BY
	REVIEWED	BY
	NOTE BOOK	NO.
	ALIGNMENT CHECKED	BY

PROFILE	DATE	BY
	REVIEWED	BY
	NOTE BOOK	NO.
	GRAVITY CHECKED	BY

28

27

26



24

22

5

7

8

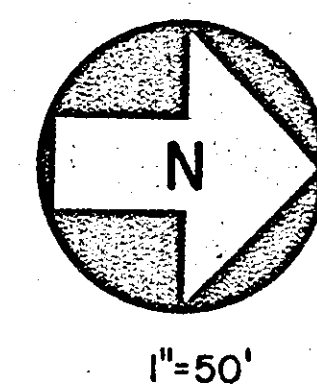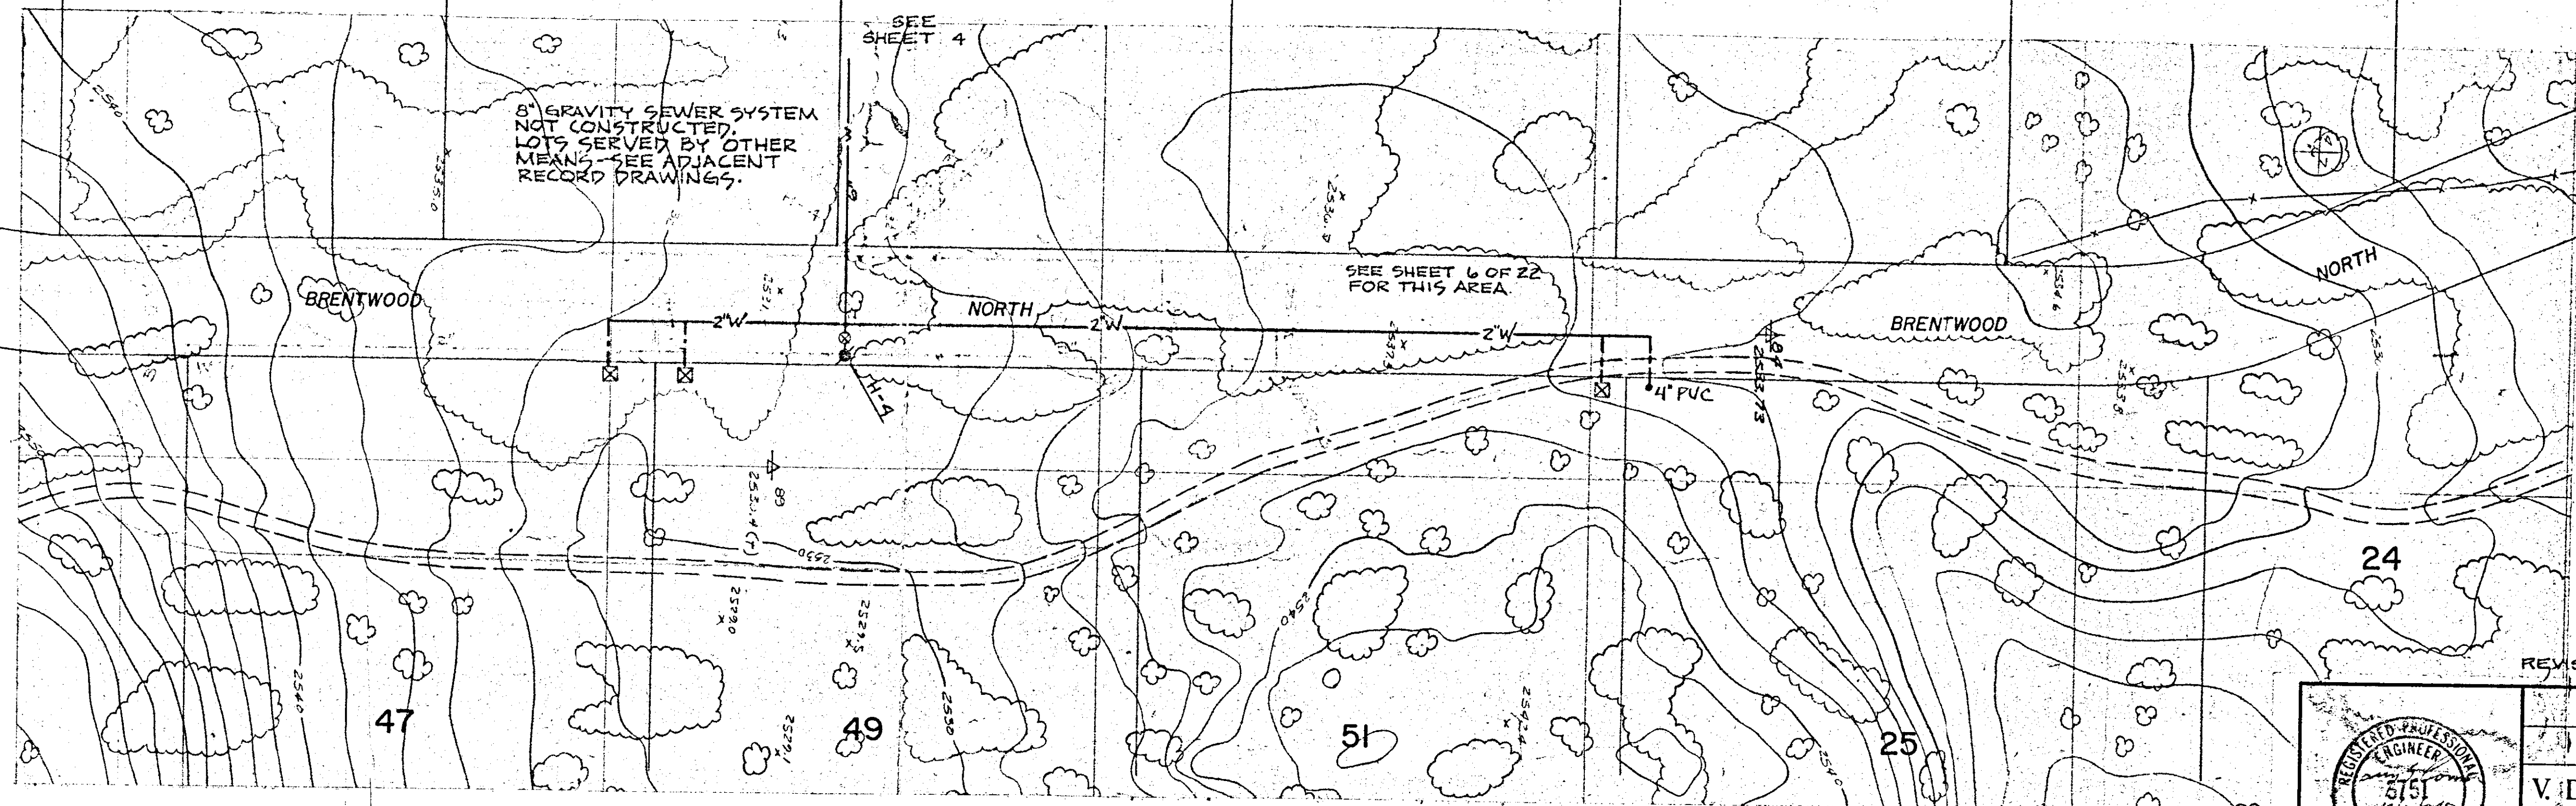


1"=50'

23

REVISED 11-13-96 - F.H. ON EAST SIDE & SEWER SYSTEM DELETED

REVISED 12/20/84

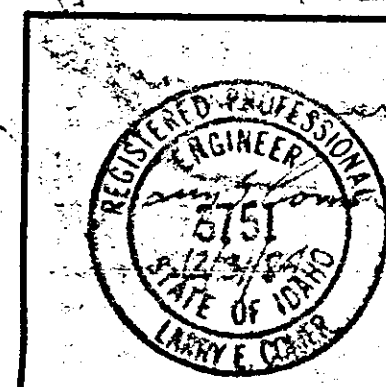


Harbor View Estates



PLAN AND PROFILE

V. David Welch Associates, Inc.
ENGINEERING SURVEYING
SANDPOINT & COEUR D'ALENE, IDAHO

Drawn by: L.P. Date: 11/84
Checked by: J.S. Scale: AS NOTED Sheet 5 of 22

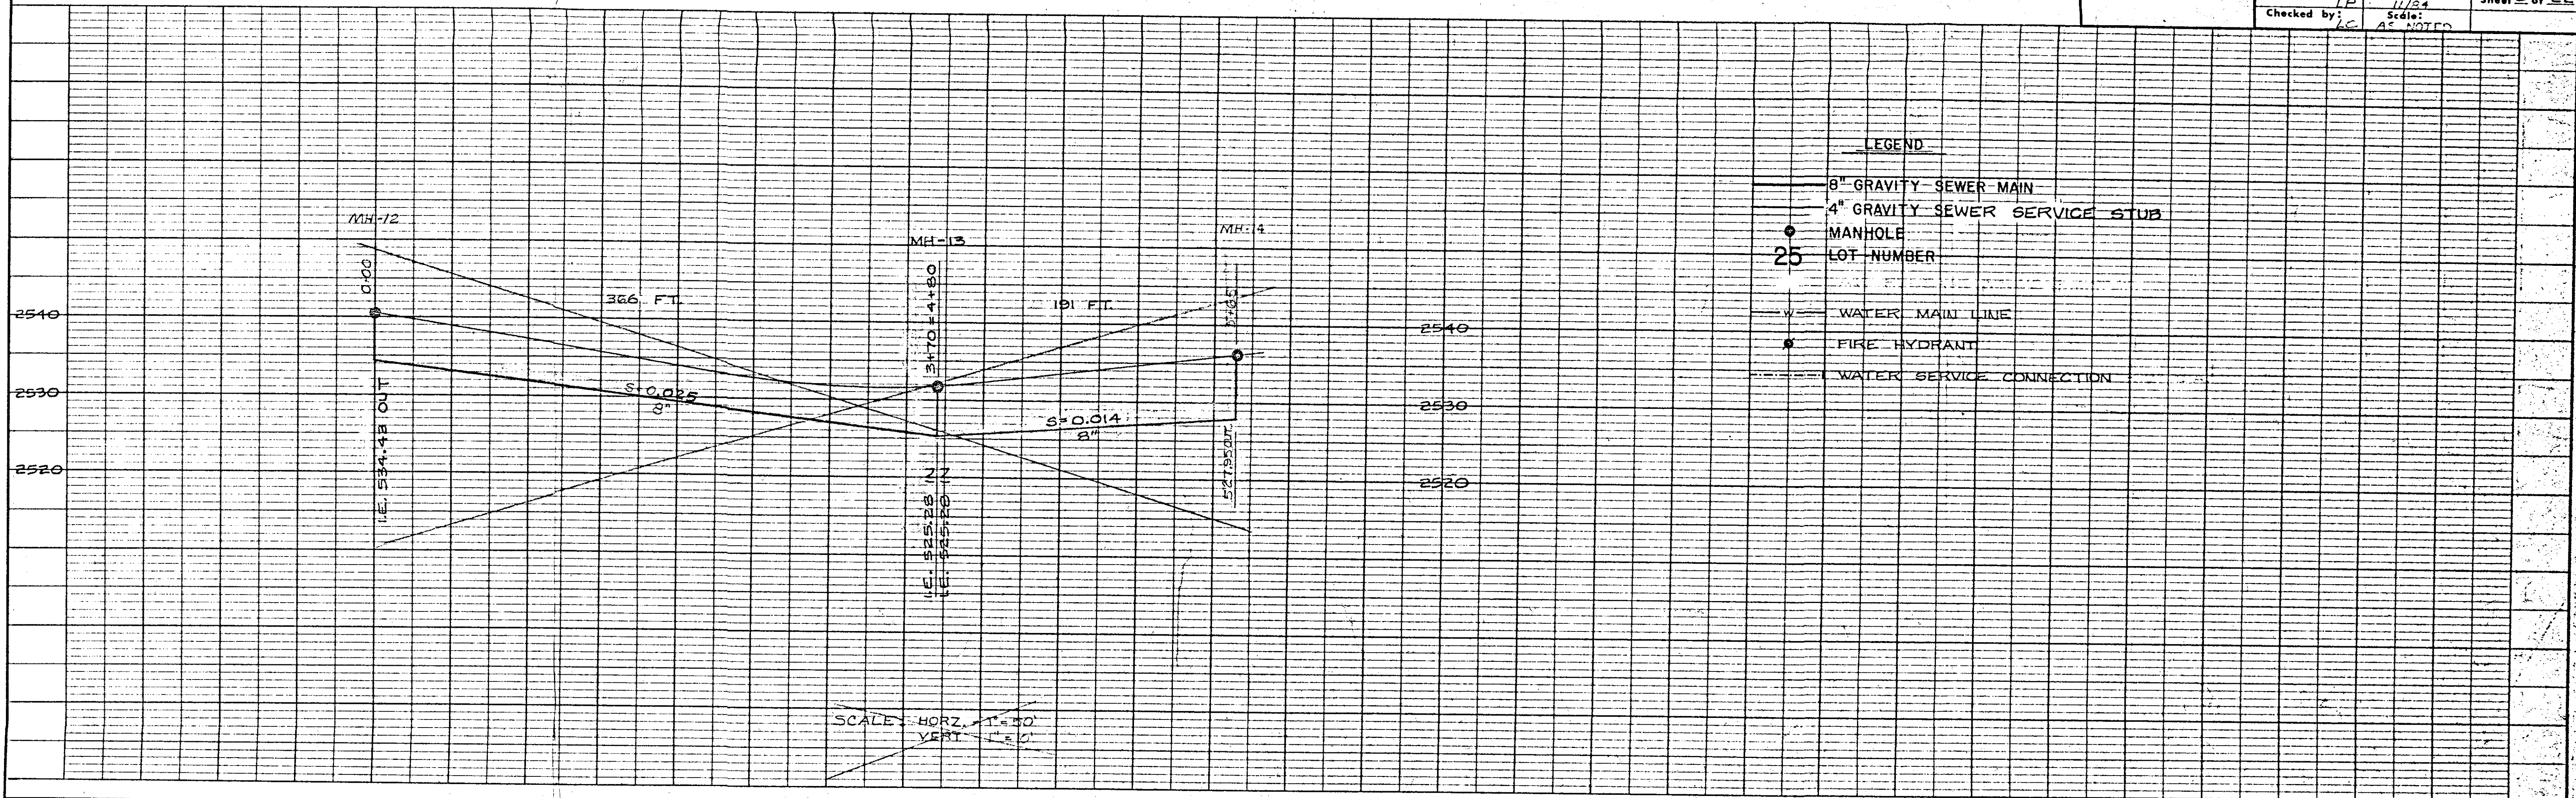


95-08447

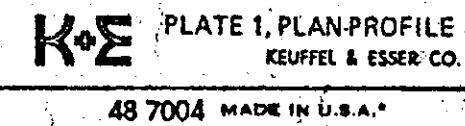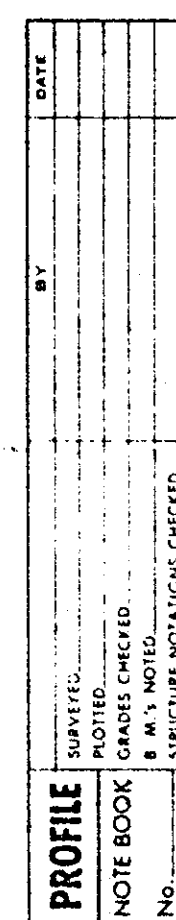


REVISID 12/20/84
REVISID 11-15-96 - WATERLINE
NOT CONSTRUCTED & H-T REVISID

PLAN	DATE	
	BY	
	REVISIONS	
	NOTES	

PROFILE	DATE	
	BY	
	REVISIONS	
	NOTES	

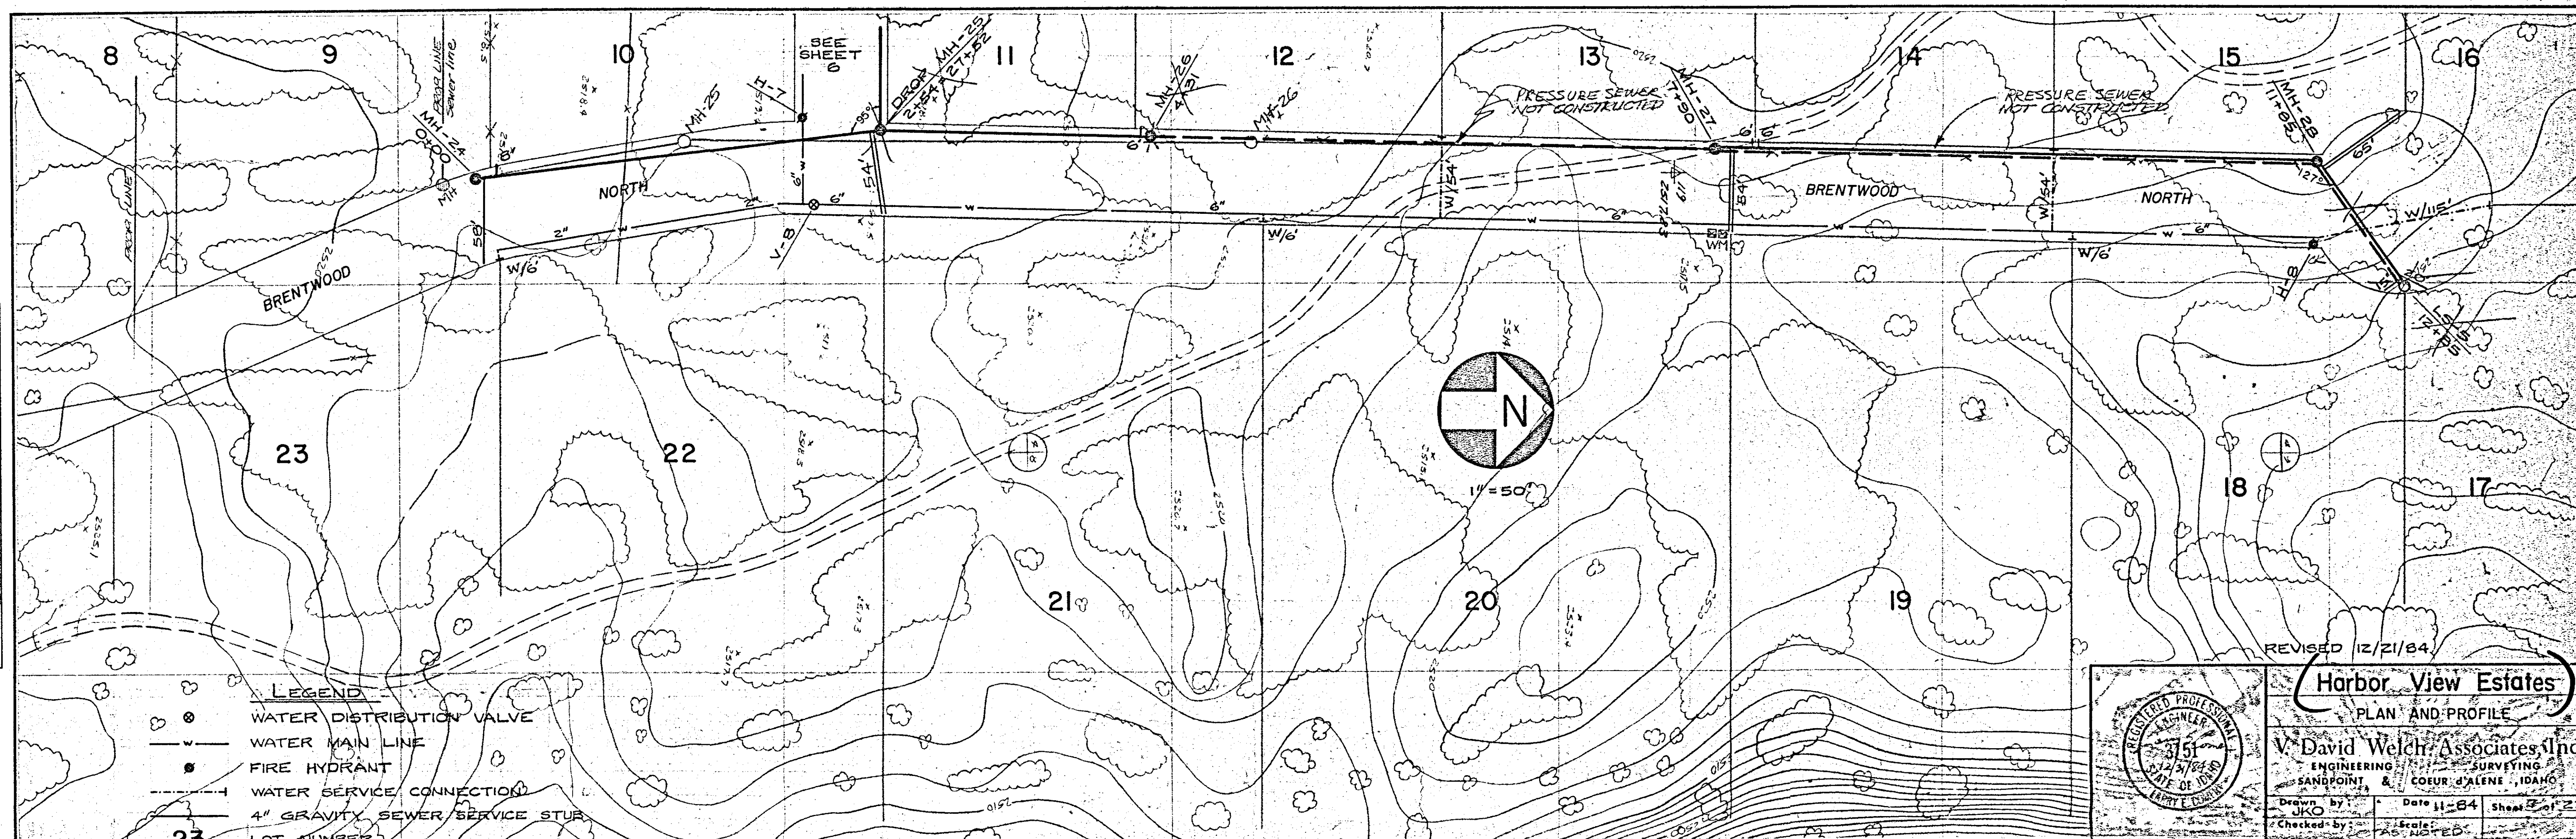

- LEGEND**
- WATER DISTRIBUTION VALVE
 - WATER MAIN LINE
 - FIRE HYDRANT
 - WATER SERVICE CONNECTION
 - 4" GRAVITY SEWER SERVICE STUB
 - 23 LOT NUMBER
 - LIFT STATION
 - MANHOLE
 - PRESSURE SEWER MAIN
 - 8" GRAVITY SEWER MAIN

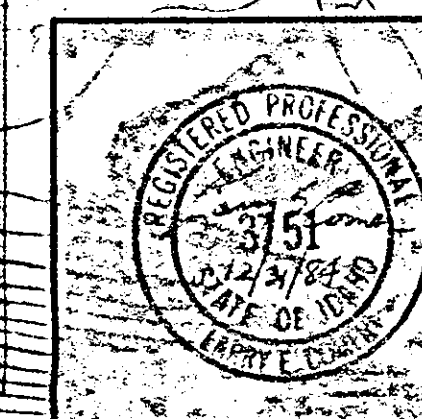

REVISED 12/21/84

Harbor View Estates

PLAN AND PROFILE


V. David Welch Associates, Inc.
ENGINEERING SURVEYING
SANDPOINT & COEUR D'ALENE, IDAHO

Drawn by: JKO Date: 11-84 Sheet: 2 of 22
Checked by: Scale: AS NOTED



RECORD DRAWING CERTIFICATION

THE WATER AND SEWER UTILITIES
DEPICTED IN THIS DRAWING HAVE BEEN
CONSTRUCTED AND TESTED IN ACCORDANCE
WITH THE PROJECT SPECIFICATIONS. NOTE
THAT REVISIONS HAVE NOT BEEN DISCLOSED
FOR WATER UTILITY BY EARRY POWER.

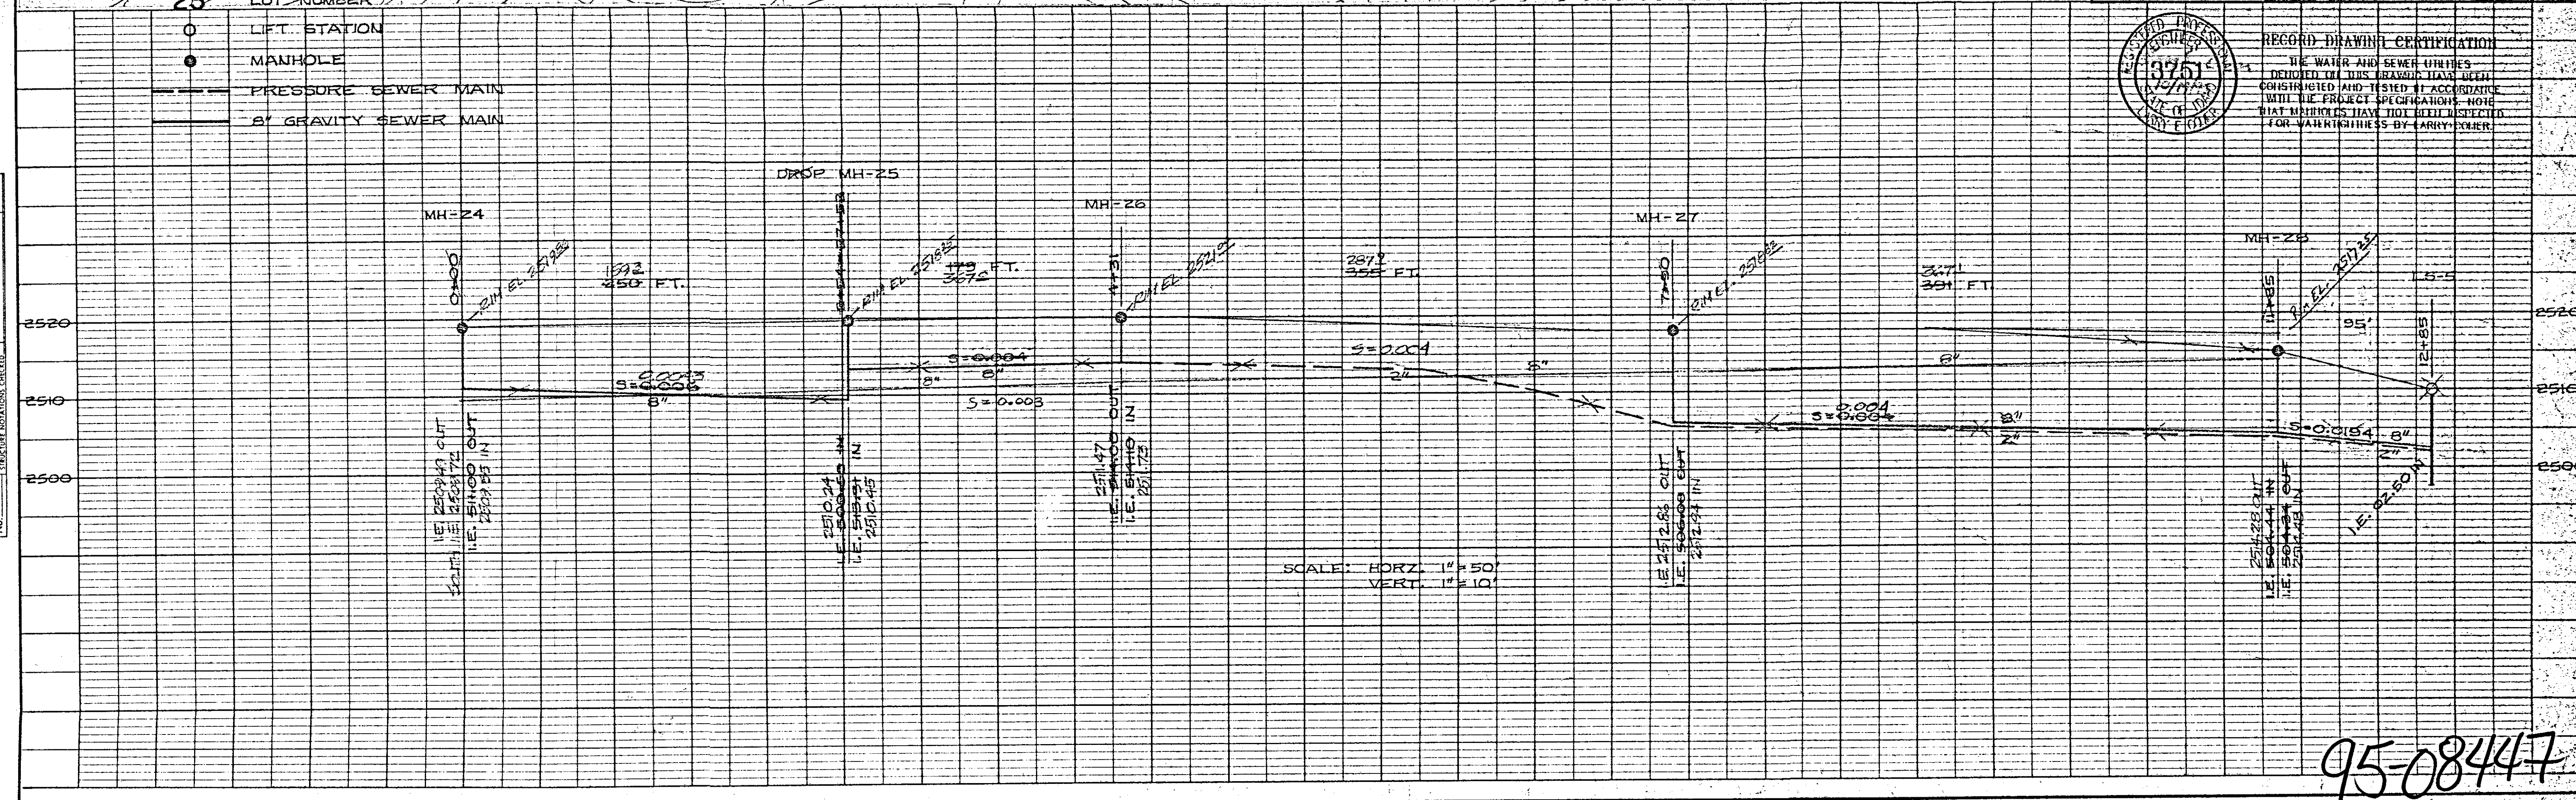

95-08447

